 
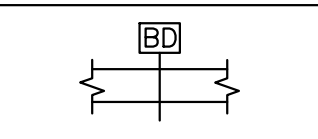
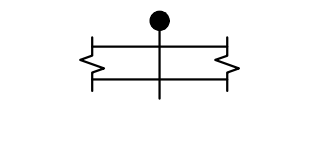
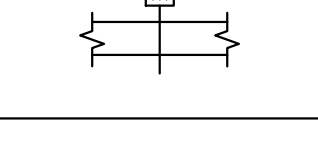
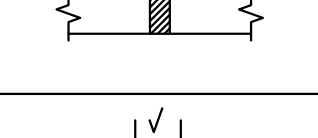
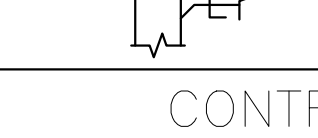




MECHANICAL SYMBOLS LIST

		EQUIPMENT SYMBOL
---	---	------------------








DUCT ACCESSORIES

	BACKDRAFT DAMPER
	FIRE DAMPER W/ ACCESS DOOR
	MOTORIZED DAMPER W/ ACCESS DOOR
	DUCT HEATER W/ ACCESS DOOR
	VOLUME DAMPER W/ ACCESS DOOR

  CONTROLS AND SENSORS

	THERMOSTAT
	TEMPERATURE SENSOR

       DUCTWORK

	RECTANGULAR DUCT (WIDTH X DEPTH)
	AIR DUCT W/ 1.5" ACOUSTICAL LINING
	FLEXIBLE CONNECTION
	ROUND DUCT (DIAMETER)
	ROUND DUCT CROSS SECTION
	SUPPLY AIR RECTANGULAR DUCT GOING UP/DOWN
	RETURN AIR RECTANGULAR DUCT GOING UP/DOWN

MECHANICAL ABBREVIATIONS

AFF	ABOVE FINISHED FLOOR
AL	ACOUSTIC LINING
BD	BACKDRAFT DAMPER
CFM	CUBIC FEET OF AIR PER MINUTE
CD	CONDENSATE DRAIN PIPE
DN	DOWN
EER	ENERGY EFFICIENCY RATIO
FC	FLEXIBLE CONNECTION
FD/AD	FIRE DAMPER W/ACCESS DOOR
FD	FIRE DAMPER W/FUSIBLE LINK
IEER	INTEGRATED ENERGY EFFICIENCY RATIO
TEF	TOILET EXHAUST FAN
KEF	TOILET EXHAUST FAN
MAU	MAKEUP AIR UNIT
EDH	ELECTRIC DUCT HEATER
SEER	SEASONAL ENERGY EFFICIENCY RATIO
CU	CONDENSING UNIT
CDS	CEILING DIFFUSER SUPPLY
CDR	CEILING DIFFUSER RETURN
RG	RETURN GRILLE

NEW JERSEY BUILDING DEPARTMENT NOTES

- ALL WORK SHALL COMPLY WITH APPLICABLE SECTIONS OF THE NEW JERSEY BUILDING CODE, EFFECTIVE JULY 1, 2020 AND ALL AMENDMENTS AND RULES AND REGULATIONS OF THE DEPARTMENT OF BUILDINGS TO DATE.
- THE CONTRACTOR SHALL ENGAGE THE THE SERVICES OF A PROFESSIONAL ENGINEER TO PROVIDE THE REQUIRED SPECIAL INSPECTIONS AND TESTS.
 - TESTS WILL BE CONDUCTED UNDER DIRECTION OF A LICENSED PROFESSIONAL ENGINEER, ARCHITECT OR OTHER PERSON HAVING NOT LESS THAN FIVE (5) YEARS EXPERIENCE SUPERVISING THE INSTALLATION OF SUCH MECHANICAL SYSTEMS. THE TESTS WILL SHOW COMPLIANCE WITH 2020 BUILDING CODE REQUIREMENTS AS OUTLINES IN SECTION [BC 1704].
 - THE LICENSED PROFESSIONAL ENGINEER, ARCHITECT OR OTHER PERSON HAVING NOT LESS THAN FIVE (5) YEARS EXPERIENCE SUPERVISING THE INSTALLATION OF SUCH MECHANICAL SYSTEMS AND CONDUCTING SUCH TESTS WILL FILE DOCUMENTATION AND REPORTS OF TESTS THAT THE SYSTEM COMPLIES WITH THE CONSTRUCTION DOCUMENTS AND APPLICABLE LAWS.
 - TESTS OF MECHANICAL SYSTEMS SHALL BE PERFORMED IN ACCORDANCE WITH THE FOLLOWING SECTIONS OF THE 2018 INTERNATIONAL MECHANICAL CODE WITH AMENDMENTS (MECHANICAL CODE 2018 OF NEW JERSEY):
 - VENTILATION SYSTEM MC 403
 - REFRIGERATION SYSTEMS MC 1108
 - REFERENCED CODE OR STANDARD:
 - STANDARDS OF HEATING – MC 309.1
 - NOISE CONTROL CODE
 - DUCT CONSTRUCTION AND INSTALLATION– MC 603
 - AIR INTAKES, EXHAUSTS AND RELIEFS – MC 401.5
 - AIR FILTERS – MC 605
 - BOILERS – MC 1004
 - PIPING AND INSULATION – MC 1201–1203 & 1204
 - MINIMUM TEMPERATURE TO BE MAINTAINED IN OCCUPIED SPACES DURING HEATING SEASON: 68 DEG. FAHRENHEIT.
 - VENTILATION FOR ALL AREA SHALL COMPLY WITH MC 401.
 - A STATEMENT SHALL BE FILED BY THE OWNER OR TENANT IN POSSESSION THAT THE VENTILATION SYSTEM WILL BE KEPT IN CONTINUOUS OPERATION AT ALL TIMES DURING THE NORMAL OCCUPANCY OF THE STRUCTURE AS REQUIRED BY IMC 2018 (MECHANICAL CODE 2018 OF NEW JERSEY), SECTION 403.3.
 - THESE PLANS ARE APPROVED ONLY FOR THE WORK INDICATED ON THE APPLICATION SPECIFICATION SHEET. ALL OTHER MATTERS SHOWN ARE NOT TO BE RELIED UPON OR TO BE CONSIDERED AS EITHER BEING APPROVED OR IN ACCORDANCE WITH APPLICABLE CODES.
 - SMOKE DETECTOR SHALL MEET UL268A.
 - ALL HEATING AND COOLING LOADS CALCULATED PER ASHRAE/ACCA 183.
 - THESE PLANS ARE APPROVED ONLY FOR THE WORK INDICATED ON THE APPLICATION SPECIFICATION SHEET. ALL OTHER MATTERS SHOWN ARE NOT TO BE RELIED UPON OR TO BE CONSIDERED AS EITHER BEING APPROVED OR IN ACCORDANCE WITH APPLICABLE CODES.
 - REFER TO ARCHITECTURAL DRAWINGS FOR REQUIRED FIRE–RATED WALL AND SMOKE WALL CONSTRUCTION AND LOCATION.
 - THESE PLANS ARE APPROVED ONLY FOR THE WORK INDICATED ON THE APPLICATION SPECIFICATION SHEET. ALL OTHER MATTERS SHOWN ARE NOT TO BE RELIED UPON OR TO BE CONSIDERED AS EITHER BEING APPROVED OR IN ACCORDANCE WITH APPLICABLE CODES.
 - SMOKE DETECTOR SHALL MEET UL268A.
 - THESE PLANS ARE APPROVED ONLY FOR THE WORK INDICATED ON THE APPLICATION SPECIFICATION SHEET. ALL OTHER MATTERS SHOWN ARE NOT TO BE RELIED UPON OR TO BE CONSIDERED AS EITHER BEING APPROVED OR IN ACCORDANCE WITH APPLICABLE CODES.
 - RECORD DRAWINGS SHALL BE SUBMIT TO THE BUILDING OWNER WITHIN 90 DAYS AFTER THE DATE OF SYSTEM ACCEPTANCE AS PER ASHRAE 90.1 2016 6.7.2.1.

MECHANICAL DRAWING LIST

M0.1	TITLE SHEET, SYMBOLS, ABBREVIATIONS AND NOTES (1 OF 3)
M0.2	MECHANICAL SPECIFICATIONS (2 OF 3)
M0.3	MECHANICAL SPECIFICATIONS (3 OF 3)
M1.0	MECHANICAL FLOOR PLANS
M5.0	MECHANICAL DETAILS
M6.0	MECHANICAL SCHEDULES
M7.0	HOOD DETAILS

GENERAL NOTES

- CONTRACTOR SHALL SURVEY THE AREA OF THIS WORK BEFORE SUBMITTING A BID AND SHALL BE RESPONSIBLE FOR NOTIFYING THE ARCHITECT OF ANY CONDITIONS WHICH WOULD PREVENT THE INSTALLATION OF THE WORK AS SHOWN ON DRAWINGS.
- ALL APPLICABLE CODES, LAWS AND REGULATIONS GOVERNING OR RELATING TO ANY PORTION OF THIS WORK ARE HEREBY INCORPORATED INTO AND MADE A PART OF THESE SPECIFICATIONS, AND THEIR PROVISIONS SHALL BE CARRIED OUT BY THE CONTRACTOR WHO SHALL INFORM THE OWNER, PRIOR TO SUBMITTING A PROPOSAL, OF ANY WORK OR MATERIALS WHICH VIOLATE ANY OF THE ABOVE LAWS AND REGULATIONS. ANY WORK DONE BY THE CONTRACTOR CAUSING SUCH VIOLATION SHALL BE CORRECTED BY THE CONTRACTOR.
- BEFORE PROCEEDING WITH ANY WORK IN OCCUPIED OR USED AREAS, THE CONTRACTOR SHALL APPLY TO OWNER FOR PERMISSION TO ENTER SUCH AREAS. THE CONTRACTOR IS OBLIGED TO PERFORM HIS WORK ONLY AT THE TIMES DESIGNATED BY OWNER. THERE WILL BE NO ADDITIONAL COMPENSATION FOR THE WORK PERFORMED AFTER HOURS OR ON OFF–DAYS WITHOUT PRIOR WRITTEN APPROVAL.
- THE WORK IN THE BUILDING SHALL BE DONE WHEN AND AS DIRECTED, AND IN A MANNER SATISFACTORY TO THE OWNER. THE WORK SHALL BE PERFORMED SO AS TO CAUSE THE LEAST POSSIBLE INCONVENIENCE AND DISTURBANCE TO THE PRESENT OCCUPANTS.
- THE CONTRACTOR'S PROPOSAL FOR ALL WORK SHALL BE PREDICATED ON THE PERFORMANCE OF THE WORK DURING REGULAR WORKING HOURS. WHEN SO DIRECTED, HOWEVER, THE CONTRACTOR SHALL INSTALL WORK IN OVERTIME AND THE ADDITIONAL COST TO BE CHARGED THEREFORE SHALL BE ONLY THE "PREMIUM" PORTION OF THE WAGES PAID.
- CONTRACTOR SHALL ASCERTAIN THE APPROPRIATE METHOD FOR BRINGING THE UNITS INTO AND THROUGH THE BUILDING TO POSITION UNIT IN LOCATION SHOWN ON THE PLANS. WHERE NECESSARY, EQUIPMENT SHALL BE SHIPPED FROM MANUFACTURER IN SECTIONS OF SIZE SUITABLE FOR MOVING THROUGH RESTRICTIVE SPACES. COORDINATE WITH BUILDING OWNER APPROPRIATE TIMES OF DAY SUCH EQUIPMENT MAY BE MOVED THROUGH ALL AREAS.
- DUCTWORK AND PIPING IS SHOWN DIAGRAMMATICALLY AND DOES NOT SHOW ALL OFFSETS, DROPS AND RISES OF RUNS. THE CONTRACTOR SHALL MAKE ALLOWANCE IN PRICING FOR ROUTING OF DUCTWORK AND PIPING TO AVOID OBSTRUCTIONS. EXACT LOCATIONS ARE SUBJECT TO APPROVAL OF ARCHITECT. COORDINATION WITH THE OTHER TRADES IS REQUIRED.
- SUPPORT ALL DUCTWORK AND PIPING FROM BUILDING STRUCTURE AND/OR FRAMING IN AN APPROVED MANNER. WHERE OVERHEAD CONSTRUCTION DOES NOT PERMIT FASTENING OR SUPPORTS FOR EQUIPMENT, FURNISH ADDITIONAL FRAMING. INSERTS SHALL BE STEEL, SLOTTED TYPE AND FACTORY PAINTED. SINGLE ROD SHALL BE SIMILAR TO GRINNELL FIG. 281. MULTI-ROD SHALL BE SIMILAR TO FEE & MASON SERIES 9000 WITH END CAPS AND CLOSURE STRIPS. MAXIMUM LOADING INCLUDING PIPES, DUCTWORK CONTENTS AND COVERING SHALL NOT EXCEED 75% OF RATED INSERT CAPABILITY. WHEN SUPPORTING FROM BUILDING USE BEAM CLAMPS IN APPROVED MANNER.
- PROVIDE ALL NECESSARY FLASHING AND COUNTER FLASHING TO MAINTAIN THE WATERPROOFING INTEGRITY OF THIS BUILDING. AS REQUIRED BY THE INSTALLATION OR REMOVAL OF PIPES, DUCTS, LOUVERS, CONDUIT, AND EQUIPMENT. PROVIDE EQUIPMENT CURBS AND DUNNAGE STEEL AS REQUIRED.
- SEAL OPENINGS AROUND DUCTS AND PIPING THROUGH PARTITIONS, WALLS AND FLOORS (NOT IN SHAFTS) WITH MINERAL WOOL OR OTHER NONCOMBUSTIBLE MATERIAL (FIBERGLASS INSULATION IS NOT ACCEPTABLE).
- WHERE PENETRATIONS THROUGH FIRE RATED WALLS ARE NOT FIRE PROOFED THIS CONTRACTOR SHALL BE RESPONSIBLE TO SEAL SAME TO MAINTAIN THE RATED INTEGRITY.
- INSTALL WORK SO AS TO BE READILY ACCESSIBLE FOR OPERATION, MAINTENANCE AND REPAIR. MINOR DEVIATIONS FROM DRAWINGS MAY BE MADE TO ACCOMPLISH THIS, BUT CHANGES WHICH INVOLVE EXTRA COST SHALL NOT BE MADE WITHOUT APPROVAL.
- ACCESS DOORS ARE REQUIRED FOR ALL BUILDING SERVICE VALVES THAT RUN THROUGH THE SPACE, AND ACCESS DOOR SHALL HAVE THE EQUAL RATED CAPACITY (1HR, 2HR, ETC.) AS WALL. COORDINATE ALL LOCATIONS OF ACCESS DOORS WITH THE ARCHITECT.
- REMOVABLE ACCESS TILE AND/OR ACCESS DOOR ARE REQUIRED IN HUNG CEILINGS, SHAFTS AND WALLS FOR ALL VOLUME AND FIRE DAMPERS, AUTOMATIC DAMPERS AND ALL OTHER MECHANICAL EQUIPMENT AND DEVICES. HVAC CONTRACTOR TO FURNISH ACCESS LOCATION REQUIREMENTS TO GENERAL CONTRACTOR. ACCESS TILE IDENTIFICATION: PROVIDE BUTTONS, TABS, AND MARKERS TO IDENTIFY LOCATION OF CONCEALED VALVES, DAMPERS AND EQUIPMENT.
- THE CONTRACTOR SHALL KEEP ALL EQUIPMENT AND MATERIALS, AND ALL PARTS OF THE BUILDING, EXTERIOR SPACES AND ADJACENT STREETS, SIDEWALKS AND PAVEMENTS, FREE FROM MATERIAL AND DEBRIS RESULTING FROM THE EXECUTION OF THIS WORK. EXCESS MATERIALS WILL NOT BE PERMITTED TO ACCUMULATE EITHER ON THE INTERIOR OR THE EXTERIOR.
- MATERIALS AND WORKMANSHIP, UNLESS OTHERWISE NOTED, SHALL BE IN ACCORDANCE WITH BUILDING STANDARDS.
- ALL EQUIPMENT SHALL BE PROVIDED WITH ONE YEAR WARRANTY PARTS AND LABOR AND FIVE YEARS ON COMPRESSORS. WARRANTY PERIOD BEGINS UPON PROJECT ACCEPTANCE
- ALL MATERIAL AND EQUIPMENT TO BE NEW UNLESS OTHERWISE NOTED AND SHALL BE IN ACCORDANCE WITH BUILDING STANDARDS.
- THE CONTRACTOR SHALL BE RESPONSIBLE FOR HIS WORK WITH ITS COMPLETION AND FINAL ACCEPTANCE AND SHALL REPLACE ANY OF THE SAME WHICH MAY BE DAMAGED, LOST, OR STOLEN WITHOUT ADDITIONAL COST TO THE OWNER.

- THE CONTRACTOR SHALL BE RESPONSIBLE FOR THE FAILURE OF ANY DUCTWORK SYSTEM OR EQUIPMENT TO FUNCTION PROPERLY UPON COMPLETION OF HIS WORK UPON SAID SYSTEM OR EQUIPMENT.
- SUBMIT SHOP DRAWING OF ALL WORK WHICH MUST BE APPROVED BY THE ARCHITECT AND ENGINEER BEFORE WORK COMMENCES.
- INSURANCE: IN ACCORDANCE WITH BUILDING REQUIREMENTS THE CONTRACTOR SHALL INCLUDE A HOLD HARMLESS CLAUSE FOR OWNER AND ENGINEER.
- THE FINAL ACCEPTANCE WILL BE MADE AFTER THE CONTRACTOR HAS ADJUSTED HIS EQUIPMENT, BALANCED THE VARIOUS SYSTEMS, DEMONSTRATED THAT IT FULFILLS THE REQUIREMENTS OF THE DRAWINGS AND SPECIFICATIONS AND HAS FURNISHED ALL THE REQUIRED CERTIFICATES OF INSPECTION AND APPROVAL.
- SPECIFICATIONS ARE OF SIMPLIFIED FORM AND INCLUDE INCOMPLETE SENTENCES. WORDS OR PHRASES SUCH AS "THE CONTRACTOR SHALL," "SHALL BE," "FURNISH," "PROVIDE," "A," "THE," AND "ALL" HAVE BEEN OMITTED FOR BREVITY.
- WHERE A CONFLICT EXISTS BETWEEN THE DRAWINGS, THE SPECIFICATIONS OR ANY OTHER CONSTRUCTION DOCUMENT, THE ONE WITH THE MOST STRINGENT REQUIREMENT(S) SHALL APPLY.

DEFINITIONS:

- "PROVIDE": TO SUPPLY, INSTALL AND CONNECT UP COMPLETE AND READY FOR SAFE AND REGULAR OPERATION THE PARTICULAR WORK REFERRED TO UNLESS SPECIFICALLY OTHERWISE NOTED.
- "INSTALL": TO ERECT, MOUNT AND CONNECT COMPLETE WITH RELATED ACCESSORIES.
- "FURNISH" OR "SUPPLY": TO PURCHASE, PROCURE, ACQUIRE AND DELIVER COMPLETE WITH RELATED ACCESSORIES.

SCOPE OF WORK

SCOPE OF WORK

- THE WORK UNDER CONTRACT INCLUDES ALL LABOR, MATERIALS AND APPLIANCES NECESSARY FOR THE FURNISHING, INSTALLING AND TESTING, COMPLETE AND READY FOR SAFE OPERATION OF THE SYSTEMS AS DESCRIBED IN THE SPECIFICATIONS, FLOOR PLAN(S) DESIGN, DETAIL DRAWINGS, NOTES, RFI'S, ETC. FOR THIS PROJECT. WORK SHALL BE INSTALLED IN A NEAT, WORKMANLIKE MANNER.
- THE CONTRACTOR SHALL GIVE NECESSARY NOTICE, FILE DRAWINGS AND SPECIFICATIONS WITH THE DEPARTMENT HAVING JURISDICTION, OBTAIN PERMITS OR LICENSES NECESSARY TO CARRY OUT THIS WORK AND PAY ALL FEES THEREFORE. THE CONTRACTOR SHALL ARRANGE FOR INSPECTION AND TESTS OF ANY OR ALL PARTS OF THE WORK IF SO REQUIRED BY AUTHORITIES AND PAY ALL CHARGES FOR SAME. THE CONTRACTOR SHALL PAY ALL COSTS FOR AND FURNISH TO THE OWNER BEFORE FINAL BILLING, ALL CERTIFICATES NECESSARY AS EVIDENCE THAT THE WORK INSTALLED CONFORMS WITH ALL REGULATIONS WHERE THEY APPLY TO THIS WORK.
- THE CONTRACTOR SHALL FURNISH A WRITTEN GUARANTEE TO REPAIR OR REPAIR PROMPTLY AND ASSUME RESPONSIBILITY FOR ALL EXPENSES INCURRED FOR ANY WORKMANSHIP AND EQUIPMENT IN WHICH DEFECTS DEVELOP WITHIN ONE YEAR FROM THE DATE OF FINAL CERTIFICATE FOR PAYMENT AND/OR FROM DATE OR ACTUAL USE OF EQUIPMENT OR OCCUPANCY OF SPACES, BY OWNER, INCLUDED UNDER THE VARIOUS PARTS OF THE WORK, WHICHEVER DATE IS EARLIER. THIS WORK SHALL BE DONE AS DIRECTED BY THE OWNER. THIS GUARANTEE SHALL ALSO PROVIDE THAT WHERE DEFECTS OCCUR, THE CONTRACTOR WILL ASSUME RESPONSIBILITY FOR ALL EXPENSES INCURRED IN REPAIRING AND REPLACING WORK OF OTHER TRADES AFFECTED BY DEFECTS, REPAIRS OR REPLACEMENTS IN EQUIPMENT SUPPLIED BY THE CONTRACTOR.

GENERAL HVAC NOTES

- PROVIDE ALL MATERIAL AND EQUIPMENT AND PERFORM ALL LABOR REQUIRED TO INSTALL COMPLETE AND OPERABLE MECHANICAL SYSTEMS AS INDICATED ON THE DRAWINGS, AS SPECIFIED AND AS REQUIRED BY CODE.
- CONTRACT DOCUMENT DRAWINGS FOR MECHANICAL WORK (HVAC, PLUMBING, AND FIRE PROTECTION) ARE DIAGRAMMATIC AND ARE INTENDED TO CONVEY SCOPE AND GENERAL ARRANGEMENT ONLY.
- THE LOCATIONS OF ALL ITEMS SHOWN ON THE DRAWINGS OR CALLED FOR IN THE SPECIFICATIONS THAT ARE NOT FIXED BY DIMENSIONS ARE APPROXIMATE ONLY. THE EXACT LOCATIONS NECESSARY TO SECURE THE BEST CONDITIONS AND RESULTS MUST BE DETERMINED BY THE PROJECT SITE CONDITIONS AND SHALL HAVE THE APPROVAL OF THE ENGINEER BEFORE BEING INSTALLED. DO NOT SCALE DRAWINGS.
- WHEN MECHANICAL WORK (HVAC, PLUMBING, SHEET METAL, FIRE PROTECTION, ETC.) IS SUBCONTRACTED, IT SHALL BE THE MECHANICAL CONTRACTOR'S RESPONSIBILITY TO COORDINATE SUBCONTRACTORS AND THE ASSOCIATED CONTRACTS. WHEN DISCREPANCIES ARISE PERTAINING TO WHICH CONTRACTOR PROVIDES A PARTICULAR ITEM OF THE MECHANICAL CONTRACT OR WHICH CONTRACTOR PROVIDES FINAL CONNECTIONS FOR A PARTICULAR ITEM OF THE MECHANICAL CONTRACT, IT SHALL BE BROUGHT TO THE ATTENTION OF THE MECHANICAL CONTRACTOR, WHOSE DECISION SHALL BE FINAL.
- COORDINATE CONSTRUCTION OF ALL MECHANICAL WORK WITH ARCHITECTURAL, STRUCTURAL, CIVIL, ELECTRICAL WORK, ETC., SHOWN ON OTHER CONTRACT DOCUMENT DRAWINGS.
- INSTALL ALL MECHANICAL EQUIPMENT AND APPURTENANCES IN ACCORDANCE WITH MANUFACTURER'S RECOMMENDATIONS, CONTRACT DOCUMENTS, AND APPLICABLE CODES AND REGULATIONS.
- WHERE TWO OR MORE ITEMS OF THE SAME TYPE OF EQUIPMENT ARE REQUIRED, THE PRODUCT OF ONE MANUFACTURER SHALL BE USED.

8. COORDINATE ALL EQUIPMENT CONNECTIONS WITH MANUFACTURERS' CERTIFIED DRAWINGS. COORDINATE AND PROVIDE ALL DUCT AND PIPING TRANSITIONS REQUIRED FOR FINAL EQUIPMENT CONNECTIONS TO FURNISHED EQUIPMENT. FIELD VERIFY AND COORDINATE ALL DUCT AND PIPING DIMENSIONS BEFORE FABRICATION.
9. ALL CONTROL WIRE AND CONDUIT SHALL COMPLY WITH THE NATIONAL ELECTRIC CODE AND ELECTRICAL DIVISION OF THE SPECIFICATION.
10. PROVIDE VIBRATION ISOLATION FOR ALL MECHANICAL EQUIPMENT TO PREVENT TRANSMISSION OF VIBRATION TO BUILDING STRUCTURE.
11. PROVIDE VIBRATION ISOLATORS FOR ALL PIPING SUPPORTS CONNECTED TO, AND WITHIN 50 FT. OF, ISOLATED EQUIPMENT (EXCEPT AT BASE ELBOW SUPPORTS AND ANCHOR POINTS).
12. LOCATE ALL TEMPERATURE, PRESSURE, AND FLOW MEASURING DEVICES IN ACCESSIBLE LOCATIONS WITH THE STRAIGHT SECTION OF PIPE OR DUCT UP- AND DOWNSTREAM AS RECOMMENDED BY THE MANUFACTURER FOR GOOD ACCURACY.
13. WHERE BEAMS ARE INDICATED TO BE PENETRATED WITH DUCTWORK OR PIPING, COORDINATE DUCTWORK AND PIPING LAYOUT WITH BEAM OPENING SIZE AND OPENING LOCATIONS. COORDINATION SHALL BE DONE PRIOR TO THE FABRICATION OF DUCTWORK, CUTTING OF PIPING, OR FABRICATION OF BEAMS.
14. ALL MISCELLANEOUS STEEL REQUIRED TO ENSURE PROPER INSTALLATION AND AS SHOWN IN THE DETAILS FOR PIPING, DUCTWORK, AND EQUIPMENT (UNLESS OTHERWISE NOTED) SHALL BE FURNISHED AND INSTALLED BY THE MECHANICAL CONTRACTOR.
15. PROVIDE ACCESS PANELS FOR INSTALLATION IN WALLS AND CEILINGS, WHERE REQUIRED, TO SERVICE DAMPERS, VALVES, SMOKE DETECTORS, AND OTHER CONCEALED MECHANICAL EQUIPMENT. ACCESS PANELS SHALL BE TURNED OVER TO THE GENERAL CONTRACTOR FOR INSTALLATION. ACCESS PANELS SHALL HAVE THE EQUAL RATED CAPACITY (1HR, 2HR, ETC.) AS WALL.
16. MECHANICAL EQUIPMENT, DUCTWORK, AND PIPING SHALL NOT BE SUPPORTED FROM A METAL DECK.
17. ALL EQUIPMENT, PIPING, DUCTWORK, ETC., SHALL BE SUPPORTED AS DETAILED, SPECIFIED AND REQUIRED TO PROVIDE A VIBRATION-FREE INSTALLATION.
18. ALL DUCTWORK, PIPING, AND EQUIPMENT SUPPORTED FROM STRUCTURAL STEEL SHALL BE COORDINATED WITH THE GENERAL CONTRACTOR. ALL ATTACHMENTS TO STEEL BAR JOISTS, TRUSSES, OR JOIST GIRDERS SHALL BE AT PANEL POINTS. PROVIDE BEAM CLAMPS MEETING MSS STANDARDS. WELDING TO STRUCTURAL MEMBERS SHALL NOT BE PERMITTED. THE USE OF C-CLAMPS SHALL NOT BE PERMITTED.
19. ALL ROOF-MOUNTED EQUIPMENT CURBS/STEEL RAILS FOR EQUIPMENT PROVIDED BY THE MECHANICAL CONTRACTOR SHALL BE FURNISHED BY THE MECHANICAL CONTRACTOR AND INSTALLED BY THE GENERAL CONTRACTOR.
20. LOCATIONS AND SIZES OF ALL FLOOR, WALL, AND ROOF OPENINGS SHALL BE COORDINATED WITH ALL OTHER TRADES INVOLVED.
21. ALL OPENINGS IN FIRE WALLS DUE TO DUCTWORK, PIPING, CONDUIT, ETC., SHALL BE FIRE STOPPED WITH A PRODUCT SIMILAR TO 3M OR APPROVED EQUAL.
22. ALL AIR CONDITIONING CONDENSATE DRAIN LINES FROM EACH AIR HANDLING UNIT SHALL BE PIPED FULL SIZE OF THE UNIT DRAIN OUTLET, WITH "P" TRAP, AND PIPED TO THE NEAREST DRAIN. SEE THE DETAILS SHOWN IN THE DRAWINGS OR THE CONTRACT SPECIFICATIONS FOR THE DEPTH OF THE AIR CONDITIONING CONDENSATE TRAP.
23. REFER TO TYPICAL DETAILS FOR DUCTWORK, PIPING, AND EQUIPMENT INSTALLATION.
24. REINFORCEMENT, DETAILING, AND PLACEMENT OF CONCRETE SHALL CONFORM TO ASTM 315 AND ACI 318. CONCRETE SHALL CONFORM TO ASTM C94. CONCRETE WORK SHALL CONFORM TO ACI 318 PART ENTITLED "CONSTRUCTION REQUIREMENTS". COMPRESSIVE STRENGTH IN 28 DAYS SHALL BE 3,000 PSI. TOTAL AIR CONTENT OR EXTERIOR CONCRETE SHALL BE BETWEEN 5 AND 7 PERCENT BY VOLUME. SLUMP SHALL BE BETWEEN 3 AND 4 IN. CONCRETE SHALL BE CURED FOR 7 DAY AFTER PLACEMENT.
25. CONCRETE HOUSEKEEPING PADS TO SUIT MECHANICAL EQUIPMENT SHALL BE SIZED AND LOCATED BY THE MECHANICAL CONTRACTOR. MINIMUM CONCRETE PAD THICKNESS SHALL BE 6 IN. PAD SHALL EXTEND BEYOND THE EQUIPMENT A MINIMUM OF 6 IN. ON EACH SIDE. CONCRETE HOUSEKEEPING PADS SHALL BE PROVIDED BY THE GENERAL CONTRACTOR. IT SHALL BE THE RESPONSIBILITY OF THE MECHANICAL CONTRACTOR TO COORDINATE THE SIZE AND LOCATION OF CONCRETE HOUSEKEEPING PADS WITH THE GENERAL CONTRACTOR.
26. ALL TESTS SHALL BE COMPLETED BEFORE ANY MECHANICAL EQUIPMENT OR PIPING INSULATION IS APPLIED.
27. TESTING, ADJUSTING, AND BALANCING AGENCY SHALL BE A MEMBER OF THE ASSOCIATED AIR BALANCE COUNCIL (AABC) OR THE NATIONAL ENVIRONMENTAL BALANCING BUREAU (NEBB). TESTING, ADJUSTING, AND BALANCING SHALL BE PERFORMED IN ACCORDANCE WITH THE AABC STANDARDS.

HVAC DUCTWORK – SHEET METAL

1. CERTAIN ITEMS SUCH AS RISES AND DROPS IN DUCTWORK/ACCESS DOORS, VOLUME DAMPERS, ETC., ARE INDICATED ON THE CONTRACT DOCUMENT DRAWINGS FOR CLARITY FOR A SPECIFIC LOCATION REQUIREMENT AND SHALL NOT BE INTERPRETED AS THE EXTENT OF THE REQUIREMENTS FOR THESE ITEMS.
2. ALL NEW DUCTWORK WILL COMPLY WITH THE LATEST SMACNA GUIDELINES AND CONFORM WITH REQUIREMENTS OF THE LATEST HANDBOOKS PUBLISHED BY ASHRAE.

3. PROVIDE VOLUME DAMPER AT EACH TAP TO MAIN DUCT AND WHERE NECESSARY TO PROPERLY BALANCE SYSTEM.
4. SUPPLY AND RETURN DUCTWORK OF ALL AC UNITS SHALL BE LINED WITH 1.5" INSULATION HAVING ACOUSTIC AND THERMAL PROPERTIES.
5. CONTRACTOR SHALL SUPPLY AND INSTALL ALL NECESSARY SUPPLY DIFFUSERS AND RETURN AIR REGISTERS WHERE INDICATED ON THE DRAWING. COORDINATE LOCATION OF DIFFUSERS AND REGISTERS WITH REFLECTED CEILING PLAN.
6. IN CORRIDORS WHERE CEILING SPEAKERS AND AIR DIFFUSERS ARE INDICATED BETWEEN THE SAME LIGHT FIXTURES, INSTALL BOTH DEVICES AT THE QUARTER POINTS BETWEEN THE FIXTURES.
7. UNLESS OTHERWISE SHOWN, LOCATE ALL ROOM THERMOSTATS (CENTER LINE) ABOVE THE FINISHED FLOOR. NOTIFY THE ENGINEER OF ANY ROOMS WHERE THE PRECEDING LOCATION CANNOT BE MAINTAINED OR WHERE THERE IS A QUESTION ON LOCATION.
8. ALL DUCTWORK SHALL CLEAR DOORS AND WINDOWS.
9. ALL DUCTWORK DIMENSIONS, AS SHOWN ON THE DRAWINGS, ARE INTERNAL CLEAR DIMENSIONS AND DUCT SIZE SHALL BE INCREASED TO COMPENSATE FOR DUCT LINING THICKNESS.
10. PROVIDE ALL 90-DEGREE SQUARE ELBOWS WITH DOUBLE RADIUS TURNING VANES UNLESS OTHERWISE INDICATED. ELBOWS IN KITCHEN, AND LAUNDRY EXHAUSTS SHALL BE OF UN-VANED SMOOTH RADIUS CONSTRUCTION WITH A RADIUS EQUAL TO 1-1/2 TIMES THE WIDTH OF THE DUCT. PROVIDE ACCESS DOORS UPSTREAM OF ALL ELBOWS WITH TURNING VANES.
11. COORDINATE DIFFUSER AND GRILLE LOCATIONS WITH ARCHITECTURAL REFLECTED CEILING PLANS, LIGHTING, AND OTHER CEILING ITEMS AND MAKE MINOR DUCT MODIFICATIONS TO SUIT.
12. FIELD-ERECTED AND FACTORY-ASSEMBLED AIR HANDLING UNIT COILS SHALL BE ARRANGED FOR REMOVAL FROM THE UPSTREAM SIDE WITHOUT DISMANTLING SUPPORTS. PROVIDE GALVANIZED STRUCTURAL STEEL SUPPORTS FOR ALL COILS (EXCEPT THE LOWEST COIL) IN BANKS OVER TWO COILS HIGH TO PERMIT THE INDEPENDENT REMOVAL OF ANY COIL.
13. ALL AIR HANDLING UNITS SHALL OPERATE WITHOUT MOISTURE CARRYOVER.
14. LOCATE ALL MECHANICAL EQUIPMENT (SINGLE DUCT, CONSTANT VOLUME, ETC.) FOR UNOBSTRUCTED ACCESS TO UNIT ACCESS PANELS, CONTROLS, AND VALVING.
15. PROVIDE FLEXIBLE CONNECTIONS IN ALL DUCTWORK SYSTEMS (SUPPLY, RETURN, AND EXHAUST) CONNECTED TO AIR HANDLING UNITS, FANS, AND OTHER EQUIPMENT THAT REQUIRE VIBRATION ISOLATION. FLEXIBLE CONNECTIONS SHALL BE PROVIDED AT THE POINT OF CONNECTION TO THE EQUIPMENT UNLESS OTHERWISE INDICATED.
16. UNLESS OTHERWISE NOTED, ALL DUCTWORK IS OVERHEAD, TIGHT TO THE UNDERSIDE OF THE STRUCTURE, WITH SPACE FOR INSULATION IF NEEDED.
17. ALL DUCTWORK SHALL BE COORDINATED WITH ALL TRADES INVOLVED. OFFSETS IN DUCTS, INCLUDING DIVIDED DUCTS AND TRANSITIONS AROUND OBSTRUCTIONS, SHALL BE PROVIDED AT NO ADDITIONAL COST TO THE OWNER.
18. PROVIDE ACCESS DOORS IN DUCTWORK TO PROVIDE ACCESS FOR ALL SMOKE DETECTORS, FIRE DAMPERS, SMOKE DAMPERS, VOLUME DAMPERS, AND OTHER ITEMS LOCATED IN THE DUCTWORK THAT REQUIRE SERVICE AND/OR INSPECTION.
19. PROVIDE ACCESS DOORS IN DUCTWORK FOR THE OPERATION, ADJUSTMENT, AND MAINTENANCE OF ALL FANS, VALVES, AND MECHANICAL EQUIPMENT.
20. ALL DUCTS SHALL BE GROUNDED ACROSS FLEXIBLE CONNECTIONS WITH FLEXIBLE COPPER GROUNDING STRAPS. GROUNDING STRAPS SHALL BE BOLTED OR SOLDERED TO BOTH THE EQUIPMENT AND THE DUCT.
21. SMOKE DETECTORS SHALL BE FURNISHED AND WIRED BY THE ELECTRICAL CONTRACTOR. THE MECHANICAL CONTRACTOR SHALL BE RESPONSIBLE FOR MOUNTING THE SMOKE DETECTOR IN DUCTWORK AS SHOWN ON THE DRAWINGS AND IN ACCORDANCE WITH THE MANUFACTURER'S PRINTED INSTRUCTIONS.
22. SEE SPECIFICATIONS FOR DUCTWORK GAUGES, BRACING, HANGERS, AND OTHER REQUIREMENTS.
23. EXCEPT AS OTHERWISE SHOWN OR NOTED, ALL DUCTWORK AND OTHER SHEET METAL WORK SHALL BE GALVANIZED SHEET STEEL AND SHALL BE INSTALLED IN ACCORDANCE WITH THE LATEST EDITION OF SHEET METAL AND AIR CONDITIONING CONTRACTORS' NATIONAL ASSOCIATION, INC. DUCT CONSTRUCTION STANDARDS, PRESSURE CLASSIFICATION 2 IN. W.G.
- DUCTWORK STATIC PRESSURE CLASSIFICATION:
a. 2 IN OF W.G. UP TO 2 IN OF W.G.
b. 6 IN OF W.G. ABOVE 2 IN & UP TO 6 IN W.G
24. SEALING OF DUCTWORK SHALL COMPLY WITH SECTION 603.9 OF THE MECHANICAL CODE OF INDIANA STATE OR THE NEW YORK STATE CONSTRUCTION CODES.
25. VOLUME DAMPERS: GALVANIZED STEEL, PER SMACNA "LOW VELOCITY MANUAL," EXCEPT PROVIDE BEARING AT ONE END OF DAMPER ROD AND QUADRANT, WITH LEVER AND LOCKSCREW AT OTHER END. FOR INSULATED DUCTS, QUADRANTS MOUNTED ON COLLAR TO CLEAR INSULATION. INSTALL WITH LEVERS ACCESSIBLE.
26. ACCESS DOORS: INSULATED OR UNINSULATED, SAME AS DUCT.

- 1) PROVIDE MINIMUM 20 IN. X 20 IN. (OR EQUIVALENT) ON ALL DUCTS, UNLESS OTHERWISE APPROVED, AT FIRE DAMPERS, AND AT ALL DUCT ACCESSORIES SUCH AS

VIBRATION ISOLATION

A. GENERAL:

- 1) PROVIDE ISOLATION FOR EQUIPMENT, PIPING AND DUCTWORK.
- 2) INSTALL IN ACCORDANCE WITH MANUFACTURER'S INSTRUCTIONS.
- 3) PROVIDE LEVELING DEVICES AND APPROVED RESILIENT RESTRAINING DEVICES AS REQUIRED TO LIMIT EQUIPMENT AND PIPING MOTION IN EXCESS OF 1/4".
- 4) ACCEPTABLE MANUFACTURERS:

a. MASON INDUSTRIES, INC.

b. VIBRATION ELIMINATOR CO.

c. KORFUND DYNAMICS CORP.

B. CEILING-HUNG FANS AND EQUIPMENT:

- 1) PROVIDE SPRING HANGER ROD ISOLATORS. STEEL COMPRESSION SPRING AND NEOPRENE SOUND PAD WITHIN A STEEL RETAINER BOX. SIMILAR TO MASON TYPE PCHS.
 - 2) 1 IN. MINIMUM STATIC DEFLECTION. 1/2 IN. MINIMUM RESERVE DEFLECTION. FACTORY-PRELOADED TO 75% OF RATED LOAD.
 - 3) PROVIDE SUPPLEMENTAL STEEL AS REQUIRED WHERE EQUIPMENT OR STRUCTURE CANNOT SUPPORT POINT LOADS.
- C. FLOOR MOUNTED EQUIPMENT HAVING INTERNAL ISOLATION:
- 1) PROVIDE 5/16 IN.-THICK NEOPRENE ACOUSTICAL BASE PADS OF RIB.

NOISE CONTROL

A. ALL ROOM NC LEVELS SHALL BE 35 OR LESS.

B. PROVIDE SOUND LINING FOR THE FOLLOWING DUCTWORK:

- 1) ALL DUCTWORK WITHIN NOT LESS THAN 20 FT ON EACH SIDE OF ALL FANS AND AC UNITS.
- 2) AIR TRANSFER DUCTS.
- 3) DOWNSTREAM OF ALL CONSTANT VOLUME BOXES FOR A MINIMUM OF 15 FT.
- 4) ALL MIXED AIR PLENUMS.
- 5) FULL EXTENT OF SUPPLY DUCTS SERVING CONFERENCE ROOMS.
- 6) ALL EXPOSED INTERIOR SUPPLY DUCTWORK.
- 7) ALSO WHERE NOTED ON A DRAWING.

C. SOUND LINING IN DUCTWORK: FIBROUS GLASS, MINIMUM 3 LB DENSITY, 1 IN. THICKNESS, MAXIMUM 0.25 K FACTOR AT 75 DEG F MEAN TEMPERATURE WITH ACRYLIC COATED FINISH FACTORY APPLIED EDGE COATING AND STENOILED IN ACCORDANCE WITH NFPA 90. FLAMESPREAD SHALL BE A MAXIMUM OF 25. LINING SHALL NOT SUPPORT MICROBIAL GROWTH AND SHALL BE TESTED IN ACCORDANCE WITH ASTM C 1071 AND ASTM G21/G22. SIMILAR TO MANVILLE PERMACOTE LINA COUSTIC.

D. ALL SOUND LINING, ADHESIVES, FACES AND ACCESSORIES TO BE APPLIED IN ACCORDANCE WITH MANUFACTURER'S RECOMMENDATIONS, EXCEPT AS OTHERWISE NOTED.

THERMOSTATIC CONTROLS:

A. GENERAL:

THE SUPPLY OF HEATING AND COOLING ENERGY TO EACH ZONE SHALL BE INDIVIDUALLY CONTROLLED BY THERMOSTATIC CONTROLS RESPONDING TO TEMPERATURE WITHIN THE ZONE. FOR THE PURPOSES OF SECTION 6.4.3.1, A DWELLING UNIT SHALL BE PERMITTED TO BE CONSIDERED A SINGLE ZONE.

B. DEAD BAND:

WHERE USED TO CONTROL BOTH HEATING AND COOLING, ZONE THERMOSTATIC CONTROLS SHALL BE CAPABLE OF PROVIDING A TEMPERATURE RANGE OR DEAD BAND OF AT LEAST 5°F WITHIN WHICH THE SUPPLY OF HEATING AND COOLING ENERGY TO THE ZONE IS SHUT OFF OR REDUCED TO A MINIMUM.

C. SETBACK CONTROLS:

HEATING SYSTEMS LOCATED IN CLIMATE ZONES 2-8 SHALL BE EQUIPPED WITH CONTROLS THAT HAVE THE CAPABILITY TO AUTOMATICALLY RESTART AND TEMPORARILY OPERATE THE SYSTEM AS REQUIRED TO MAINTAIN ZONE TEMPERATURES ABOVE A HEATING SETPOINT ADJUSTABLE DOWN TO 55°F OR LOWER. COOLING SYSTEMS LOCATED IN CLIMATE ZONES 1B, 2B, AND 3B SHALL BE EQUIPPED WITH CONTROLS THAT HAVE THE CAPABILITY TO AUTOMATICALLY RESTART AND TEMPORARILY OPERATE THE SYSTEM AS REQUIRED TO MAINTAIN ZONE TEMPERATURES BELOW A COOLING SETPOINT ADJUSTABLE UP TO 90°F OR HIGHER OR TO PREVENT HIGH SPACE HUMIDITY LEVELS.

D. AUTOMATIC SHUTDOWN:

HVAC SYSTEMS SHALL BE EQUIPPED WITH AT LEAST ONE OF THE FOLLOWING: CONTROLS THAT CAN START AND STOP THE SYSTEM UNDER DIFFERENT TIME SCHEDULES FOR SEVEN DIFFERENT DAY-TYPES PER WEEK, ARE CAPABLE OF RETAINING PROGRAMMING AND TIME SETTING DURING LOSS OF POWER FOR A PERIOD OF AT LEAST TEN HOURS, AND INCLUDE AN ACCESSIBLE MANUAL OVERRIDE, OR EQUIVALENT FUNCTION, THAT ALLOWS TEMPORARY OPERATION OF THE SYSTEM FOR UP TO TWO HOURS.

E. SETPOINT OVERLAP RESTRICTION:

WHERE HEATING AND COOLING TO A ZONE ARE CONTROLLED BY SEPARATE ZONE THERMOSTATIC CONTROLS LOCATED WITHIN THE ZONE, MEANS (SUCH AS LIMIT SWITCHES, MECHANICAL STOPS, OR, FOR DDC SYSTEMS, SOFTWARE PROGRAMMING) SHALL BE PROVIDED TO PREVENT THE HEATING SETPOINT FROM EXCEEDING THE COOLING SETPOINT MINUS ANY APPLICABLE PROPORTIONAL BAND.

F. HEAT PUMP SUPPLEMENTARY HEAT :

HEAT PUMPS HAVING SUPPLEMENTARY ELECTRIC RESISTANCE HEAT SHALL HAVE CONTROLS THAT, EXCEPT DURING DEFROST, PREVENT SUPPLEMENTARY HEAT OPERATION WHERE THE HEAT PUMP CAN PROVIDE THE HEATING LOAD.

SPECIFICATIONS

SECTION 0001 – NOTICE TO BIDDERS

1.1 BIDDERS REPRESENTATIONS

A. THE BIDDER BY MAKING A BID REPRESENTS THAT:

- A. THE BIDDER HAS READ AND UNDERSTANDS THE BIDDING DOCUMENTS, TO THE EXTENT THAT SUCH DOCUMENTATION RELATES TO THE WORK FOR WHICH THE BID IS SUBMITTED, AND FOR OTHER PORTIONS OF THE PROJECT, IF ANY, BEING BID CONCURRENTLY OR PRESENTLY UNDER CONSTRUCTION.
- B. THE BID IS MADE IN COMPLIANCE WITH THE BIDDING DOCUMENTS.
- C. THE SPECIFICATIONS AND DRAWINGS ARE INTENDED TO SERVE JOINTLY AS A BASIS FOR THE BIDDER TO SUBMIT A CONTRACT PRICE FOR THE MATERIAL AND LABOR.
- D. SHOULD CONFLICTS OR DISCREPANCIES OCCUR WITHIN THE BIDDING DOCUMENTS, THE ITEM OR ITEMS IN DISPUTE THAT REPRESENT THE GREATER COST SHALL PREVAIL IN THE FINAL BID.
- E. THE BID IS BASED UPON THE MATERIALS, EQUIPMENT AND SYSTEMS REQUIRED BY THE BIDDING DOCUMENTS WITHOUT EXCEPTION.

1.2 EXISTING CONDITIONS AND COORDINATION

- A. THE BIDDER HAS VISITED THE SITE, BECOME FAMILIAR WITH LOCAL CONDITIONS UNDER WHICH THE WORK IS TO BE PERFORMED AND HAS CORRELATED THE BIDDER'S PERSONAL OBSERVATIONS WITH THE REQUIREMENTS OF THE PROPOSED BIDDING DOCUMENTS.
 - B. THE BIDDER SHALL PROPOSE COORDINATION OF WORK SUCH THAT CONFLICTS WITH OTHER TRADES AND SPACE ALLOCATIONS ARE AVOIDED.
- 1.3 RESPONSIBILITIES
- A. THE BIDDER UNDERSTANDS THAT ANY CONTRACTOR SHALL BE FULLY RESPONSIBLE FOR THE TIMELY COMPLETION AND ACCEPTANCE OF THEIR WORK AND THAT ANY ITEMS DAMAGED, LOST OR STOLEN DURING TIME OF CONSTRUCTION SHALL BE REPAIRED OR REPLACED WITHOUT ANY ADDITIONAL COST TO THE OWNER.
 - B. THE BIDDER UNDERSTANDS THAT ANY PROPOSED WORK IN OCCUPIED TENANT SPACES SHALL BE PERFORMED DURING TIMES OF NON-TENANT OCCUPANCY OR AS SCHEDULED OR DIRECTED BY THE BUILDING MANAGER.
 - C. THE BIDDER UNDERSTANDS THAT ANY PROPOSED SHUT-DOWN OF EXISTING SYSTEMS DURING CONSTRUCTION SHALL BE PRE-ARRANGED WITH THE BUILDING MANAGER AND THAT SUCH SHUT-DOWNS ARE TO BE KEPT TO A MINIMUM.

END OF SECTION 0001

SECTION 0101 – QUALITY OF WORK

1.1 WORKMANSHIP

- A. ALL WORK SHALL BE FREE FROM DEFECTS IN MATERIALS AND WORKMANSHIP FOR A PERIOD OF ONE YEAR FROM DATE OF FINAL ACCEPTANCE.
- B. ALL DEFECTS WHICH DEVELOP OR ARE DISCOVERED WITHIN THIS PERIOD SHALL BE REPAIRED BY THE CONTRACTOR TO THE SATISFACTION OF THE ARCHITECT OR BUILDING MANAGER AT NO ADDITIONAL COST TO THE OWNER.
- C. UPON COMPLETION OF THE WORK THE CONTRACTOR SHALL REMOVE FROM THE SITE, ALL TOOLS, DEMOLISHED APPLIANCES AND ANY SURPLUS MATERIAL.

1.2 CODE COMPLIANCE

- A. ALL WORK SHALL MEET ALL STATE AND LOCAL CODES HAVING JURISDICTION.

END OF SECTION 0101

SECTION 0102 –REQUIRED DOCUMENTS

1.1 SHOP DRAWINGS

- A. A SET OF PRINTS FOR ANY MECHANICAL WORK INCLUDING BUT NOT LIMITED TO, DUCTWORK AND PIPING LAYOUT SHALL BE SUBMITTED FOR APPROVAL TO THE ENGINEER PRIOR TO CONSTRUCTION OR PURCHASE OF MATERIALS.

1.2 SUBMITTALS

- A. EQUIPMENT SUBMITTALS OF ALL PROPOSED MECHANICAL AND ANCILLARY EQUIPMENT INCLUDING ALL ACCESSORIES SHALL BE SUBMITTED TO THE ENGINEER FOR REVIEW. ALL PERTINENT MODELS, SIZES, ACCESSORIES AND CHOICES SHALL BE CLEARLY CHECKED, PRINTED OR OTHERWISE INDICATED ON THE SUBMITTALS.

1.3 RECORD DRAWINGS

- A. UPON COMPLETION OF THE WORK, A RECORD DRAWING SHALL BE SUBMITTED TO THE OWNER DEPICTING ALL SUBSEQUENT CHANGES, ADDITIONS AND OR CORRECTIONS TO THE CONTRACT DRAWINGS AND OR CONTRACT SCOPE MADE DURING CONSTRUCTION. THIS DRAWING SHALL REPRESENT A COMPLETE RECORD OF THE WORK INSTALLED.

1.4 EQUIPMENT OPERATING INSTRUCTIONS

- A. ON COMPLETION AND ACCEPTANCE OF WORK, THIS CONTRACTOR SHALL FURNISH WRITTEN INSTRUCTIONS, EQUIPMENT MANUALS AND DEMONSTRATE TO THE OWNER THE PROPER OPERATION AND MAINTENANCE OF ALL EQUIPMENT AND APPARATUS FURNISHED UNDER THIS CONTRACT.

- B. THESE INSTRUCTIONS SHALL BE TYPED ON 8-1/2 IN. X 11 IN. PAPER AND BOUND IN THREE-RING BINDERS WITH CLEAR ACETATE COVERS. THE CONTRACTOR SHALL GIVE THREE COPIES OF THE INSTRUCTIONS TO THE OWNER AND ONE ELECTRONIC COPY TO THE ENGINEER.
- C. THE INSTRUCTION BOOKLET SHALL BE ORGANIZED IN SECTIONS, WITH ONE SECTION PER SYSTEM. THE COVER OF THE INSTRUCTION BOOKLET SHALL BEAR THE NAME, ADDRESS AND PHONE NUMBER OF THE PROJECT, ARCHITECT, ENGINEER, MECHANICAL CONTRACTOR AND SUBCONTRACTORS.

END OF SECTION 0102

SECTION 078413-PENETRATION FIRE-STOPPING

1.1 QUALITY ASSURANCE

- A. INSTALLER QUALIFICATIONS: AN FM GLOBAL-APPROVED FIRE-STOP CONTRACTOR OR A UL-QUALIFIED FIRE-STOP CONTRACTOR.
- B. FIRE-TEST-RESPONSE CHARACTERISTICS: UL, INTERTEK ETL SEMKO OR FM GLOBAL

1.2 PENETRATION FIRESTOPPING

- A. PENETRATIONS IN FIRE-RESISTANCE-RATED WALLS: F-RATINGS PER ASTM E 814 OR UL 1479.
- B. PENETRATIONS IN HORIZONTAL ASSEMBLIES: F- AND T-RATINGS PER ASTM E 814 OR UL 1479:
- C. PENETRATIONS IN SMOKE BARRIERS: L-RATINGS PER UL 1479.
- D. W-RATINGS: PER UL 1479.

1.3 INSTALLATION

- A. IDENTIFICATION: PREPRINTED METAL OR PLASTIC LABELS.

1.4 FIELD QUALITY CONTROL

- A. INSPECTION OF INSTALLED FIRE-STOPPING: BY OWNER-ENGAGED AGENCY ACCORDING TO ASTM E 2174.

1.5 THROUGH-PENETRATION FIRESTOP SYSTEM SCHEDULE

WHERE UL-CLASSIFIED SYSTEMS ARE INDICATED, THEY REFER TO SYSTEM NUMBERS IN UL'S "FIRE RESISTANCE DIRECTORY" UNDER PRODUCT CATEGORY XHEZ.

FOR THE FOLLOWING SYSTEMS:

METALLIC AND NON-METALLIC PIPES, CONDUIT, OR TUBING, ELECTRICAL CABLES, CABLE TRAYS WITH ELECTRIC CABLES, MISCELLANEOUS ELECTRICAL PENETRANTS, INSULATED PIPES, GROUPINGS OF PENETRANTS, USE ON OR MORE THE FOLLOWING MATERIALS:

- a. LATEX SEALANT
- b. SILICONE SEALANT
- c. INTUMESCENT PUTTY
- d. MORTAR
- h. SILICONE FOAM
- i. PILLOWS/BAGS
- j. INTUMESCENT WRAP STRIPS
- k. INTUMESCENT COMPOSITE SHEET

1.6 MANUFACTURERS

1. HILTI CONSTRUCTION CHEMICAL, INC
2. TREMCO INC.
3. 3M FIRE PROTECTION PRODUCTS

END OF SECTION 078413

SECTION 230517 – SLEEVES AND SLEEVE SEALS FOR HVAC PIPING

1.1 SLEEVE-SEAL SYSTEMS

- A. FIELD-ASSEMBLED, MODULAR SEALING-ELEMENT UNIT FOR FILLING ANNULAR SPACE BETWEEN PIPING AND SLEEVE.

1. SEALING ELEMENTS: EPDM RUBBER OR NBR.

2. PRESSURE PLATES: CARBON STEEL, PLASTIC, STAINLESS STEEL.

3. CONNECTING BOLTS AND NUTS: CARBON STEEL WITH CORROSION-RESISTANT COATING, STAINLESS STEEL.

- B. MANUFACTURERS: SUBJECT TO COMPLIANCE WITH REQUIREMENTS, AVAILABLE MANUFACTURERS OFFERING PRODUCTS THAT MAY BE INCORPORATED INTO THE WORK INCLUDE, BUT ARE NOT LIMITED TO, THE FOLLOWING:

1. ADVANCE PRODUCTS & SYSTEMS, INC.
2. CALPICO, INC.
3. METRAFLEX COMPANY (THE).
4. PIPELINE SEAL AND INSULATOR, INC.
5. PROCO PRODUCTS, INC.

1.2 SLEEVE-SEAL FITTINGS

- A. MANUFACTURED PLASTIC, SLEEVE-TYPE, PLASTIC OR RUBBER WATER-STOP ASSEMBLY MADE FOR IMBEDDING IN CONCRETE SLAB OR WALL.

1.3 GROUT

- A. NON-SHRINK, FACTORY PACKAGED.

1.4 SLEEVE AND SLEEVE-SEAL SCHEDULE

- A. USE SLEEVES AND SLEEVE SEALS FOR THE FOLLOWING PIPING-PENETRATION APPLICATIONS:

1. INTERIOR PARTITIONS:

- a. PIPING SMALLER THAN NPS 6 (DN 150): GALVANIZED-STEEL-PIPE SLEEVES, PVC-PIPE SLEEVES.
- b. PIPING NPS 6 (DN 150) AND LARGER: GALVANIZED-STEEL-SHEET SLEEVES.

END OF SECTION 230517

SECTION 230529 – HANGERS AND SUPPORTS FOR HVAC PIPING AND EQUIPMENT

- 1.1 PERFORMANCE REQUIREMENTS

A. DELEGATED DESIGN: DESIGN TRAPEZE PIPE HANGERS AND EQUIPMENT SUPPORTS, INCLUDING COMPREHENSIVE ENGINEERING ANALYSIS BY A QUALIFIED PROFESSIONAL ENGINEER, USING PERFORMANCE REQUIREMENTS AND DESIGN CRITERIA INDICATED.

B. STRUCTURAL PERFORMANCE: HANGERS AND SUPPORTS FOR HVAC PIPING AND EQUIPMENT SHALL WITHSTAND THE EFFECTS OF GRAVITY LOADS AND STRESSES WITHIN LIMITS AND UNDER CONDITIONS INDICATED ACCORDING TO ASCE/SEI 7.

1. DESIGN SUPPORTS FOR MULTIPLE PIPES CAPABLE OF SUPPORTING COMBINED WEIGHT OF SUPPORTED SYSTEMS, SYSTEM CONTENTS, AND TEST WATER.

2. DESIGN EQUIPMENT SUPPORTS CAPABLE OF SUPPORTING COMBINED OPERATING WEIGHT OF SUPPORTED EQUIPMENT AND CONNECTED SYSTEMS AND COMPONENTS.
- 1.2 SUBMITTALS

A. SHOP DRAWINGS: SIGNED AND SEALED BY A PROFESSIONAL ENGINEER
- 1.3 QUALITY ASSURANCE

A. AWS D1.1/D1.1M, "STRUCTURAL WELDING CODE – STEEL."
- 1.4 COMPONENTS

A. METAL PIPE HANGERS AND SUPPORTS: CARBON OR STAINLESS STEEL

B. TRAPEZE PIPE HANGERS: CARBON OR STAINLESS STEEL

C. FIBERGLASS PIPE HANGERS: –CLEVIS, CENTURY COMPOSITES, COOPER B–LINE

D. METAL FRAMING SYSTEMS: MFMA MANUFACTURER

E. FIBERGLASS STRUT SYSTEMS: COOPER B–LINE

F. THERMAL–HANGER SHIELD INSERTS:

G. FASTENER SYSTEMS: POWDER–ACTUATED FASTENERS OR MECHANICAL–EXPANSION ANCHORS

H. PIPE STANDS: COMPACT, LOW TYPE, SINGLE PIPE, HIGH TYPE, SINGLE PIPE, HIGH TYPE, MULTIPLE PIPES, CURB–MOUNTED TYPE

I. EQUIPMENT SUPPORTS.

END OF SECTION 230529
- SECTION 230548 – VIBRATION CONTROLS FOR HVAC EQUIPMENT
- PART 1 – GENERAL

1.1 PERFORMANCE REQUIREMENTS

A. SEISMIC–RESTRAINT LOADING:

1. SITE CLASS AS DEFINED IN THE IBC: A, B

2. ASSIGNED SEISMIC USE GROUP OR BUILDING CATEGORY AS DEFINED IN THE IBC: I II III

a. COMPONENT IMPORTANCE FACTOR: 1.0

b. COMPONENT RESPONSE MODIFICATION FACTOR: 2.5

c. COMPONENT AMPLIFICATION FACTOR: 2.5.

3. DESIGN SPECTRAL RESPONSE ACCELERATION AT SHORT PERIODS (0.2 SECOND) 18%

4. DESIGN SPECTRAL RESPONSE ACCELERATION AT 1–SECOND PERIOD: 8%

1.2 COMPONENTS

A. VIBRATION ISOLATORS:

1. ISOLATOR PADS: NEOPRENE, RUBBER, HERMETICALLY AND/OR SEALED COMPRESSED FIBERGLASS

2. MOUNTS: DOUBLE–DEFLECTION TYPE.

3. RESTRAINED MOUNTS: ALL DIRECTIONAL MOUNTINGS WITH SEISMIC RESTRAINT; CAST–DUCTILE–IRON HOUSING.

4. SPRING ISOLATORS: FREESTANDING, LATERALLY STABLE, OPEN–SPRING TYPE.

5. RESTRAINED SPRING ISOLATORS: FREESTANDING, STEEL, OPEN–SPRING TYPE WITH SEISMIC RESTRAINT.

6. HOUSED SPRING MOUNTS: DUCTILE–IRON OR STEEL HOUSING, WITH INTEGRAL, VERTICALLY ADJUSTABLE SEISMIC SNUBBERS.

7. ELASTOMERIC HANGERS: DOUBLE–DEFLECTION TYPE.

8. SPRING HANGERS: COMBINATION COIL–SPRING AND ELASTOMERIC–INSERT HANGERS WITH SPRING AND INSERT IN COMPRESSION.

9. SPRING HANGERS WITH VERTICAL–LIMIT STOP- COMBINATION COIL–SPRING AND ELASTOMERIC–INSERT HANGERS WITH SPRING AND INSERT IN COMPRESSION AND WITH VERTICAL–LIMIT STOP.

10.PIPE RISER RESILIENT SUPPORT: ALL–DIRECTIONAL, ACOUSTICAL PIPE ANCHOR.

11.RESILIENT PIPE GUIDES.
- B. AIR–MOUNTING SYSTEMS:

1. AIR MOUNTS: FREESTANDING, SINGLE OR MULTIPLE, COMPRESSED–AIR BELLOW.

2. RESTRAINED AIR MOUNTS: HOUSED COMPRESSED–AIR BELLOW.

C. RESTRAINED VIBRATION ISOLATION ROOF–CURB RAILS: FACTORY–ASSEMBLED, FULLY ENCLOSED, INSULATED, AIR– AND WATERTIGHT CURB RAIL; WITH SPRING ISOLATORS MOUNTED ON ELASTOMERIC ISOLATION PADS, AND SNUBBER BUSHINGS.

D. VIBRATION ISOLATION EQUIPMENT BASES:

1. STEEL BASE: FACTORY–FABRICATED, WELDED, STRUCTURAL–STEEL BASES AND RAILS.

2. INERTIA BASE: FACTORY–FABRICATED, WELDED, STRUCTURAL–STEEL BASES AND RAILS READY FOR FIELD–APPLIED, CAST–IN–PLACE CONCRETE

1.3 FIELD QUALITY CONTROL

A. TESTING: BY EITHER: OWNER–ENGAGED AGENCY, CONTRACTOR–ENGAGED AGENCY, OR CONTRACTOR.
- PART–2 PRODUCTS

1.4 VIBRATION ISOLATORS & SEISMIC–RESTRAINT DEVICES

A. AVAILABLE MANUFACTURERS: SUBJECT TO COMPLIANCE WITH REQUIREMENTS, MANUFACTURERS OFFERING PRODUCTS THAT MAY BE INCORPORATED INTO THE WORK INCLUDE, BUT ARE NOT LIMITED TO, THE FOLLOWING:

1. ACE MOUNTINGS CO., INC.

2. AMBER/BOOTH COMPANY, INC.

3. CALIFORNIA DYNAMICS CORPORATION.

4. COOPER B–LINE, INC.; A DIVISION OF COOPER INDUSTRIES.

5. HILTI, INC.

6. ISOLATION TECHNOLOGY, INC.

7. KINETICS NOISE CONTROL.

8. LOOS & CO.; CABLEWARE DIVISION.

9. MASON INDUSTRIES.

10. TOLCO INCORPORATED; A BRAND OF NIBCO INC.

11. UNISTRUT; TYCO INTERNATIONAL, LTD.

12. VIBRATION ELIMINATOR CO., INC.

13. VIBRATION ISOLATION.

14. VIBRATION MOUNTINGS & CONTROLS, INC.

B. MANUFACTURERS: SUBJECT TO COMPLIANCE WITH REQUIREMENTS, PROVIDE PRODUCTS BY ONE OF THE FOLLOWING:

1. ACE MOUNTINGS CO., INC.

2. AMBER/BOOTH COMPANY, INC.

3. CALIFORNIA DYNAMICS CORPORATION.

4. COOPER B–LINE, INC.; A DIVISION OF COOPER INDUSTRIES.

5. HILTI, INC.

6. ISOLATION TECHNOLOGY, INC.

7. KINETICS NOISE CONTROL.

8. LOOS & CO.; CABLEWARE DIVISION.

9. MASON INDUSTRIES.

10. TOLCO INCORPORATED; A BRAND OF NIBCO INC.

11. UNISTRUT; TYCO INTERNATIONAL, LTD.

12. VIBRATION ELIMINATOR CO., INC.

13. VIBRATION ISOLATION.

14. VIBRATION MOUNTINGS & CONTROLS, INC.
- END OF SECTION 230548

SECTION 230593 – TESTING, ADJUSTING, AND BALANCING FOR HVAC
- 1.1 SUMMARY

A. TESTING, ADJUSTING, AND BALANCING FOR THE FOLLOWING:

1. MOTORS.

2. CONDENSING UNITS.

3. AIR SYSTEM: CONSTANT VOLUME

1.2 QUALITY ASSURANCE

A. THE CONTRACTOR SHALL PROCURE THE SERVICES OF A TESTING, ADJUSTING AND BALANCING (TAB) SPECIALIST WHO SPECIALIZES IN HEATING, VENTILATION AND AIR CONDITIONING SYSTEMS. THE TAB AGENT SHALL HAVE THE FOLLOWING QUALIFICATIONS: AABC, NEBB OR TABB CERTIFIED.

1.3 EXECUTION

A. THE TAB SPECIALIST SHALL PERFORM FLOW MEASUREMENTS OF ALL EXISTING AIR AND HYDRONIC SYSTEMS THAT ARE TO REMAIN OR TO BE INCORPORATED INTO NEW WORK PRIOR TO THE STARTING OF WORK IN THE PROJECT SCOPE. A REPORT OF THESE MEASUREMENTS, INDICATING ANY AND ALL DEFICIENCIES SHALL BE SUBMITTED FOR OWNER REVIEW.

B. THE TAB SPECIALIST SHALL PERFORM FLOW MEASUREMENTS OF ALL NEW AIR AND HYDRONIC SYSTEMS AS LISTED ABOVE IN THE PROJECT SCOPE. A REPORT OF THESE MEASUREMENTS, INDICATING ANY AND ALL DEFICIENCIES SHALL BE SUBMITTED FOR OWNER REVIEW.

C. THE REPORT SHALL INDICATE A SCHEMATIC DIAGRAM INDICATING LOCATIONS OF ALL EQUIPMENT TESTED AND MEASUREMENT LOCATIONS.

D. PRIOR TO FINAL INSPECTION OF THE WORK, THE TAB SPECIALIST SHALL BALANCE ALL SYSTEMS AS INDICATED ABOVE TO THE REQUIREMENTS OF THE DESIGN.

E. THE CONTRACTOR SHALL HAVE FURNISH AND INSTALL ALL ADDITIONAL BALANCING EQUIPMENT, PRESSURE TAPS, GAUGES AND OTHER EQUIPMENT AS REQUIRED FOR A PROPERLY BALANCED SYSTEM AT NO ADDITIONAL COST TO THE OWNER. SUCH ADDITIONAL EQUIPMENT SHALL ADHERE IN STRICT ACCORDANCE WITH THE RESPECTIVE EQUIPMENT MANUFACTURER’S RECOMMENDATIONS.

F. THE CONTRACTOR SHALL HAVE THE TESTING AND BALANCING SPECIALIST COORDINATE ALL WORK OF THIS SECTION WITH THE BUILDING MANAGER. BALANCING WORK SHALL NOT CONFLICT WITH OTHER WORK SO AS TO MAINTAIN COMPLETION WITHIN THE SPECIFIED TIME.

G. ALL INSTRUMENTS USED FOR TAB SHALL BE MAINTAINED IN GOOD WORKING CONDITION AND ACCURATELY CALIBRATED.
- H. TOLERANCES: PLUS OR MINUS 5 PERCENT OF DESIGN VALUES.

I. INSPECTIONS: RANDOM CHECKS BY OWNER OR ARCHITECT TO VERIFY FINAL TESTING, ADJUSTING, AND BALANCING REPORT.

J. ADDITIONAL TESTS: RANDOM TESTS WITHIN 90 DAYS OF COMPLETING TAB TO VERIFY BALANCE CONDITIONS AND SEASONAL TESTS.

END OF SECTION 230593
- SECTION 230713 – DUCT INSULATION
- 1.1 QUALITY ASSURANCE

SURFACE–BURNING CHARACTERISTICS: ALL INSULATION SHALL HAVE COMPOSITE (INSULATION JACKET OR FACING AND ADHESIVE USED TO ADHERE THE FACING OR JACKET TO THE INSULATION) A FLAME–SPREAD INDEX OF 25, AND SMOKE–DEVELOPED INDEX OF 50 FOR INSULATION INSTALLED INDOOR, 75, AND SMOKE–DEVELOPED INDEX OF 150 FOR INSULATION INSTALLED OUTDOORS; ACCORDING TO ASTM 84.

1.2 FIELD QUALITY CONTROL

A. FIELD INSPECTIONS: BY OWNER–ENGAGED AGENCY.

1.3 INDOOR DUCT AND PLENUM INSULATION SCHEDULE;

A. CONCEALED, RECTANGULAR, ROUND AND FLAT–OVAL, SUPPLY–RETURN, OUTDOOR–AND EXHAUST–AIR DUCT AND AIR PLENUM INSULATION:

B. FLEXIBLE ELASTOMERIC, MINERAL–FIBER BLANKET, MINERAL–FIBER BOARD OR POLYOLEFIN WITH MINIMUM INSTALLED THERMAL RESISTANCE AS FOLLOWS: UNCONDITIONED SPACES WITHIN BUILDING: R–6 WITHIN BUILDING ENVELOPE ASSEMBLY: R–8 OUTSIDE OF BUILDING: R–8

B. ITEMS NOT INSULATED:

1. FIBROUS–GLASS DUCTS.

2. METAL DUCTS WITH DUCT LINER OR SUFFICIENT THICKNESS TO COMPLY WITH ENERGY CODE ANDASHRAE/IESNA 90.1.

3. FACTORY–INSULATED FLEXIBLE DUCTS.

4. FACTORY–INSULATED PLENUMS AND CASINGS.

5. FLEXIBLE CONNECTORS.

6. VIBRATION–CONTROL DEVICES.

7. FACTORY–INSULATED ACCESS PANELS AND DOORS.

8. DUCTS THAT HAVE INTERNAL ACOUSTICAL LINING.

1.5 PRODUCTS

A. THE FOLLOWING INSULATION MANUFACTURERS WILL BE ACCEPTABLE:

1. JOHNS–MANVILLE

2. OWENS–CORNING

1.6 ACOUSTICAL TREATMENT

1. WHERE SHOWN ON THE DRAWINGS, LOW PRESSURE DUCTWORK SHALL BE LINED WITH 1.5" THICK R–6 AS MANUFACTURED BY DUCTMATE, 1–1/2 POUND MINIMUM DENSITY, NEOPRENE COATED, FLEXIBLE FIBERGLASS DUCT LINER. LINING SHALL COMPLY WITH NFPA 90A AND SHALL HAVE A FLAME SPREAD CLASSIFICATION OF NOT MORE THAN 25 AND A SMOKE DEVELOPED RATING NOT MORE THAN 50. DUCT SIZES WHERE LINING IS INDICATED ON PLANS ARE MINIMUM INSIDE CLEAR DIMENSIONS REQUIRED,

END OF SECTION 230713
- SECTION 233113 – METAL DUCTS
- 1.1 CONSTRUCTION

A. EACH DUCT SYSTEM SHALL BE CONSTRUCTED FOR THE SPECIFIC SMACNA DUCT PRESSURE CLASSIFICATIONS SHOWN ON THE CONTRACT DRAWINGS. WHERE NO PRESSURE CLASSES ARE SPECIFIED BY THE DESIGNER, THE SMACNA 2–1/2 INCH WG PRESSURE CLASS IS THE BASIS OF COMPLIANCE WITH THESE STANDARDS, REGARDLESS OF THE VELOCITY IN THE DUCT.

B. ALL DUCTWORK SHALL BE CONSTRUCTED TO SMACNA 2" WG DESIGN AND NOT LESS THAN THE FOLLOWING STANDARDS:

1. DUCTWORK SHALL BE TRANSVERSELY JOINTED BY CONNECTING SEAMS OF COMPANION ANGLES, FORMED FROM 1–1/2"x1–1/2"x1/8" GALVANIZED ANGLES, TACK WELDED OR RIVETED TO THE DUCT. THE ANGLE FRAME SHALL BE CONTINUOUSLY FLANGED UP INTO UPRIGHT OF ANGLE AND EACH CORNER SHALL BE FILLED IN AND GROUND SMOOTH. JOINTS SHALL BE GASKETED WITH 1/8" THICK REINFORCED GASKET, OVERLAPPED AT CORNERS, GASKET SIMILAR TO 3M–1202 OR APPROVED EQUAL.

2. RECTANGULAR FITTINGS AND ALL TRANSITION PIECES FROM RECTANGULAR TO ROUND SHALL BE NO. 16 GAUGE ALL WELDED CONSTRUCTION.

3. HORIZONTAL DUCTS SHALL BE SUPPORTED ON NOT MORE THAN 6' CENTERS. VERTICAL RISERS SHALL BE SUPPORTED AT EACH FLOOR.

4. LONGITUDINAL SEAMS FOR RECTANGULAR DUCTWORK SHALL BE PITTSBURGH LOCK SEAMS WITH SEALING COMPOUND, EQUAL TO BENJAMIN FOSTER NO. 30–03 INSERTED INTO SEAM. ALL SEAMS SHALL BE BRUSHED WITH NO. 30–02 AND COVERED WITH APPROVED SEALING TAPE.

5. RECTANGULAR DUCTWORK 18 GAUGE AND HEAVIER, FILLER RODS SHALL BE IN ACCORDANCE WITH SPECIFICATIONS FOR IRON AND STEEL GAS WELDING RODS, ASTM 215; AWG A5.2.

6. ALL FITTINGS SUCH AS ELBOWS, TEES, ETC., SHALL BE NO. 20 GAUGE ZINC COATED STEEL. ELBOWS SHALL BE OF FIVE (5) PIECE WELDED AIRTIGHT CONSTRUCTION.

C. WHERE LATEST EDITION OF SMACNA DOES NOT CLEARLY STATE GAUGES AND/OR STIFFENERS TO BE USED OR, WHERE SMACNA STANDARDS REQUIRE INTERPRETATION, THE FOLLOWING MINIMUM METAL GAUGES AND BRACING SHALL BE USED:

- USG MAX. SIDE INCHES TRANSVERSE JOINTS AND BRACING
- 22 UP TO 12 S SLIP, DRIVE SLIP, ONE INCH POCKET LOCK ON 8 FOOT CENTERS
- 22 13 TO 24 1"x1"x1/8" ANGLES ON 4 FOOT CENTERS
- 20 25 TO 35 1"x1"x1/8" ANGLES ON 2 FOOT CENTERS
- D. FLAT OVAL OR ROUND DUCTWORK MAY BE PROVIDED IN LIEU RECTANGULAR DUCTWORK WITH THE REINFORCEMENT FOR FLAT SIDES SAME AS SPECIFIED FOR THE RECTANGULAR DUCTWORK, AND AS PER SMACNA FLAT OVAL DUCT CONSTRUCTION STANDARDS SHOWN IN FIG. 3–6 AND AS SHOWN IN FIG. 3–1 AND 3–2 FOR ROUND DUCTWORK.
- E. ALL DUCTWORK SHALL BE SEALED TO CLASS "A" AND LEAK TESTED TO MEAT SMACNA CLASS 6 FOR RECTANGULAR AND CLASS 3 FOR ROUND DUCTS.
- 1.2 MATERIALS

A. SINGLE–WALL RECTANGULAR DUCTS AND FITTINGS.

B. DOUBLE–WALL RECTANGULAR DUCTS AND FITTINGS.

4. FIBROUS–GLASS OR FLEXIBLE ELASTOMERIC DUCT LINER FOR INTERSTITIAL INSULATION.

5. PERFORATED INNER DUCT.

C. SINGLE–WALL ROUND AND FLAT–OVAL DUCTS AND FITTINGS.

D. DOUBLE–WALL ROUND AND FLAT–OVAL DUCTS AND FITTINGS.

1. FIBROUS–GLASS OR FLEXIBLE ELASTOMERIC DUCT LINER FOR INTERSTITIAL INSULATION.

2. PERFORATED INNER DUCT.

E. SHEET METAL MATERIALS:

1. GALVANIZED SHEET STEEL.

2. PVC–COATED, GALVANIZED SHEET STEEL.

3. CARBON–STEEL SHEETS.

4. STAINLESS–STEEL SHEETS.

5. ALUMINUM SHEETS.

6. FACTORY–APPLIED ANTI–MICROBIAL COATING.

F. DUCT LINER:

1. FIBROUS GLASS, TYPE I, FLEXIBLE.

a. WITH ANTI–MICROBIAL EROSION–RESISTANT COATING.

2. FLEXIBLE ELASTOMERIC.

3. NATURAL FIBER.

G. SEALANT MATERIALS:

1. TWO–PART TAPE SEALING SYSTEM.

2. WATER–BASED JOINT AND SEAM SEALANT.

3. SOLVENT–BASED JOINT AND SEAM SEALANT.

4. FLANGED JOINT SEALANT.

5. FLANGE GASKETS.

6. ROUND DUCT JOINT O–RING SEALS.

1.3 SEISMIC–RESTRAINT DEVICES

A. CHANNEL SUPPORT SYSTEM.

B. STAINLESS–STEEL RESTRAINT CABLES.

C. HANGER ROD STIFFENER: STEEL TUBE OR STEEL SLOTTED–SUPPORT–SYSTEM SLEEVE WITH INTERNALLY BOLTED CONNECTIONS OR REINFORCING STEEL ANGLE CLAMPED TO HANGER ROD.

1.4 DUCT CLEANING

A. CLEAN EXISTING DUCT SYSTEM(S) BEFORE TESTING, ADJUSTING, AND BALANCING.

B. CLEAN THE FOLLOWING ITEMS:

1. AIR OUTLETS AND INLETS.

2. SUPPLY, RETURN, AND EXHAUST FANS.

3. RETURN–AIR DUCTS, DAMPERS, ACTUATORS, AND TURNING VANES.

4. SUPPLY–AIR DUCTS, DAMPERS, ACTUATORS, AND TURNING VANES.

5. DEDICATED EXHAUST AND VENTILATION COMPONENTS AND MAKEUP AIR SYSTEMS.

1.5 DUCT SCHEDULE

A. ALL DUCTS SHALL BE GALVANIZED STEEL EXCEPT AS FOLLOWS:

1. MOIST ENVIRONMENT DUCT MATERIAL: ALUMINUM.

END OF SECTION 233113

SECTION 233713 – GRILLES

1.1 PRODUCTS

A. GRILLES SHALL BE FURNISHED AND INSTALLED FOR CAPACITIES AND IN LOCATIONS INDICATED ON DRAWINGS. ALL REGISTERS AND DIFFUSERS SHALL BE PRIME COATED STEEL OR EXTRUDED ALUMINUM FINISHED UNLESS OTHERWISE NOTED IN BAKED WHITE ENAMEL.

B. MANUFACTURERS: TITUS

1. SUBJECT TO COMPLIANCE WITH REQUIREMENTS, PROVIDE PRODUCT BY ONE OF THE FOLLOWING:

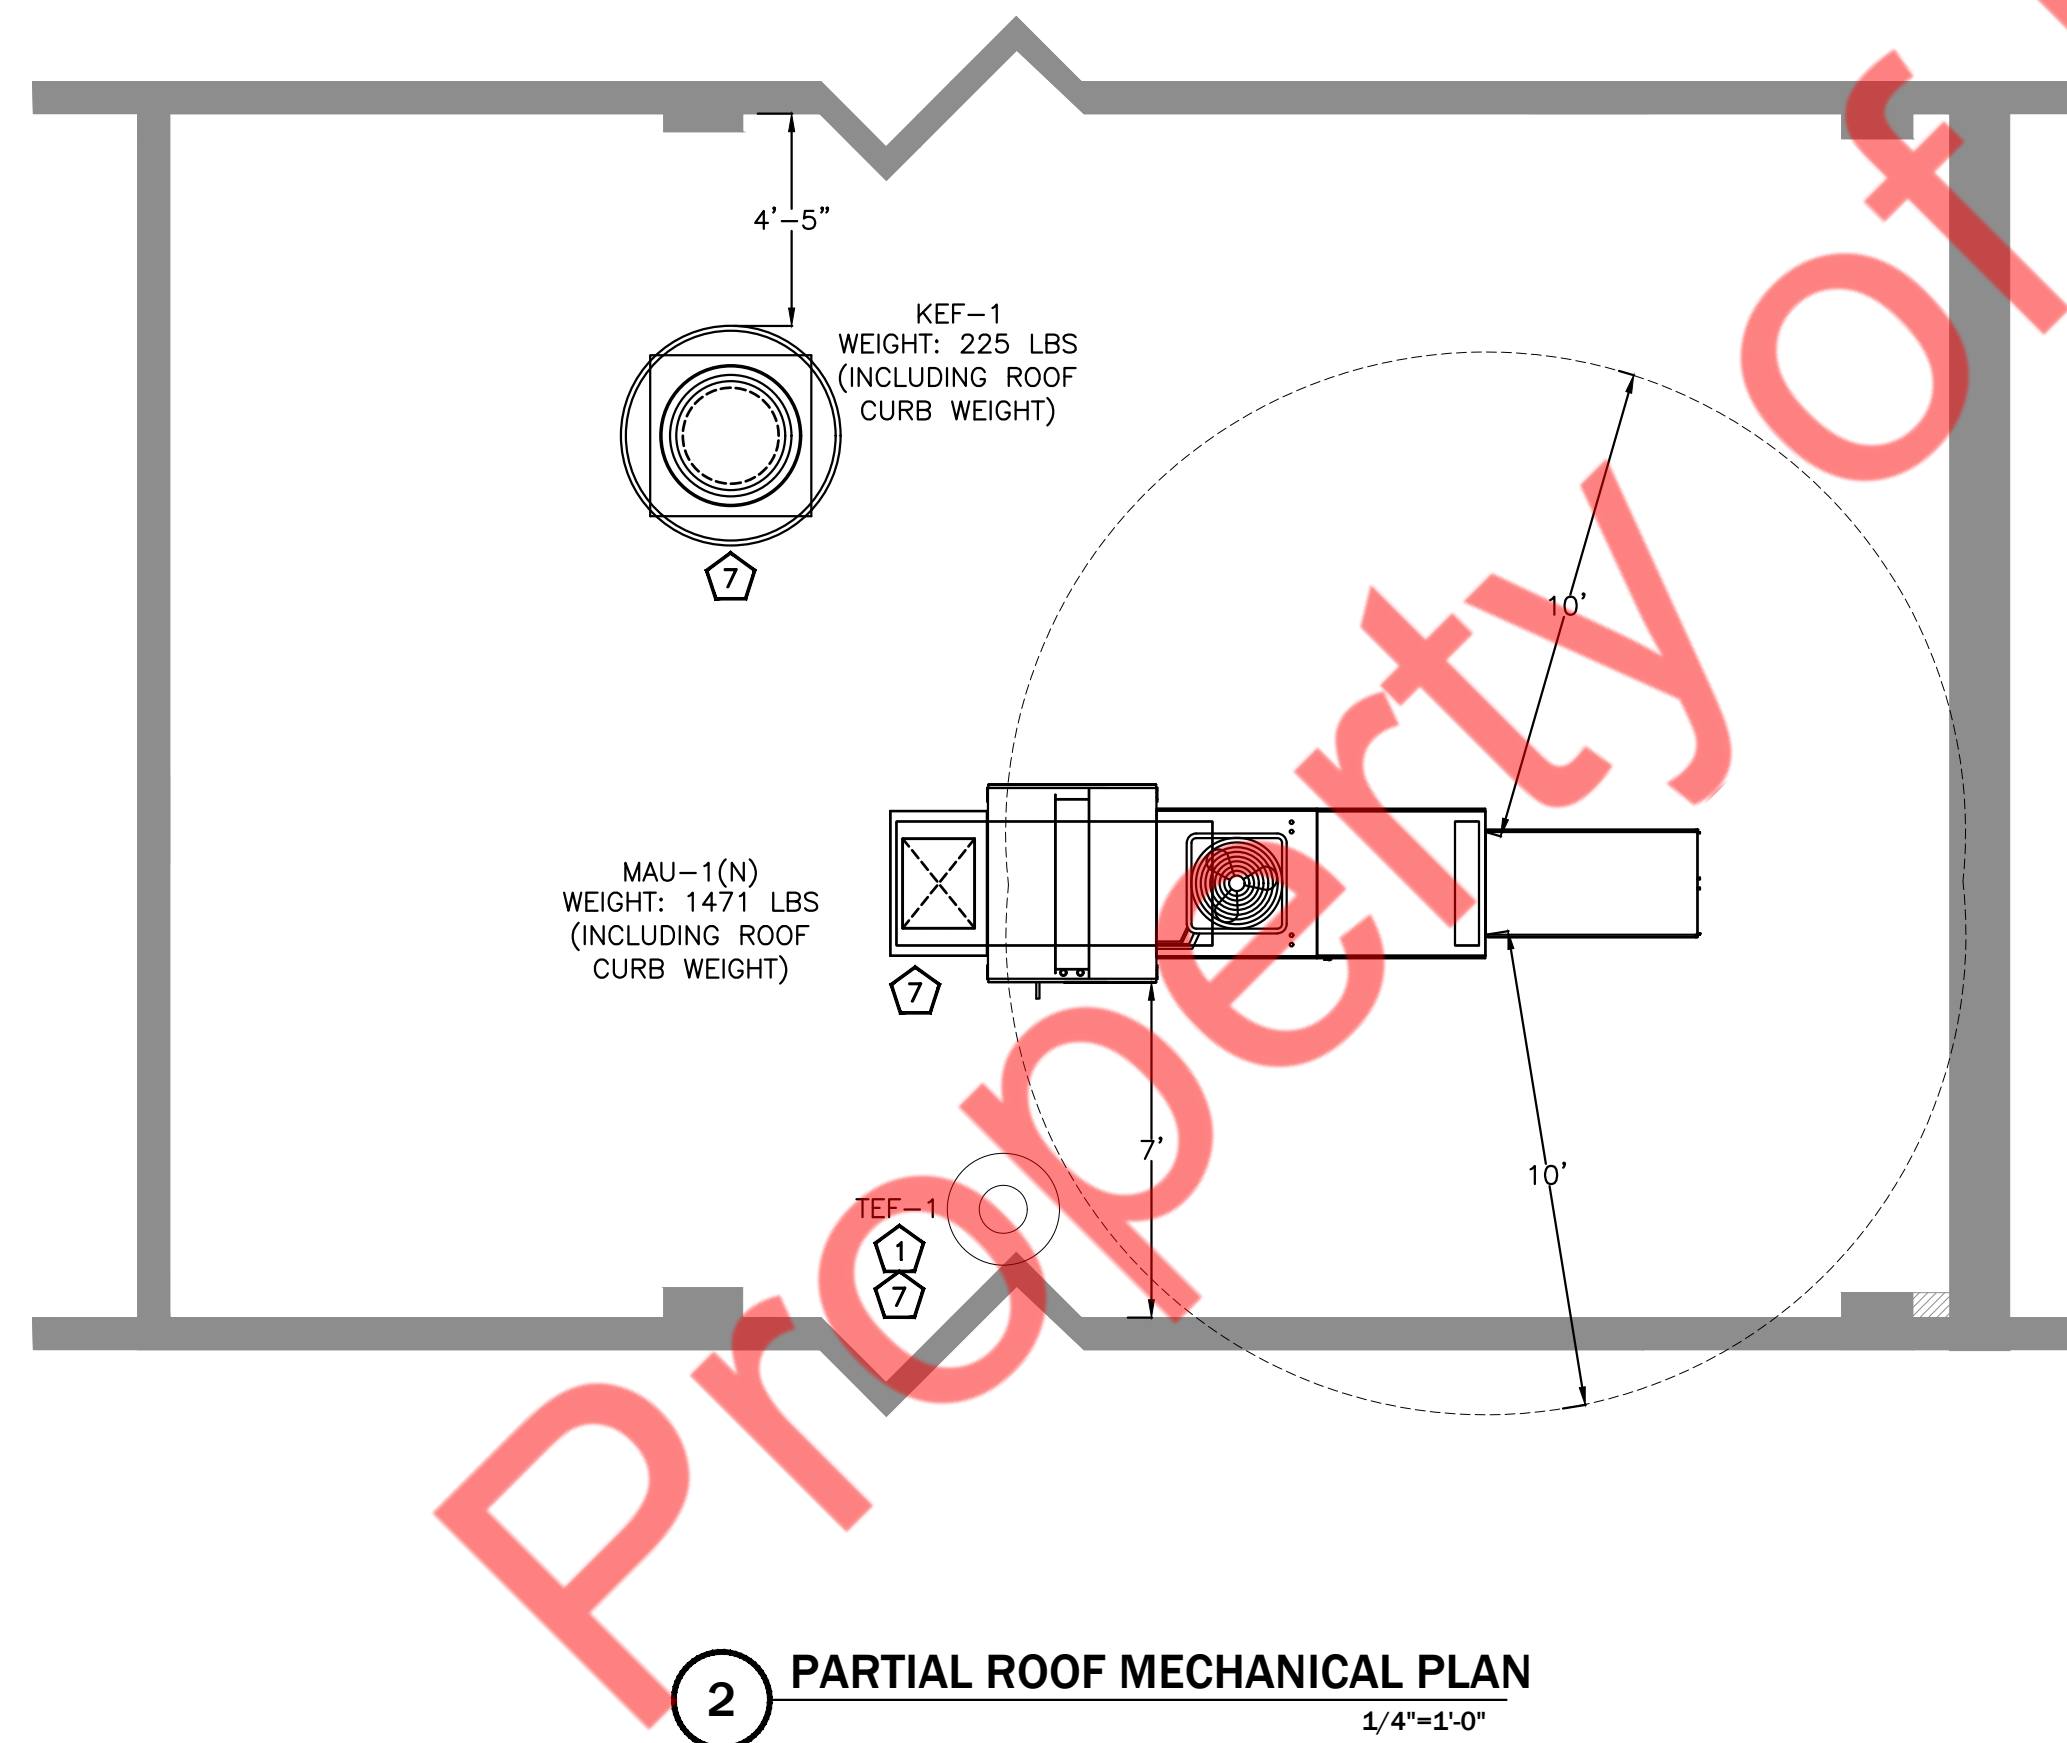
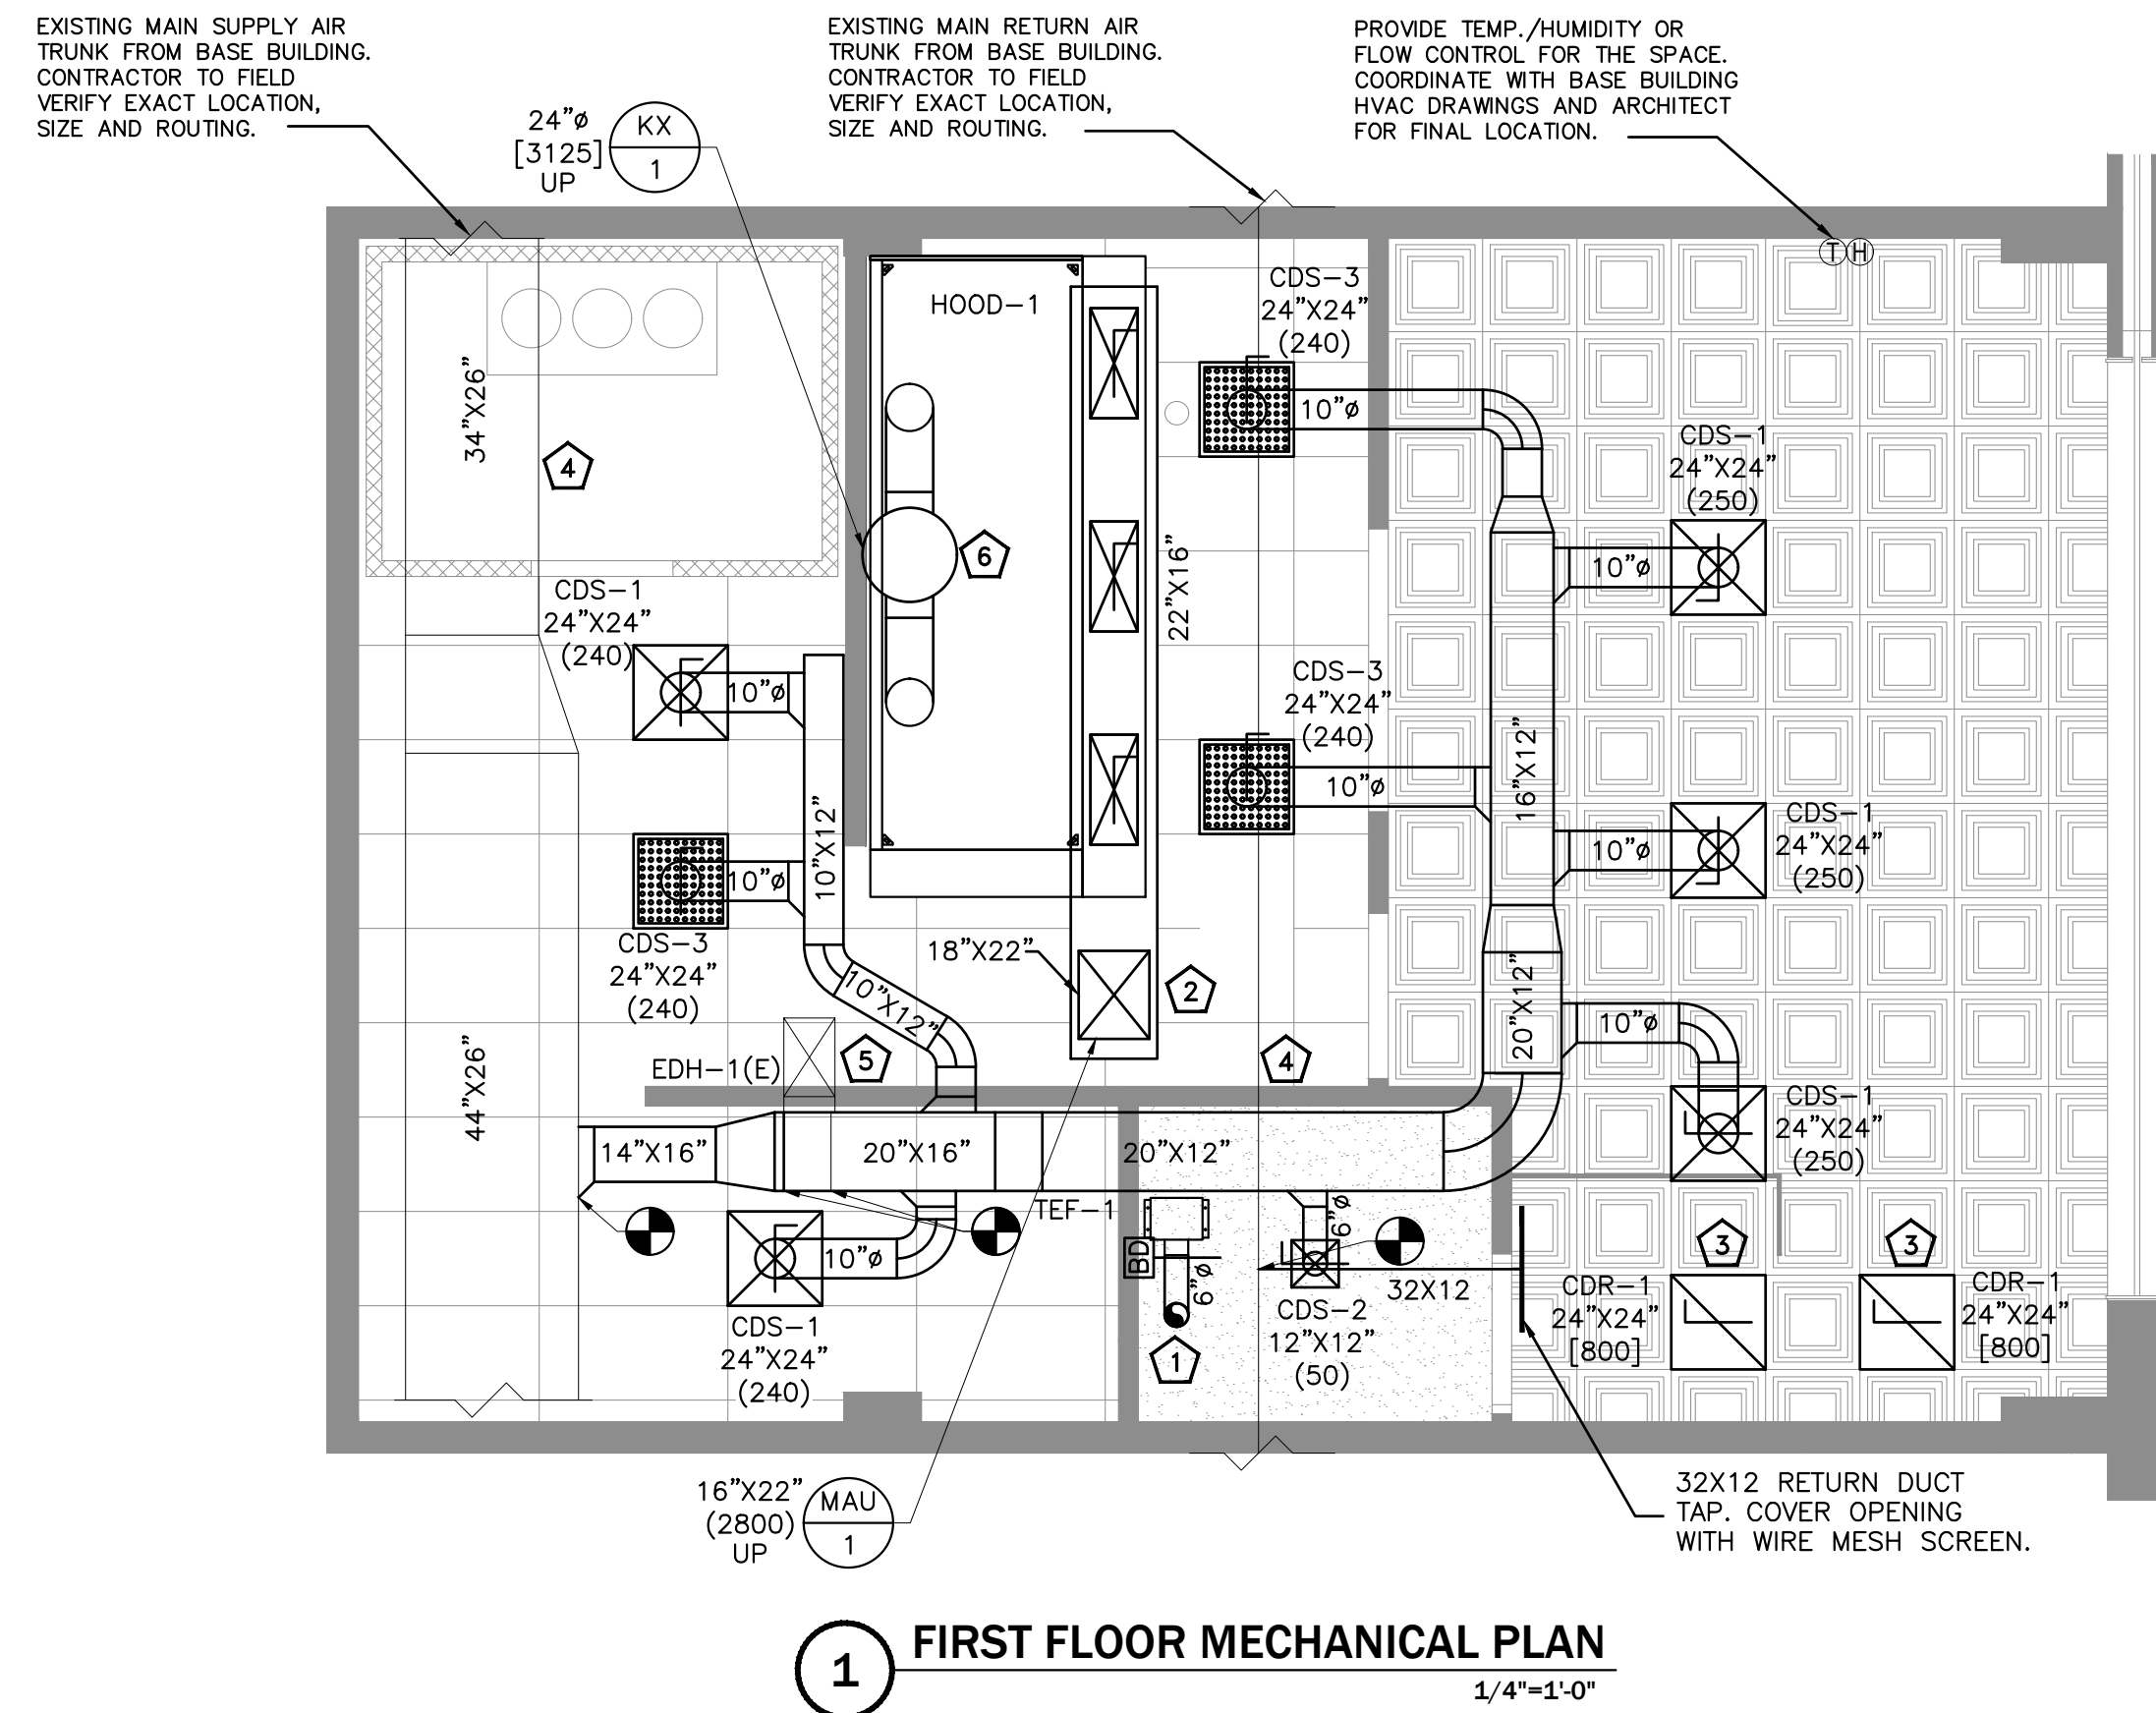
a. CARNES.

b. KRUEGER.

c. METALAIR, INC.

C. ALL DUCTED RETURN REGISTERS SHALL HAVE AN OPPOSED BLADE DAMPER UNLESS OTHERWISE NOTED.

END OF SECTION 233713





MECHANICAL GENERAL NOTES

- CONTRACTOR SHALL BALANCE EACH DEVICE WITH THE CFM SHOWN ON PLAN.
- NEW DUCTWORK SHOWN ON PLAN ARE SCHEMATIC ONLY. CONTRACTOR SHALL COORDINATE WITH OTHER TRADES FOR PIPING AND DUCTWORK ROUTING. OFFSET AND RUN PIPING, DUCTWORK INSIDE THE STRUCTURE IF REQUIRED. PROVIDE ANY EXTRA PIPING, DUCTWORK, FITTINGS, INSULATIONS AND OTHER ACCESSORIES IN ORDER TO COMPLETE THE INSTALLATION.
- COORDINATE LOCATIONS AND SIZES OF ROOF OPENINGS WITH OWNER AND STRUCTURAL ENGINEERS.
- EQUIPMENT SIZES, DIMENSIONS AND REQUIRED CONNECTIONS SHALL BE VERIFIED WITH THE ACTUAL EQUIPMENT SELECTED VENDOR DRAWINGS BEFORE FABRICATION OF DUCTWORK, PIPING ETC.
- DUCT SIZES SHOWN ON PLANS ARE CLEAR INSIDE AIR STREAM DIMENSIONS.
- CONTRACTOR SHALL COORDINATE ALL ELECTRICAL REQUIREMENTS FOR ALL HVAC BASED ON ACTUAL EQUIPMENT SELECTED PRIOR TO INSTALLATION.
- CONTRACTOR SHALL COORDINATE EQUIPMENT WEIGHTS AND SUPPORTS BASED ON ACTUAL EQUIPMENT SELECTED.
- COORDINATE WITH ALL TRADES FOR MATERIALS IN RATED AND PLENUM SPACES.
- ALL SOURCE OF MECHANICAL INTAKE SHALL MAINTAIN 10 LINEAR FEET SEPARATION BETWEEN ANY SOURCE OF EXHAUST. CONTRACTOR IS RESPONSIBLE TO ADJUST DUCT LENGTH AS NEEDED.
- MOUNT DUCTWORK AS HIGH AS POSSIBLE.
- TEST AND BALANCE AIR SYSTEMS. PROVIDE REPORT TO G.C AND OWNER.
- ALL EXPOSED ROUND DUCTWORK SHALL BE INTERNALLY LINED. ALL DUCTWORK DIMENSIONS ARE INSIDE CLEAR.
- EXHAUST HOODS, DUCTS, CURBS, FANS AND CONTROLS TO BE SUPPLIED AND INSTALLED BY HOOD CONTRACTOR ACCORDING TO THE MANUFACTURER'S INSTRUCTIONS, THE IBC, NEC AND NFPA 96.


MECHANICAL PLAN KEY NOTES:

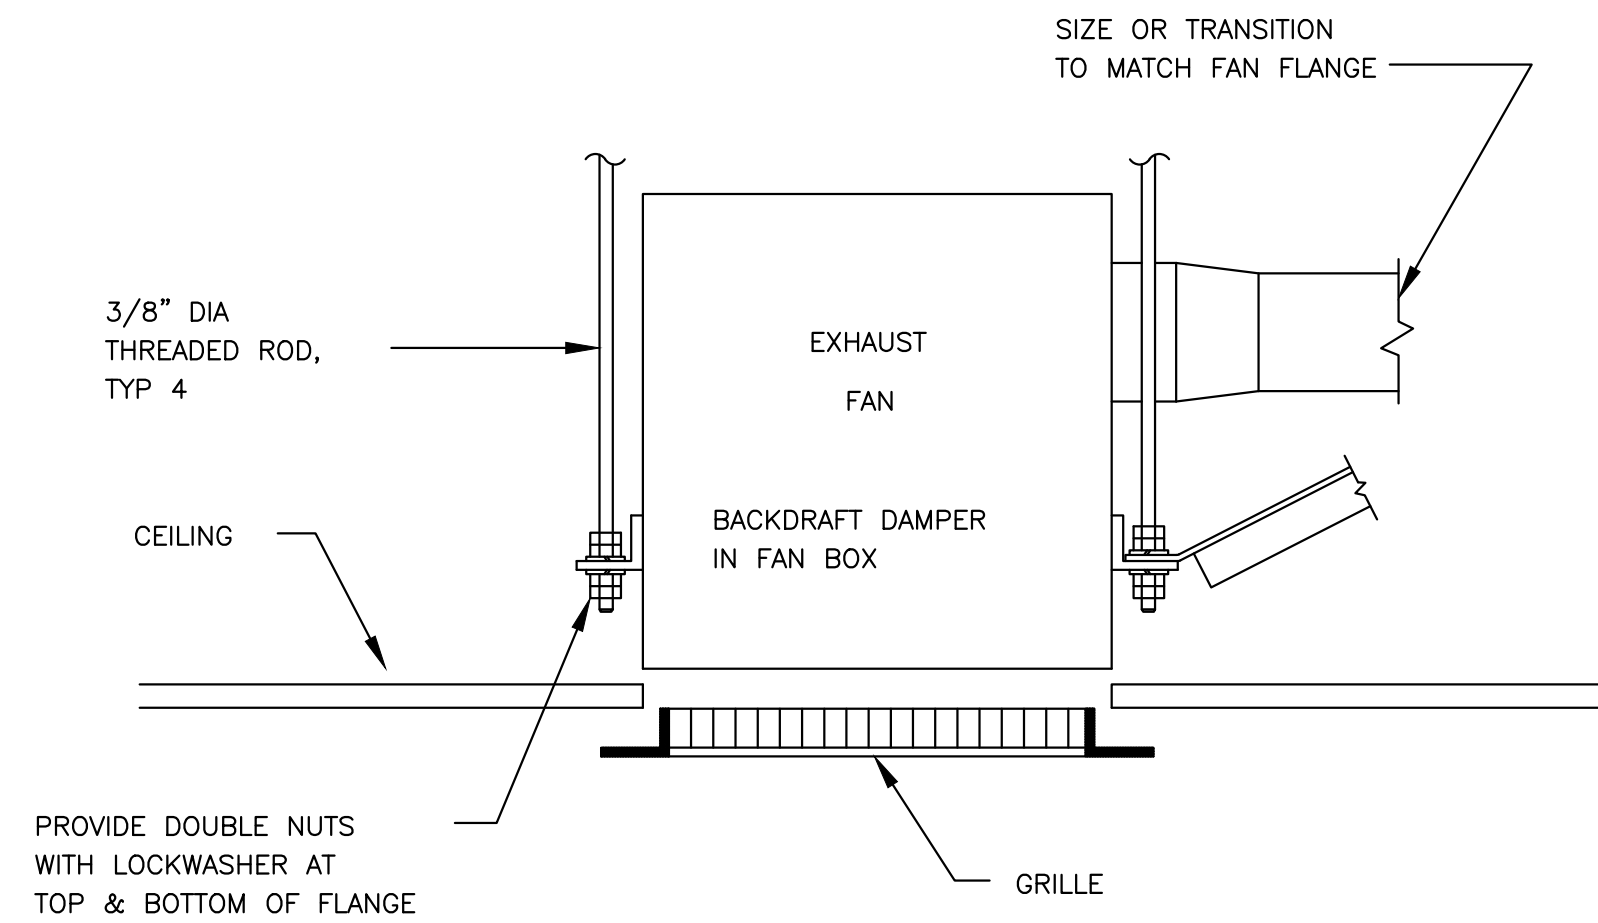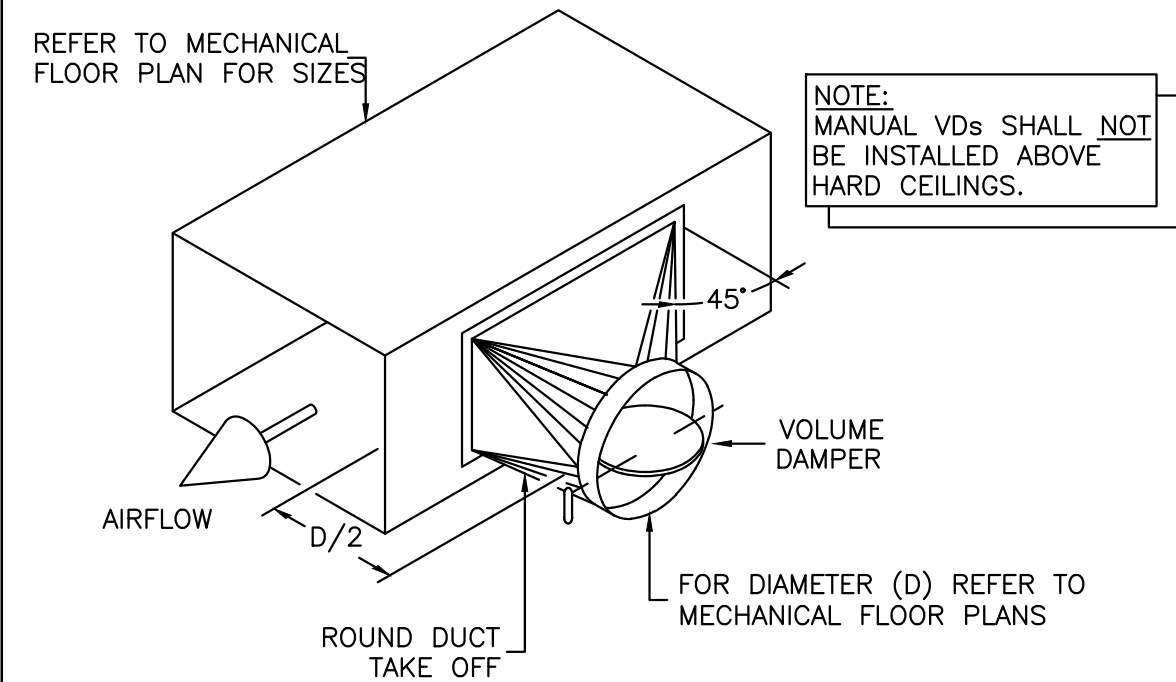- CONNECT TOILET ROOM EXHAUST AIR DUCT TO RESPECTIVE EXHAUST FAN ON THE ROOF.
- CONNECT KITCHEN MAKEUP AIR DUCT TO RESPECTIVE MAKEUP AIR UNIT ON THE ROOF.
- CONTRACTOR SHALL MAINTAIN MINIMUM 400 CFM OUTDOOR AIR REQUIREMENT. ALL RETURN THROUGH CEILING.
- CONTRACTOR SHALL COORDINATE WITH EXISTING SUPPLY AND RETURN DUCT FROM LANDLORD.
- EXISTING DUCT HEATER TO REMAIN AND TO BE REUSED. CONTRACTOR FIELD VERIFY IF IT IS OPERATIONAL OR NOT. VERIFY CAPACITY IN FIELD. IF FOUND INADEQUATE, INFORM TO ENGINEER. PROVIDE ALL ACCESSORIES REQUIRED. PROVIDE THERMOSTAT FOR ALL DUCT HEATERS. FINAL LOCATION OF T-STAT TO BE CONFIRMED WITH ARCHITECT/OWNER.
- CONNECT KITCHEN EXHAUST AIR DUCT TO RESPECTIVE EXHAUST FAN ON THE ROOF.
- COORDINATE ROOF TOP EQUIPMENT/DUCT PENETRATION LOCATIONS WITH ONYX PRIOR TO INSTALLATION.



1
M5.0
ROUND DUCT TAKE OFF DETAIL
N.T.S

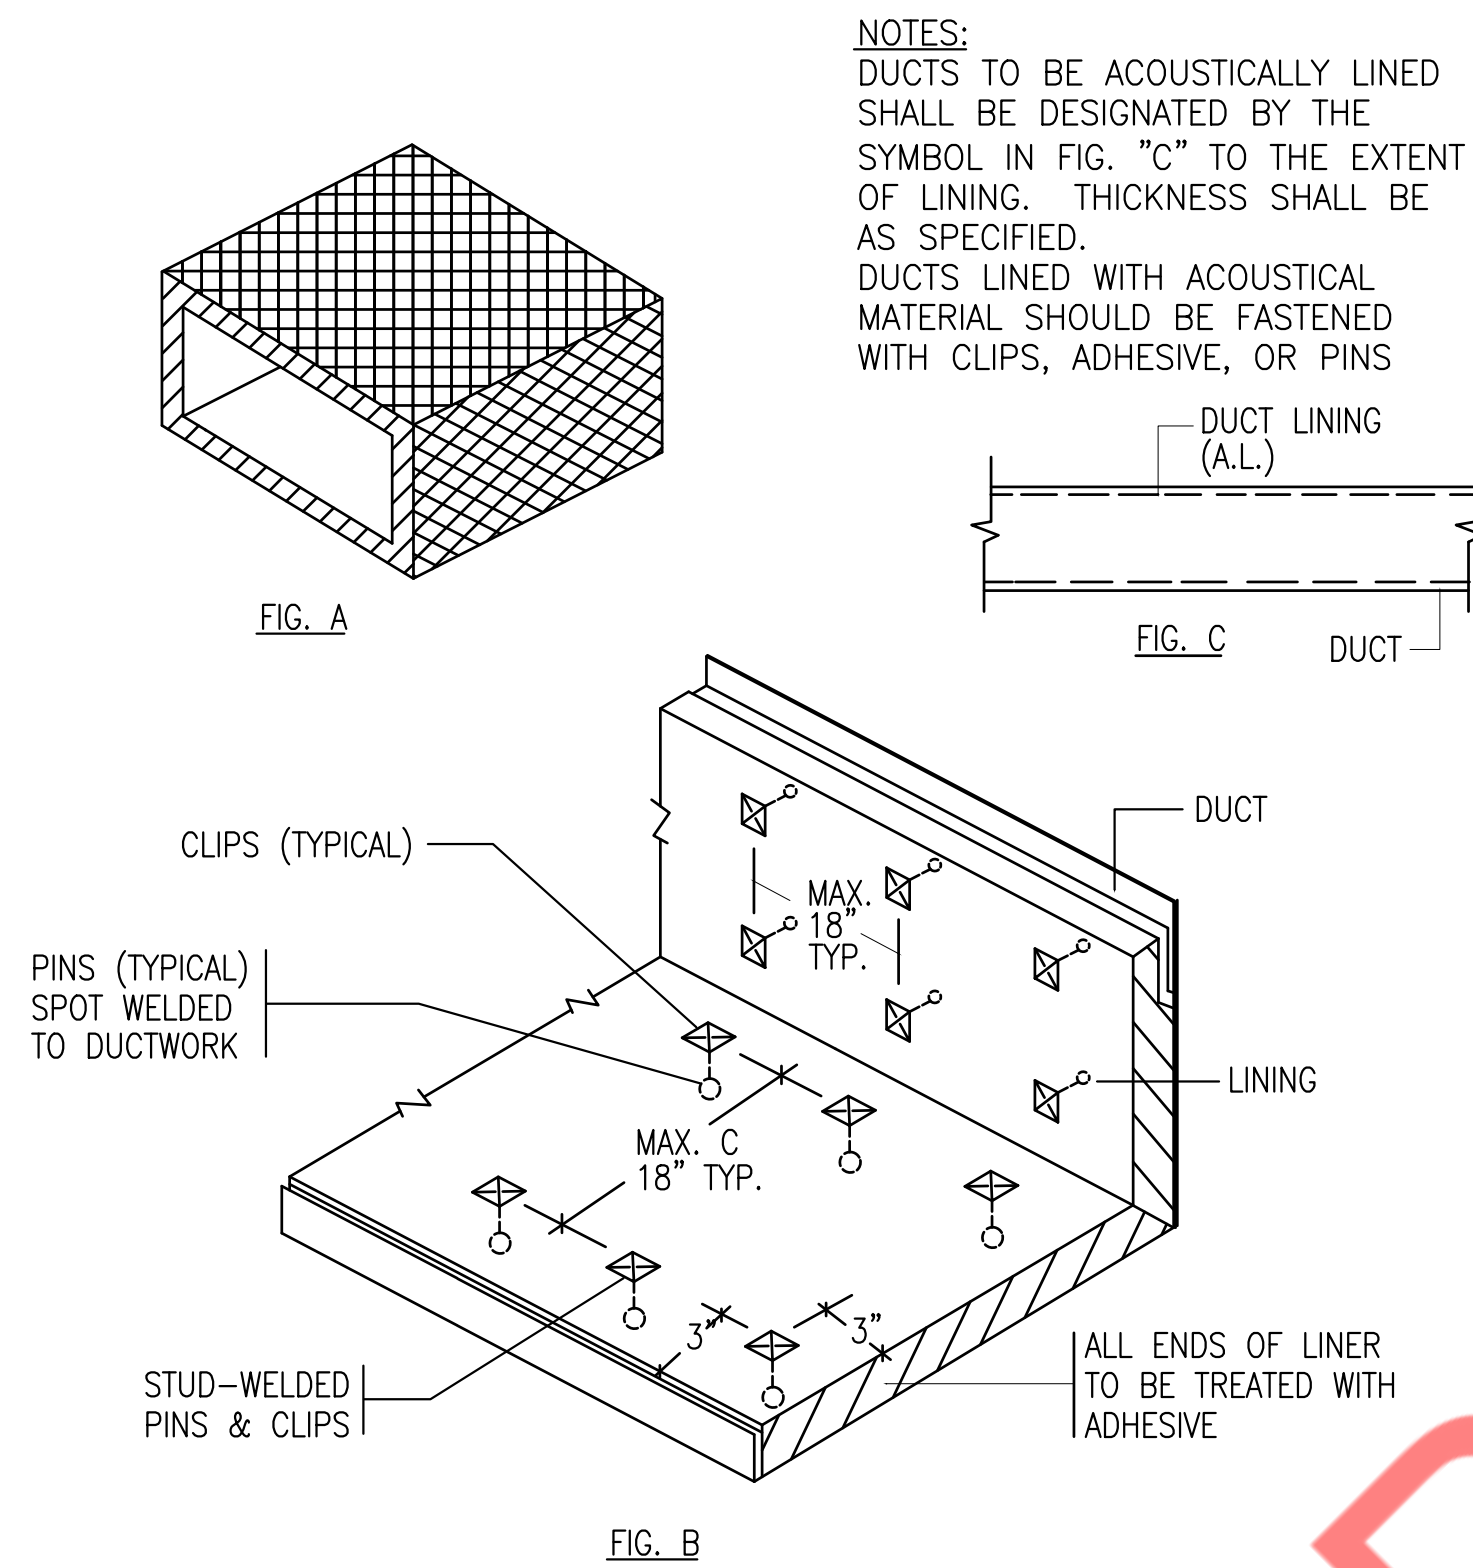2
M5.0
CEILING EXHAUST FAN
N.T.S



3
M5.0
ACOUSTICAL TREATMENT DUCT LINING
N.T.S

MAKEUP AIR UNIT SCHEDULE

UNIT ID	MANUFACTURER	MODEL	AREA SERVED	NOMINAL TONS	SUPPLY FAN		GAS HEAT		COOLING				ELECTRICAL				SEER	THERMAL EFFICIENCY	OPERATING WEIGHT (LBS)	NOTES	
					TOTAL	OUTSIDE	EXTERNAL STATIC	INPUT	OUTPUT	TOTAL	SENSIBLE	AMBIENT	ENTERING	VOLTS	PHASE	MCA(A)					MOPC(A)
					CFM	AIR CFM	PRESSURE(IN. W.G.)	MBH	MBH	MBH	MBH	DB (°F)	DB / WB(°F)								
MAU-1(N)	CAPTIVE-AIRE	A2-D.500-20D-MPU	KITCHEN	5	2800	2800	0.5	194.55	178.98	58.4	40.9	95	95/75	208	3	7.7	15	14.00	92%	1364	1

NOTES:-

1.MAKE UP AIR UNIT PROVIDED BY HOOD MANUFACTURER. REFER TO HOOD DRAWINGS FOR MORE INFORMATION.

MAU CONDENSER SCHEDULE

UNIT ID	MANUFACTURER	MODEL	NOMINAL CAPACITY	SEER	VOLTS	PHASE	MCA(A)	MOCP(A)
CU-1	CAPTIVE-AIRE	A2-D.500-20D-MPU	5 TON	14	208	3	21.4	30

MECHANICAL AIR TERMINAL DEVICES SCHEDULE

TAG	SIZE (IN.)	DESCRIPTION	CONSTRUCTION	BASIS OF DESIGN			NOTES
				NECK SIZE	MANUFACTURER	MODEL	
CDS-1	24X24	SQUARE CEILING DIFFUSER	STEEL	SEE PLAN	TITUS	TMS	ALL
CDS-2	12X12	SQUARE CEILING DIFFUSER	STEEL	SEE PLAN	TITUS	TMS	ALL
CDS-3	24X24	PERFORATED CEILING DIFFUSER	STEEL	SEE PLAN	TITUS	PAS	ALL
CDR-1	24X24	RETURN GRILLE	STEEL	-	TITUS	350RL	ALL
RG-1	24X24	RETURN GRILLE	STEEL	-	TITUS	56FL	ALL

NOTES:-

1) PROVIDE STANDARD WHITE FINISH FOR ALL AIR DEVICES UNLESS NOTED OTHERWISE ON PLAN.

2) PAINT ALL SURFACES VISIBLE THROUGH FACE OF RETURN AIR GRILLE FLAT BLACK. THIS SHALL INCLUDE PIPING, CONDUIT, DUCTWORK AND

3) PROVIDE FRAME FOR MOUNTING AIR DEVICE IN LAY-IN GRID CEILING UNLESS REFLECTED CEILING PLAN INDICATES HARD CEILING. IN AREAS WITH

4) UNLESS OTHERWISE NOTED, BRANCH DUCTS SERVING AIR DEVICES SHALL BE SAME SIZE AS NECK OF AIR DEVICE.

5) COORDINATE FINAL COLOR/FINISH WITH ARCHITECT/OWNER.

6) AIR DEVICE SHALL BE OF GALVANIZED FINISH WHEN INSTALLED ON EXPOSED DUCTWORK.

7) MAXIMUM NOISE CRITERION RATING < 35 DBA.

HOODS

UNIT ID	MANUFACTURER	LENGTH	MODEL	SERVICE	COOKING	SUPPLY	EXHAUST			CONSTRUCTION	WEIGHT
		(FEET-INCH)			TEMPERAT URE (DEG F)	AIR (CFM)	A/R (CFM)	COLLAR (IN. W.G.)	E.S.P (IN. W.G.)		(LBS)
HOOD-1	CAPTIVE-AIRE	12'-6"	5424 ND-2-PSP-F	KITCHEN AREA	600	2500	3125	12	0.854	430 STAINLESS STEEL	1156

EXHAUST FAN SCHEDULE

TAG	QUANTITY	FLOW RATE	EXTERNAL	SPEED	ELECTRIC DATA			MAXIMUM	BASIS OF DESIGN		WEIGHTS (LBS)	NOTES	REMARK
		CFM	STATIC PRESSURE		V/PH/Hz	HP	FLA (AMPS)	LOADNESS	MANUFACTURER	MODEL			
			IN W.G.					RPM					
TEF-1	1	70	0.3	900	115/1/60	0.01	0.17	28	GREENHECK	SP-A90	12	1-3	NEW
KEF-1	1	3125	1.35	1289	208/3/60	3	9.5	19.1 SONES	CAPTIVEAIRE	DU180HFA	225	1-3	NEW

NOTES:

1) PROVIDE FACTORY MOUNTED AND INSTALLED WEATHER PROOF DISCONNECT SWITCH.

2) PROVIDE THERMAL OVERLOAD PROTECTION, BACKDRAFT DAMPER.

3) PROVIDE ALL NECESSARY ACCESSORIES AS PER MANUFACTURER'S RECOMMENDATIONS.

VENTILATION CALCULATION

ROOM NAME	AREA (SQ.FT.)	NO. OF PEOPLE/1000 SQ.FT. AS PER ICM 2018	NO. OF PEOPLE AS PER ICM 2018	NO. OF CHAIR	FINAL PEOPLE NO.	MIN OUTSIDE AIR AS PER ICM 2018 CFM/PEOPLE	CFM/SQ.FT	REQ. OSA	PROVIDED OSA
SALES/SERVICE	362	15	5	6	5	7.5	0.12	81	400
KITCHEN	421	20	8	-	5	7.5	0.12	88	
TOILET	50	0	0	0	0	0	0	0	
TOTAL									400

NOTES:-

1.CONTRACTOR TO MAKE SURE THAT SPACE RECEIVED MIN. 20% OA.

ELECTRIC DUCT HEATER SCHEDULE






































UNIT TAG	LOCATION	DUCT HEATER DIMENSIONS (INCH)			CFM	DELTA T DEG F	ELECTRICAL SELECTION					MODEL	HEATER TYPE	NOTE	REMARKS
		W	H	D			KW	AMPS	V	PH	HZ				
EDH-1	SEE PLAN	SAE	SAE	SAE	SAE	SAE	14.4	40.0	208	3	60	CBK	FLANGE	1-3	EXISTING

NOTES:

1. INSTALL ELECTRIC DUCT HEATER AS PER MANUFACTURER'S RECOMMENDATION.

2. PROVIDE T-STAT AND WIRE TO DUCT HEATER.

                                     3. PROVIDE SCR CONTROLLER, DISCONNECT SWITCH, VAPOR BARRIER, DUST TIGHT BOX, AUTOMATIC THERMAL CUTOUT, AIR FLOW SWITCH & FAN INTERLOCK SWITCH.

ELECTRICAL SYMBOLS LIST					GENERAL NOTES (APPLY TO ALL "E" DRAWINGS)		
SWITCHES AND CONTROLS		POWER AND TELECOMMUNICATION		ELECTRICAL ABBREVIATIONS			1. ALL WORK SHALL BE PERFORMED IN STRICT ACCORDANCE WITH THE CURRENT VERSION OF THE NATIONAL ELECTRIC CODE(NEC) 2017 WITH NEW JERSEY AMENDMENTS, LOCAL JURISDICTION REQUIREMENTS, AND ALL GOVERNING LOCAL CODES, LAWS, AND REGULATIONS. 2. CONTRACTOR SHALL VISIT THE SITE AND BECOME FAMILIAR WITH ALL EXISTING CONDITIONS THAT MAY AFFECT THE WORK. NO ADDITIONAL COMPENSATION WILL BE CONSIDERED FOR FAILURE TO DO SO. 3. CONTRACTOR SHALL OBTAIN AND PAY FOR ALL PERMITS, TEST REPORTS, AND CERTIFICATIONS FOR TEMPORARY AND FINAL CERTIFICATE OF OCCUPANCY. 4. FIRE STOP ALL PENETRATIONS OF FIRE RATED CONSTRUCTION IN A CODE APPROVED MANNER IN ORDER TO MAINTAIN FIRE RATING. ALL PENETRATIONS SHALL BE SLEEVED AND SEALED WATERTIGHT. 5. SECURE ALL SUPPORTS TO BUILDING STRUCTURE UTILIZING TOGGLE BOLTS (HOLLOW MASONRY), EXPANSION SHIELDS OR INSERTS (CONCRETE AND BRICK), MACHINE SCREWS (METAL), BEAM CLAMPS (FRAMEWORK), WOOD SCREWS (WOOD) OR PAN THRU STRAPS (METAL DECK), NAILS, RAWL PLUGS AND WOOD PLUGS ARE NOT PERMITTED. WHERE REQUIRED BY STRUCTURE, PROVIDE THRU BOLTS AND FISH PLATES. SUPPORT HORIZONTAL RUNS OF METALLIC RACEWAYS NOT MORE THAN 10 FT APART. SUPPORT RACEWAY RISERS AT EACH FLOOR LEVEL. RUN EXPOSED RACEWAYS PARALLEL WITH OR AT RIGHT ANGLES TO WALLS. 6. LEAVE WIRES WITH SUFFICIENT SLACK TO PERMIT MAKING FINAL CONNECTIONS. RACEWAYS OVER 10 FT LONG IN WHICH WIRING IS NOT INSTALLED: FURNISH FISH WIRE. 7. VERIFY LOCATIONS OF OUTLETS AND SWITCHES IN FINISHED ROOMS WITH ARCHITECTURAL DRAWINGS OF INTERIOR DETAILS AND FINISH. IN CENTERING OUTLETS AND LOCATING BOXES AND OUTLETS, ALLOW FOR OVERHEAD PIPES, DUCTS AND MECHANICAL EQUIPMENT, EQUIPMENT, VARIATIONS IN FIREPROOFING AND PLASTERING, WINDOW AND DOOR TRIM, PANELING, HUNG CEILINGS AND THE LIKE. CORRECT ANY INACCURACY RESULTING FROM FAILURE TO DO SO WITHOUT EXPENSE TO OWNER. 8. CONTRACTOR SHALL PROVIDE A WARRANTY ON ALL MATERIALS, EQUIPMENT, AND WORKMANSHIP FOR A PERIOD OF ONE YEAR FROM THE DATE OF FINAL ACCEPTANCE. 9. ALL UNUSED MATERIALS AND DEBRIS SHALL BE LEGALLY REMOVED AND DISPOSED OF AWAY FROM THE PREMISES ON A DAILY BASIS. 10. CONTRACTOR SHALL PATCH, PAINT, AND RESTORE EXISTING SURFACES DAMAGED DURING THE COURSE OF THIS CONSTRUCTION TO PRE-EXISTING CONDITIONS OR BETTER. 11. MINIMUM SIZE OF CONDUIT SHALL BE ¾", AND TYPE SHALL BE ELECTRICAL METALLIC TUBING (EMT), UNLESS OTHERWISE NOTED. PROVIDE NYLON DRAG LINE AND CONDUIT CAP FOR ALL EMPTY CONDUITS. 12. CONNECT CONDUIT TO MOTOR CONDUIT TERMINAL BOXES WITH FLEXIBLE CONDUIT (MINIMUM 18 IN. LENGTH AND 50% SLACK). DO NOT TERMINATE IN OR FASTEN RACEWAYS TO MOTOR FOUNDATION. 13. PULL AND JUNCTION BOXES WHERE INDICATED ON THE DRAWINGS, SHALL BE CONSIDERED SHOWN AT THEIR APPROXIMATE LOCATION. THE CONTRACTOR SHALL LOCATE THEM AS FIELD CONDITIONS DICTATE. ADDITIONAL PULL AND JUNCTION BOXES NOT SHOWN ON DRAWINGS SHALL BE PROVIDED WHERE REQUIRED BY APPLICABLE CODE PROVISIONS OR WHERE CALLED FOR BY FIELD CONDITIONS. PULL AND JUNCTION BOXES SHALL BE SURFACE TYPE IN UNFINISHED AREAS AND INSTALLED CANCEALED IN FINISHED AREAS, AND ALL COVERS TO PULL & JUNCTION BOXES SHALL BE READILY ACCESSIBLE. 14. SUPPORT PANEL, JUNCTION AND PULLBOXES INDEPENDENTLY TO BUILDING STRUCTURE WITH NO WEIGHT BEARING ON RACEWAYS. 15. FOR EXACT LOCATION AND MOUNTING HEIGHT OF LIGHTING FIXTURES AND SWITCH/RECEPTACLE OUTLETS, REFER TO ARCHITECTURAL REFLECTED CEILING AND POWER PLANS. 16. ALL ELECTRICAL ACCESSORIES AND EQUIPMENT INSTALLED OUTSIDE OR EXPOSED TO WEATHER SHALL HAVE NEMA 3R ENCLOSURES AND SHALL BE TIGHTLY GASKETED FOR A COMPLETE RAINIGHT INSTALLATION. ALL BUILDING EXTERIOR MOUNTED RECEPTACLES SHALL BE GFCI RATED AND MOUNTED IN WEATHERPROOF ENCLOSURE. 17. ALL ACCESS PANEL LOCATIONS SHALL BE REVIEWED BY ARCHITECT PRIOR TO INSTALLATION. 18. ELECTRICAL CONTRACTOR SHALL COORDINATE THE LOCATION AND INSTALLATION OF NEW WORK WITH THE GENERAL CONTRACTOR AND OTHER ASSOCIATED TRADES IN A TIMELY MANNER. THE CONTRACTOR IS RESPONSIBLE FOR FIELD VERIFYING ALL DIMENSIONS AND CONDITIONS PRIOR TO CONSTRUCTION. REFER TO ALL GENERAL, MECHANICAL, AND ELECTRICAL, DRAWINGS AND SPECIFICATIONS FOR THIS PROJECT. 19. ALL CONDUITS AND EQUIPMENT TO BE CONCEALED IN FINISHED SPACES UNLESS OTHERWISE NOTED. CONDUITS SHALL BE ENCASED IN THE CONCRETE FLOOR SLAB. 20. ALL EQUIPMENT AND MATERIALS INSTALLED IN PLENUM CEILINGS SHALL BE APPROVED FOR THAT APPLICATION. 21. OUTLET BOXES AND JUNCTION BOXES ON OPPOSITE SIDES OF FIRE-RATED WALLS SHALL BE SEPARATED BY A HORIZONTAL DISTANCE OF NOT LESS THAN 24 INCHES, UNLESS FIRE-RATED BOXES OR PUTTY PADS ARE UTILIZED. 22. COORDINATE ALL FLOOR PENETRATIONS WITH THE STRUCTURAL AND ARCHITECTURAL DRAWINGS. CONFIRM PENETRATION LOCATIONS WITH THE ENGINEER AND OWNER BEFORE INSTALLATION. 23. COORDINATE THE MOUNTING HEIGHT AND LOCATION OF RACEWAYS, COMMUNICATIONS OUTLETS, AND RECEPTACLES WITH THE ARCHITECTURAL CASEWORK DRAWINGS AND DETAILS. COORDINATE LOCATIONS OF LIGHT FIXTURES, SWITCHES, AND RELATED DEVICES WITH THE ARCHITECTURAL DRAWINGS AND DETAILS. 24. REFER TO ARCHITECTURAL PLANS FOR FINAL LOACTIONS OF ALL LUMINARIES AND SWITCHES, AND FOR ALL FINISHED CEILING HEIGHTS. 25. REFER TO ARCHITECTURAL PLANS FOR FINAL LOCATIONS OF ALL ELECTRICAL DEVICES, AND FOR FINAL CEILING AND WALL HEIGHTS AND LAYOUTS. 26. LIGHTING FIXTURES PROVIDED WITH EMERGENCY BATTERY PACKS AND INDICATED WITH SWITCH CONTROL SHALL BE WIRED WITH BATTERY CHARGING/SENSING CIRCUIT WIRED AHEAD OF SWITCH CONTROL. 27. NUMBER(S) SHOWN AT RECEPTACLES, JUNCTION BOXES AND EQUIPMENT INDICATES CIRCUIT NUMBERS IN PANELBOARD. PROVIDE WIRE AND CONDUIT TO INTERCONNECT EQUIPMENT AND DEVICES WITH SAME CIRCUIT NUMBERS AND RUN TO PANELBOARD.
	20A SPST TOGGLE SWITCH U.O.N. "a" DENOTES LIGHTING FIXTURE CONTROLLED.		JUNCTION BOX WITH BLANK COVER PLATE, FLUSH IN FLOOR.	A	AMPERES	EA	EACH
	20A 3-WAY TOGGLE SWITCH U.N.O. "a" DENOTES LIGHTING FIXTURE CONTROLLED		JUNCTION BOX WITH BLANK COVER PLATE, WALL MOUNTE, +18" AFF OR AS NOTED.	A/C, AC	AIR CONDITIONING UNIT	EC	EMPTY CONDUIT/ ELECTRICAL CONTRACTOR
	20A 4-WAY TOGGLE SWITCH U.N.O. "a" DENOTES LIGHTING FIXTURE CONTROLLED		JUNCTION BOX WITH BLANK COVER PLATE, CEILING MOUNTED..	AF	AMPERE FRAME/AMP FUSE	EF	EXHAUST FAN
	WALL BOX INCANDESCENT DIMMER SWITCH, LUTHRON MAESTRO SERIES. "a" DENOTES LIGHTING FIXTURE CONTROLLED.		DUPLEX CONVENIENCE RECEPTACLE, +18" AFF OR AS NOTED.	AFF	ABOVE FINISHED FLOOR	EM	EMERGENCY
	WALL OCCUPANCY SENSOR, NUMBER INDICATES TYPE; SEE OCCUPANCY SENSOR SCHEDULE.		DUPLEX DEDICATED RECEPTACLE, +18" AFF OR AS NOTED.	AS	AMP SWITCH	EMT	ELECTRICAL METALLIC TUBING
	WALL MOUNTED VACANCY SENSOR SWITCH, WATTSTOPPER CS-50PIR SERIES.		DUPLEX CONVENIENCE RECEPTACLE – 20A–1P, 125V, NEMA 5–20R MOUNTED FLUSH IN CELING.	AIC	AMPS INTERRUPTING CAPACITY	EQUIP	EQUIPMENT
	WALL MOUNTED SPRING WOUND TIME SWITCH TORK		DUPLEX RECEPTACLE WITH GFCI PROTECTION	AT	AMP TRIP	ER	EXISTING TO BE RELOCATED
	ASCO CONTACTOR C–25 TORK TIMER T–25 STACKED.		DUPLEX RECEPTACLE WITH GFCI PROTECTION MOUNTED ABOVE COUNTER	ATS	AUTOMATIC TRANSFER SWITCH	ETR	EXISTING TO REMAIN
	DOOR SWITCH		ELECTRICAL FLOOR BOX	AUTO	AUTOMATIC	EWF	ELECTRIFIED WORKSTATION FURNITURE
	PHOTOCELL IN NAMA 3R ENCLOSURE.		RECEPTACLE FOR DRYER	AWG	AMERICAN WIRE GAUGE	EWH	ELECTRIC WATER HEATER
	WALL MOUNTED PHOTOCELL MOUNTED IN NEMA 3R ENCLOSURE.		NETWORK INTERFACE DEVICE. NID IS 'ONT' BOX WHICH INCLUDES BOTH 'ONT' AND ITS SISTER BOX AS PER VERIZON STANDARDS.	C	CONDUIT	FA	FIRE ALARM
	CEILING OCCUPANCY SENSOR, NUMBER INDICATES TYPE; SEE OCCUPANCY SENSOR SCHEDULE. 'A' LETTER REFERES TO WIRING DIAGRAM.		DOUBLE DUPLEX RECEPTACLE – 20A–1P, 125V, NEMA 5–20R.	C/B,CB	CIRCUIT BREAKER	FBO	FURNISHED BY OTHERS, INSTALLED & WIRED BY EC
	WALL OCCUPANCY SENSOR, NUMBER INDICATES TYPE; SEE OCCUPANCY SENSOR SCHEDULE.		TELEPHONE/DATA OUTLET, 4" SQUARE OUTLET BOX WITH SINGLE GANG COLLAR AND BLANK PLATE. PROVIDE 3/4" E.C., U.O.N., UP TO HUNG CEILING AND TERMINATE WITH 90° ELBOW, BUSHING AND DRAG WIRE.	CKT	CIRCUIT	FDR	FEEDER
	WALL VACANCY SENSOR, NUMBER INDICATES TYPE; SEE OCCUPANCY SENSOR SCHEDULE.		TELEPHONE OUTLET, WALL-MOUNTED +48" AFF UNO TEL / DATA OUTLET TO BE PROVIDED WITH 1" CONDUIT U.O.N. TO H.C. AND TERMINATED WITH 90 DEGREE REE ELBOW AND BUSHING. TEL / DATA OUTLET PLATE SHALL BE PROVIDED WITH 1 1/4" DIAMETER GROMMETED OPENING.	CLG	CEILING	FIBO	FURNISHED & INSTALLED BY OTHERS, WIRED BY EC
	CEILING VACANCY SENSOR, NUMBER INDICATES TYPE; SEE OCCUPANCY SENSOR SCHEDULE.		DATA OUTLET – (1) PORT UNO, +18" AFF, UNO TEL / DATA OUTLET TO BE PROVIDED WITH 1" CONDUIT U.O.N. TO H.C. AND TERMINATED WITH 90 DEGREE ELBOW AND BUSHING. TEL / DATA OUTLET PLATE SHALL BE PROVIDED WITH 1 1/4" DIAMETER GROMMETED OPENING.	COMM	COMMUNICATION	FIXT	FIXTURE
	CEILING MOUNTED DAYLIGHT SENSOR.			CT	CURRENT TRANSFORMER	FL	FLOOR
WIRING SYSTEMS				CU	COPPER	FLUOR	FLUORESCENT
	POWER OR LIGHTING CIRCUITRY HOMERUN WITH PANELBOARD DESIGNATION, NUMBER WHERE USED INDICATES CIRCUIT NUMBER. IT SHALL CONSISTS OF 1#12 Ø, 1#12 N. & 1#12 G. IN 3/4"C, UNLESS OTHERWISE NOTED.	MOTORS AND CONTROLS		*C	DEGREE CELSIUS	G	GROUND
	POWER OR LIGHTING CIRCUITRY HOMERUN WITH PANELBOARD DESIGNATION, NUMBER WHERE USED INDICATES CIRCUIT NUMBER. IT SHALL CONSISTS OF 2#12 Ø, 2#12 N. & 2#12 G. IN 3/4"C, UNLESS OTHERWISE NOTED.		AC INDOOR UNIT MOTOR AS NOTED WITH LIQUID TIGHT FLEXIBLE CONNECTION WITH JUNCTION BOX AND MOTOR SWITCH.	*F	DEGREE FAHRENHEIT	GFI	GROUND FAULT INTERRUPTER
	POWER OR LIGHTING CIRCUITRY HOMERUN WITH PANELBOARD DESIGNATION, NUMBER WHERE USED INDICATES CIRCUIT NUMBER. IT SHALL CONSISTS OF 3#12 Ø, 3#12 N. & 3#12 G. IN 3/4"C, UNLESS OTHERWISE NOTED.		AC OUTDOOR UNIT MOTOR AS NOTED WITH CONTROLLER AND DISCONNECT SWITCH WITH WEATHER PROOF.	DIA	DIAMETER	GP	GENERAL PURPOSE
	CONDUIT TURNING UP, SEE FLOOR PLANS FOR CONDITIONS.		NON FUSED DISCONNECT SWITCH AMPERAGE, AND NUMBER OF POLES AS NOTED.	DISC	DISCONNECT	HC	HUNG CEILING
	CONDUIT TURNING DOWN, SEE FLOOR PLANS FOR CONDITION.		30A NON FUSED DISCONNECT SWITCH	DN	DOWN	HP	HORSEPOWER
	CONDUIT AND WIRE TO BUILDING GROUND.		60A NON FUSED DISCONNECT SWITCH	DP	DISTRIBUTION PANEL	HWH	HOW WATER HEATER
	CABLE TRAY, WIDTH AND MOUNTING AS NOTED.		100A NON FUSED DISCONNECT SWITCH	DWH	DOMESTIC WATER HEATER	HZ	HERTZ
	UNDERGROUND		200A NON FUSED DISCONNECT SWITCH	DWG	DRAWING	IC	INTERRUPTING CAPACITY
	EXISTING		COMBINATION MAGNETIC STARTER AND DISCONNECT SWITCH, FURNISHED BY HVAC/CONTRACTOR, INSTALLED AND WIRED BY ELECTRICAL CONTRACTOR.	JB	JUNCTION BOX	PP	POWER PANEL
	NEW		FUSED DISCONNECT SWITCH AND FUSE AMPERAGE AS INDICATED. TOP NUMBER DENOTS SWITCH SIZE AND BOTTOM NUMBER DENOTES FUSE.	KCMIL	ONE THOUSAND CIRCULAR MILS	PVC	POLYVINYL CHLORIDE
	CEILING MOUNTED SMOKE DETECTOR.		COMBINATION SOLID–STATE MOTOR STARTER.	KV	KILOVOLT	PWR	POWER
	COMBINATION OF SMOKE AND CO DETECTOR.		MOTORIZED DAMPER.	KVA	KILOVOLT–AMPERES	R	REMOVE
ELECTRICAL DRAWING LIST			FIRE SMOKE DAMPER	KW	KILOWATTS	RE	RELOCATED EXISTING
E0.1	ELECTRICAL SYMBOL LIST, ABBREVIATIONS & GENERAL NOTES		DUPLEX PUMP. NUMBER INDICATES HP RATING OF PUMP.	LP	LIGHTING PANEL	REC	RECEPTACLE
E0.2	ELECTRICAL SPECIFICATIONS SHEET 1 OF 2		THERMAL OVERLOAD SWITCH AT MOTOR. PROVIDE THERMAL ELEMENTS AS PER MOTOR RATING.	LTG	LIGHTING	RGS	RIGID GALVANIZED STEEL
E0.3	ELECTRICAL SPECIFICATIONS SHEET 2 OF 2		MANUAL MOTOR SWITCH	MAX	MAXIMUM	RR	REMOVE & RELOCATE
E1.0	ELECTRICAL LIGHTING PLAN		ELECTRICAL HEATER, NUMBER DENOTES HEATER RATING	MC	MOTOR CONTROLLER	SECT	SECTION
E2.0	ELECTRICAL POWER PLAN	ANNOTATION		MCB	MAIN CIRCUIT BREAKER	SPDT	SINGLE POLE DOUBLE THROW
E3.0	ELECTRICAL DETAILS		INDICATES MOUNTING HEIGHT, CENTER LINE TO FINISHED FLOOR.	MER	MECHANICAL EQUIPMENT ROOM	SPST	SINGLE POLE SINGLE THROW
E4.0	ELECTRICAL PANEL SCHEDULES AND RISER DIAGRAM		KEYED NOTE REFERENCE	MIN	MINIMUM	SPEC	SPECIFICATION
			DETAIL REFERENCE: DETAIL NUMBER INDICATED ON TOP; DRAWING NUMBER INDICATED ON BOTTOM	MLO	MAIN LUGS ONLY	SW	SWITCH
		POWER DISTRIBUTION		MTD	MOUNTED	SWBD	SWITCHBOARD
			MAJOR ELECTRICAL COMPONENT OR DEVICE. VOLTAGE AND AMPERAGE AS NOTED.	MTS	MANUAL TRANSFER SWITCH	SYM	SYMMETRICAL
			BRANCH PANELBOARD, 208Y/120V–SURFACE OR FLUSH MOUNTED	N	NEUTRAL	SYS	SYSTEMS
			DISTRIBUTION PANELBOARD, 208Y/120V–SURFACE OR FLUSH MOUNTED.	NE	NEW DEVICE TO REPLACE EXISTING	TELE	TELEPHONE
				NIC	NOT IN CONTRACT	TEMP	TEMPERATURE
				NL	NIGHT LIGHT	TXF	TOILET EXHAUST FAN
				NTS	NOT TO SCALE	TYP	TYPICAL
				OC	ON CENTER	UON	UNLESS OTHERWISE NOTED
				P	POLES	V	VOLT/VOLTAGE
				PB	PULLBOX	VA	VOLT AMPERE
				PC	PERSONAL COMPUTER	VAV	VARIABLE AIR VOLUME
				ø	PHASE	VFD	VARIABLE FREQUENCY DRIVE
				PNL	PANEL	VP	VAPORPROOF
				W	WATT	WP	WEATHER PROOF
				W	WIRE	XFMR	TRANSFORMER
				WH	WALL HEATER	ZRT	ZONE REGISTER TERMINALS
				E	EXISTING	IG	ISOLATED GROUND

ELECTRICAL SPECIFICATIONS

1. GENERAL:

- A. THE "GENERAL CONDITIONS OF THE CONTRACT FOR CONSTRUCTION," ITS DOCUMENT, LATEST EDITION, AND THESE SPECIFICATIONS AS APPLICABLE ARE PART OF THIS CONTRACT.
- B. DRAWING ARE DIAGRAMMATIC AND INDICATE GENERAL ARRANGEMENT OF SYSTEMS AND WORK. CONDUIT ROUTING IS SHOWN DIAGRAMMATICALLY AND DOES NOT SHOW ALL OFFSETS, DROPS AND RISES OF RUNS. THE CONTRACTOR SHALL ALLOW IN HIS PRICE FOR ROUTING OF CONDUIT TO AVOID OBSTRUCTIONS. COORDINATION WITH EXISTING SERVICES, INCLUDING THOSE OF OTHER TRADES, IS REQUIRED, MAINTAIN HEADROOM AND SPACE CONDITIONS.
- C. BIDDERS, BEFORE SUBMITTING PROPOSALS, SHALL VISIT AND CAREFULLY EXAMINE THE AREA AFFECTED BY THE WORK TO FAMILIARIZE THEMSELVES WITH THE EXISTING CONDITIONS AND THE DIFFICULTIES THAT WILL ATTEND THE EXECUTION OF THIS WORK. SUBMISSION OF A PROPOSAL WILL BE CONSTRUED AS EVIDENCE THAT SUCH AN EXAMINATION HAS BEEN MADE, AND LATER CLAIMS WILL NOT BE RECOGNIZED FOR EXTRA LABOR, EQUIPMENT, OR MATERIALS, REQUIRED BECAUSE OF DIFFICULTIES ENCOUNTERED WHICH COULD HAVE BEEN FORESEEN HAD SUCH AN EXAMINATION BEEN MADE.
- D. INSTALL WORK SO AS TO BE READILY ACCESSIBLE FOR OPERATION, MAINTENANCE AND REPAIR, MINOR DEVIATIONS FROM DRAWING MAY BE MADE TO ACCOMPLISH THIS, BUT CHARGES WHICH INVOLVE EXTRA COST SHALL NOT BE MADE WITHOUT APPROVAL.
- E. REMOVAL AND RELOCATION OF CERTAIN EXISTING WORK MAY BE NECESSARY FOR THE PERFORMANCE OF THE GENERAL WORK. ALL EXISTING CONDITIONS CANNOT BE COMPLETELY DETAILED ON THE DRAWINGS. THE CONTRACTOR SHALL SURVEY THE SITE AND INCLUDE ALL CHANGES AND CHARGES IN MAKING UP THE WORK PROPOSAL.
- F. CONNECTIONS TO EXISTING WORK: INSTALL NEW WORK AND CONNECT TO EXISTING WORK WITH MINIMUM INTERFERENCE TO EXISTING FACILITIES. TEMPORARY SHUTDOWNS OF EXISTING SERVICES SHALL BE PERFORMED AT NO ADDITIONAL CHARGES. AT TIMES NOT TO INTERFERE WITH NORMAL OPERATION OF EXISTING FACILITIES AND ONLY WITH WRITTEN CONSENT OF OWNER. ALARM AND EMERGENCY SYSTEMS SHALL NOT BE INTERRUPTED. MAINTAIN CONTINUOUS OPERATION OF EXISTING FACILITIES AS REQUIRED WITH NECESSARY TEMPORARY CONNECTIONS BETWEEN NEW AND EXISTING WORK. CONNECT NEW WORK TO EXISTING WORK IN NEAT AND ACCEPTABLE MANNER. RESTORE EXISTING DISTURBED WORK TO ORIGINAL CONDITION, INCLUDING MAINTENANCE OF WIRING CONTINUITY AS REQUIRED.
- G. DISCONNECT, REMOVE AND/OR RELOCATE EXISTING MATERIAL, EQUIPMENT AND OTHER WORK AS NOTED OR REQUIRED FOR PROPER INSTALLATION OF NEW WORK.
- H. THE CONTRACTOR SHALL KEEP ALL EQUIPMENT AND MATERIALS, AND ALL PARTS OF THE BUILDING, EXTERIOR SPACES AND ADJACENT STREETS, SIDEWALKS AND PAVEMENTS, FREE FROM MATERIAL AND DEBRIS RESULTING FROM THE EXECUTION OF THIS WORK. EXCESS MATERIALS WILL NOT BE PERMITTED TO ACCUMULATE EITHER ON THE INTERIOR OR THE EXTERIOR.
- I. SEAL OPENINGS THROUGH PARTITIONS, WALLS AND FLOORS WITH MINERAL WOOL OR OTHER NONCOMBUSTIBLE MATERIAL, UNLESS OTHERWISE NOTED.
- J. PROVIDE ALL NECESSARY FLASHING AND COUNTER FLASHING TO MAINTAIN THE WATERPROOFING INTEGRITY OF THE BUILDING AS REQUIRED BY THE INSTALLATION OR REMOVAL OF CONDUIT AND EQUIPMENT, PROVIDE EQUIPMENT CURBS AS REQUIRED.
- K. ALL EXISTING MATERIAL, EQUIPMENT AND CONSTRUCTION DEBRIS TO BE REMOVED UNDER THIS CONTRACT SHALL BECOME THE PROPERTY OF THE CONTRACTOR WITH THE EXCEPTION OF SPECIFIC EQUIPMENT AND APPARATUS REQUESTED BY THE BUILDING REPRESENTATIVE, ARCHITECT OR AS NOTED TO BE RELOCATED ON THE DRAWINGS. REMOVED EQUIPMENT SHALL BE PROPERLY DISPOSED OF BY THIS CONTRACTOR.
- L. THE CONTRACTOR'S PROPOSAL FOR ALL WORK SHALL BE PREDICATED ON THE PERFORMANCE OF THE WORK DURING REGULAR WORKING HOURS. WHEN SO DIRECTED, HOWEVER, THE CONTRACTOR SHALL INSTALL WORK DURING OVERTIME HOURS, AND THE ADDITIONAL COST TO BE CHARGED THEREFORE SHALL BE ONLY THE "PREMIUM" PORTION OF THE WAGES PAID.
- M. UNLESS OTHERWISE SPECIFICALLY NOTED OR SPECIFIED, INCLUDE ALL CUTTING AND PATCHING OF EXISTING FLOORS, WALLS, PARTITIONS AND OTHER MATERIALS IN THE EXISTING BUILDING. THE CONTRACTOR SHALL RESTORE THESE AREAS TO ORIGINAL CONDITION.
- N. ALL MATERIAL AND EQUIPMENT SHALL BE NEW UNLESS OTHERWISE NOTED AND SHALL BE IN ACCORDANCE WITH BUILDING STANDARDS.
- O. INSURANCE: PROVIDE IN ACCORDANCE WITH OWNER/BUILDING REQUIREMENTS AND SHALL INCLUDE A HOLD HARMLESS CLAUSE FOR OWNER AND ENGINEER.
- P. THE FINAL ACCEPTANCE SHALL BE MADE AFTER THE CONTRACTOR HAS ADJUSTED HIS EQUIPMENT, TESTED THE VARIOUS SYSTEMS, DEMONSTRATED THAT IT FULFILLS THE REQUIREMENTS OF THE DRAWINGS AND SPECIFICATIONS AND HAS FURNISHED ALL THE REQUIRED CERTIFICATED OF INSPECTION AND APPROVAL.

2. GENERAL PROVISIONS FOR ELECTRICAL WORK:

A. DEFINITIONS:

- 1) "PROVIDE": TO FURNISH, INSTALL AND CONNECT UP COMPLETE AND READY FOR SAFE AND REGULAR OPERATION THE PARTICULAR WORK REFERRED TO UNLESS SPECIFICALLY OTHERWISE NOTED.
- 2) "INSTALL": TO ERECT, MOUNT AND CONNECT COMPLETE WITH RELATED ACCESSORIES.
- 3) "FURNISH" OR "SUPPLY": TO PURCHASE, PROCURE, ACQUIRE, AND DELIVER COMPLETE WITH RELATED ACCESSORIES.
- 4) "WORK": LABOR, MATERIALS, EQUIPMENT, APPARATUS, CONTROLS, ACCESSORIES AND OTHER ITEMS REQUIRED FOR PROPER AND COMPLETE INSTALLATION.
- 5) "WIRING": RACEWAY, FITTINGS, WIRE, BOXES, AND RELATED ITEMS.
- 6) "CONCEALED": EMBEDDED IN MASONRY OR OTHER CONSTRUCTION, INSTALLED IN FURRED SPACES, WITHIN DOUBLE PARTITIONS OR HUNG CEILINGS, IN TRENCHES, IN CRAWL SPACES, OR IN ENCLOSURES.
- 7) "EXPOSED": NOT INSTALLED UNDERGROUND OR "CONCEALED" AS DEFINED ABOVE.
- 8) "SIMILAR" OR "EQUAL": EQUAL IN MATERIALS, WEIGHT, SIZE, DESIGN AND EFFICIENCY OF SPECIFIED PRODUCT.

- B. TEMPORARY LIGHT AND POWER: PROVIDE TEMPORARY LIGHT AND POWER SYSTEMS AT EARLIEST POSSIBLE DATE WITHIN THE CONSTRUCTION AREAS FOR THE REQUIREMENTS OF ALL TRADES AS HEREIN DESCRIBED. EXTEND SYSTEMS TO NEW CONSTRUCTION AS SOON AS PHYSICALLY POSSIBLE. MAINTAIN SYSTEM DURING WORKING OWNER. PROVIDE ALL REQUIRED MAINTENANCE, INCLUDING LAMPS AND SOCKETS.

C. QUALITY ASSURANCE

- 1) QUALITY OF MATERIALS: ALL EQUIPMENT SHALL BE NEW SPECIFICATION GRADE, FREE FROM DEFECTS AND LISTED BY APPROVED TESTING AGENCY AND BEARING THEIR LABEL MATERIALS AND EQUIPMENT OF SIMILAR APPLICATION SHALL BE OF SAME MANUFACTURER, EXCEPT AS NOTED.

- 2) GUARANTEE: ALL MATERIALS AND WORKMANSHIP SHALL BE GUARANTEED AS DEFINED IN PARAGRAPH 2.C.

3) CURRENT CHARACTERISTICS:

- a. SERVICE: 120/208 VOLT, 3 PHASE, 4 WIRE, 60 HERTZ WITH GROUNDED NEUTRAL.
- b. DISTRIBUTION: 120/208 VOLT, 3 PHASE, 4 WIRE, 60 HERTZ WITH GROUNDED NEUTRAL.

4) HEIGHTS OF OUTLETS:

- a. FROM FINISHED FLOOR TO CENTERLINE OF OUTLETS FOR:
- RECEPTACLES AND TELEPHONES: 1 FT-6 IN.
 - WALL SWITCHES: 4 FT-0 IN.
 - WALL FIXTURES: 7 FT-0 IN.
 - MOTOR CONTROLLERS: 5 FT-0 IN.
 - CLOCKS: 7 FT 6 IN
- b. EXCEPTIONS: AT JUNCTION OF DIFFERENT WALL FINISH MATERIALS, ON MOLDING OR BREAK IN WALL SURFACE, IN VIOLATION OF CODE, OR AS NOTED OR DIRECTED.

D. PRODUCT DELIVERY, STORAGE AND HANDLING

- 1) MOVING OF EQUIPMENT: WHERE NECESSARY, SHIP IN CARTED SECTIONS OF SIZE TO PERMIT PASSING THROUGH AVAILABLE SPACES.
- 2) ACCESSIBILITY: FOR OPERATION, MAINTENANCE AND REPAIR, MINOR DEVIATIONS SHALL BE PERMITTED, CHANGES OF MAGNITUDE OR INVOLVING EXTRA COST ARE NOT PERMISSIBLE WITHOUT REVIEW. GROUP CONCEALED ELECTRICAL EQUIPMENT REQUIRING ACCESS WITH EQUIPMENT FREELY ACCESSIBLE THROUGH ACCESS DOORS.

E. MATERIALS

- 1) NAMEPLATES: PROVIDE BLACK LAMICOID SHEET WITH 3/4 IN. WHITE LETTERING, FASTENED WITH EPOXY CEMENT FOR EACH DISCONNECT SWITCH, CIRCUIT BREAKER, PANEL, CABINET, TRANSFORMER, ENCLOSURE, MOTOR CONTROLLER AND THE LIKE. NAMEPLATES SHALL DESCRIBE THE NAME AND NUMBER OF EACH COMPONENT.
- 2) CABLE TAGS: TAG EACH CONDUCTOR PASSING THROUGH SPLICE OR PULLBOX WITH A WHITE LINEN TAG, INDICATING POINT OF ORIGIN AND TERMINATION OF THE CIRCUIT.
- 3) INSERTS AND SUPPORTS:
- a. INSERTS: STEEL, SLOTTED TYPE, FACTORY PAINTED.
- SINGLE ROD: SIMILAR TO GRINNELL FIG. 281.
 - MULTI-ROD: SIMILAR TO FEE AND MASON SERIES 9000 WITH END CAPS AND CLOSURE STRIPS.
 - CLIP FORM NAILS FLUSH WITH INSERTS.
 - MAXIMUM LOADING 75 PERCENT OF RATING.
- b. SUPPORTS FROM BUILDING CONSTRUCTION: INSERTS, BEAM CLAMPS, STEEL FISHPLATES (IN CONCRETE FILL ONLY), CANTILEVER BRACKETS OR OTHER MEANS. SUBMIT FOR REVIEW.
- c. GROUPED LINES AND SERVICES: TRAPEZE HANGERS OF BOLTED ANGLES OR CHANNELS.
- d. WHERE BUILDING CONSTRUCTION IS INADEQUATE: PROVIDE ADDITIONAL FRAMING. SUBMIT FOR REVIEW.

- F. PAINT SHALL BE THE BEST GRADE FOR ITS PURPOSE. DELIVER IN ORIGINAL SEALED CONTAINERS AND APPLY IN ACCORDANCE WITH MANUFACTURER'S INSTRUCTIONS. COLORS SHALL BE AS SELECTED BY ARCHITECT OR ENGINEER. UTILIZE GALVANIZED IRON PRIMER ON PANEL AND PULL BOXES, AFTER FABRICATION. UTILIZE HOT DIPPED GALVANIZED OR DIPPED IN ZINC BASED PRIMER FOR: OUTLET BOXES, JUNCTION BOXES, CONDUIT HANGERS, RODS, INSERTS AND SUPPORTS. ZINC BASED PRIMER WITH FINISH TO MATCH SURROUNDINGS SHALL BE USED FOR MARRED SURFACES OF STEEL EQUIPMENT AND RACEWAYS. A FIELD-APPLIED ZINC BASED PRIME COAT SHALL BE UTILIZED FOR STEEL OR IRONWORK.

- G. BRUSH AND CLEAN WORK PRIOR TO CONCEALING, PAINTING AND ACCEPTANCE. PAINTED EXPOSED WORK SOILED OR DAMAGED; CLEAN AND REPAIR TO MATCH ADJOINING WORK BEFORE FINAL ACCEPTANCE. REMOVE DEBRIS FROM INSIDE AND OUTSIDE OF MATERIAL AND EQUIPMENT.

- H. FINAL LOCATIONS AND MOUNTING ORIENTATIONS OF ALL SWITCHES, RECEPTACLES AND LIGHT FIXTURES SHALL BE VERIFIED WITH ARCHITECT.

- I. ALL ACCESS DOOR LOCATIONS SHALL BE REVIEWED BY ARCHITECT PRIOR TO INSTALLATION.

3. SCOPE OF WORK:

- A. SCOPE OF WORK SHALL CONSIST OF PROVIDING LABOR, MATERIALS, EQUIPMENT, SERVICES AND FEES NECESSARY FOR COMPLETE AND SAFE INSTALLATION IN CONFORMING WITH THE NATIONAL ELECTRICAL CODE (NEC), AND ALL OTHER APPLICABLE INDUSTRY, NATIONAL AND LOCAL CODES AND AUTHORITIES HAVING JURISDICTION, AS INDICATED ON DRAWINGS AND HEREIN SPECIFIED.

- B. ALL DRAWINGS, PLANS, DETAILS, SPECIFICATIONS AND SPECIFICATION ADDENDA ARE MADE PART OF THIS CONTRACT AND SHALL APPLY TO ALL WORK UNDER THE CONTRACT UNLESS OTHERWISE AMENDED, MODIFIED, SUPPLIED OR SPECIFIED HEREIN.

- C. THE CONTRACTOR SHALL FURNISH A WRITTEN GUARANTEE TO REPLACE OR REPAIR PROMPTLY AND ASSUME RESPONSIBILITY FOR ALL EXPENSES INCURRED FOR ANY WORKMANSHIP AND EQUIPMENT IN WHICH DEFECTS DEVELOP WITHIN ONE YEAR FROM THE DATE OF FINAL CERTIFICATE FOR PAYMENT AND/OR FROM DATE OR ACTUAL USE OF EQUIPMENT OR OCCUPANCY OF SPACES BY OWNER INCLUDED UNDER THE VARIOUS PARTS OF THE WORK, WHICHEVER, DATE IS EARLIER, THIS WORK SHALL BE DONE AS DIRECTED BY THE OWNER. THIS GUARANTEE SHALL ALSO PROVIDED THAT WHERE DEFECTS OCCUR, THE CONTRACTOR WILL ASSUME RESPONSIBILITY OF OTHER TRADES AFFECTED BY DEFECTS, REPAIRS OR REPLACEMENTS IN EQUIPMENT SUPPLIED BY THE CONTRACTOR.

- D. THE CONTRACTOR SHALL GIVE NECESSARY NOTICE, FILE DRAWINGS AND SPECIFICATIONS WITH ALL DEPARTMENTS HAVING JURISDICTION, WORK AND PAY ALL FEES THEREFOR. THE CONTRACTOR SHALL ARRANGE FOR INSPECTION AND TESTS OF ANY OR ALL PARTS OF THE WORK IF SO REQUIRED BY AUTHORITIES AND PAY ALL CHARGES FOR SAME. THE CONTRACTOR SHALL PAY ALL COSTS FOR, AND FURNISH TO THE OWNER BEFORE FINAL BILLING, ALL CERTIFICATES NECESSARY AS EVIDENCE THAT THE WORK INSTALLED CONFORMS WITH ALL REGULATIONS WHERE THEY APPLY TO THIS WORK.

- E. CONTRACTOR SHALL PERFORM ALL CONTROLLED INSPECTIONS IN ACCORDANCE WITH THE BUILDING CODE. SECURE ALL REQUIRED PERMITS AND APPROVALS AND TRANSMIT SAME TO OWNER. CONTRACTOR SHALL BE RESPONSIBLE FOR ALL FEES.

- F. AREAS WITH NO ELECTRICAL WORK SHALL REMAIN AS IS. CONTRACTOR SHALL MAINTAIN CONTINUITY OF ALL ELECTRICAL SYSTEMS TO ALL AREAS NOT COVERED BY THIS RENOVATION AND SHALL PROVIDE 48 HOUR NOTICE TO LANDLORD OF ANY PLANNED POWER INTERRUPTIONS OR SIGNAL SYSTEM OUTAGES.

4. SHOP DRAWINGS

- A. PRIOR TO THE INSTALLATION OF ANY WORK AND PROCUREMENT OF EQUIPMENT, CONTRACTOR SHALL PROVIDE COMPLETE SETS OF COORDINATED SHOP DRAWINGS OF ALL NEW AND EXISTING EQUIPMENT, INDICATING CAPACITY, DIMENSIONS AND SEQUENCE OF OPERATION FOR WRITTEN APPROVAL BY THE ARCHITECT AND ENGINEER.

B. INDICATE ON EACH SHOP DRAWINGS SUBMITTED:

- 1) PROJECT NAME AND LOCATION
- 2) NAME OF ARCHITECT AND ENGINEER
- 3) ITEM IDENTIFICATION
- 4) APPROVAL STAMP OF PRIME CONTRACTOR

C. SUBMISSIONS:

- 1) SUBMISSIONS 11 IN. X 17 IN. OR SMALLER: IF THE SUBMISSION IS A CATALOG CUT, THEN THE CONTRACTOR SHALL SUBMIT ONE ORIGINAL AND TWO COPIES. OTHERWISE, HE SHALL SUBMIT THREE COPIES. THE ARCHITECT WILL FORWARD THE ORIGINAL AND ONE COPY (TWO COPIES WHEN NO ORIGINAL IS RECEIVED) TO THE ENGINEER. ALL CATALOG CUTS SHALL BE COMPLETE.
- 2) SUBMISSIONS LARGER THAN 11 IN. X 17 IN.: SUBMIT TWO PRINTS AND ONE PAPER SEPIA TO THE ARCHITECT. THE ARCHITECT WILL FORWARD ONE PRINT AND THE PAPER SEPIA TO THE ENGINEER.

D. SUBMIT SHOP DRAWINGS FOR THE FOLLOWING:

- 1) SAFETY/DISCONNECT SWITCHES
- 2) FUSES
- 3) CIRCUIT BREAKERS
- 4) PANELBOARDS/LOADCENTER (INCLUDING DIMENSIONS, SCHEDULES, AND CATALOG CUTS).
- 5) RACEWAYS
- 6) WIRE AND CABLE
- 7) WALL SWITCHES
- 8) INSERTION RECEPTACLES
- 9) MOMENTARY CONTACT SWITCHES
- 10) TIME SWITCHES
- 11) LIGHTING FIXTURES.

- E. ASSIST AND PROVIDE ALL NECESSARY INFORMATION, DIAGRAMS, SKETCHES, ETC. TO THE HVAC CONTRACTOR, FOR THE PREPARATION OF COORDINATED SHOP DRAWINGS INDICATING ROUTING OF FEEDERS, CONTROL, CONDUITS, RECESSED FIXTURES AND ADJACENT NEARBY PIPING AND DUCTWORK WHERE APPLICABLE. CERTIFIED BY ALL TRADES THAT COORDINATION HAS BEEN ESTABLISHED. SUBMIT FOUR(4) BOOKBOUND OPERATING AND SERVICE MANUALS WHICH SHALL INCLUDE COPIES OF ALL SHOP DRAWING. PROVIDE SHOP DRAWINGS FOR PANELS, FIXTURES, WIRING DEVICES, CONDUIT, CABLE, DISCONNECT SWITCH, REEYS, CONTRACTORS AND OTHER SYSTEMS AS DIRECTED BY THE ENGINEER.

5. AS-BUILT DRAWINGS AND EQUIPMENT OPERATIONAL INSTRUCTIONS

- A. UPON COMPLETION AND ACCEPTANCE OF WORK, CONTRACTOR SHALL FURNISH WRITTEN INSTRUCTIONS AND EQUIPMENT MANUALS AND DEMONSTRATE TO THE OWNER THE PROPER OPERATION AND MAINTENANCE OF ALL EQUIPMENT AND APPARATUS FURNISHED UNDER THIS CONTRACT.

- B. THESE INSTRUCTIONS SHALL BE TYPED ON 8-1/2 IN. X 11 IN. PAPER AND BOUND IN THREE RING BINDERS WITH CLEAR ACETATE COVERS. CONTRACTOR SHALL GIVE THREE COPIES OF THE INSTRUCTIONS TO THE OWNER AND ONE COPY TO THE ENGINEER.

- C. THE INSTRUCTION BOOKLET SHALL BEAR THE NAME, ADDRESS AND TELEPHONE NUMBER OF THE PROJECT, ARCHITECT AND ENGINEER.

- D. REPRODUCIBLE "AS-BUILT" DRAWINGS SHALL BE PROVIDED INDICATING THE AS INSTALLED CONDITIONS OF THE WORK. "AS-BUILT" DRAWINGS SHALL BE PROVIDED TO THE ARCHITECT AFTER COMPLETION OF THE INSTALLATION.

6. LOW-VOLTAGE DISTRIBUTION EQUIPMENT:

- A. PROVIDE COMPLETE EQUIPMENT INCLUDING: SWITCHES, FUSES, CIRCUIT BREAKERS, PANELS AND TRANSFORMERS.
- B. ALL EQUIPMENT SHALL CONFORM TO NEMA, ANSI AND IEEE STANDARDS.
- C. DISCONNECT SWITCHES SHALL BE FUSED OR NONFUSED AS NOTED. VOLTAGE SHALL BE AS REQUIRED. SWITCHES SHALL BE HEAVY DUTY, EXCEPT AS NOTED, AND HORSEPOWER RATED FOR MOTOR LOADS. TOGGLE TYPE SWITCHES SHALL BE NONFUSED. LOAD BREAK, HAVING MAXIMUM RATINGS OF 20 AMP AT 600 VOLTS AND 30 AMP AT 240 VOLTS. TWO-POLE SWITCHES SHALL BE SIMILAR TO HART AND HEGBMAN NO. 6808F. THREE-POLE SWITCHES SHALL BE SIMILAR TO HART AND HEGBMAN NO. 7810F. KNIFE-BLADE TYPE SWITCHES SHALL BE LOAD BREAK, QUICK-MAKE, QUICK-BREAK, UL CLASS R UP TO 600 AMP. MAXIMUM RATING EXCEPT AS NOTED SHALL BE 800 AMP. ARC QUENCHERS SHALL BE PROVIDED. SWITCHES SHALL BE SIMILAR TO GENERAL ELECTRIC QMR. ALL SWITCH ENCLOSURES SHALL BE DEAD FRONT, NEMA TYPE 1, EXCEPT AS NOTED.

7. FUSES:

- A. CIRCUITS 0 TO 800 AMPERES SHALL BE PROTECTED BY FUSES SIMILAR TO CURRENT LIMITING BUSSMANN LOW-PEAK DUAL-ELEMENT TIME-DELAY LPN-RK (AMP)SP (250V) /LPS-RK (AMP)SP (600V) OR LPJ (AMP)SP (600V) (UL CLASS RK1 OR CLASS J), AND BE LISTED BY UL WITH AN INTERRUPTING RATING OF 300,000 AMPERES RMS SYMMETRICAL.
- B. MOTOR CIRCUITS - ALL INDIVIDUAL MOTOR CIRCUITS WITH FULL LOAD AMPERE RATINGS (FLA) OF 480 AMPERES OR LESS SHALL BE PROTECTED BY FUSES SIMILAR TO CURRENT LIMITING BUSSMANN LOW-PEAK DUAL-ELEMENT TIME-DELAY LPN-RK (AMP)SP (250V) /LPS-RK (AMP)SP (600V) OR LPJ (AMP)SP (600V) (UL CLASS RK1 OR CLASS J), AND BE LISTED BY UL WITH AN INTERRUPTING RATING OF 300,000 AMPERES RMS SYMMETRICAL.
- C. ALL FUSES SHALL BE PROVIDED BY SAME MANUFACTURER.
- D. PROVIDE 1 SPACE MATCHING FUSE FOR EACH SET OF 3.

- E. CIRCUIT BREAKERS: MOLDED CASE BREAKERS SHALL BE THERMAL-MAGNETIC, QUICK-MAKE-QUICK-BREAK, BOLT-ON TYPE, MANUALLY OPERATED WITH INSULATED TRIP-FREE HANDLE. MULTI-POLE TYPE BREAKERS SHALL CONTAIN INTERNAL TRIP BAR. TERMINALS SHALL BE SUITABLE FOR COPPER OR ALUMINUM CABLE. FURNISH AUXILIARY DEVICES WHERE REQUIRED FOR SHUNT-TRIPPING, OPEN AND CLOSE MOTOR OPERATOR AND ALARM INDICATION. ENCLOSURES SHALL BE DEAD FRONT, NEMA TYPE 1, EXCEPT AS NOTED. FRAMES, IC AND INTERCHANGEABLE TRIPS SHALL BE AS FOLLOWS, UNLESS OTHERWISE NOTED:

- 1) 120 VOLTS, 100-AMP FRAME: 10,000 AMPS, 1 POLE.
- 2) 120/240 VOLTS, 225-AMP FRAME: 22,000 AMPS MINIMUM

8. DISTRIBUTION PANELBOARDS, CIRCUIT BREAKER TYPE:

- A. THREE PHASE, 4 OR 5 WIRE, COPPER BUS BARS, WITH 2, 3, OR 4 WIRE BRANCHES, AS NOTED. CAPACITY OF PANEL AND CIRCUITS, AS NOTED BELOW. PANELBOARD TO HAVE GROUND BUS SAME SIZE AS PHASE BUSES.
- B. CABINETS: CODE GAUGE GALVANIZED SHEET STEEL PRIMED AND PAINTED WITH TRIM AND DOOR, TYPE AS NOTED, LAP AND RIVET CORNERS OR FORM AS APPROVED.
- C. TRIM: ONE PIECE FULL FINISH PRIMED AND PAINTED SHEET STEEL. TRIM SHALL BE MOUNTED WITH A CONTINUOUS PIANO HINGE CONFIGURED IN SUCH A MANNER THAT IT SHALL BE POSSIBLE TO GAIN FULL ACCESS TO CIRCUIT BREAKERS AND WIRING GUTTERS WITHOUT REMOVING THE TRIM. PROVIDE A MULTI-PIN CYLINDER LOCK (YALE, CORBIN OR EQUAL) TO LATCH THE TRIM. KEYS SHALL BE MILLED.
- D. HARDWARE: MULTI-PIN, CYLINDER LOCKS WITH MILLED KEYS. ALL PANELS SHALL BE KEYPED ALIKE. DOOR OVER 48" HIGH SHALL BE EQUIPPED WITH A CHROME PLATED VAULT HANDLE, BUILT-IN LOCK AND 3-POINT CATCH FASTENING DOOR AT TOP, BOTTOM AND CENTER.
- E. HINGES: CONCEALED, CONTINUOUS PIANO HINGE AS DESCRIBED ABOVE.
- F. DIRECTORY HOLDER: MEAL FRAME WITH NONBREAKABLE TRANSPARENT COVER AND DIRECTORY CARD. ENTRIES TO BE TYPEWRITTEN BY ELECTRICAL CONTRACTOR. PROVIDE AN ENGRAVED LAMINATED NAMEPLATE ADJACENT TO EACH BRANCH BREAKER. MOUNT WITH SELF TAPPING MACHINE SCREWS.
- G. FURNISH MULTI-CABLE LUGS WHERE REQUIRED. DOUBLE LUGGING NOT PERMITTED. SECURE LUGS TO BUS BY STUD BOLTS.
- H. PANELBOARD CONSTRUCTION FOR BOLTED TYPE BREAKERS. MINIMUM SHORT CIRCUIT RATING 25,000 AMPERES, RMS SYMMETRICAL FOR ALL 120/208V APPLICATIONS. INDIVIDUAL CIRCUIT BREAKERS SHALL HAVE MINIMUM 100A FRAME, TRIPS SIZED AS SHOWN ON THE PLANS.
- I. MINIMUM GUTTER SPACES: PANELS WITH 225 AMPERE MAINS, 5-3/4" MINIMUM, 400 AMPERES AND OVER, MINIMUM GUTTERS 8". FOR PANELS WITH THROUGH FEEDERS, INCREASE GUTTER WIDTH BY 2" MINIMUM AND PROVIDE A SHEET STEEL BARRIER BETWEEN THE PANEL GUTTER AND THE THROUGH FEEDER PORTION OF THE BACK BOX. BRANCH CIRCUIT BREAKERS SHALL BE MECHANICALLY INTERLOCKED WHEN SHOWN ON DRAWINGS.
- J. DISTRIBUTION AND SUB-DISTRIBUTION PANELBOARDS SHALL BE A MINIMUM OF 30" WIDE AND 10" DEEP.
- K. PANELBOARD SHALL HAVE MAIN CIRCUIT BREAKER OR MAIN LUGS AS INDICATED ON THE DRAWINGS. QUANTITY, POLES AND TRIP RATINGS OF BRANCH CIRCUIT BREAKERS TO BE AS INDICATED ON DRAWINGS.
- L. PANELBOARD SHALL HAVE ENGRAVED WHITE CORE, BLACK LAMACOID NAMEPLATE SCREWED ONTO PANE TRIM WITH DESIGNATION LISTED (PANELBOARD NAME, VOLTAGE, RATING OR MAINS IN AMPS).

8. DISTRIBUTION PANELBOARDS, SWITCH AND FUSE:

- A. THREE PHASE, 3 OR 4 WIRE WITH COPPER BUS BARS. ALL THROUGH BUS SHALL BE INSULATED.
- B. NEMA CLASS 1 CONSTRUCTION TO ACCOMMODATE FUSIBLE, INDIVIDUALLY ENCLOSED SWITCHES, FRONT REMOVABLE, SWITCH AND DOOR INTERLOCKS. COVERS TO BE PAD-LOCKABLE.
- C. PANELBOARD SHALL BE CONSTRUCTED OF CODE-GAUGE STEEL, GRAY FINISH OVER RUST INHIBITOR, FOR SURFACE MOUNTING. BOX AND PANEL FRAME SHALL BE FLANGED AND REINFORCED FOR RIGID SUPPORT OF INTERIOR AND ACCURATE ALIGNMENT OF INTERIOR WITH FRONT. TRIMS TO BE FASTENED TO BACK BOX WITH SCREWS.
- D. ALL BRANCH SWITCHES SHALL HAVE INDIVIDUAL ENGRAVED LAMICOID NAMEPLATES (BLACK WITH WHITE CORE).
- E. DISTRIBUTION PANELBOARD CONSTRUCTION MINIMUM SHORT CIRCUIT RATING 25,000 AMPERES, RMS SYMMETRICAL FOR ALL 120/208V APPLICATIONS. APPLICATIONS.
- F. DISCONNECTS
- 1) DISCONNECT SWITCHES SHALL CONFORM TO NEMA AND UL STANDARDS, AND SHALL BE HORSEPOWER RATED.
- 2) SWITCHING MECHANISM SHALL BE QUICK-MAKE, QUICK-BREAK, SINGLE THROW WITH EXTERNAL OPERATING HANDLE MECHANICALLY INTERLOCKED WITH ENCLOSURE COVER TO PROVIDE ACCESS TO INTERIOR WHEN DISCONNECT IS IN OFF POSITION ONLY. PROVIDE MEANS TO LOCK OPERATING HANDLE IN THE OPEN AND CLOSED POSITION. DESIGNATE ON THE ENCLOSURE THE OPEN AND CLOSED POSITION OF THE OPERATING HANDLE.
- 3) SWITCHES SHALL BE OF THE DOUBLE STATIONARY CONTACT TYPE.
- 4) SWITCHES SHALL BE EQUIPPED WITH REJECTION TYPE FUSE HOLDERS, FUSIBLE AS SHOWN ON THE DRAWINGS; PROVIDE COMPLETE WITH FUSES AS SCHEDULED.

G. INSTALLATION

- 1) DISTRIBUTION PANELBOARD SHALL BE MOUNTED TO STRUCTURAL STEEL CHANNEL (KINDORF) WHICH SHALL BE BOLTED TO THE WALL USING EXPANSION ANCHORS FOR LARGE PANELS.

H. IDENTIFICATION

- 1) PROVIDE NAMEPLATE AT EACH SWITCH IDENTIFYING THE LOAD SERVED.
- 2) NAMEPLATES SHALL BE MOUNTED ON THE FRONT COVER SECURED WITH SELF-TAPPING SCREWS OR NUTS AND BOLTS. NAMEPLATES SHALL BE LAMINATED PHENOLIC, BLACK WITH A MINIMUM OF 1/4" HIGH WHITE LETTERING.
- I. DISTRIBUTION AND SUB-DISTRIBUTION PANELBOARDS SHALL BE A MINIMUM OF 30" WIDE AND 10" DEEP.
- J. POWER PANELBOARDS SHALL BE SIMILAR TO GENERAL ELECTRIC TYPE "QMR", AS MANUFACTURED BY ATLAS SWITCH COMPANY, ELECTRIC SWITCHBOARD COMPANY OR APPROVED EQUAL.
- K. PANELBOARD SHALL HAVE MAIN CIRCUIT BREAKER OR MAIN LUGS AS INDICATED ON THE DRAWINGS. QUANTITY, POLES AND TRIP RATINGS OF BRANCH CIRCUIT BREAKERS TO BE AS INDICATED ON DRAWINGS.
- L. PANELBOARD SHALL HAVE ENGRAVED WHITE CORE, BLACK LAMACOID NAMEPLATE SCREWED ONTO PANE TRIM WITH DESIGNATION LISTED (PANELBOARD NAME, VOLTAGE, RATING OR MAINS IN AMPS).

B. MATERIALS

1) RACEWAYS:

- a. RIGID STEEL CONDUIT: FULL-WEIGHT PIPE, GALVANIZED, THREADED.
- b. ELECTROMETALLIC TUBING (EMT): THIN WALL PIPE, GALVANIZED, THREADLESS.
- c. FLEXIBLE STEEL CONDUIT: CONTINUOUS SINGLE STRIP, GALVANIZED.
- d. WIREWAYS: WIRE SHALL BE AS NOTED, MINIMUM NO. 16 GAUGE STEEL WITH GROUND CONTINUITY. FINISH SHALL BE BAKED ENAMEL. COVERS SHALL BE SCREW-ON.

- e. SURFACE METAL RACEWAY: SIZE AS NOTED. BASE 0.04 IN., COVER 0.25 IN. MATERIAL SHALL BE STEEL. FINISH SHALL BE BAKED ENAMEL. COVERS SHALL BE SCREW-ON.

2) FITTINGS AND ACCESSORIES:

- a. RIGID STEEL: NONSPLIT, THREADED, STEEL OR MALLEABLE IRON. ZINC DIE CAST NOT PERMITTED.
- b. ELECTROMETALLIC TUBING: COMPRESSION TYPE. GALVANIZED RIGID STEEL ELBOWS, 2 IN. OR LARGER.
- c. FLEXIBLE METALLIC CONDUIT: ANGLE WEDGE TYPE WITH INSULATED THROAT.
- d. BUSHINGS: METALLIC INSULATED TYPE.

ELECTRICAL SPECIFICATIONS (CONT.)

3) BOXES:

a. OUTLET BOXES: EXCEPT AS OTHERWISE REQUIRED BY CONSTRUCTION, DEVICES OR WIRING, BOXES SHALL BE STAMPED STEEL, 4 IN. SQUARE OR OCTAGON FOR FIXTURES. BOXES ABOVE CEILING SHALL BE 1-1/2 IN. DEEP. BOXES IN CEILING OR SLAB SHALL BE 3 IN. DEEP. BOXES IN WALL FOR FIXTURES SHALL BE 2-3/4 IN. DEEP. BOXES IN WALL FOR RECEPTACLES AND SWITCHES SHALL BE 1-1/2 IN. DEEP. FURNISH WITH RAISED COVERS AND FIXTURE STUDS WHERE REQUIRED. WITHOUT FIXTURE OR DEVICE: FURNISH BLANK COVER. OFFSET BACK-TO-BACK OUTLETS WITH MINIMUM 6 IN. SEPARATION.

b. JUNCTION AND PULL BOXES: GALVANIZED SHEET STEEL WITH SCREW-ON COVERS, EXCEPT AS NOTED, FURNISH WITH INSULATED SUPPORTS FOR CABLES. LOCATIONS SHALL BE AS NOTED OR REQUIRED AND ACCESSIBLE. PROVIDE BARRIERS IN NEW AND RENOVATED BOXES BETWEEN 120/208 VOLT AND 265/460 VOLT WIRING AND BETWEEN EMERGENCY AND NORMAL WIRING. FLOOR BOXES SHALL BE SUITABLE FOR CONDUIT AND DEVICES NOTED. RAISED OUTLETS SHALL BE HUBBELL #B2414 SERIES WITH ABOVE FLOOR FITTING. TELEPHONE: BUSHED HOLE. POWER: DUPLEX RECEPTACLE OR OTHER AS NOTED. INCREASE SIZE TO SUIT AS NECESSARY. FLUSH OUTLETS SHALL BE HUBBELL #B2414 SERIES WITH FLUSH FLOOR FITTING FOR TELEPHONE AND FLUSH DUAL FLAP COVER WITH DUPLEX RECEPTACLE FOR POWER AS NOTED. INCREASE SIZE TO SUIT AS NECESSARY.

C. PROVIDE RACEWAYS ONLY AS HEREIN SPECIFIED, EXCEPT AS NOTED. RACEWAYS SHALL BE RUN CONCEALED, EXCEPT AS NOTED.

PROVIDE RACEWAY SUPPORT UTILIZING CEILING TRAPEZE, STRAP HANGERS, OR WALL BRACKETS. PROVIDE U-BOLTS AT EACH FLOOR LEVEL OF RISER RACEWAYS AND CONNECTED TO ACCEPTABLE SUPPORTS. PROVIDE RISER CLAMPS AT EACH FLOOR LEVEL OF RISER RACEWAYS AND RESTING ON SLAB. FOR THROUGH-THE-FLOOR SYSTEMS, UTILIZE AN ASSEMBLY SIMILAR TO HUBBELL FIRE RATED POKE-THROUGH-FLOOR BOX SYSTEM. FOR ABOVE FLOOR FITTINGS, TELEPHONE SHALL BE BUSHED HOLE AND POWER SHALL BE DUPLEX RECEPTACLE OR OTHER AS NOTED. PROVIDE SEPARATION BARRIER BETWEEN POWER AND TELEPHONE COMPARTMENTS. PROVIDE JUNCTION BOX ON UNDERSIDE OF FLOOR. PACK FITTING TO RESTORE FIRE RATING OF FLOOR.

SECURE ALL RACEWAYS TO SUPPORTS WITH PIPE STRAPS OR U-BOLTS. SPACING OF SUPPORTS SHALL BE A MINIMUM OF 10 FT ON CENTER FOR METALLIC RACEWAY AND AS REQUIRED FOR NONMETALLIC RACEWAY. SPACING SHALL BE 5 FT ON CENTER FOR WIREWAYS AND PER CODE AND AS NOTED FOR OTHERS. MOUNT SUPPORTS TO STRUCTURE. MASONRY WITH TOGGLE BOLTS ON HOLLOW MASONRY, EXPANSION SHIELDS OR INSERTS IN CONCRETE AND BRICK, MACHINE SCREWS ON METAL, BEAM CLAMPS ON FRAMEWORK, WOOD SCREWS ON WOOD, AND PAN THROUGH STRAPS IN METAL DECK, NAILS, RAWL PLUGS OR WOOD PLUGS SHALL NOT BE PERMITTED. WHERE REQUIRED BY STRUCTURE, FURNISH THROUGH BOLTS AND FISHPLATES.

EXPPOSED RACEWAYS SHALL BE RUN PARALLEL WITH OR AT RIGHT ANGLES TO WALLS. PROVIDE CLEARANCE WITH WATER, STEAM OR OTHER PIPING (MINIMUM 3 IN. SEPARATION FROM STEAM AND HOT WATER PIPES. EXCEPT 1 IN. FROM PIPE COVER AT CROSSINGS AND 18 IN. FOR PARALLEL RUNS). FOR HUNG CEILING OUTLETS, RUN IN HUNG CEILING AND CONNECT TO CEILING SUPPORT CHANNELS. IN MASONRY AND POURED CONCRETE, RUN VERTICALLY ONLY.

MAINTAIN GROUNDING CONTINUITY OF INTERRUPTED METALLIC RACEWAYS WITH GROUND CONDUCTOR, AND IN FLEXIBLE CONDUIT FOR FEEDERS AND MOTOR TERMINAL CONNECTIONS.

EMPTY RACEWAYS OVER 10 FT LONG: PROVIDE FISH OR PULL WIRE, GALVANIZED OR NYLON ROPE.

RIGID STEEL CONDUIT SHALL BE PERMITTED FOR FEEDERS AND BRANCH CIRCUITS. PAINT MALE THREADS OF FIELD-THREADED CONDUIT WITH GRAPHITE-BASE PIPE COMPOUND AND BUTT CONDUIT ENDS. TOUCH UP MARRED SURFACES AND FIELD-CUT THREADS. CRC-COLD GALVANIZED. EMT SHALL BE PERMITTED FOR BRANCH CIRCUITS ONLY, IN DRY LOCATIONS, DRY WALLS, HUNG CEILINGS, HOLLOW BLOCK WALLS AND FURRED SPACES. EMT SHALL NOT BE PERMITTED IN RAISED FLOORS. FLEXIBLE STEEL CONDUIT SHALL BE UTILIZED FOR SHORT CONNECTIONS WHERE RIGID CONDUIT IS IMPRACTICAL. FROM OUTLET BOX TO RECESSED LIGHTING FIXTURE: PROVIDE MINIMUM 4 FT AND MAXIMUM 6 FT LENGTHS. FOR FINAL CONNECTION TO MOTOR TERMINAL BOX, TRANSFORMER AND OTHER VIBRATING EQUIPMENT: PROVIDE WITH POLYVINYL SHEATHING AND GROUND CONDUCTOR. MINIMUM LENGTH: 18 IN. WITH SLACK. CONNECT GROUND CONDUCTOR TO ENCLOSURE OR RACEWAY AT EACH END. FOR EXPANSION JOINT CROSSINGS, CROSS AT RIGHT ANGLES AND ANCHOR ENDS.

CUT CONDUIT ENDS SQUARE. REAM SMOOTH. PAINT MALE THREADS OF FIELD THREADED RACEWAYS WITH GRAPHITE BASE PIPE COMPOUND. DRAW UP TIGHT WITH RACEWAY COUPLING.

ALL COUPLINGS SHALL BE COMPRESSION TYPE. NO SET SCREW FITTINGS.

EXPANSION FITTINGS SHALL BE INSTALLED AT RIGHT ANGLES WITH CLIP JOINT CENTERED IN EXPANSION JOINT. PROVIDE A LENGTH OF RUN IN ACCORDANCE MANUFACTURER'S RECOMMENDATIONS. PRESET FITTINGS SHALL ALLOW FOR TEMPERATURE VARIATION.

RACEWAYS PASSING THROUGH FIRE-RATED CONSTRUCTION: SEAL OPENING WITH FIRE SEALANT.

D. PROVIDE CABLE SUPPORTS IN ACCORDANCE WITH NATIONAL ELECTRIC CODE ARTICLE 300.19. CABLE SUPPORTS SHALL UTILIZE A ONE-PIECE PLUG WITH POZI-GRIP WEDGING PLUG AS MANUFACTURED BY OZ-GEDNEY. TYPE SF SHALL BE USED FOR ARMORED CABLE.

INSTALL CABLE SUPPORTS AT THE TOP OF A VERTICAL RISE AND PROVIDE INTERMEDIATE SUPPORTS AS REQUIRED TO LIMIT SUPPORTED CONDUCTOR LENGTHS TO NOT GREATER THAN THOSE SPECIFIED IN TABLE 300.19(A).

A. ERECT WALL AND SWITCH OUTLETS IN ADVANCE OF FURRING AND FIREPROOFING. OUTLET BOXES SHALL BE SET SQUARE AND TRUE WITH BUILDING FINISH. SECURE TO BUILDING STRUCTURE BY ADJUSTABLE STRAP IRON OR GROUT IN WITH MASONRY. VERIFY OUTLET LOCATIONS IN FINISHED SPACES WITH ARCHITECTURAL DRAWINGS OF INTERIOR DETAILS AND FINISHES. PROVIDE BARRIERS BETWEEN SWITCHES CONNECTED TO DIFFERENT PHASES FOR VOLTAGES EXCEEDING 150 VOLTS TO GROUND.

D. PANEL, JUNCTION AND PULL BOXES SHALL BE LOCATED CLEAR OF OTHER TRADES, CONCEAL JUNCTION AND PULL BOXES IN FINISHED SPACES. WHERE NECESSARY, REROUTE RACEWAYS OR MAKE OTHER ARRANGEMENTS FOR CONCEALMENT. BOXES SHALL BE ACCESSIBLE. SUPPORT BOXES FROM BUILDING STRUCTURE, INDEPENDENT OF CONDUIT. PROVIDE FLOOR-TO-CEILING CHANNELS FOR MOUNTING ON DRYWALL AND LIGHTWEIGHT CONSTRUCTION. OUTLET BOXES FOR FIXTURES EXCEPT IN HUNG CEILINGS SHALL BE ACCESSIBLE THROUGH OPENING CREATED BY REMOVAL OF FIXTURE. SECURE TO BLACK IRON SUPPORT. MOTOR TERMINAL BOXES: COORDINATE WITH MOTOR BRANCH CIRCUIT CONDUIT AND WIRING; ADD BOX VOLUME WHERE REQUIRED.

E. FIRE SEALANTS: PROVIDE FOR RACEWAYS AND WIRE PASSING THROUGH FLOOR SLOTS, SLEEVES OR OPENINGS IN FIRE-PARTITIONS ROOMS.

F. PERFORM CONTINUITY TESTS OF RESISTANCE OF FEEDER CONDUITS FROM SERVICE TO POINT OF FINAL DISTRIBUTION USING 1 CONDUCTOR RETURN. MAXIMUM RESISTANCE SHALL BE 25 OHMS.

9. WIRE AND CABLE:

A. PROVIDE WIRE AND CABLE COMPLETE WITH ACCESSORIES. SIZE REFERENCE SHALL BE AWG EXCEPT AS NOTED.

B. CONDUCTORS SHALL BE COPPER, ASTM STANDARD SOLID (NO. 10 AND SMALLER) OR STRANDED (NO. 8 AND LARGER). GENERAL USE CABLING SHALL BE NO. 12 MINIMUM. AT 120 VOLTS AND OVER 100 FT CIRCUIT LENGTH PROVIDE NO. 10 MINIMUM. AT 265 VOLTS AND OVER 200 FT CIRCUIT LENGTH PROVIDE NO. 10 MINIMUM.

C. CONTROL AND ALARM CABLING, EXCEPT AS NOTED, SHALL BE NO. 14 MINIMUM. AT 120 VOLTS AND OVER 200 FT CIRCUIT LENGTH PROVIDE NO. 12 MINIMUM. OTHER VOLTAGES AND PHASES: ADJUST CABLE SIZING AS REQUIRED TO MAINTAIN VOLTAGE DROP. INCREASE RACEWAY SIZES FOR LARGER WIRE AS REQUIRED.

D. INSULATION SHALL BE RUBBER AND THERMOPLASTIC MEETING ASTM AND IPCCA STANDARDS. TYPE THW OR THWN SHALL BE UTILIZED FOR FEEDERS AND BRANCH CIRCUITS EXCEPT AS NOTED. TYPE SFF-2 SHALL BE UTILIZED FOR BRANCH CIRCUITS LOCATED IN WIRING CHANNELS OF CONTINUOUS FLUORESCENT FIXTURES AND IN AMBIENT TEMPERATURES OVER 90 DEG C. FOR UNGROUNDED ISOLATED BRANCH CIRCUITS PROVIDE CROSS-LINKED POLYETHYLENE INSULATION (TYPE XHHW).

E. ARMORED CABLE (BX) SHALL BE UTILIZED FOR BRANCH CIRCUITS IN DRY HOLLOW LOCATIONS, HUNG CEILINGS, AND BLOCK WALLS. WHEN USED IN LIEU OF WIRING IN CONDUIT, STATE IN PROPOSAL THAT PRICE IS BASED UPON THE USE OF HOSPITAL GRADE 'BX'.

F. COLOR CODING SHALL BE AS FOLLOWS:

120/208 VOLT SYSTEM:
BLACK FOR A PHASE
RED FOR B PHASE
BLUE FOR C PHASE

1) NEUTRAL WIRE SHALL UTILIZE WHITE OUTER COVERING THROUGHOUT. EQUIPMENT GROUND WIRE SHALL UTILIZE GREEN OUTER COVERING THROUGHOUT.

WHERE COLOR-CODED CABLE IS NOT AVAILABLE, CERTIFY IN WRITING AND REQUEST PERMISSION TO OVERLAP CONDUCTORS WITH 6 IN. OF COLOR TAPING IN ACCESSIBLE LOCATIONS.

G. PROVIDE FLAMEPROOF LINEN OR FIBER TAGS IN ACCESSIBLE LOCATIONS. FOR FEEDERS INDICATE FEEDER NUMBER, SIZE, PHASE AND POINTS OF ORIGIN AND TERMINATIONS. FOR CONTROL AND ALARM WIRING INDICATE TYPE (CONTROL OR ALARM), SIZE OF WIRE, AND POINTS OF ORIGIN AND TERMINATIONS.

H. TERMINATIONS, SPLICES AND TAPS UNDER 600 VOLTS: COPPER CONDUCTORS NO. 10 AND SMALLER SHALL UTILIZE COMPRESSION-TYPE OF TWIST-ON SPRING-LOADED CONNECTORS AND CLEAR NYLON-INSULATED COVERING. COPPER CONDUCTORS NO. 8 AND LARGER SHALL UTILIZE MECHANICAL BOLTED PRESSURE OR HYDRAULIC COMPRESSION TYPE USING MANUFACTURER'S RECOMMENDED TOOLING. CABLE LUGS AND CONNECTORS SHALL UTILIZE COMPRESSION TYPE OF SAME METAL AS CONDUCTOR. PROVIDE TO MATCH CABLE, WITH MARKING INDICATING SIZE AND TYPE. COPPER LUG CONNECTIONS TO BUS BARS: USE ANTISIZE COMPOUND ON TANG.

I. NOT MORE THAN 3 LIGHTING OR CONVENIENCE OUTLET CIRCUITS SHALL BE INSTALLED IN ONE CONDUIT UNLESS OTHERWISE INDICATED. PULL NO THERMOPLASTIC WIRES AT TEMPERATURES LOWER THAN 32 DEG F. PROVIDE SEPARATE RACEWAYS FOR CONDUCTORS OF 120/208V AND 265/460 VOLT SYSTEMS. EXCEPT 460 VOLT MOTOR BRANCH CIRCUIT WIRING AND RELATED 120 VOLT CONTROL WIRING. THERMOPLASTIC WIRES SHALL NOT BE INSTALLED IN COMPUTER AREA RAISED FLOORS.

J. LEAVE WIRES WITH SUFFICIENT SLACK TO PERMIT MAKING FINAL CONNECTIONS.

K. PERFORM CONTINUITY AND INSULATION TESTS. MEGGER TEST 100 PERCENT OF FEEDERS, 10 PERCENT OF BRANCH CIRCUITS AND ALL MOTOR BRANCH CIRCUITS OVER 25 HP.

PERFORM TESTS PRIOR TO CONNECTING EQUIPMENT AND IN PRESENCE OF AUTHORIZED REPRESENTATIVES. SUBMIT WRITTEN REPORT OF RESULTS. CORRECT OR REPLACE CABLE TESTING BELOW MANUFACTURER'S STANDARDS.

11. WIRING DEVICES:

A. WIRING DEVICES SHALL BE SPECIFICATION GRADE UNLESS OTHERWISE SPECIFIED. ALL DEVICES SHALL BE FLUSH MOUNTED, UNLESS OTHERWISE NOTED. PROVIDE COMPLETE MATERIAL AND ACCESSORIES AS NOTED.

B. LOCAL WALL SWITCHES SHALL BE ROCKER TYPE, QUIET OPERATING, RATED 20 AMP, 120/277 VOLT, AC, SIMILAR TO LEVITON DECORA SERIES A5621 (SINGLE POLE), A5623 (3-WAY) AND A5624 (4-WAY).

C. STRAIGHT BLADE RECEPTACLES SHALL BE RESIDENTIAL GRADE DUPLEX CONVENIENCE 125 VOLTS, 2 POLE, 3 WIRE, U GROUND SLOT, DECORA SERIES BY LEVITON. GROUNDED, EXCEPT AS NOTED.

1)SINGLE GANG, RECESSED, DUPLEX RECEPTACLE: TAMPER RESISTANT, 2-POLE, 3-WIRE GROUNDING, 15A, 125V, NEMA 5-20R; LEVITON 689 SERIES (COLOR AS SPECIFIED BY

ARCHITECT).
2)USB CHARGER/ DUPLEX TAMPER-RESISTANT RECEPTACLE: TAMPER RESISTANT,

D. DEVICE PLATES: SEE ARCHITECT FOR TYPE. FOR RECEPTACLES WITH OTHER THAN 120 VOLT, INSCRIBED VOLTAGE AVAILABLE.

E. COLORS: COORDINATE COLORS WITH ARCHITECT.

F. MOUNTING ORIENTATION OF RECEPTACLES (HORIZONTAL OR VERTICAL): COORDINATE WITH ARCHITECT.

12. LIGHTING FIXTURES:

A. FIXTURES TO BE AS SPECIFIED BY ARCHITECT AND SHALL BE COMPLETELY FACTORY ASSEMBLED, WIRED AND EQUIPPED WITH ALL NECESSARY SOCKETS, BALLASTS, SUPPORTING HARDWARE AND ACCESSORIES. REFER TO DRAWINGS FOR INDIVIDUAL FIXTURE DESCRIPTIONS.

B. FIXTURE CATALOG NUMBERS USED TO ILLUSTRATE EQUIPMENT TYPE DO NOT NECESSARILY DENOTE REQUIRED MOUNTING EQUIPMENT OR ACCESSORIES. PROVIDE ACCESSORIES TO SUIT.

C. BALLAST: CLASS P, HIGH POWER FACTOR, LOWEST AVAILABLE NEMA RATED NOISE LEVEL, ET1 AND CBM APPROVED. ENERGY SAVING TYPE. TRIGGER START FOR 24-INCH LAMPS AND RAPID START FOR 48-INCH. TWO LAMP BALLASTS; NO THREE LAMP BALLASTS. BALLASTS SHALL BE ADVANCE MAGNETEK, UNIVERSAL OR EQUAL.

D. LED DRIVERS SHALL BE ELECTRONIC TYPE, LABELED AS COMPLIANT WITH RADIO FREQUENCY INTERFERENCE (RFI) REQUIREMENTS OF FCC TITLE 47, PART 15 AND COMPLY WITH NEMA SSL 1 "ELECTRONIC DRIVERS FOR LED DEVICES, ARRAYS OR SYSTEMS". LED DRIVERS SHALL HAVE A SOUND RATING OF "A", HAVE A MINIMUM EFFICIENCY OF 85% AND BE RATED FOR A THD OF LESS THAN 20% AT ALL INPUT VOLTAGES.

E. DIMMABLE LED DRIVERS SHALL BE CAPABLE OF DIMMING WITHOUT LED STROBING OR FLICKER ACROSS THEIR FULL DIMMING RANGE. PROVIDE TYPE OF LED DRIVER AS PER LIGHTING FIXTURE SCHEDULE. DIMMABLE LED DRIVERS SHALL BE 0-10V WHERE NOT INDICATED.

F. CONTINUOUS ROW, TWO LAMP STRIP FIXTURES SHALL BE STAGGERED TYPE.

G. EXIT SIGNS SHALL BE PRECISION DIE-CAST ALUMINUM HOUSING WITH LASER-FORMED ACRYLIC LEGEND. EXIT SIGNS SHALL COMPLY WITH UL 924 AND BE MEA APPROVED. AC POWERED WITH PREMIUM LONG-LIFE NICKEL CADMIUM BATTERY WITH STANDARD UL LISTED 3-HOUR RUN TIME. PROVIDE WITH INTEGRAL AUTOMATIC CHARGER IN A SELF CONTAINED POWER PACK. LED INDICATOR WITH PUSH TO TEST SWITCH.

13. TELEPHONE CONDUIT SYSTEM:

A. PROVIDE COMPLETE SYSTEM OF: RACEWAYS AND ACCESSORIES, OUTLET BOXES, SLEEVES AND FISHWIRES.

B. EQUIPMENT SHALL CONFORM TO REQUIREMENTS OF TELEPHONE COMPANY.

C. OUTLETS SHALL BE:

1) WALL: 4 IN. SQUARE WITH BUSHED COVER PLATE.

D. PROVIDE FISHWIRES, IN RACEWAYS OVER 10 FT LONG.

E. CONDUIT SHALL BE 3/4 IN. MINIMUM. FURNISH EMPTY CONDUIT FROM OUTLET BOX TO BUSHED END THRU WALL 6" BELOW THE PLASTER CEILING.

F. FACE RACEWAYS IN ROOMS SHALL HUBBELL HBL500, HBL750 OR HBL2000 SERIES OR AS ACCEPTABLE.

14. GROUNDING AND BONDING:

A. PROVIDE GROUNDING SYSTEM IN ACCORDANCE WITH (NATIONAL ELECTRICAL CODE), AND THESE SPECIFICATIONS. THE WIRING SYSTEM SHALL BE INSTALLED AS REQUIRED TO PROVIDE A CONTINUOUSLY GROUNDING SYSTEM. WHERE FLEXIBLE CONDUIT IS USED FOR PART OF A CONDUIT RUN EXCEPT LIGHTING BRANCH CIRCUITS, AN INSULATED GROUNDING CONDUCTOR SHALL BE PROVIDED IN THE CONDUIT AND CONNECTED TO GROUNDING BUSHINGS AT EACH END OF THE RUN.

B. USE EXOTHERMIC WELDING PROCESS FOR INACCESSIBLE CONNECTIONS.

C. EXTEND EXISTING SYSTEM GROUND TO INCLUDE ALL THE ELECTRICAL EQUIPMENT IN THE SCOPE OF WORK.

D. WHERE FLEXIBLE METALLIC CONDUIT IS USED AN INTERNAL BONDING CONDUCTOR SHALL BE INSTALLED.

E. IN ADDITION, FURNISH A SEPARATE INSULATED GREEN EQUIPMENT GROUND CONDUCTOR WHERE INDICATED ON DRAWINGS AND FOR THE FOLLOWING BRANCH CIRCUITS:
1) CIRCUITS SERVING ANY WALL BOX DIMMER.

2) CIRCUITS SERVING ANY ISOLATED GROUND RECEPTACLES. TERMINATE GROUND DIRECTLY AT AN EQUIPMENT GROUNDING CONDUCTOR TERMINAL OF THE SOURCE AT THE SOURCE , OR AS OTHER WISE NOTED ON DRAWINGS.

3) CIRCUITS SERVING ANY DUPLEX OR SIMPLEX COMPUTER RECEPTACLES

4) ANY CIRCUIT SERVED VIA AN ISOLATION TRANSFORMER OR COMPUTER POWER DISTRIBUTION UNIT.

15. PANELBOARDS:

A. PANELBOARDS SHALL BE OF THE DEAD FRONT TYPE MANUFACTURED IN CODE GAUGE AND SIZE BOXES FOR MOUNTING AS INDICATED ON PLANS COMPLETE WITH TRIM, DOORS AND LOCKS. ALL LOCKS SHALL BE KEYED ALIKE.

B. CIRCUIT BREAKERS SHALL BE OF THE BOLT-ON THERMAL MAGNETIC MOLDED CASE TYPE, AND SHALL HAVE THE TRIP RATINGS AND NUMBER OF POLES SHOWN IN SCHEDULES ON THE CONTRACT DRAWINGS. FOR BLANK (SPACE) COMPARTMENTS, PROVIDE FULL RATED BUS. MINIMUM GUTTER SPACES SHALL BE 5-3/4". SIDES, TOP AND BOTTOM, INCREASE FOR THROUGH FEEDERS. PROVIDE 25% COPPER GROUND BUS AND 100% COPPER NEUTRAL BUS AND INCREASE NEUTRAL BUS INDICATED.

C. LOCKING TABS SHALL BE PROVIDED ON ALL CIRCUIT BREAKERS SERVING EMERGENCY LIGHTING, FIRE ALARM SYSTEM, SECURITY SYSTEMS AND OTHER EMERGENCY OR CRITICAL EQUIPMENT AND AS NOTED ON THE CONTRACT DRAWINGS. A TOTAL OF 5 SPARE LOCKING TABS SHALL BE FURNISHED TO THE OWNER.

D. BUSES SHALL BE HARD DRAWN COPPER OF 98 PERCENT CONDUCTIVITY AND SHALL HAVE CROSS SECTIONAL AREAS LARGE ENOUGH TO LIMIT THE TEMPERATURE RISE, WHEN CARRYING FULL LOAD, TO 35 DEGREES C. ABOVE AN AMBIENT INSIDE THE ENCLOSURE OF 55 DEGREES C. AS DEFINED IN IEEE STANDARD RULES. MAIN BUS CAPACITY SHALL BE AS SHOWN ON THE CONTRACT DRAWINGS.

E. ENCLOSURES SHALL BE SURFACE OR FLUSH AS INDICATED. TRIMS SHALL BE SECURED TO PANEL WITH MACHINE SCREWS. COVERS SHALL BE HINGED DOOR-IN-DOOR CONSTRUCTION WITH CYLINDER LOCKS AND CATCHES. LOCKS MUST BE COMPATIBLE WITH BUILDING STANDARD KEY SYSTEM AND WHEN NONE EXISTS, THEY SHALL BE SIMILAR TO A YALE NO. 911 KEY.

F. DISTRIBUTION AND SUB-DISTRIBUTION PANELBOARD SHALL BE A MINIMUM OF 30" WIDE AND 10" DEEP.

G. ALL STANDARD PANELBOARDS SHALL BE A MINIMUM OF 20" WIDE AND 5 3/4" DEEP.

H. FURNISH ALL PANELBOARDS WITH FEED-THRU LUGS UNLESS OTHERWISE INDICATED ON THE DRAWINGS.

I. ALL NEW PANELBOARDS SHALL BE PROVIDED WITH AN ENGRAVED WHITE CORE LAMACOID NAMEPLATE, WITH 3/4 IN. WHITE LETTERING ON A BLACK BACKGROUND, WITH DESIGNATION LISTED (PANELBOARD NAME), FASTENED WITH EPOXY CEMENT OR OVAL HED CHROME PLATED MACHINE SCREWS.

J. THE CIRCUIT DIRECTORY SHALL BE TYPEWRITTEN AND PROVIDED INSIDE EACH PANEL DOOR TO INDICATE EQUIPMENT AND/OR AREA SERVED. DIRECTORY HOLDER SHALL BE METAL FRAME WITH CLEAR PLASTIC, TRANSPARENT COVER. THE TYPEWRITTEN LIST INDICATING CIRCUIT NUMBERS, OUTLETS SUPPLIED AND THEIR LOCATIONS SHALL BE PROVIDED.

K. TIE-BARS SHALL NOT BE USED TO CREATE MULTI-POLE CIRCUITS. MAXIMUM 42 CIRCUITS ALLOWED.

L. ONLY ONE WIRE SHALL BE INSTALLED UNDER EACH CIRCUIT BREAKER LUG.

M. SHORT CIRCUIT RATING OF PANELBOARDS SHALL NOT BE LESS THAN AS INDICATED ON THE CONTRACT DRAWINGS OR SPECIFIED HEREIN. WHERE NOT INDICATED OR SPECIFIED THE MINIMUM SHORT CIRCUIT RATING SHALL BE EQUAL TO THE INTERRUPTING CAPACITY OF THE LOWEST RATED CIRCUIT BREAKER IN THE PANELBOARD, BUT IN NO CASE LESS THAN 10,000 AMPERES R.M.S. SYMMETRICAL FOR 208Y/120 VOLT SYSTEM AND 14,000 AMPERES R.M.S. SYMMETRICAL FOR 480Y/277 VOLT SYSTEM. SERIES RATED PANELBOARDS SHALL BE USED TO ACHIEVE REQUIRED SHORT CIRCUIT RATINGS.

N. FOR ALL EXISTING PANELBOARDS, CONTRACTOR SHALL PROVIDE NEW CIRCUIT BREAKERS TO REPLACE EXISTING AS REQUIRED AS INDICATED ON DRAWINGS.

16. LOADCENTERS

A. LOAD CENTERS SHALL COMPLY WITH UL67 AND MEET FEDERAL SPECIFICATION W-P-115c.

B. CIRCUIT BREAKERS SHALL BE OF THE PLUG-IN, THERMAL MAGNETIC, MOLDED CASE TYPE, AND SHALL HAVE THE TRIP RATINGS AND NUMBER OF POLES SHOWN IN SCHEDULES ON THE CONTRACT DRAWINGS. FOR BLANK (SPACE) COMPARTMENTS, PROVIDE FULL RATED BUS. TANDEM OR DUPLEX TYPE CIRCUIT BREAKERS SHALL NOT BE PERMITTED. ONLY ONE WIRE SHALL BE INSTALLED UNDER EACH CIRCUIT BREAKER LUG. TIE-BARS SHALL NOT BE USED TO CREATE MULTI-POLE CIRCUITS.

C. BUSES SHALL BE HARD DRAWN COPPER OF 98 PERCENT CONDUCTIVITY AND SHALL HAVE CROSS SECTIONAL AREAS LARGE ENOUGH TO LIMIT THE TEMPERATURE RISE, WHEN CARRYING FULL LOAD, TO 35 DEGREES C. ABOVE AN AMBIENT INSIDE THE ENCLOSURE OF 55 DEGREES C. AS DEFINED IN IEEE STANDARD RULES. MAIN BUS CAPACITY SHALL BE AS SHOWN ON THE CONTRACT DRAWINGS.

D. ENCLOSURES MANUFACTURED IN CODE GAUGE AND SIZE BOXES FOR FLUSH MOUNTING AS INDICATED ON PLANS COMPLETE WITH TRIM, DOORS AND LOCKS. ALL LOCKS SHALL BE KEYED ALIKE. MINIMUM GUTTER SPACES SHALL BE 5-3/4". SIDES, TOP AND BOTTOM, INCREASE FOR THROUGH FEEDERS. PROVIDE 25% COPPER GROUND BUS AND 100% COPPER NEUTRAL BUS AND INCREASE NEUTRAL BUS INDICATED. ALL LOAD CENTERS SHALL BE 14 1/2" WIDE AND 3 1/2" DEEP.

E. THE CIRCUIT DIRECTORY SHALL BE TYPEWRITTEN AND PROVIDED INSIDE EACH PANEL DOOR TO INDICATE EQUIPMENT AND/OR AREA SERVED. DIRECTORY HOLDER SHALL BE METAL FRAME WITH CLEAR PLASTIC, TRANSPARENT COVER. THE TYPEWRITTEN LIST INDICATING CIRCUIT NUMBERS, OUTLETS SUPPLIED AND THEIR LOCATIONS SHALL BE PROVIDED.

F. SHORT CIRCUIT RATING OF PANELBOARDS SHALL NOT BE LESS THAN AS INDICATED ON THE CONTRACT DRAWINGS OR SPECIFIED HEREIN. WHERE NOT INDICATED OR SPECIFIED THE MINIMUM SHORT CIRCUIT RATING SHALL BE EQUAL TO THE INTERRUPTING CAPACITY OF THE LOWEST RATED CIRCUIT BREAKER IN THE PANELBOARD, BUT IN NO CASE LESS THAN 22,000/10,000 AMPERES R.M.S. SYMMETRICAL SERIES RATING FOR 208Y/120 VOLT. SERIES RATED LOAD CENTERS SHALL BE USED TO ACHIEVE REQUIRED SHORT CIRCUIT RATINGS.

17. SMOKE ALARMS

A. PROVIDE SOLID STATE, PHOTOELECTRIC TYPE, HARD-WIRED SMOKE ALARM WITH 9V BATTERY BACKUP AND INTEGRAL TEMPORAL PATTERN EVACUATION HORN. EDWARDS 517 SERIES OR APPROVED EQUAL.

B. THREE POSITION TEST FEATURE THAT SIMULATES ACTUAL SMOKE CONDITIONS. SHALL CONTAIN MAINTENANCE INDICATOR.

C. PROVIDE WITH INTEGRAL 135 DEGREE F ISOLATED HEAT DETECTION OR INTEGRAL RELAY RATED 0.6A AT 125V AC., AS INDICATED ON THE PLANS AND DRAWINGS.

D. DEVICE SHALL BE RATED TO OPERATE AT A RANGE OF 40°F TO 100°F.

E. UL LISTED TO UL217 AND APPROVED.

18. INTERCOM CONDUIT SYSTEM:

A. PROVIDE COMPLETE SYSTEM OF: RACEWAYS AND ACCESSORIES, OUTLET BOXES, SLEEVES AND FISHWIRES.

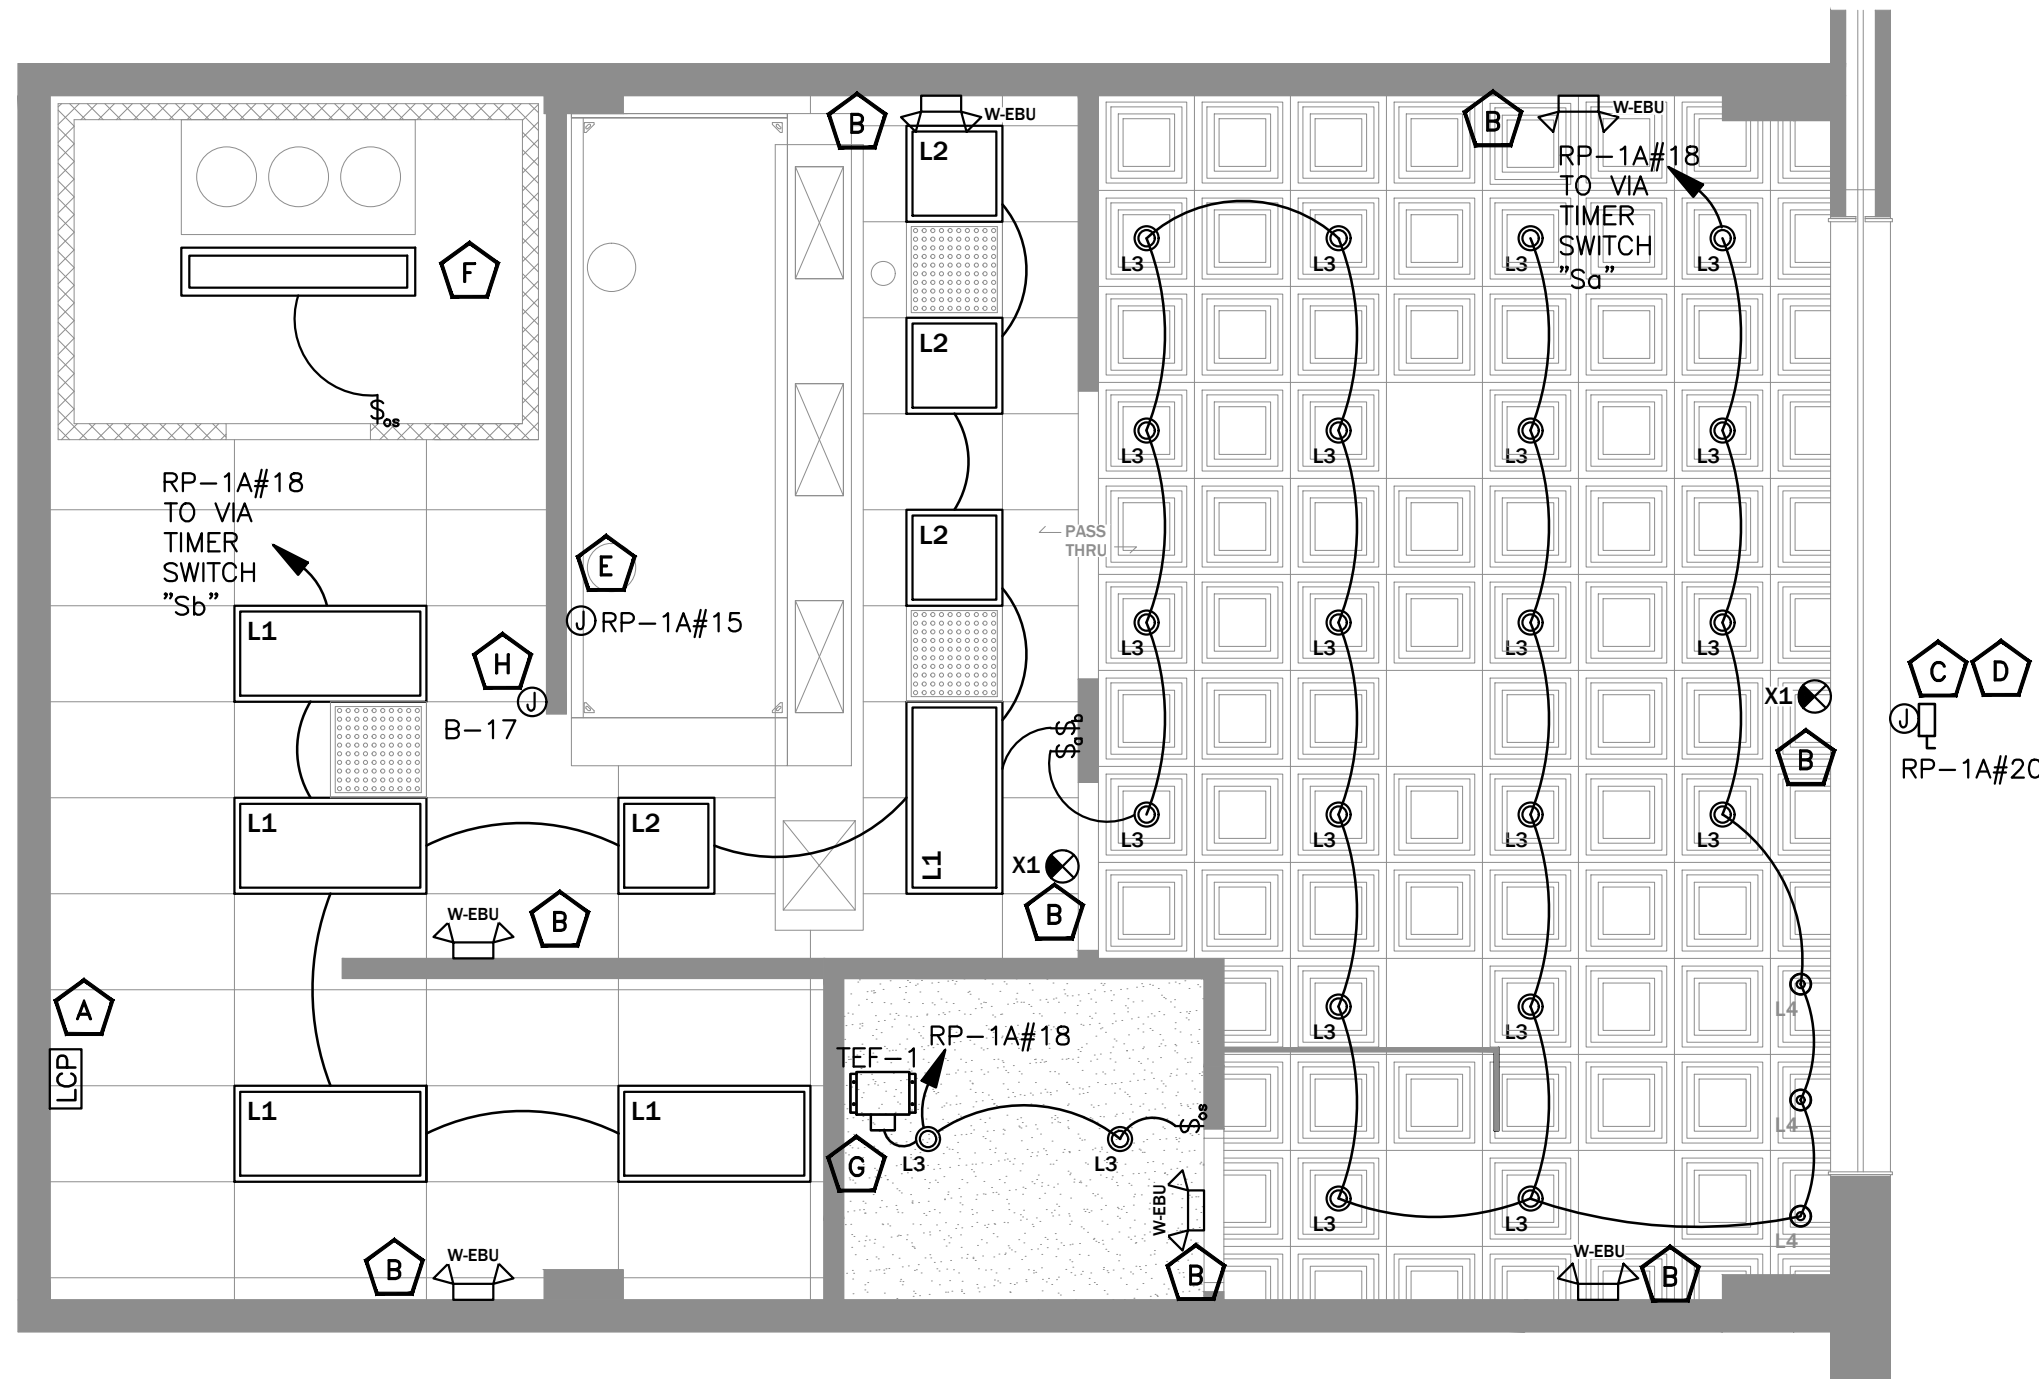
B. EQUIPMENT SHALL CONFORM TO REQUIREMENTS OF INTERCOM MANUFACTURER.

C. OUTLETS SHALL BE:


1)WALL: 4 IN. SQUARE WITH SINGLE GANG COVER PLATE.

D. PROVIDE FISHWIRES, IN RACEWAYS OVER 10 FT LONG.

E. CONDUIT SHALL BE 3/4 IN. MINIMUM. FURNISH EMPTY CONDUIT FROM EACH APARTMENT TO MAIN INTERCOM CONTROLLER AT ENTRANCE.



1
E1.0
LIGHTING PLAN
1/4"=1'-0"

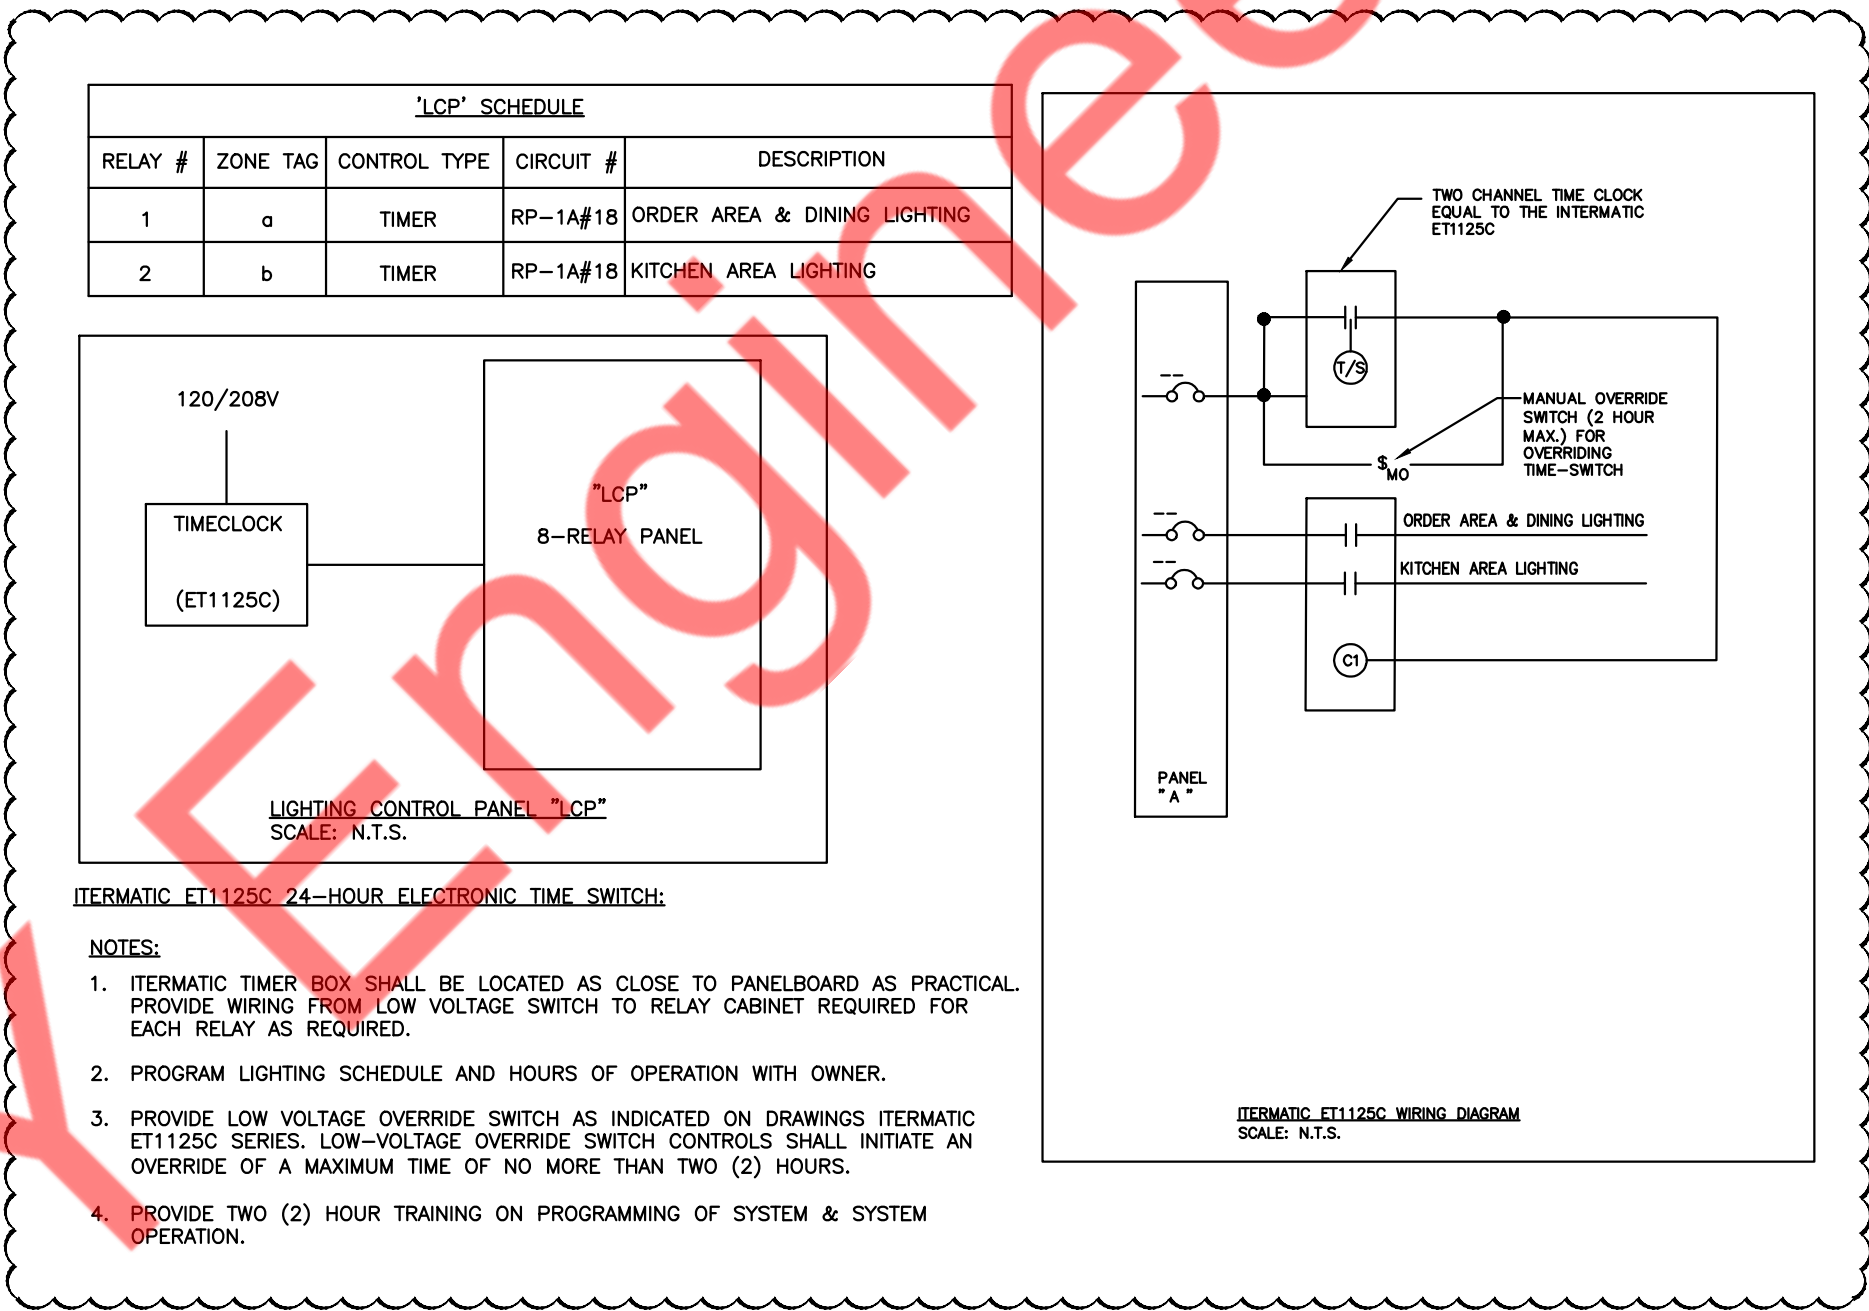


LIGHTING FIXTURE SCHEDULE								
CODE	MANUFACTURER	MODEL	QUANTITY	VOLTS/PHASE	WATTS	LAMP TYPE	MOUNTING	DESCRIPTION
L1	LITHONIA	EPANL 2X4 4000LMHE 80CRI 35K MVOLT SLD	5	120/277V	31	LED	RECESSED	2' X 4' LED FLAT PANEL
L2	LITHONIA	EPANL 2X2 3400LM 80CRI 35K MVOLT SLD	4	120/277V	30	LED	RECESSED	2' X 2' LED FLAT PANEL
L3	LITHONIA	LDN6 35/15 L06BR LSS MVOLT EZ10	20	120/277V	20.5	LED	RECESSED	6" LED DOWNLIGHT
L4	Y LIGHTING - ACCESS LIGHTING	ACC186262-9	3	120V	10	LED	SURFACE	PENDANT LIGHT
W-EBU	EXITRONIX	LED-95-WH	5	120/277V	3	LED	UNIVERSAL	EMERGENCY LED
X1	EXITRONIX	VLED-U-WH-EL90-R	2	120/277V	2.2	LED	WALL	EXIT LED LIGHT

REFER TO REFLECTED CEILING PLAN IN ARCHITECTURAL DRAWINGS FOR MORE INFORMATION ON COLORS AND TRIMS REQUIRED.


(*) EXISTING FIXTURES ARE ACCEPTABLE. IF THEY NEED TO BE REPLACED, REPLACE W/ EXACT MATCH OR MATCH SCHEDULE.

E.C. SHALL RECEIVE APPROVAL FROM ARCHITECT/ OWNER FOR LIGHTING FIXTURE SELECTIONS BEFORE PURCHASE AND INSTALLATION.

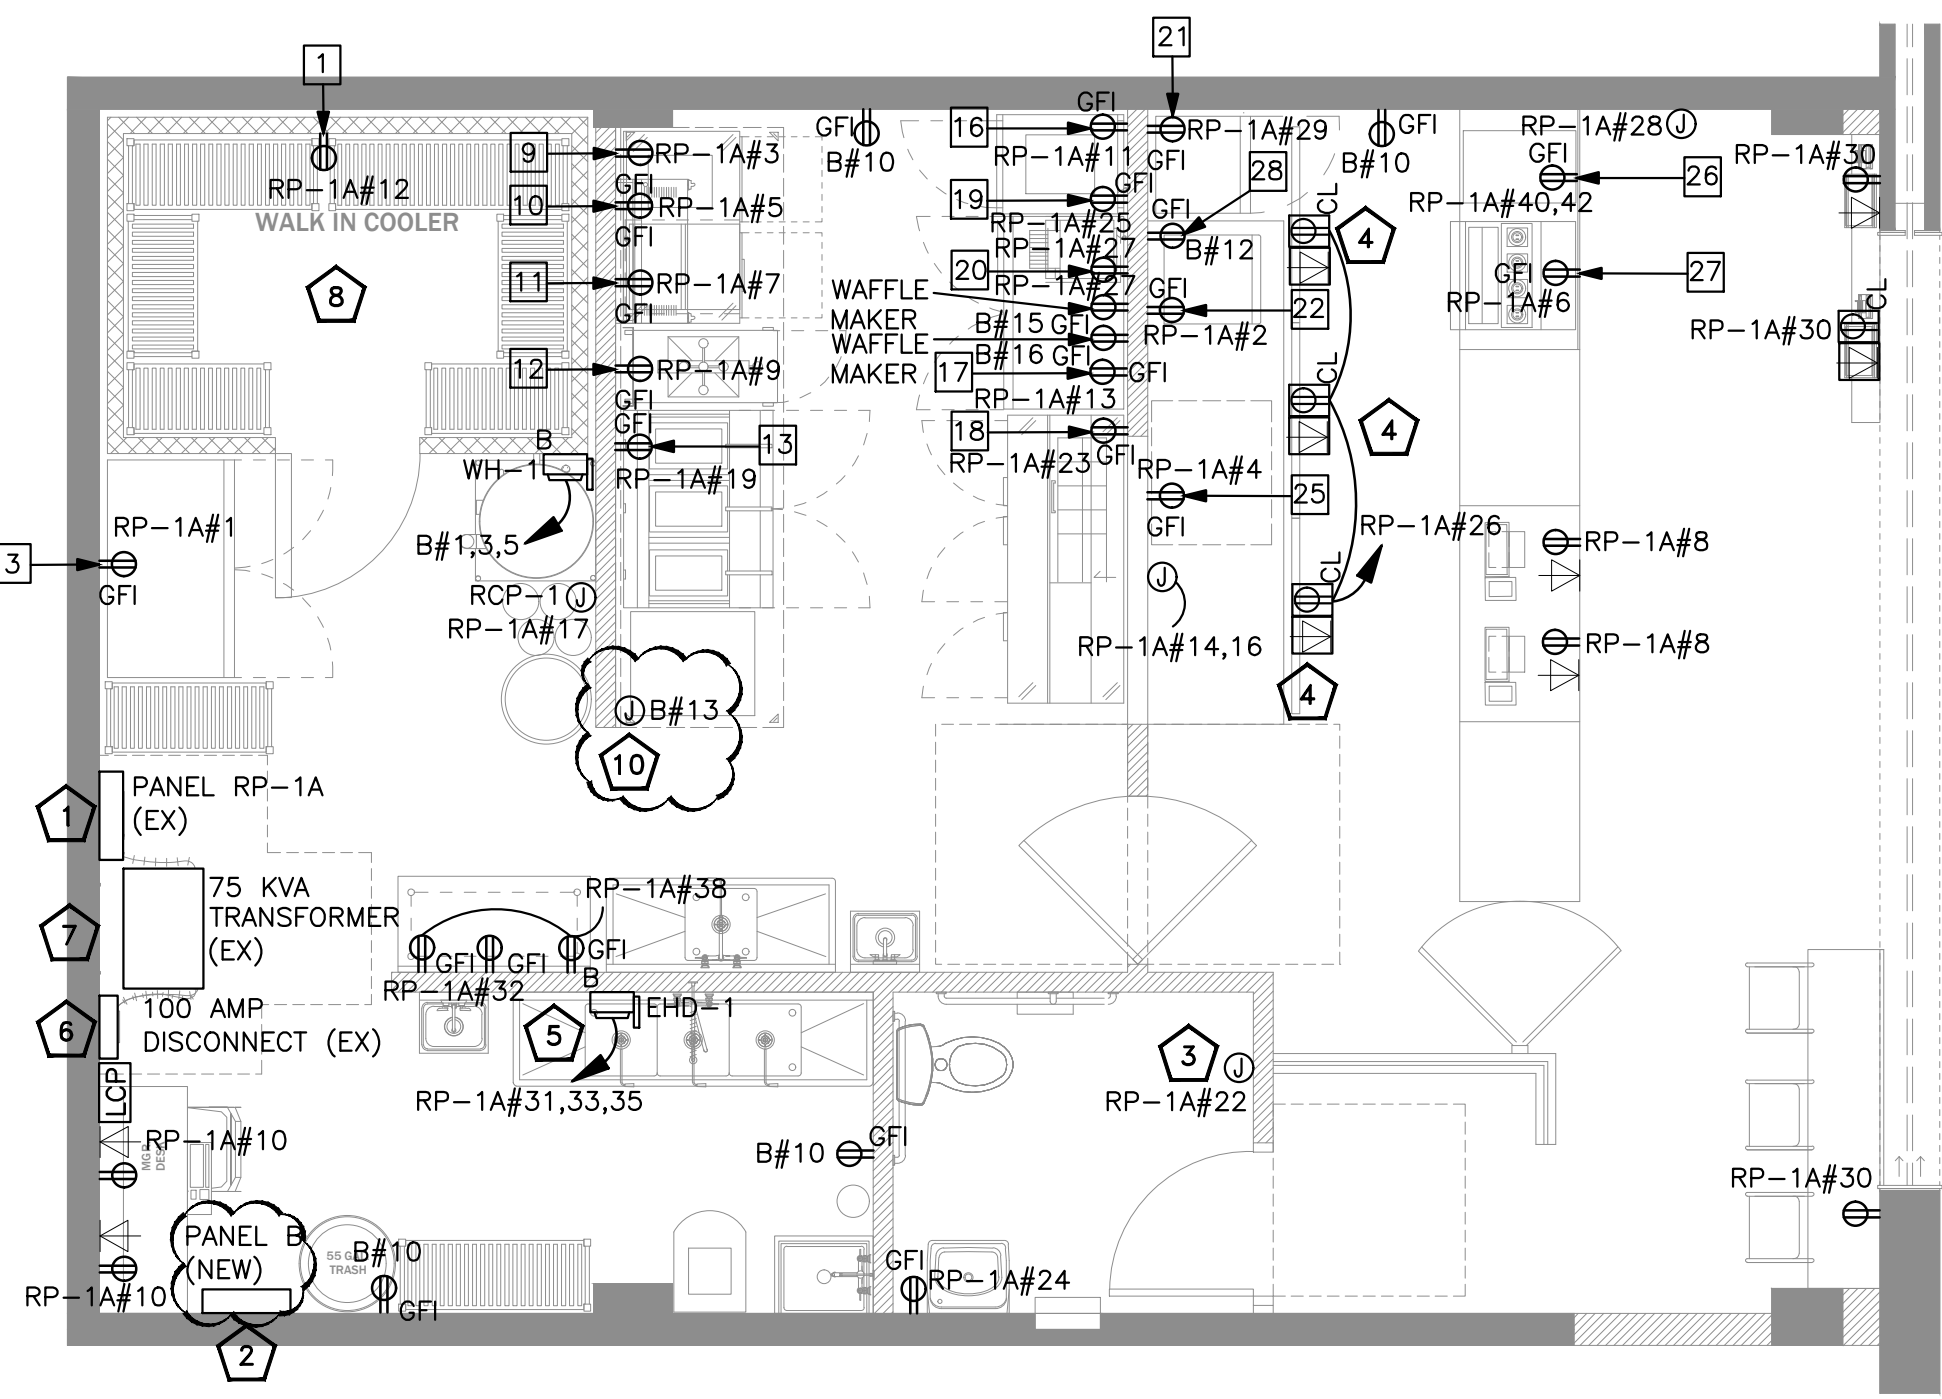- ELECTRICAL LIGHTING PLAN KEYED WORK NOTES:**
- E.C. SHALL COORDINATE EXACT LOCATION OF THE LIGHTING CONTROL PANEL "LCP" WITH ARCHITECT/OWNER.
 - CONNECT ALL EMERGENCY EGRESS AND NIGHT LIGHTING FIXTURES TO THE NEAREST LIGHTING BRANCH CIRCUIT AHEAD OF ALL SWITCHING AND CONTROLS PER STATE AND LOCAL CODES.
 - VERIFY THE EXACT LOCATIONS OF SIGNS, AND FASCIA BOXES BEFORE INSTALLATION OF JUNCTION BOXES. E.C. SHALL VERIFY EXACT SIGN(S) WIRING REQUIREMENTS WITH THE SIGN SUPPLIER PRIOR TO SUBMITTING A BID FOR THE ELECTRICAL.
 - PROVIDE A 30AMP DISCONNECT SWITCH WITH LOCK-OFF CAPABILITY FOR STOREFRONT SIGN. VERIFY EXACT LOCATION AND ELECTRICAL REQUIREMENTS CONNECTION TO STOREFRONT SIGN. VERIFY EXACT LOCATION OF POWER FEED AND PUNCH-THRU WITH SIGNAGE CONTRACTOR TO ENSURE NO EXCESSIVE CONDUIT IS RUN NEITHER INSIDE NOT OUTSIDE. TIE CIRCUIT INTO LIGHTING CONTROL SYSTEM FOR CONTROLS.
 - JUNCTION BOX ON HOOD FOR RE-WIRED HOOD LIGHTS.
 - LIGHTING BY W.I.B MANUFACTURER. E.C. TO PROVIDE RACEWAYS, WIRING AND LAMPS FOR ALL LIGHT FIXTURES FURNISHED WITH THE FREEZER/COOLER STORAGE UNIT. COORDINATE THE INSTALLATION OF SWITCHES AND PLATES WITH THE EQUIPMENT SUPPLIER.
 - TEF-1 SHALL BE CIRCUITED AND CONTROLLED ALONG WITH THE LIGHT FIXTURES IN THE RESTROOM AREA.
 - JUNCTION BOX FOR EMERGENCY GAS SHUT OFF SOLENOID VALVE. E.C. TO COORDINATE WITH PLUMBING CONTRACTOR FOR EXACT LOCATION AND ELECTRICAL REQUIREMENT IN FIELD.



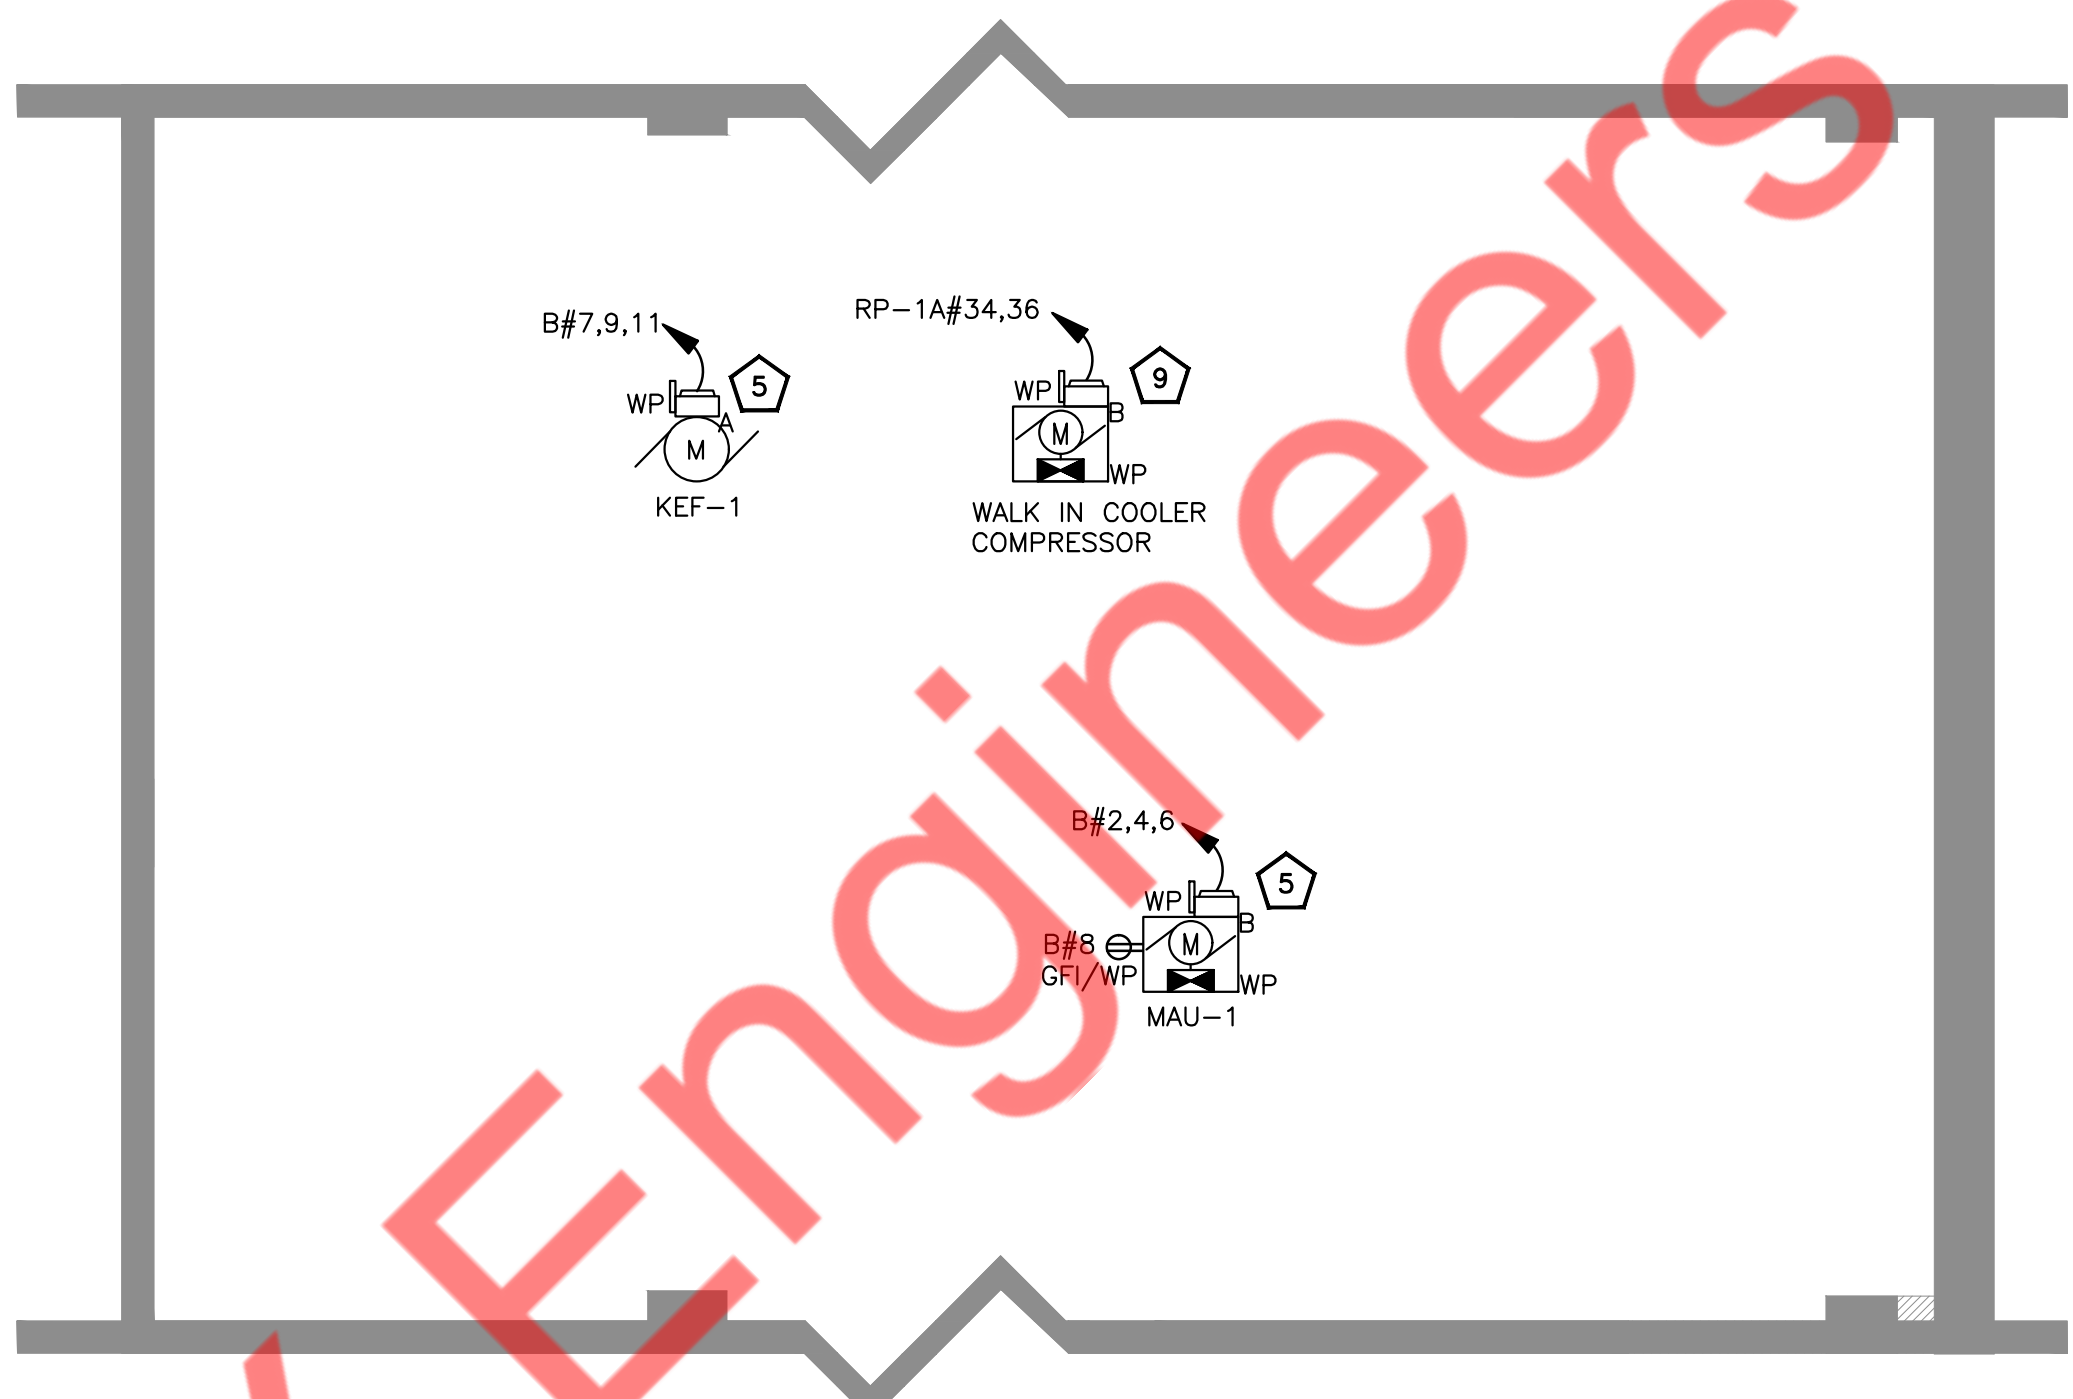1 FIRST FLOOR POWER PLAN
E2.0 1/4"=1'-0"



2 ROOF POWER PLAN
E2.0 1/4"=1'-0"

KITCHEN EQUIPMENT SCHEDULE:

ITEM NO.	DESCRIPTION	VOLTAGE	PHASE	AMPS	KW	CONN. TYPE	NEMA
1	WALK IN BOX	115	1	15	1.73	CORD & PLUG	5-15P
3	ATOSA USA, INC.	115	1	8.6	0.99	CORD & PLUG	5-15P
9	REFRIGERATED WORK TOP	115	1	2.2	0.25	CORD & PLUG	5-15P
10	INDUCTION RANGE, COUNTERTOP	120	1	15.7	1.88	CORD & PLUG	5-15P
11	FRENCH FRY WARMER	120	1	10.5	1.26	CORD & PLUG	5-15P
12	PRESSURE FRYER GAS	120	1	10	1.20	CORD & PLUG	5-15P
13	GAS FRYER, BATTERY	120	1	12	1.44	CORD & PLUG	5-15P
16	MOBILE HEATED CABINET	120	1	14	1.68	CORD & PLUG	5-15P
17	REACH-IN UNDERCOUNTER FREEZER	115	1	2.6	0.30	CORD & PLUG	5-15P
18	SANDWICH/ SALAD PREP. REFRIGERATOR	115	1	5.4	0.62	CORD & PLUG	5-15P
19	HEATED HOLDING/WARMING BIN	120	1	3.3	0.40	CORD & PLUG	5-15P
20	CONVEYOR TOASTER	120	1	14.8	1.78	CORD & PLUG	5-15P
21	REFRIGERATED MERCHANDISER	115	1	2.1	0.24	CORD & PLUG	5-15P
22	ICE MAKER	115	1	8.2	0.94	CORD & PLUG	5-15P
25	UNDERCOUNTER REFRIGERATOR	115	1	2.3	0.26	CORD & PLUG	5-15P
26	SHAKE FREEZER	208	1	12	2.50	CORD & PLUG	6-20P
27	FOUNTAINETTE	115	1	4.6	0.53	CORD & PLUG	5-15P
28	COUNTER TOP FOUNTAIN MACHINE	115	1	3	0.35	CORD & PLUG	5-15P
	WAFEL MAKER	120	1	12	1.44	CORD & PLUG	5-15P

KITCHEN EQUIPMENT SCHEDULE GENERAL NOTES:

E.C. TO COORDINATE WITH ARCHITECT/ KITCHEN EQUIPMENT SPECIALIST FOR CONNECTION TYPE AND HEIGHT PRIOR TO ROUGH IN.

ELECTRICAL POWER PLAN GENERAL NOTES:

- VERIFY MOUNTING HEIGHTS OF ALL RECEPTACLES WITH EQUIPMENT SUPPLIED PRIOR TO INSTALLATION.
- E.C. TO PROVIDE CORD & PLUG CONNECTIONS FOR EQUIPMENT AS REQUIRED.
- ALL 120V, 20A OUTLETS IN THE FOOD PREP AREA SHALL BE GROUND FAULT INTERRUPT TYPE.
- ALL CIRCUITS FOR P.O.S. (POINT OF SALE) EQUIPMENT SHALL BE CONNECTED TO THE SAME PHASE OF POWER IN THE PANEL. ALL BRANCH CIRCUIT BREAKERS SUPPLYING P.O.S. EQUIPMENT SHALL HAVE LOCKING HANDLES DEVICES.
- EACH RECEPTACLE TYPE (LOCKING OR STRAIGHT BLADE) SHALL MATCH THAT OF THE EQUIPMENT FURNISHED.

ELECTRICAL POWER PLAN KEYED WORK NOTES:

- EXISTING 225A, 120/208V, 3-PHASE ELECTRICAL PANEL TO REMAIN. E.C SHALL VERIFY RATING, CONNECTION AND LOCATION OF PANEL IN FIELD. REPLACE IF INOPERABLE. BASE BID ACCORDINGLY.
- NEW 125A, 120/208V, 3-PHASE ELECTRICAL PANEL. E.C SHALL COORDINATE WITH ARCHITECT/OWNER FOR LOCATION.
- JUNCTION BOX FOR HAND DRYER. COORDINATE MOUNTING HEIGHT TO COMPLY WITH ADA.
- REFER TO EQUIPMENT SPECIFICATIONS FOR DATA AND POWER REQUIREMENTS AND LOCATIONS FOR ALL MENU BOARDS AND SIGNS.
- ELECTRICAL CONTRACTOR SHALL COORDINATE DISCONNECT AND FUSE REQUIREMENT FOR MECHANICAL UNIT WITH MECHANICAL CONTRACTOR AND EQUIPMENT MANUFACTURER PRIOR TO ROUGH-IN AND PROVIDE AS REQUIRED. COORDINATE LOCATION OF DISCONNECT WITH MANUFACTURER AND MECHANICAL CONTRACTOR PRIOR TO ROUGH-IN. LOCATE AS REQUIRED TO MAINTAIN NEC CLEARANCES.
- EXISTING 100A, 480V, 3-PHASE DISCONNECT SWITCH TO REMAIN. E.C SHALL VERIFY RATING, CONNECTION AND LOCATION IN FIELD. REPLACE IF INOPERABLE. BASE BID ACCORDINGLY.
- EXISTING 75KVA, 3-PHASE TRANSFORMER TO REMAIN. E.C SHALL VERIFY RATING, CONNECTION AND LOCATION IN FIELD. REPLACE IF INOPERABLE. BASE BID ACCORDINGLY.
- ELECTRICAL CONTRACTOR TO COORDINATE EXACT POWER REQUIREMENT WITH WALK IN BOX MANUFACTURER AND MAKE POWER PROVISION ACCORDINGLY.
- E.C. TO FIELD VERIFY LOCATION OF COMPRESSOR UNIT AND PROVIDE POWER CONNECTION WITH NECESSARY ELECTRICAL FIXTURES/ DISCONNECTS AS PER MANUFACTURER REQUIREMENTS.
- JUNCTION BOX FOR HOOD/ANSUL SYSTEM. ELECTRICAL CONTRACTOR TO COORDINATE EXACT POWER REQUIREMENT WITH HOOD MANUFACTURER AND MAKE POWER PROVISION ACCORDINGLY.

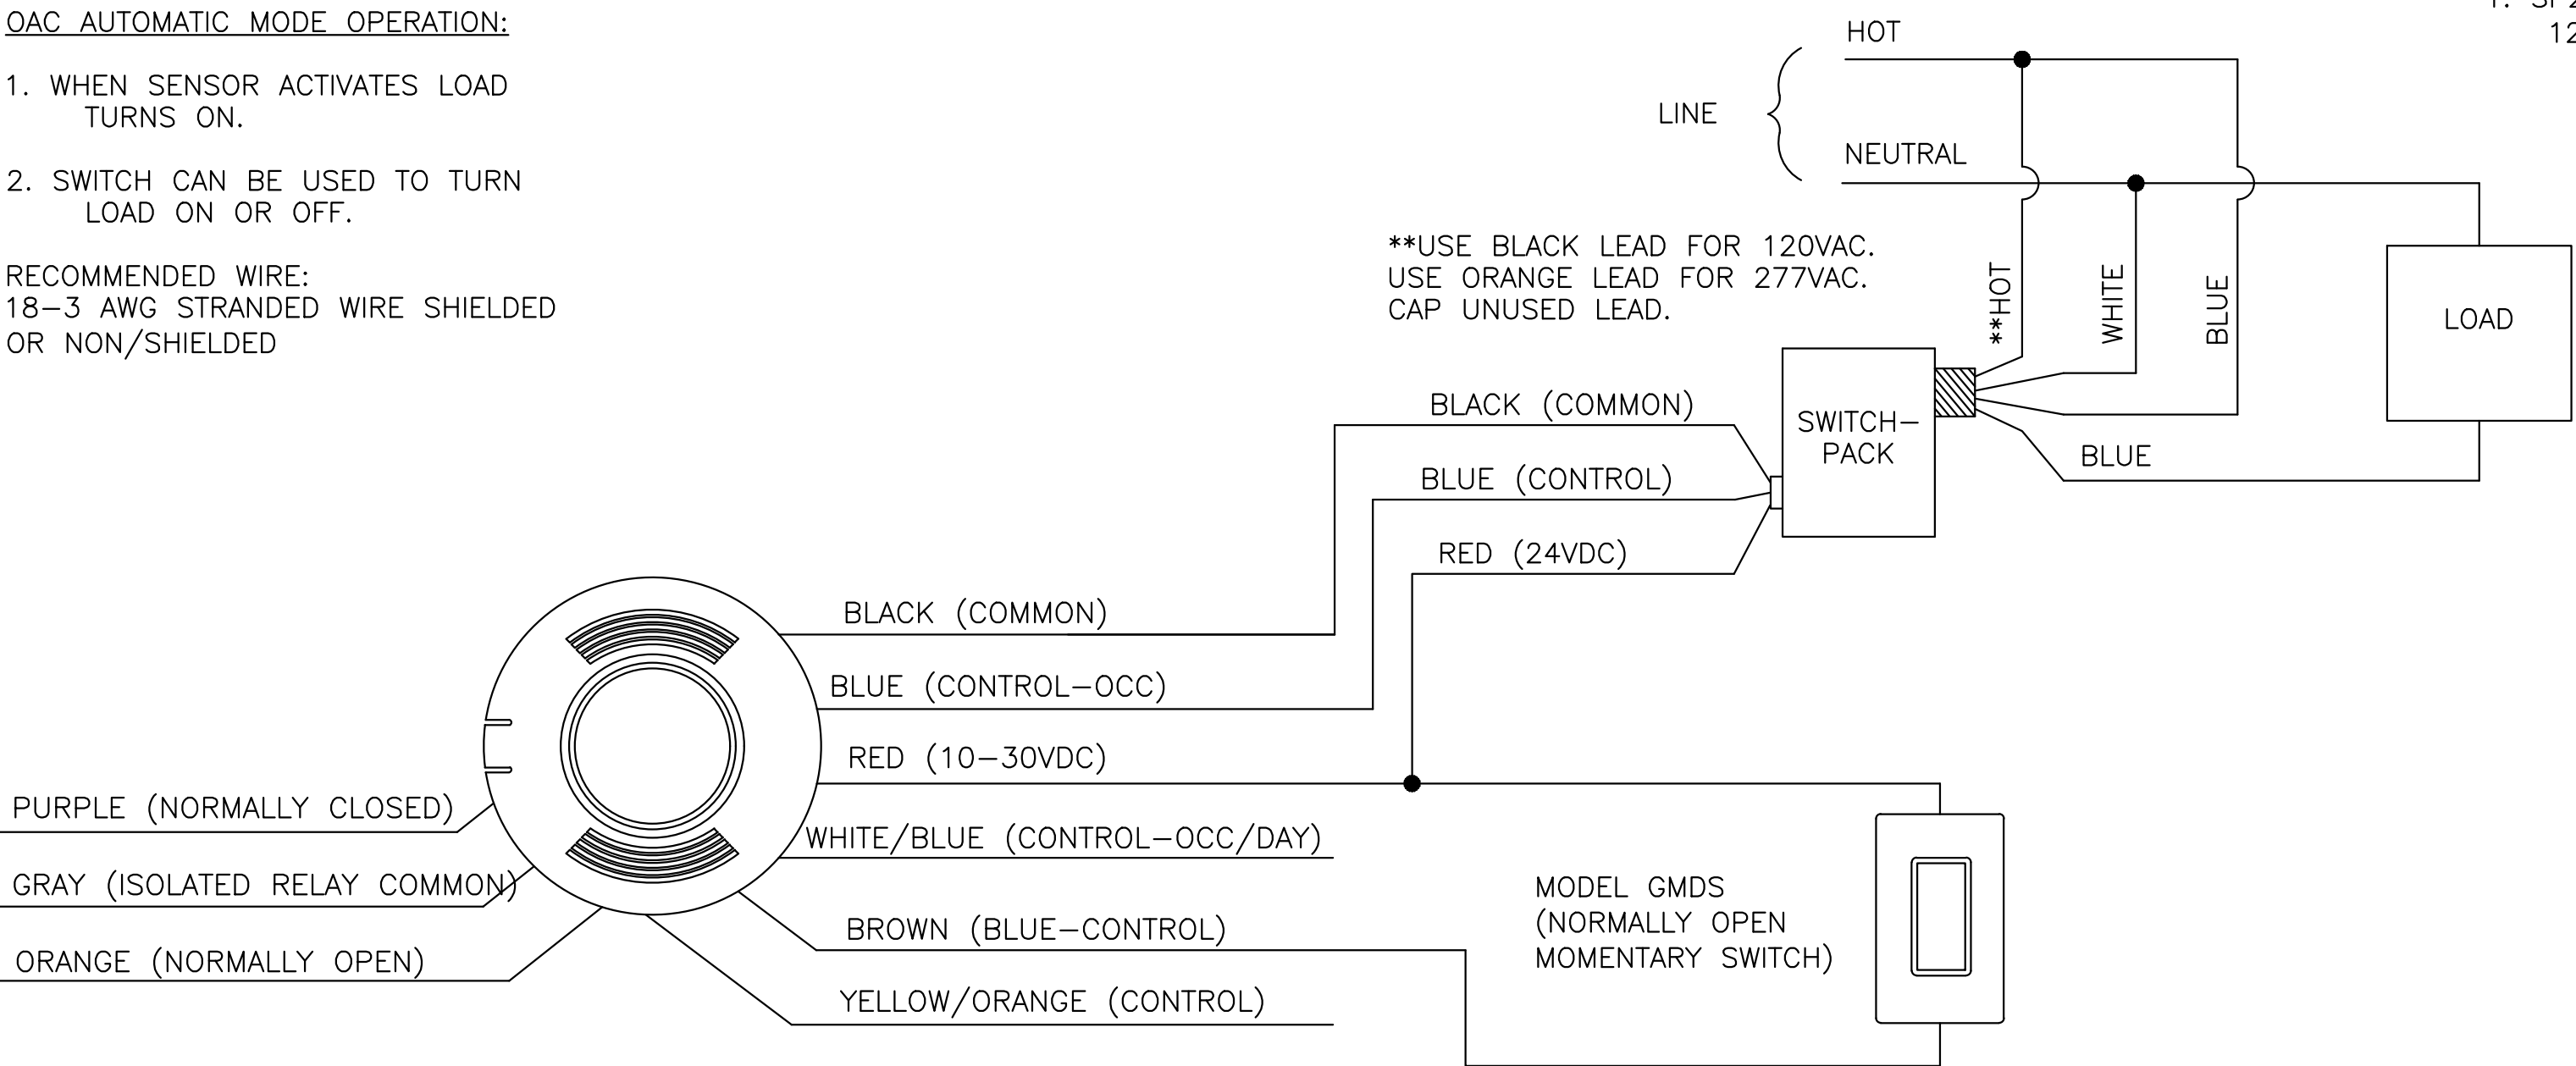
OAC AND VAC MANUAL MODE OPERATION:

1. SWITCHES ARE REQUIRED TO TURN LOAD ON.
2. LOAD TURNS OFF WHEN SENSOR TIMES OUT OR WITH SWITCH.

OAC AUTOMATIC MODE OPERATION:

1. WHEN SENSOR ACTIVATES LOAD TURNS ON.
2. SWITCH CAN BE USED TO TURN LOAD ON OR OFF.

RECOMMENDED WIRE:
18-3 AWG STRANDED WIRE SHIELDED
OR NON/SHIELDED




NOTES

1. SP20-RD4 SWITCHPACK SHOWN.
120/277VAC 20AMP RATING.

NOTES:

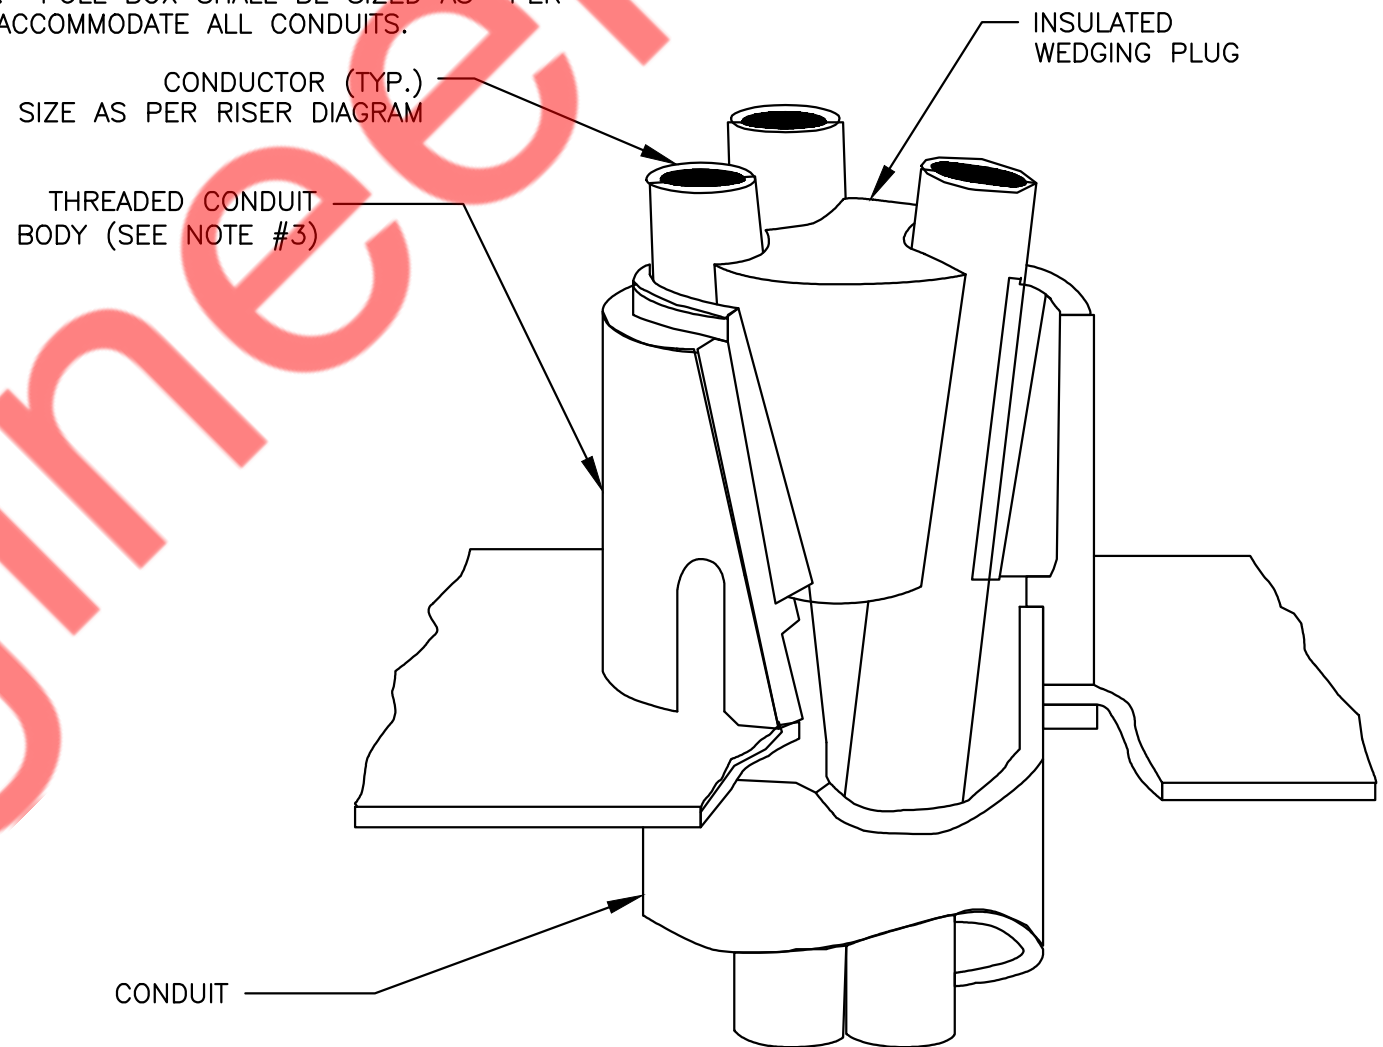1. ALL CONDUCTORS IN VERTICAL RACEWAYS SHALL BE SUPPORTED IN ACCORDANCE WITH ARTICLE 300.19 OF NEC. CABLE SUPPORTS SHALL BE LOCATED AT THE INTERVALS REQUIRED BY THE NEC.
2. CABLE SUPPORT SYSTEM SHALL BE AS MANUFACTURED BY O-Z GEDNEY WITH pOZI-GRIP "S-STYLE" WEDGING PLUG OR APPROVED EQUAL.
3. FOR THREADLESS CONDUIT (RIGID, IMC OR EMT), ATTACH CONDUIT BODY TO MALE THREADS OF A SET SCREW OR COMPRESSION CONNECT, AS PERMITTED BY SPECIFICATIONS.
4. PROVIDE PULL BOX AT EACH LOCATION OF CABLE SUPPORTS. PULL BOX SHALL BE SIZED AS PER CODE TO ACCOMMODATE ALL CONDUITS.



3

E3.0 N.T.S

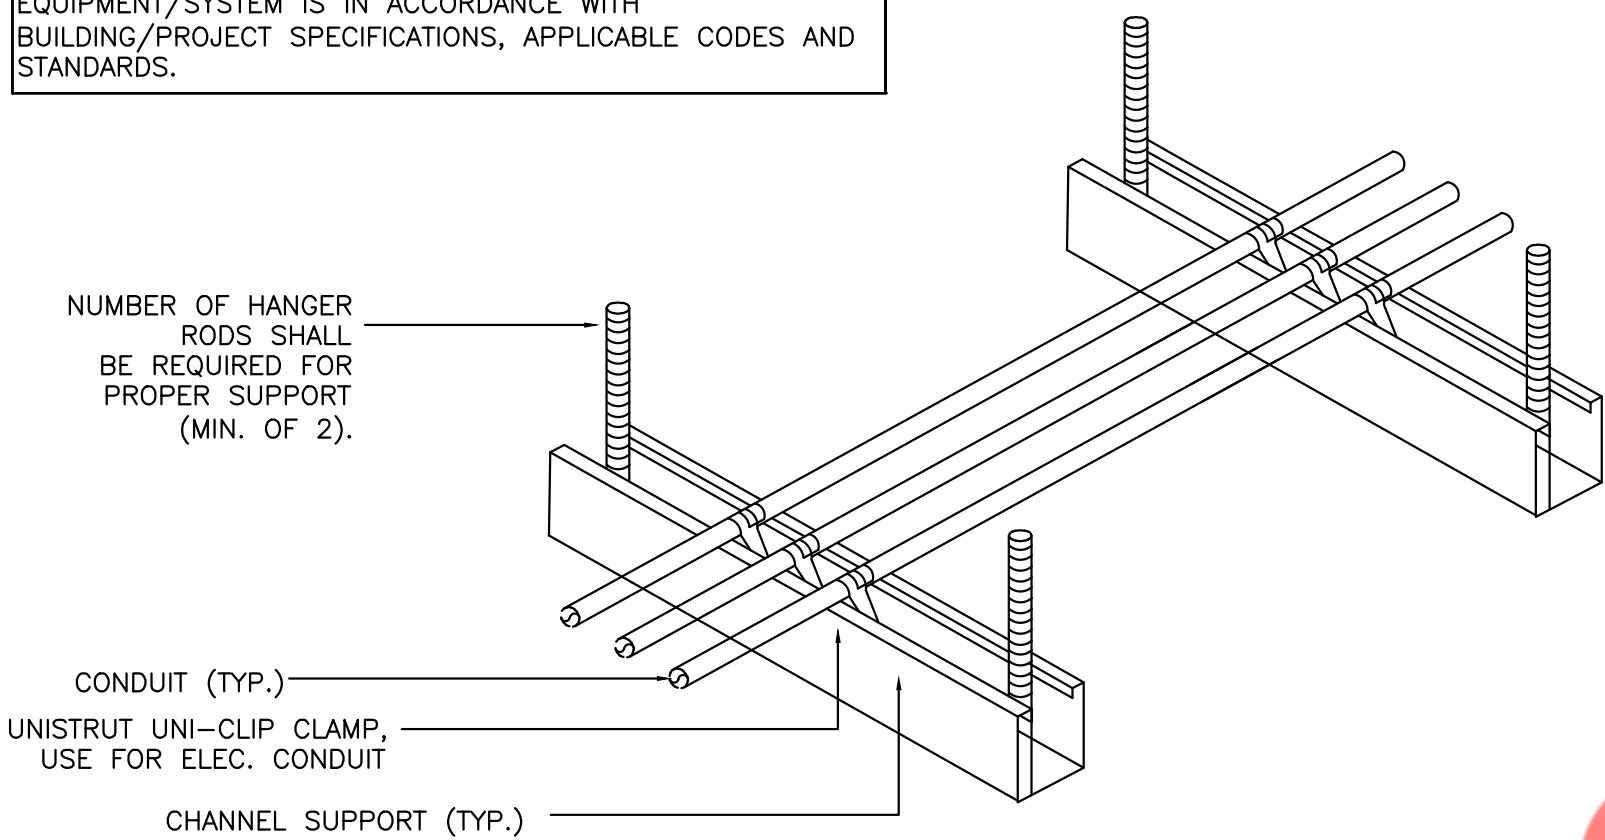
OCCUPANCY - AUTO ON/OFF.
WIRING DIAGRAM - LOW VOLTAGE CEILING SENSOR

2

E3.0 N.T.S


VERTICAL CABLE SUPPORT DETAIL

NOTE:
THIS INFORMATION MAY NOT CONTAIN ALL DETAILS REQUIRED FOR CONSTRUCTION. APPROPRIATE MODIFICATION MAY BE REQUIRED TO ENSURE SUITABILITY OF THESE DRAWINGS FOR THE SPECIFIC APPLICATION. IT IS THE USER'S RESPONSIBILITY TO ENSURE INSTALLATION OF THE EQUIPMENT/SYSTEM IS IN ACCORDANCE WITH BUILDING/PROJECT SPECIFICATIONS, APPLICABLE CODES AND STANDARDS.




NOTES:

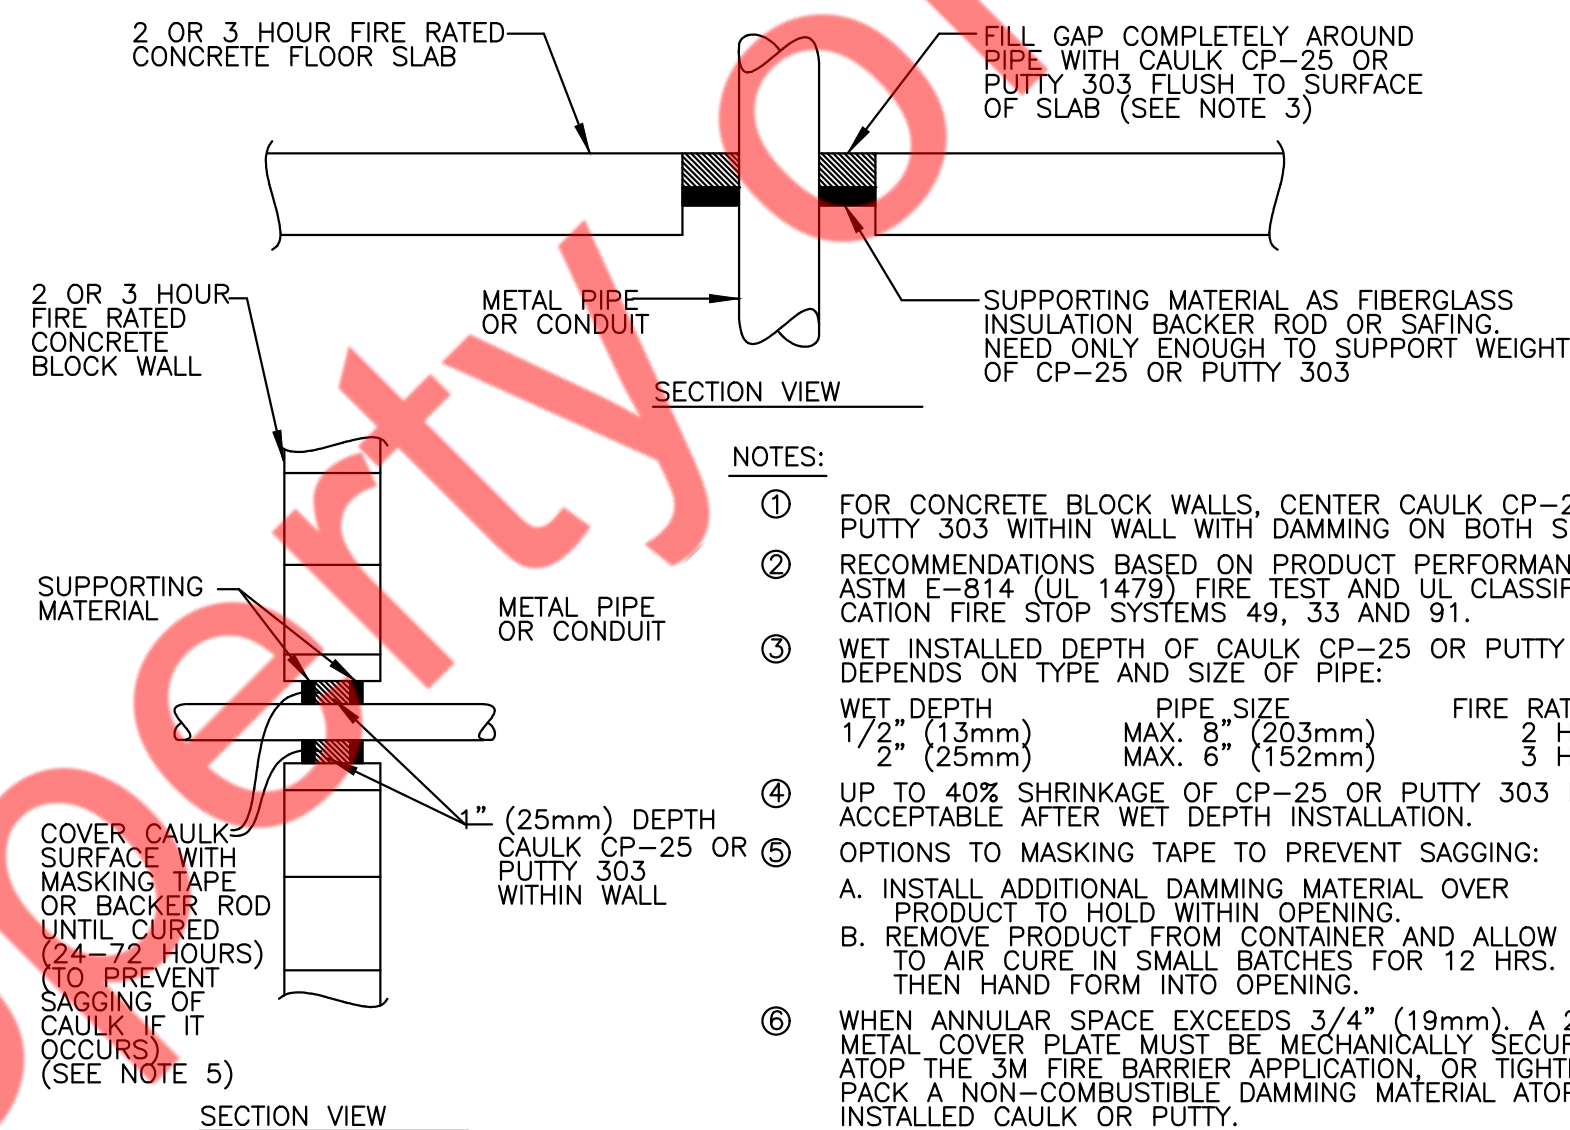1. ALL CONDUIT MAY BE COMBINED ON SAME SUPPORT CHANNEL WHERE PRACTICAL.
2. SUPPORT CHANNEL LENGTH SHALL NOT BE DETERMINED UNTIL ALL PIPING, CONDUIT, ETC. TO BE SUPPORTED IS COORDINATED.
3. SUPPORT CHANNEL SPACING SHALL BE NO MORE THAN 10'-0".
4. UNISTRUT AND CONDUIT INSTALLATION MAY BE REVERSED.



NOTES:

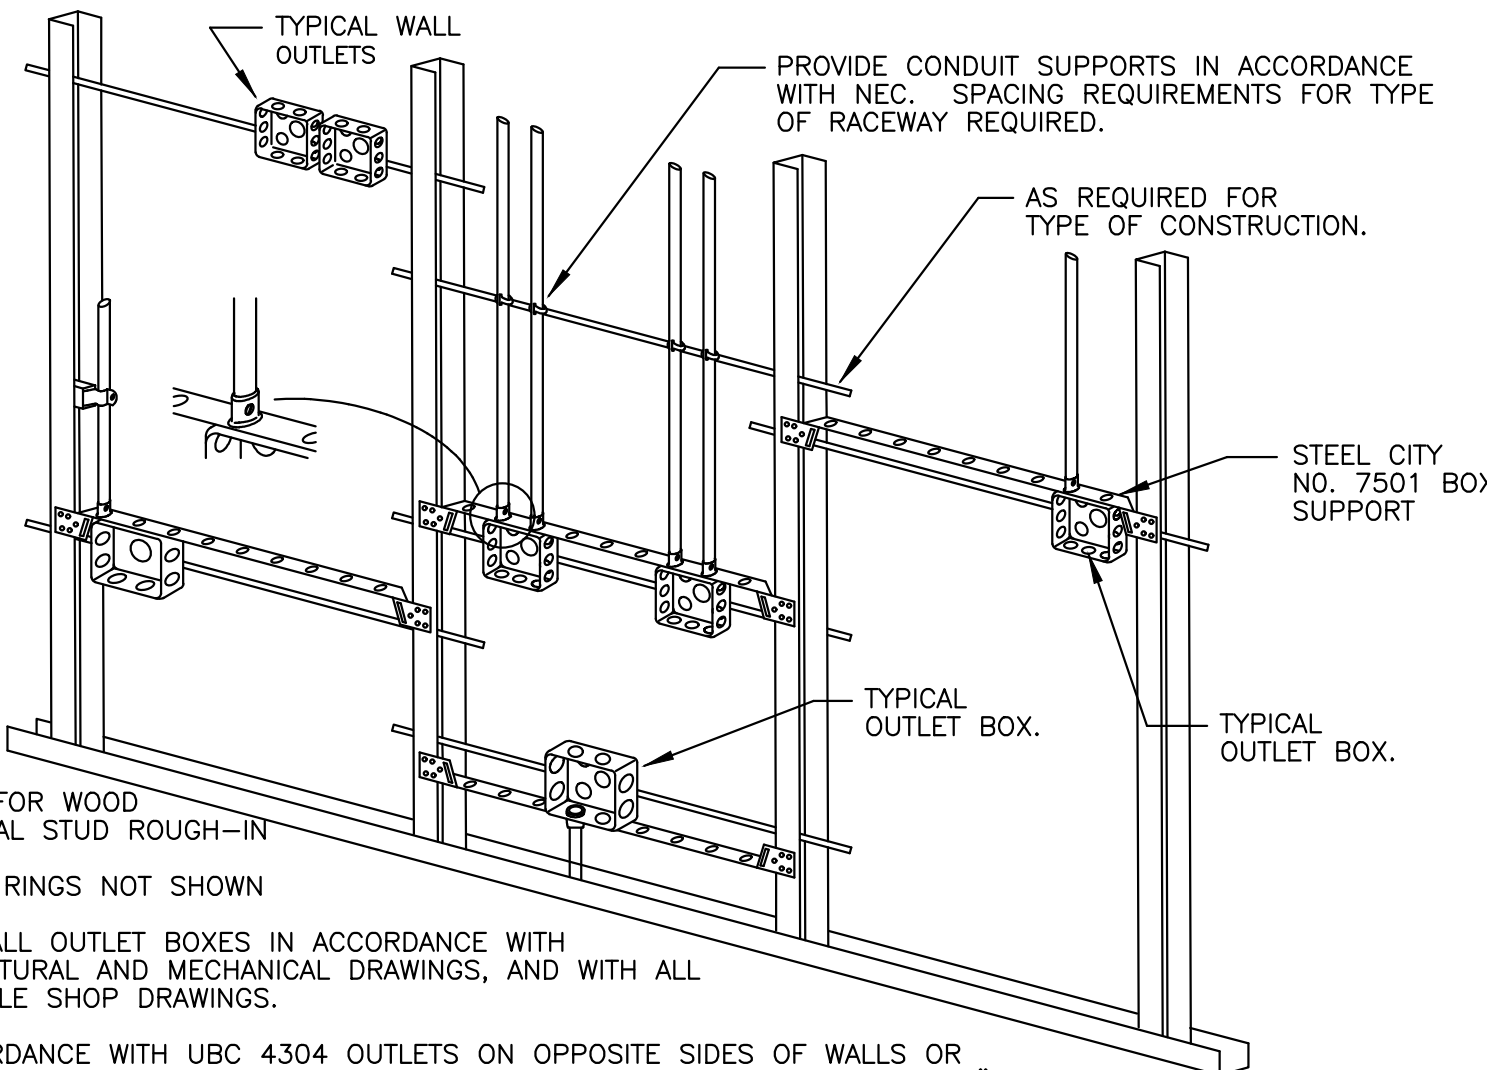- ① FOR CONCRETE BLOCK WALLS, CENTER CAULK CP-25 OR PUTTY 303 WITHIN WALL WITH DAMMING ON BOTH SIDES.
- ② RECOMMENDATIONS BASED ON PRODUCT PERFORMANCE PER ASTM E-814 (UL 1479) FIRE TEST AND UL CLASSIFICATION FIRE STOP SYSTEMS 49, 33 AND 91.
- ③ WET INSTALLED DEPTH OF CAULK CP-25 OR PUTTY 303 DEPENDS ON TYPE AND SIZE OF PIPE:
WET DEPTH PIPE SIZE FIRE RATING
1/2" (13mm) MAX. 6" (203mm) 2 HRS.
1/2" (25mm) MAX. 6" (152mm) 3 HRS.
- ④ UP TO 40% SHRINKAGE OF CP-25 OR PUTTY 303 IS ACCEPTABLE AFTER WET DEPTH INSTALLATION.
- ⑤ OPTIONS TO MASKING TAPE TO PREVENT SAGGING:
A. INSTALL ADDITIONAL DAMMING MATERIAL OVER PRODUCT TO HOLD WITHIN OPENING.
B. REMOVE PRODUCT FROM CONTAINER AND ALLOW TO AIR CURE IN SMALL BATCHES FOR 12 HRS. THEN HAND FORM INTO OPENING.
- ⑥ WHEN ANNULAR SPACE EXCEEDS 3/4" (19mm), A 28 AWG METAL COVER PLATE MUST BE MECHANICALLY SECURED ATOP THE 3M FIRE BARRIER APPLICATION, OR TIGHTLY PACK A NON-COMBUSTIBLE DAMMING MATERIAL ATOP INSTALLED CAULK OR PUTTY.



NOTES:

- ① TYPICAL FOR WOOD AND METAL STUD ROUGH-IN
- ② PLASTER RINGS NOT SHOWN
- ③ LOCATE ALL OUTLET BOXES IN ACCORDANCE WITH ARCHITECTURAL AND MECHANICAL DRAWINGS, AND WITH ALL APPLICABLE SHOP DRAWINGS.
- ④ IN ACCORDANCE WITH UBC 4304 OUTLETS ON OPPOSITE SIDES OF WALLS OR PARTITIONS IN THE SAME STUD SPACE MUST BE SEPARATED BY A MIN. OF 24" HORIZONTAL DISTANCE.

4

E3.0 N.T.S

CONDUIT SUPPORT DETAIL

5

E3.0 N.T.S

FIRE STOP DETAIL

1

E3.0 N.T.S

DETAIL TYPICAL ROUGH-IN REQUIREMENTS


PANEL BOARD SCHEDULES:

PANEL: RP-1A (EX)										MOUNTING: SURFACE				
208Y/120		VOLTS,	3	PHASE,	4	WIRE				PANEL LOCATION:				
MAIN CB:		225 A	MLO:	NA	BUS:	225 A	MIN,			FED FROM: TRANSFORMER				
NOTE:														
CKT NO.	TRIP AMPS	DESCRIPTION OF LOAD	LOAD TYPE	LOAD (KVA)	MINIMUM BRANCH CIRCUIT	PER PHASE (KVA)			MINIMUM BRANCH CIRCUIT	LOAD (KVA)	LOAD TYPE	DESCRIPTION OF LOAD	TRIP AMPS	CKT NO.
						A	B	C						
1	20	3 ATOSA USA, INC.	E	0.99	2#12, #12G, 3/4"	1.93			2#12, #12G, 3/4"	0.94	E	22 ICE MAKER	20	2
3	20	9 REFRIGERATED WORK TOP	E	0.25	2#12, #12G, 3/4"		0.51		2#12, #12G, 3/4"	0.26	E	25 UNDERCOUNTER REFRIGERATOR	20	4
5	20	10 INDUCTION RANGE, COUNTERTOP	E	1.88	2#12, #12G, 3/4"			2.41	2#12, #12G, 3/4"	0.53	E	27 FOUNTAINETTE	20	6
7	20	11 FRENCH FRY WARMER	E	1.26	2#12, #12G, 3/4"	1.62			2#12, #12G, 3/4"	0.36	R	POS RECEPTACLE	20	8
9	20	12 PRESSURE FRYER GAS	E	1.20	2#12, #12G, 3/4"		1.56		2#12, #12G, 3/4"	0.36	R	DESK RECEPTACLE	20	10
11	20	16 MOBILE HEATED CABINET	E	1.68	2#12, #12G, 3/4"			3.41	2#12, #12G, 3/4"	1.73	E	1 WALK IN BOX	20	12
13	20	17 REACH-IN UNDERCOUNTER FREEZER	E	0.30	2#12, #12G, 3/4"	0.88			2#12, #12G, 3/4"	0.58	O	FOOD WARMER	2P-15	14
15	20	18 FOR HOOD LIGHTING	L	0.20	2#12, #12G, 3/4"		0.78			0.58	O			16
17	20	RCP-1	M	0.10	2#12, #12G, 3/4"			0.90	2#12, #12G, 3/4"	0.80	L	LIGHTING ALL AREAS	20	18
19	20	13 GAS FRYER BATTERY	E	1.40	2#12, #12G, 3/4"	2.40			2#12, #12G, 3/4"	1.00	L	SIGNAGE	20	20
21	20	SPARE					1.00		2#12, #12G, 3/4"	1.00	O	HAND DRYER	20	22
23	20	18 SANDWICH/ SALAD PREP. REFRIGERATOR	E	0.62	2#12, #12G, 3/4"			0.80	2#12, #12G, 3/4"	0.18	R	RESTROOM RECEPTACLE	20	24
25	20	19 HEATED HOLDING/WARMING BIN	E	0.40	2#12, #12G, 3/4"	0.94			2#12, #12G, 3/4"	0.54	R	MENU BOARD	20	26
27	20	20 CONVEYOR TOASTER	E	1.78	2#12, #12G, 3/4"		1.98		2#12, #12G, 3/4"	0.20	O	1B FOR SIGN BOARD	20	28
29	20	21 REFRIGERATED MERCHANDISER	E	0.24	2#12, #12G, 3/4"			0.78	2#12, #12G, 3/4"	0.54	R	FOH RECEPTACLE	20	30
31	3P-50	EDH-1 (EX)	H	4.80	3#8, #10G, 3/4"	5.80			2#12, #12G, 3/4"	1.00	E	FUTURE CHEST FREEZER	20	32
33			H	4.80			5.80	2#10, #10G, 3/4"	1.00	E	WALK IN COOLER COMPRESSOR	2P-30	34	
35			H	4.80				1.00	E	36				
37			O	10.90				11.44			2#12, #12G, 3/4"	0.54	E	PREP TABEL RECEPTACLE
39	3P-125	PANEL B (NEW)	O	10.90	4#1, #6G, 1 1/4"		12.15		2#12, #12G, 3/4"	1.25	E	26 SHAKE FREEZER	2P-20	40
41			O	10.90				12.15		1.25	E			42
TOTAL CONNECTED LOAD (KVA)						25.01	23.28	26.24						
LOAD CLASSIFICATION			CONNECTED LOAD (KVA)			DEMAND FACTOR		DEMAND LOAD (KVA)		PANEL TOTAL LOAD				
TOTAL LIGHTING		L	2.00			125%		2.50						
TOTAL RECEPTACLE		R	1.98			100%		1.98		TOTAL CONNECTED LOAD 75.03 KVA				
TOTAL HVAC		H	14.40			100%		14.40		TOTAL DEMAND LOAD 68.01 KVA				
TOTAL MOTOR		M	0.10			100%		0.10		TOTAL CONNECTED CURRENT 208.51 AMP				
TOTAL KITCHEN/EQUIPMENTS		E	21.50			65%		13.97		TOTAL DEMAND CURRENT 189.00 AMP				
TOTAL OTHER/MISCELLANEOUS		O	35.06			100%		35.06		MAIN CIRCUIT BREAKER RATING 200.00 AMP				

PANEL: B (NEW)										MOUNTING: SURFACE															
208Y/120		VOLTS,		3	PHASE,		4	WIRE		PANEL LOCATION:															
MAIN CB:		125 A		MLO:		BUS:		125 A		MIN,		AIC RATING:		10KA		FED FROM: PANEL RP-1A (EX)									
NOTE:																									
CKT NO.	TRIP AMPS	DESCRIPTION OF LOAD	LOAD TYPE	LOAD (KVA)	MINIMUM BRANCH CIRCUIT	PER PHASE (KVA)			MINIMUM BRANCH CIRCUIT	LOAD (KVA)	LOAD TYPE	DESCRIPTION OF LOAD	TRIP AMPS	CKT NO.											
						A	B	C																	
1	3P-60	WH-1	H	5.00	3#6, #10G, 3/4"C	8.60			3#8, #10G, 3/4"C	3.60	H	MAU-1	3P-50	2											
H			5.00			8.60		3.60		H	4														
3			H	5.00				8.60							3.60	H	6								
5	3P-20	KEF-1	H	1.20	3#12, #12G, 3/4"C	1.38			2#12, #12G, 3/4"C	0.18	R	ROOF RECEPTACLE	20	8											
7			H	1.20			1.92			2#12, #12G, 3/4"C	0.72				R	KITCHEN RECEPTACLE	20	10							
9			H	1.20				1.55			2#12, #12G, 3/4"C				0.35				E	28 COUNTER TOP FOUNTAIN MACHINE	20	12			
11											2#12, #12G, 3/4"C				0.10				O				FIRE ALARM CONTROL PANEL	20	14
13			20	JB FOR HOOD/ANSUL		O	0.20	2#12, #12G, 3/4"C		0.30									2#12, #12G, 3/4"C						
15	20	WAFFLE MAKERS	E	1.44	2#12, #12G, 3/4"C		2.88		2#12, #12G, 3/4"C			SPARE	20	18											
17	20	JB FOR EMERGENCY SOLENOID VALVE	O	0.30	2#12, #12G, 3/4"C			0.30																	
TOTAL CONNECTED LOAD (KVA)						10.28	13.40	10.45																	
LOAD CLASSIFICATION			CONNECTED LOAD (KVA)			DEMAND FACTOR		DEMAND LOAD (KVA)		PANEL TOTAL LOAD															
TOTAL LIGHTING			L	0.00	125%	0.00	TOTAL CONNECTED LOAD								34.13	KVA									
TOTAL RECEPTACLE			R	0.90	100%	0.90	TOTAL DEMAND LOAD								33.00	KVA									
TOTAL HVAC			H	29.40	100%	29.40	TOTAL CONNECTED CURRENT								94.83	AMP									
TOTAL MOTOR			M	0.00	100%	0.00	TOTAL DEMAND CURRENT								91.70	AMP									
TOTAL KITCHEN/EQUIPMENTS			E	3.23	65%	2.10	MAIN CIRCUIT BREAKER RATING								125.00	AMP									
TOTAL OTHER/MISCELLANEOUS			O	0.60	100%	0.60																			

PANEL BOARD SCHEDULES NOTES:

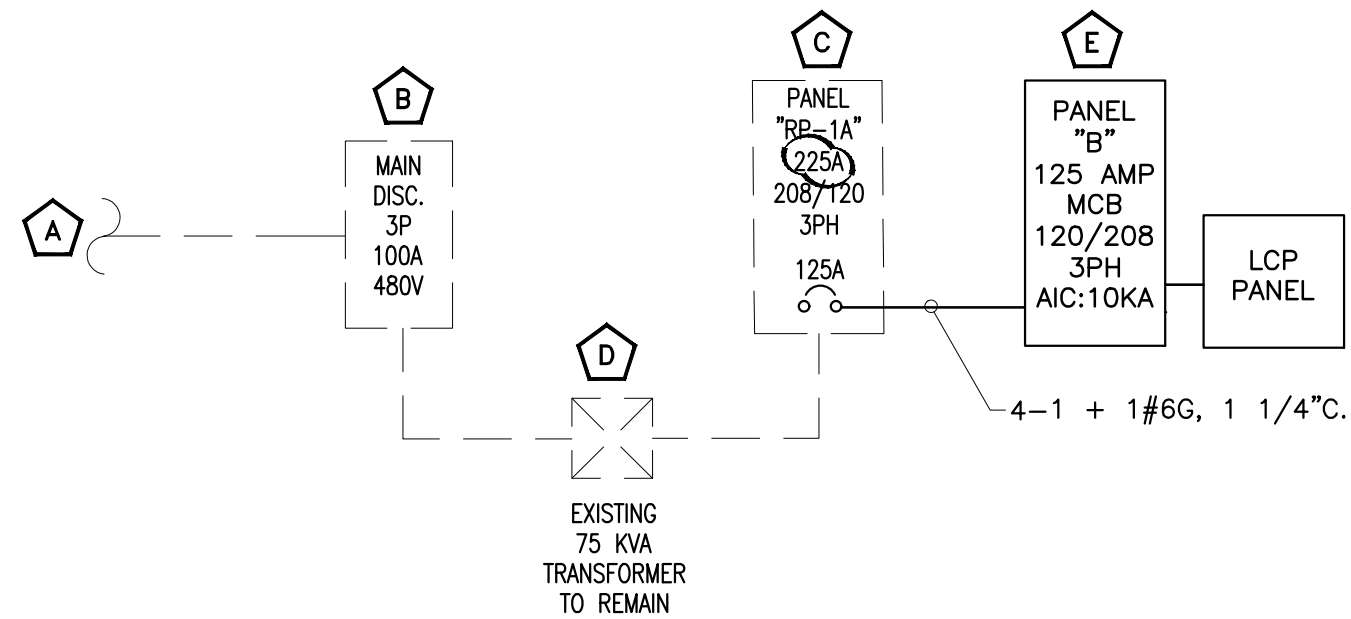- A. ALL CIRCUITING SHOWN IS FOR REFERENCE PURPOSE ONLY. E.C. SHALL VERIFY CIRCUITING OF THE EXISTING DEVICES IN FIELD AND INFORM ENGINEER FOR DISCREPANCIES.
- B. ELECTRICAL CONTRACTOR SHALL VERIFY EXACT CIRCUIT NUMBER & BREAKER SIZE OF THE EXISTING DEVICE IN FIELD.



INTERIOR

FIRST FLOOR

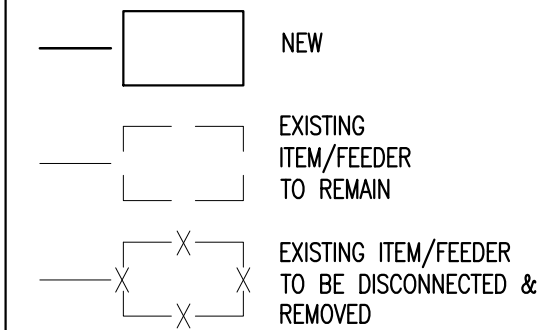
ELECTRICAL RISER KEYED WORK NOTES:

- A** EXISTING 100 AMPS 480 VOLTS 3 PHASE SERVICE FOR THE SPACE FROM LANDLORD PANEL. E.C. SHALL FIELD VERIFY THE EXISTING POWER DISTRIBUTION AND CONNECTION IN FIELD. INFORM ENGINEER FOR ANY DISCREPANCY PRIOR COMMENCING ANY WORK.
- B** EXISTING 100A, 480V, 3-PHASE ELECTRICAL DISCONNECT SWITCH TO REMAIN. E.C. SHALL VERIFY THE RATING AND CONNECTION IN FIELD. INFORM ENGINEER FOR ANY DISCREPANCY PRIOR COMMENCING ANY WORK.
- C** EXISTING 225A, 120/208V, 3-PHASE ELECTRICAL PANEL TO REMAIN. E.C. SHALL VERIFY THE RATING AND CONNECTION IN FIELD. INFORM ENGINEER FOR ANY DISCREPANCY PRIOR COMMENCING ANY WORK.
- D** EXISTING 75KVA, 3-PHASE TRANSFORMER TO REMAIN. E.C. SHALL VERIFY EXACT SIZE AND OPERABLE CONDITION ON FIELD. PROVIDE NEW TRANSFORMER OF THE SAME RATING AS MENTIONED IF FOUND INOPERABLE.
- E** NEW 125A, 120/208V, 3-PHASE ELECTRICAL PANEL WITH 10KA AIC RATING. E.C. SHALL COORDINATE WITH ARCHITECT/ OWNER FOR LOCATION.

NOTE:

- E.C. SHALL VERIFY INCOMING SERVICE AMPERAGE, WIRE SIZING AND DISTRIBUTION.
- ELECTRICAL CONTRACTOR TO COORDINATE FAULT CURRENT (Isc) RATING WITH UTILITY COMPANY AND AHJ PRIOR TO COMMENCING ANY WORK.

ELECTRICAL RISER SYMBOLS:




ELECTRICAL RISER

SCALE
N.T.S.

1

 PLUMBING LEGENDS

----	EXISTING DOMESTIC COLD WATER PIPING
-----	DOMESTIC COLD WATER PIPING
-----	DOMESTIC HOT WATER PIPING
-----	HOT WATER RECIRCULATION PIPING
----	VENT PIPING
----	EXISTING SANITARY PIPING
-----	WASTE (SANITARY SEWER)
-----	UNDERGROUND WASTE (SANITARY SEWER)
----	EXISTING GAS PIPING
----	GAS PIPING
	GATE VALVE
-----	BALANCING VALVE
—○—	PIPE UP
—○—	PIPE DOWN
	FLOOR DRAIN
	FLOOR CLEAN OUT
	FLOOR SINK
GC	GENERAL CONTRACTOR
CO	FLOOR CLEAN OUT
FD	FLOOR DRAIN
CW	COLD WATER
HW	HOT WATER
	TIE INTO EXISTING

NOT ALL SYMBOLS AND ABBREVIATIONS IN THIS LEGEND WILL APPEAR IN DRAWING.

PLUMBING ABBREVIATIONS

CO	CLEANOUT
CODP	CLEAN OUT DECK PLATE
CW	COLD WATER
HW	HOT WATER
HWR	HOT WATER RETURN
SAN	SANITARY
V	VENT
W	WASTE
LAV	LAVATORY
WC	WATER CLOSET
TYP.	TYPICAL
DN	DOWN
AFF	ABOVE FINISH FLOOR
FD	FLOOR DRAIN
SQ. FT.	SQUARE FEET
BFP	BACK FLOW PREVENTER
KS	KITCHEN SINK
HWHT	HOT WATER HEATER
SK	SINK
ST	STORM
FS	FLOOR SINK
FD	FLOOR DRAIN

BUILDING DEPARTMENT PLUMBING NOTES

- ALL PLUMBING SYSTEMS (SANITARY, WASTE, VENT & WATER DISTRIBUTION PIPING SYSTEMS) AND ASSOCIATED EQUIPMENT SHALL BE INSTALLED, OPERATED AND MAINTAINED IN ACCORDANCE WITH THE REQUIREMENTS OF 2018 NATIONAL STANDARD PLUMBING CODE NEW JERSEY EDITION (NSPC).
- INSTALLATION OF UNDERGROUND PIPING SHALL BE IN ACCORDANCE WITH THE REQUIREMENTS OF SECTION 2.6.6.
- PROTECTION OF PIPING AND PLUMBING SYSTEM AS PER CHAPTER 2 SECTION 2.9.
- TRENCHING, EXCAVATION AND BACKFILL AS PER CHAPTER 2 SECTION 2.6.
- MATERIAL USED IN PLUMBING SYSTEM SHALL BE IN ACCORDANCE WITH THE REQUIREMENTS OF CHAPTER 3.
- EQUIPMENT CONNECTIONS AND JOINING OF PIPING SHALL BE IN ACCORDANCE WITH THE REQUIREMENTS OF CHAPTER 4.
- DEEP SEAL TRAPS FOR FLOOR DRAINS AND CLEAN-OUTS SHALL BE INSTALLED IN ACCORDANCE WITH THE REQUIREMENTS OF CHAPTER 5.
- DRAINAGE PIPE CLEANOUTS AS PER SECTION 5.4.
- VERTICAL AND HORIZONTAL PIPING SHALL BE SUPPORTED IN ACCORDANCE WITH THE REQUIREMENTS OF CHAPTER 8.
- WATER SUPPLY SYSTEM SHALL BE INSTALLED AND MAINTAINED IN ACCORDANCE WITH THE REQUIREMENTS OF CHAPTER 10.
- THE SANITARY DRAINAGE SYSTEM SHALL BE SIZED AND INSTALLED IN ACCORDANCE WITH THE REQUIREMENTS OF CHAPTER 11.
- VENT PIPING FOR THE SANITARY DRAINAGE SYSTEM SHALL BE INSTALLED IN ACCORDANCE WITH REQUIREMENTS OF CHAPTER 12
- INSPECTION AND TESTING OF PLUMBING AND GAS PIPING SYSTEM SHALL BE IN ACCORDANCE WITH CHAPTER 15 OF 2018 NSPC AND SECTION 406 OF 2018 IFGC.

PLUMBING DRAWING LIST

P0.1	PLUMBING NOTES AND SPECIFICATIONS(1 OF 2)
P0.2	PLUMBING NOTES AND SPECIFICATIONS(2 OF 2)
P1.0	PLUMBING SANITARY FLOOR PLAN
P1.1	PLUMBING DOMESTIC WATER PLAN
P1.2	PLUMBING GAS PLAN
P5.0	PLUMBING DETAILS
P6.0	PLUMBING RISER DIAGRAMS

PLUMBING SPECIFICATIONS

1. BASIC PLUMBING REQUIREMENTS, MATERIALS AND METHODS

1.01 SCOPE

- PROVIDE ALL MATERIAL, TOOLS, SUPERVISION AND LABOR INCLUDING ALL MISCELLANEOUS AND INCIDENTAL ITEMS REQUIRED FOR COMPLETE AND OPERABLE PLUMBING INSTALLATIONS AS SHOWN OR DESCRIBED ON THE DRAWINGS AND IN THESE SPECIFICATIONS.
- THE CONTRACTOR SHALL BE RESPONSIBLE FOR THE PROTECTION OF ALL NEW CONDITIONS AND MATERIALS WITHIN THE CONSTRUCTION AREA. ANY DAMAGE CAUSED BY THE CONTRACTOR SHALL BE REPAIRED TO THE OWNER'S SATISFACTION.
- OBTAIN ALL PERMITS, PAY ALL PERMIT FEES AND SCHEDULE ALL REQUIRED INSPECTIONS. COPIES OF ALL PERMITS AND INSPECTION CERTIFICATES SHALL BE FORWARDED TO THE OWNER FOR RECORD.
- THE GENERAL CONDITIONS OF THE CONTRACT AND ALL DIVISION 1 REQUIREMENTS APPLY TO THE WORK OF THIS SECTION.
- THE CONTRACTOR SHALL VISIT THE SITE PRIOR TO SUBMITTING BID TO DETERMINE CONDITIONS AND THE EXTENT OF THE WORK. BY COMMENCING WORK, THE CONTRACTOR ACKNOWLEDGES HIS CONFIRMATION OF ALL CONDITIONS AS ACCEPTABLE WITH REFERENCE TO HIS CONTRACT, SCOPE OF WORK AND BID PRICE SUCH THAT NO ADDITIONAL COMPENSATION SHALL BE FORTHCOMING FOR UNFORESEEN EXISTING CONDITIONS.
- IN ALL AREAS SUBJECT TO FREEZING CONDITIONS, THE CONTRACTOR SHALL PROVIDE FREEZE PROTECTION FOR ALL DOMESTIC WATER PIPING INSTALLED UNDER HIS CONTRACT.
- ALL ELECTRICAL REQUIREMENTS SHALL BE COORDINATED WITH THE CONTRACTOR FOR ELECTRICAL WORK. THIS CONTRACTOR IS RESPONSIBLE FOR ALL LOW VOLTAGE WIRING FOR EQUIPMENT INSTALLED UNDER HIS CONTRACT. THE CONTRACTOR FOR ELECTRICAL WORK IS RESPONSIBLE FOR LINE VOLTAGE POWER WIRING ONLY.
- COLOR AND FINISH SELECTIONS FOR ALL MATERIALS, INCLUDING PAINTING OF PIPING, SHALL BE AS DIRECTED AND/OR APPROVED BY THE ARCHITECT.
- MINOR DETAILS NOT SHOWN OR SPECIFIED, BUT NECESSARY FOR THE PROPER AND ACCEPTABLE CONSTRUCTION, INSTALLATION OR OPERATION OF ANY PART OF THE WORK AS DETERMINED BY THE ENGINEER SHALL BE INCLUDED AS IF SPECIFIED OR INDICATED ON THE DRAWINGS.
- THIS CONTRACTOR SHALL BE RESPONSIBLE FOR COORDINATING ALL REQUIREMENTS FOR THE INSTALLATION, CONNECTION, EXTENSION OR MODIFICATION TO ALL UTILITY SERVICES WITH RESPECTIVE PROVIDERS INCLUDING PAYMENT OF ALL ASSOCIATED FEES.
- THE CONTRACTOR IS RESPONSIBLE FOR ALL PAINTING ASSOCIATED WITH CUTTING AND PATCHING. ALL PAINTING IN AREAS WITH COMPLETE FINISH RENOVATIONS SHALL BE PROVIDED BY THE GENERAL CONTRACTOR.

1.02 SUBMITTALS

- SUBMITTAL REQUIREMENTS SHALL BE COORDINATED WITH THE ARCHITECT AND AUTHORITIES HAVING JURISDICTION. UNLESS OTHERWISE DIRECTED, CONTRACTOR SHALL PROVIDE SUBMITTALS AS LISTED BELOW.
 - PIPE AND FITTINGS
 - VALVES
 - HANGERS AND SUPPORTS
 - PLUMBING PIPING LAYOUT
 - TESTS
 - PLUMBING FIXTURES
 - WATER HEATERS & ACCESSORIES
 - FLOOR DRAINS
 - MIXING VALVES
 - ALL SCHEDULED PLUMBING EQUIPMENT
- SUBMITTALS FROM SUPPLIERS OR MANUFACTURERS WHICH DO NOT BEAR THE STAMP OF THE SUBMITTING CONTRACTOR INDICATING THAT THE CONTRACTOR HAS REVIEWED THE SUBMITTAL FOR CONFORMANCE WITH THE PROJECT REQUIREMENTS WILL BE RETURNED REJECTED.
- THE ENGINEER'S REVIEW OF SUBMITTALS IS A COURTESY WHICH DOES NOT RELIEVE THE CONTRACTOR FROM CONFORMING WITH THE CONSTRUCTION DOCUMENTS, REGARDLESS OF THE ACTION INDICATED BY THE SHOP DRAWINGS STAMP.
- REVIEW OF SHOP DRAWINGS BY THE ENGINEER SHALL BE LIMITED TO THE INITIAL REVIEW, AND A SECOND REVIEW OF ANY REQUIRED RESUBMITTED DATA. IF THE ENGINEER IS REQUIRED TO REVIEW SHOP DRAWINGS FOR A THIRD (OR MORE) SUBMISSION OF THE SAME ITEM, THE CONTRACTOR SHALL BE LIABLE FOR COMPENSATING THE ENGINEER FOR THESE SUBSEQUENT REVIEWS AS PER THE ENGINEER'S CURRENT HOURLY RATE SCHEDULE.
- SUBMIT PROOF OF APPROVAL AND/OR CONFIRMATION OF SATISFACTORY TEST RESULTS TO THE OWNER AND THE ARCHITECT.
- SUBMIT TO THE OWNER'S MAINTENANCE PERSONNEL OPERATION AND MAINTENANCE DATA FOR ALL SYSTEM COMPONENTS, SERVICING REQUIREMENTS, INSPECTION DATA, REPLACEMENT PART NUMBERS AND AVAILABILITY AND CONTACT INFORMATION FOR SERVICE/SUPPLY COMPANY.
- FOR ALL BELOW GRADE PIPING WHERE ACTUAL INSTALLATION DEVIATES FROM CONSTRUCTION DRAWINGS, THE CONTRACTOR SHALL PROVIDE AS-BUILT DRAWINGS INDICATING BELOW GRADE PIPE LOCATIONS DIMENSIONED TO NEAREST COLUMN LINES.
- RECORD AS-BUILT DRAWINGS SHALL BE SUPPLIED TO THE OWNER/TENANT AFTER COMPLETION OF THE WORK SHOWING ANY ALTERATIONS, ADDITIONS AND/OR DELETIONS TO THE SYSTEM(S) INSTALLED.

1.03 SUBSTITUTIONS

- ALL EQUIPMENT SHALL BE PRODUCTS OF THE SPECIFIED MANUFACTURER OR MANUFACTURERS. ALL BIDS SHALL BE BASED ON THE SPECIFIED MANUFACTURER OR MANUFACTURER'S EQUIPMENT. FOR SUBSTITUTIONS OF OTHER MANUFACTURER'S EQUIPMENT TO BE CONSIDERED, THE SUBSTITUTION MUST BE INDICATED PRIOR TO BIDDING WITH THE REASON FOR THE PROPOSED SUBSTITUTION IDENTIFIED, AND THE PROPOSED CREDIT TO THE OWNER INDICATED. THE ENGINEER SHALL DETERMINE THE ACCEPTABILITY OF ANY PROPOSED SUBSTITUTIONS.
- THE CONTRACTOR ASSUMES ALL RESPONSIBILITY FOR COORDINATING THE WORK OF OTHER TRADES WHICH MAY BE AFFECTED BY SUBSTITUTIONS, INCLUDING ALL RELATED COSTS.

1.04 DEFINITIONS

- FURNISH: TO PURCHASE, PROCURE, ACQUIRE AND DELIVER, COMPLETE WITH RELATED ACCESSORIES.

- INSTALL: TO ERECT, MOUNT AND CONNECT, COMPLETE WITH RELATED ACCESSORIES.

- PROVIDE: TO FURNISH AND INSTALL.

- PLUMBING CONTRACTOR, THE CONTRACTOR, THIS CONTRACTOR: THE CONTRACTOR FOR PLUMBING WORK WHICH IS SPECIFIED HEREIN AND SHOWN ON THESE DRAWINGS.

- REFER TO THE NATIONAL STANDARD PLUMBING CODE FOR ADDITIONAL DEFINITIONS.

1.05 DRAWINGS

- THE DRAWINGS ARE DIAGRAMMATIC AND ARE INTENDED TO ILLUSTRATE THE GENERAL ARRANGEMENT AND ROUTING OF PIPING AND GENERAL LOCATIONS OF EQUIPMENT. PRECISE LOCATIONS OF EQUIPMENT, RISERS AND STACKS, AND ROUTING AND ELEVATION OF ALL PIPING SYSTEMS SHALL BE COORDINATED IN THE FIELD WITH THE ARCHITECT, ARCHITECTURAL DRAWINGS, THE WORK OF OTHER TRADES, EXISTING AND NEW BUILDING CONDITIONS AND/OR THE PREFERENCES OF THE OWNER/TENANT AS CONSTRUCTION PROCEEDS. ALL PIPING SHALL BE INSTALLED CONCEALED IN FINISHED SPACES, UNLESS NOTED OTHERWISE.

- PROVIDE ALL NECESSARY INCIDENTAL MATERIALS AND ACCESSORIES REQUIRED TO MAKE THE WORK COMPLETE IN ALL RESPECTS, EVEN IF NOT PARTICULARLY SHOWN OR SPECIFIED.

- REFER TO PLUMBING EQUIPMENT/FIXTURE SCHEDULE ON THE DRAWINGS FOR ALL FIXTURE AND EQUIPMENT SPECIFICATIONS.

- REFER TO FIXTURE CONNECTION SIZE SCHEDULE FOR ALL FIXTURE ROUGHING SIZE REQUIREMENTS.

- VERIFY ALL INDICATED CONDITIONS BEFORE STARTING WORK AND REPORT ANY DISCREPANCIES. THE DRAWINGS REFLECT CONDITIONS WHICH CAN BE REASONABLY INTERPRETED FROM THE EXISTING VISIBLE CONDITIONS OR FROM DRAWINGS AND INFORMATION FURNISHED BY THE OWNER.

- LOCATE ALL FIXTURES AND EQUIPMENT AS PER THE FINAL ARCHITECTURAL DRAWINGS.

1.06 PRODUCTS

A. SANITARY AND VENT PIPING:

- ABOVE GRADE PIPING SHALL BE HUBLESS CAST IRON PIPE WITH STAINLESS STEEL COUPLINGS AND ELASTOMERIC GASKETS WITH A MINIMUM NO. OF BANDS PER COUPLING AS PER CISPI 310-12.
- SLOPE OF DRAINAGE SYSTEM SHALL BE 1/8" PER FOOT OF RUN FOR PIPE OVER 3" (I.D.) AND 1/4" PER FOOT OF RUN FOR PIPE 3" AND SMALLER (I.D.). VENT PIPING SHALL BE PITCHED TO DRAIN.
- PVC OR OTHER COMBUSTIBLE PLASTIC PIPING SHALL NOT BE INSTALLED IN CEILING PLENUM SPACES.
- ALL CAST IRON SOIL PIPE AND FITTINGS SHALL BE MARKED WITH THE COLLECTIVE TRADEMARK OF THE CAST IRON SOIL PIPE INSTITUTE (CISPI) AND BE LISTED BY NSF INTERNATIONAL

B. DOMESTIC WATER PIPING:

- ABOVE GRADE WATER PIPING SHALL BE TYPE 'L' HARD-DRAWN COPPER TUBE.
- FITTINGS IN DOMESTIC WATER PIPING SHALL BE WROUGHT COPPER OR CAST BRASS.
- JOINTS SHALL BE MADE WITH LEAD-FREE SOLDER.
- THE ENTIRE DOMESTIC WATER DISTRIBUTION SYSTEM SHALL BE INSULATED INCLUDING ALL VALVES, FITTINGS, ETC.
- COMPLY WITH NSF 61 FOR MATERIALS FOR WATER-SERVICE PIPING AND SPECIALTIES FOR DOMESTIC WATER.
- ALL DOMESTIC WATER PIPING ABOVE GRADE SHALL BE INSULATED WITH FIRE-RETARDANT, FACTORY-APPLIED JACKET. PROVIDE COLD WATER PIPING WITH FACTORY-APPLIED VAPOR BARRIER. INSULATION REQUIREMENT SHOULD COMPLY WITH ASHRAE 90.1 2016 SECTION ENERGY CONSERVATION CODE 7.4.3 REFER BELOW TABLE.

MINIMUM PIPE INSULATION THICKNESS							
FLUID OPERATING TEMPERATURE RANGE AND USAGE (°F)	INSULATION CONDUCTIVITY		NOMINAL PIPE OR TUBE SIZE (INCHES)				
	CONDUCTIVITY BTU-IN./ (H-FT ² -°F)	MEAN RATING TEMPERATURE, °F	<1	1 to < 1½	1½ to < 4	4 to < 8	>8
141–200	0.25–0.29	125	1.5	1.5	2	2	2
105–140	0.21–0.28	100	1.0	1.0	1.5	1.5	1.5
40–60	0.21–0.27	75	0.5	0.5	1.0	1.0	1.0

- AS PER ASHRAE 90.1 2016 SECTION 7.4.4.1 TEMPERATURE CONTROLS SHALL BE PROVIDED THAT ALLOW FOR STORAGE TEMPERATURE ADJUSTMENT FROM 120° OR LOWER TO A MAXIMUM TEMPERATURE COMPATIBLE WITH INTENDED USE.
- AS PER ASHRAE 90.1 2016 SECTION 7.4.4.2, SYSTEM DESIGNED TO MAINTAIN USAGE TEMPERATURE IN HOT WATER PIPES, SUCH AS RE-CIRCULATING HOT WATER SYSTEMS OR HEAT TRACE, SHALL BE EQUIPPED WITH AUTOMATIC TIME SWITCHES OR OTHER CONTROLS THAT CAN BE USED TO SWITCH THE USAGE TEMPERATURE MAINTENANCE SYSTEM DURING EXTENDED PERIOD WHEN HOT WATER IS NOT REQUIRED.
- AS PER ASHRAE 90.1 2016 SECTION 7.4.4.3, TEMPERATURE CONTROLLING MEANS SHALL BE PROVIDED TO LIMIT THE MAXIMUM TEMPERATURE OF WATER DELIVERED FROM LAVATORY FAUCETS IN PUBLIC FACILITY RESTROOMS TO 110°F.
- AS PER ASHRAE 90.1 2016 SECTION 7.4.4.4, WHEN USED TO MAINTAIN STORAGE TANK WATER TEMPERATURE, RECIRCULATING PUMPS SHALL BE EQUIPPED WITH CONTROLS LIMITING OPERATION TO A PERIOD FROM THE START OF THE HEATING CYCLE TO A MAXIMUM OF FIVE MINUTES AFTER THE END OF THE HEATING CYCLE.
- SEAL ALL JOINTS BETWEEN SEGMENTS OF INSULATION.
- PROVIDE SHIELDS BETWEEN HANGERS AND INSULATION.
- AS PER IECC 2018 C404.3 STORAGE TANK TYPE WATER HEATERS AND HOT WATER STORAGE TANKS THAT HAVE VERTICAL WATER PIPES CONNECTING TO THE INLET AND OUTLET OF THE TANK SHALL BE PROVIDED WITH INTEGRAL HEAT TRAPS AT THOSE INLETS AND OUTLETS OR SHALL HAVE PIPE CONFIGURED HEAT TRAPS IN THE PIPING CONNECTED TO THOSE INLETS AND OUTLETS.

A. HANGERS AND SUPPORTS:

- HANGERS SHALL BE STANDARD STEEL, MALLEABLE OR WROUGHT IRON, AS MANUFACTURED BY GRINNELL OR APPROVED EQUAL, SUITABLE FOR THE TYPE OF CONSTRUCTION. PIPING SHALL NOT BE HUNG FROM OTHER PIPE.
- SECTIONS OF INDIVIDUAL PIPE RUNS SHALL BE SUPPORTED BY CLEVIS HANGERS.
- ALL EQUIPMENT SHALL BE PROVIDED WITH APPROVED SUPPORTS.
- PROVIDE SEISMIC RESTRAINTS IN ACCORDANCE WITH ALL APPLICABLE FEDERAL, STATE AND LOCAL CODES AND STANDARDS AND THE REQUIREMENTS OF AUTHORITIES HAVING JURISDICTION.
- UNLESS OTHERWISE INDICATED OR REQUIRED BY AUTHORITIES HAVING JURISDICTION, THE FOLLOWING SHALL BE PROVIDED WITH SEISMIC RESTRAINTS AS REQUIRED BY THE BOCA NATIONAL BUILDING CODE, SECTION 1610.6.4: ALL EQUIPMENT AND MACHINERY, ALL NEW PIPING 2–1/2" AND LARGER (1–1/4" AND LARGER INBOILER/MECHANICAL ROOMS) WITH HANGERS GREATER THAN 12" IN LENGTH FROM THE TOP OF PIPE TO THE STRUCTURE.
- SUPPORTS SHALL BE PROVIDED IN STRICT ACCORDANCE WITH THE RECOMMENDATIONS OF THE PIPING MANUFACTURER.

D. HEAT TRACING

- HEATING CABLES SHALL BE SELF-REGULATING, CAPABLE OF MAINTAINING MINIMUM TEMPERATURE OF 40°F.
- CABLE MUST BE OF PARALLEL CONSTRUCTION SO THAT IT CAN BE CUT TO LENGTH WITHOUT CHANGING ITS POWER OUTPUT PER UNIT LENGTH.
- THE HEATER CABLE ASSEMBLY SHALL HAVE A MONOLITHIC HEATING CORE CONSTRUCTION CONSISTING OF TWO PARALLEL 16 AWG NICKELPLATED COPPER BUS CONDUCTORS WITH A SEMICONDUCTIVE PTC POLYMER EXTRUDED OVER AND BETWEEN THESE PARALLEL CONDUCTORS. A POLYETHYLENE DIELECTRIC INSULATING JACKET IS EXTRUDED OVER THE HEATING ELEMENT CORE.
- THE SEMICONDUCTIVE HEATING MATRIX AND PRIMARY INSULATING JACKET SHALL BE CROSS-LINKED BY IRRADIATION.
- THE BASIC CABLE WILL BE COVERED BY MEANS OF A METALLIC BRAID OF TINNED COPPER. THE BRAID WILL PROVIDE A NOMINAL COVERAGE OF EIGHTY PERCENT (80%) AND WILL EXHIBIT A RESISTANCE NOT EXCEEDING 0.0045 OHM/FT.
- THE CABLE SHALL BE COVERED WITH A CORROSION RESISTANT OVERJACKET OF THERMOPLASTIC ELASTOMER (FOR POSSIBLE EXPOSURE TO AQUEOUS SOLUTIONS, MILD ACIDS OR BASES) OR FLUOROPOLYMER (FOR POSSIBLE EXPOSURE TO ORGANIC CHEMICALS OR CORROSIVES).
- LONG TERM STABILITY SHALL BE ESTABLISHED BY THE SERVICE LIFE PERFORMANCE TEST PER IEEE 515 STD-2004.

E. VALVES:

- PROVIDE GATE VALVES, BUTTERFLY OR BALL VALVES FOR SHUT-OFF DUTY ON MAIN AND BRANCH SUPPLY LINES. FOR ALL PIPE RUNS 2" AND SMALLER, PROVIDE BALL FOR ALL PIPE RUNS LARGER THAN 2" AND SMALLER THAN 4", PROVIDE GATE VALVES. PIPING 4" AND LARGER, PROVIDE BUTTERFLY VALVES FOR SHUT-OFF DUTY.
- ALL FIXTURES WITH THE EXCEPTION O FLUSHOMETER-EQUIPPED WATER CLOSETS AND URINALS SHALL HAVE STOP VALVES TO CONTROL SUPPLY TO THE FIXTURE. WHERE SUPPLIES ARE EXPOSED PROVIDE CHROME-PLATED STOPS WITH CHROME-PLATED ESCUTCHEONS ON PIPING PENETRATIONS.
- ALL PLUMBING FIXTURES AND EQUIPMENT TO HAVE SHUT-OFF VALVES ON SUPPLY LINES.
- ALL BRANCH LINES TO HAVE SHUT-OFF VALVES.
- ALL VALVES SHALL BE ACCESSIBLE. PROVIDE ACCESS DOORS WHERE REQUIRED FOR VALVE ACCESS.
- PROVIDE GLOBE VALVES FOR THROTTLING/BALANCING OF THE HOT WATER CIRCULATING SYSTEM.

E. SLEEVES AND ESCUTCHEONS:

- SLEEVES THROUGH STRUCTURAL CONCRETE MEMBERS AND SLEEVES FOR WALLS BELOW GRADE AND FLOORS ON GRADE SHALL BE STANDARD WEIGHT GALVANIZED SCHEDULE 40 STEEL PIPE. SLEEVES THROUGH OTHER THAN STRUCTURAL COMPONENTS OF THE BUILDING SHALL BE 20 GAGE GALVANIZED SHEET METAL WITH LOCK SEAM JOINTS. USG THERMAFIBER SAFING INSULATION SHALL BE INSTALLED BETWEEN PIPE AND SLEEVE.
- PIPE ESCUTCHEON PLATES SHALL BE INSTALLED WHERE EXPOSED PIPING PASSES THROUGH WALLS, CEILINGS, AND FLOORS AND SHALL BE MINIMUM 20 GAGE STEEL. PROVIDE CHROME PLATED ESCUTCHEON PLATES IN FINISHED AREAS.

F. DRAINAGE ACCESSORIES

1.GENERAL:

- INSTALL THE WORK OF THIS SECTION IN ACCORDANCE WITH THE MANUFACTURER'S PRINTED INSTALLATION INSTRUCTIONS, UNLESS OTHERWISE SPECIFIED.
- SECURE EXTERNAL COMPONENTS IN PLACE WITH VANDAL RESISTANT FASTENERS OR DEVICES WHICH CANNOT BE REMOVED WITHOUT SPECIAL TOOLS.
- INSTALL PIPING TO CONSERVE BUILDING SPACE. DO NOT INTERFERE WITH USE OF BUILDING SPACE AND THE WORK OF OTHER TRADES. ALL PIPING RUN IN CEILING SHALL BE INSTALLED TIGHT TO THE STRUCTURE ABOVE.
- INSTALL PIPING TO ALLOW FOR EXPANSION AND CONTRACTION WITHOUT STRESSING PIPE, JOINTS OR CONNECTED EQUIPMENT. PROVIDE PIPE ANCHORS, GUIDES AND EXPANSION JOINTS OR LOOPS IN ALL HOT WATER AND HOT WATER CIRCULATING MAIN SUPPLY PIPING AND SEGMENTS OF SUCH PIPE THAT EXCEED 30'–0" IN LENGTH.
- IN ALL AREAS WITH FINISHED SURFACES, SYSTEM PIPING AND COMPONENTS SHALL BE CONCEALED ABOVE OR WITHIN FINISHED SURFACES.

2.03 INSULATION

COVER ALL HOT WATER AND HOT WATER RECIRCULATION PIPE WITH 1" THICK FOR PIPE SIZE UP TO 1½" AND 1½" THICK FOR PIPE SIZE 1½" AND GREATER WITH MANVILLE MICRO-LOK AP-T PLUS FIBERGLASS INSULATION. COVER ALL COLD WATER PIPE WITH ½" THICK FOR PIPE SIZE UP TO 1¼" AND 1" THICK FOR PIPE SIZE 1¼" AND GREATER WITH 1" MANVILLE MICRO-LOK AP-T PLUS FIBERGLASS INSULATION. FITTINGS AND VALVES SHALL BE INSULATED WITH MANVILLE ZESTON 2000 PVC INSULAT-ED FITTING COVERS. INSTALL ALL INSULATION AS PER MANUFACTURERS RECOMMENDATIONS. ALL INSULATION MATERIAL SHALL COMPLY WITH THE 2018 INTERNATIONAL BUILDING CODE REQUIREMENT OF A FLAME SPREAD RATING NOT TO EXCEED 25 AND A SMOKE DEVELOPED RATING NOT TO EXCEED 50. ALL PIPE INSULATION SHALL COMPLY WITH ASHRAE 90.1 2016 STANDARD.

J. DRAINAGE ACCESSORIES

1. GENERAL:

a. INSTALL THE WORK OF THIS SECTION IN ACCORDANCE WITH THE MANUFACTURER'S PRINTED INSTALLATION INSTRUCTIONS, UNLESS OTHERWISE SPECIFIED.

b. SECURE EXTERNAL COMPONENTS IN PLACE WITH VANDAL RESISTANT FASTENERS OR DEVICES WHICH CANNOT BE REMOVED WITHOUT SPECIAL TOOLS.

K. DEVICES:

a. CLEANOUT & CLEANOUT PLUG

• THREADED PIPE FITTING OR CAST IRON FERRULE WITH GAS TIGHT CLEANOUT PLUG

• PLUG SHOULD BE CAST BRASS OR BRONZE, WITH THREADED END, AND RAISED OR COUNTERSUNK HEAD.

• LUBRICATE THREADS OF CLEANOUT PLUG WITH ANTI-SEIZE LUBRICANT BEFORE FINAL INSTALLATION.

b. CLEANOUT WALL PLATE

• IT SHOULD BE ROUND, STAINLESS STEEL OR POLISHED CHROME PLATED BRONZE COVER PLATE WITH STAINLESS STEEL VANDAL RESISTANT FASTENER TO SECURE TO CLEANOUT PLUG.

c. CLEANOUT DECK PLATE

• IT SHOULD BE STANDARD DUTY FLOOR CLEANOUT FITTING WITH COATED CAST IRON BODY; ROUND, POLISHED NICKEL BRONZE SCORIATED TOP SECURED TO CLEANOUT PLUG WITH STAINLESS STEEL VANDAL RESISTANT FASTENER; THREADED HEIGHT ADJUSTMENT, CAST IRON HEAD, GAS TIGHT CLEANOUT PLUG, AND CONNECTION TO MATCH PIPING OPTION SELECTED.

• GRILLE FREE AREA SHOULD BE AT LEAST EQUAL TO CROSS-SECTION AREA OF PIPE TO WHICH CONNECTION MADE AND MADE OF POLISHED NICKEL BRONZE, WITH REMOVABLE GRATE, EITHER PERFORATED OR BAR TYPE. GRATE ATTACHED TO GRILLE BODY WITH VANDAL RESISTANT FASTENER.

L. INDIRECT WASTE FLOOR SINK

a. IT SHOULD BE COMBINATION OF FUNNEL DRAIN AND P TRAP WITH POLISHED CHROME PLATED CAST BRASS CONSTRUCTION WITH 4" TOP DIA., 4" DEEP WITH THREADED OUTLET.

M. INSTALL PIPING TO CONSERVE BUILDING SPACE. DO NOT INTERFERE WITH USE OF BUILDING SPACE AND THE WORK OF OTHER TRADES. ALL PIPING RUN IN CEILING SHALL BE INSTALLED TIGHT TO THE STRUCTURE ABOVE.

N. INSTALL PIPING TO ALLOW FOR EXPANSION AND CONTRACTION WITHOUT STRESSING PIPE, JOINTS OR CONNECTED EQUIPMENT. PROVIDE PIPE ANCHORS, GUIDES AND EXPANSION JOINTS OR LOOPS IN ALL HOT WATER AND HOT WATER CIRCULATING MAIN SUPPLY PIPING AND SEGMENTS OF SUCH PIPE THAT EXCEED 30'-0" IN LENGTH.

O. IN ALL AREAS WITH FINISHED SURFACES, SYSTEM PIPING AND COMPONENTS SHALL BE CONCEALED ABOVE OR WITHIN FINISHED SURFACES.

P. REDUCTIONS IN PIPE SIZES SHALL BE MADE WITH ONE-PIECE REDUCING FITTINGS. BUSHINGS ARE NOT ACCEPTABLE. USE FLANGED FITTINGS AT THE BASE OF RISERS.

Q. VENT PENETRATIONS THROUGH THE ROOF SHALL BE FLASHED.

R. IF WATER PRESSURE EXCEEDS 80 PSI, A WATER PRESSURE REDUCING VALVE SHALL BE INSTALLED IN WATER PIPING AT CONNECTION TO MAIN.

S. PROVIDE DIELECTRIC FITTINGS BETWEEN DISSIMILAR METALS.

T. PIPE BACKFLOW PREVENTER DRAINS TO FLOOR DRAIN OR OTHER APPROVED INDIRECT WASTE SOURCE.

U. PROVIDE ACCESS DOORS/PANELS FOR SERVICE AND ACCESS TO ALL VALVES AND OTHER SYSTEM COMPONENTS ENCLOSED IN WALLS AND CEILINGS. ACCESS DOORS SHALL BE FURNISHED BY THIS CONTRACTOR, INSTALLED BY THE GENERAL CONTRACTOR.

V. ALL FIXTURES REQUIRING VACUUM BREAKERS SHALL BE EQUIPPED WITH INTEGRAL VACUUM BREAKERS.

W. PIPE BACKFLOW PREVENTER DRAINS TO FLOOR DRAIN OR OTHER APPROVED INDIRECT WASTE SOURCE.

X. PROVIDE ACCESS DOORS/PANELS FOR SERVICE AND ACCESS TO ALL VALVES AND OTHER SYSTEM COMPONENTS ENCLOSED IN WALLS AND CEILINGS. ACCESS DOORS SHALL BE FURNISHED BY THIS CONTRACTOR, INSTALLED BY THE GENERAL CONTRACTOR.

Y. ALL FIXTURES REQUIRING VACUUM BREAKERS SHALL BE EQUIPPED WITH INTEGRAL VACUUM BREAKERS.

Z. ANY PENETRATIONS THROUGH FIRE RATED PARTITIONS, FLOORS, OR CEILINGS SHALL BE STEEL SLEEVED AND SEALED WITH 3M BRAND UL RATED FIRE BARRIER CAULK OR APPROVED EQUAL.

AA. WHEN THE WATER PIPING SYSTEM IS COMPLETE, THOROUGHLY FLUSH ALL DIRT, SEDIMENT, SOLDER, ETC., OUT OF THE SYSTEM, REMOVING ALL STRAINERS, VALVE STEM SEATS, ETC., REQUIRED TO ACCOMPLISH THE FLUSHING.

AB. AT ALL INDIRECT WASTE DRAINS, MAINTAIN AIR GAP AS REQUIRED BY CODE.

AC. INSTALL SLEEVES FOR ALL PIPES WHICH PASS THROUGH WALLS, FLOORS, AND CEILINGS WHERE PIPES ARE TO BE INSULATED, THE SLEEVE SHALL BE LARGE ENOUGH TO ACCOMMODATE INSULATION. SLEEVES SHALL BE FLUSH WITH FINISHED SURFACES AT BOTH ENDS. ON FINISHED SURFACES IN EXPOSED AREAS PROVIDE ESCUTCHEONS COMPATIBLE WITH FINISH.

AD. PROVIDE WATER HAMMER ARRESTERS ON SUPPLY PIPING TO ALL FLUSHOMETER VALVES AND QUICK-CLOSING VALVES.

AE. UNLESS OTHERWISE INDICATED, TRAPS SEALS AT ALL FLOOR DRAINS SHALL BE MAINTAINED BY AN APPROVED TRAP PRIMING DEVICE.

AF. MAINTAIN ALL REQUIRED AND RECOMMENDED CLEARANCES FOR ALL PLUMBING SYSTEM COMPONENTS AND EQUIPMENT.

AG. MAINTAIN MINIMUM 10'-0" CLEARANCE BETWEEN ALL PLUMBING V.T.R.S AND ALL OUTDOOR AIR INTAKES. OFFSET VENT STACKS AND STACK VENTS IF AND AS REQUIRED BELOW ROOF TO MAINTAIN SUCH CLEARANCE WHETHER OR NOT SUCH OFFSET IS INDICATED ON THE DRAWINGS. PROVIDE ALL REQUIRED SEISMIC SUPPORTS.

2. INSTALLATION

2.01 GENERAL

A. ALL WORK WHICH REQUIRES DISRUPTION OF THE ROOFING SHALL BE DONE BY A CONTRACTOR CERTIFIED BY THE ROOFING MANUFACTURER AS REQUIRED TO MAINTAIN ANY EXISTING ROOF WARRANTIES.

B. EXTERIOR INSTALLATIONS TO BE WEATHER PROOF IN ALL RESPECTS.

C. EXTERIOR MATERIALS AND EQUIPMENT SHALL BE PAINTED TO PREVENT CORROSION, COLOR PER ARCHITECT.

D. COORDINATE THE PLUMBING WORK WITH ALL OTHER AFFECTED WORK AND THE CONSTRUCTION SCHEDULE.

E. REAM PIPE AND TUBE ENDS. REMOVE BURRS. BEVEL PLAIN AND FERROUS END PIPE.

F. REMOVE SCALE AND FOREIGN MATERIAL, FROM INSIDE AND OUTSIDE, BEFORE ASSEMBLY.

G. PREPARE PIPING CONNECTIONS TO EQUIPMENT WITH FLANGES AND UNIONS.

H. COORDINATION WITH THE WORK OF OTHER TRADES IS REQUIRED. PROVIDE OFFSETS IN PIPING SYSTEMS OR MINOR DEVIATIONS TO THE INDICATED PIPE ROUTING IN ORDER TO COORDINATE THE PLUMBING WORK WITH THE WORK OF ALL OTHER TRADES AND THE GENERAL BUILDING CONDITIONS.

I. NO DOMESTIC WATER PIPING SHALL BE INSTALLED IN UNHEATED SPACES.

J. PRIOR TO DISCONNECTING AND CONNECTING NEW WORK TO EXISTING SYSTEMS, THE PLUMBING CONTRACTOR SHALL NOTIFY THE PROPERTY MANAGER AND OFFER A PROPOSED SCHEDULE OF WORK. ESB WILL AUTHORIZE CONNECTIONS AND COORDINATE NECESSARY SHUT DOWNS AND DRAIN DOWNS AS REQUIRED. SHUT DOWNS AND DRAIN DOWNS MAY BE PERFORMED BY THE PLUMBING CONTRACTOR ONLY AFTER RECEIVING ESB AUTHORIZATION, AND SHOULD BE PERFORMED UNDER SUPERVISION OF ESB PERSONNEL. THREE (3) DAYS ADVANCE NOTICE TO THE PROPERTY MANAGER IS REQUIRED.

K. THE PLUMBING CONTRACTOR IS ADVISED THAT DUE TO THE NATURE OF THE OPERATIONS AND TENANT REQUIREMENTS, CONNECTIONS TO EXISTING SYSTEMS MAY HAVE TO BE MADE AFTER REGULAR WORKING HOURS. THE PROPERTY MANAGER WILL ADVISE THE PLUMBING CONTRACTOR OF THE TIME CONSTRAINTS UPON RECEIPT AND APPROVAL OF THE PLUMBING CONTRACTOR'S REQUEST FOR SHUT DOWN AND CONNECTION TO EXISTING SYSTEMS.

L. WHEN CONNECTING TO EXISTING STACKS AND RISERS, PROVISION IS TO BE MADE FOR FUTURE CONNECTIONS BY PROVIDING CAPPED AND VALVED OUTLETS ON DOMESTIC WATER RISERS AND PLUGGED OUTLETS ON THE SANITARY AND VENT STACKS.

2.02 ABOVE GRADE

A. INSTALL PLUMBING PIPING IN ACCORDANCE WITH RECOGNIZED INDUSTRY PRACTICES TO ENSURE THAT PIPING COMPLIES WITH REQUIREMENTS AND SERVES INTENDED PURPOSES.

B. ROUTE PIPING IN AN ORDERLY MANNER, PLUMB AND PARALLEL TO BUILDING STRUCTURE. MAINTAIN GRADIENT. SLOPE PIPING AND ARRANGE SYSTEMS TO DRAIN. IN DOMESTIC WATER SYSTEMS, PROVIDE DRAIN VALVES AT MAIN SHUT-OFF VALVES AND ALL LOW POINTS IN PIPING.

C. USE EXISTING CONNECTIONS AT MAINS WHERE AVAILABLE FOR NEW BRANCH PIPING. LOCATE ALL RISERS AND PIPING BEFORE CONSTRUCTION COMMENCES AND TAKE CARE NOT TO DAMAGE SAME. ANY DAMAGE OCCURRING TO THE EXISTING PIPING WILL BE THE SOLE RESPONSIBILITY OF THE CONTRACTOR.

2.03 INSULATION (PIPE AND FITTINGS)

A.PIPING

COVER ALL HOT WATER PIPE WITH 1" THICK FOR PIPE SIZE UP TO 1¼" AND 1½" THICK FOR PIPE SIZE 1½" AND GREATER WITH MANVILLE MICRO-LOK AP-T PLUS FIBERGLASS INSULATION. COVER ALL COLD WATER PIPE WITH ½" THICK FOR PIPE SIZE UP TO 1¼" AND 1" THICK FOR PIPE SIZE 1¼" AND GREATER WITH 1" MANVILLE MICRO-LOK AP-T PLUS FIBERGLASS INSULATION. FITTINGS AND VALVES SHALL BE INSULATED. INSTALL ALL INSULATION AS PER MANUFACTURERS RECOMMENDATIONS. ALL INSULATION MATERIAL SHALL COMPLY WITH THE 2018 INTERNATIONAL BUILDING CODE REQUIREMENT OF A FLAME SPREAD RATING NOT TO EXCEED 25 AND A SMOKE DEVELOPED RATING NOT TO EXCEED 50. ALL PIPE INSULATION SHALL COMPLY WITH ASHRAE 90.1 2016 STANDARD.

3. TESTING

A. AT THE COMPLETION OF THE PLUMBING WORK, COMPLETELY TEST THE ENTIRE INSTALLATION OF ALL SYSTEMS FOR PROPER OPERATION AND COMPLIANCE WITH APPLICABLE CODES AND LOCAL REQUIREMENTS. CORRECT ALL DEFICIENCIES FOUND.

B. TESTING OF THE INSTALLED SYSTEMS SHALL BE MADE BY THE CONTRACTOR IN THE PRESENCE OF A REPRESENTATIVE OF THE OWNER.

C. THE CONTRACTOR SHALL NOT COVER UP OR PERMANENTLY CONCEAL PIPING, DEVICES OR ANY PORTION OF NEWLY CONSTRUCTED PLUMBING SYSTEM(S) UNTIL SUCH SYSTEM OR PORTION OF THE SYSTEM, HAS BEEN TESTED IN THE PRESENCE OF A REPRESENTATIVE OF THE OWNER AND INSPECTED BY THE LOCAL INSPECTOR AND APPROVED IN WRITING, EXCEPT PIPING PASSING THROUGH FLOORS, WALLS, PARTITIONS, OR BEAMS, FOR DISTANCES EQUAL TO THE THICKNESS OF SUCH FLOOR, WALL, PARTITION OR BEAM.

D. THIS CONTRACTOR SHALL NOTIFY THE VARIOUS DEPARTMENTS, BUREAUS AND INDIVIDUALS AT LEAST TWO WEEKS IN ADVANCE OF THE TIME THAT THE TESTS ARE TO BE CONDUCTED.

E. ALL DEFECTIVE PARTS SHALL BE REPLACED OR CORRECTED BY THIS CONTRACTOR AND AN EXTRA TEST OR TESTS SHALL BE MADE UNTIL THE OPERATION IS SATISFACTORY. ALL ARRANGEMENTS AND EXPENSES NECESSARY TO CONDUCT ALL TESTS REQUIRED BY THESE SPECIFICATIONS AND THE VARIOUS AGENCIES HAVING JURISDICTION OVER THE WORK INSTALLED UNDER THIS CONTRACT SHALL BE MADE BY THIS CONTRACTOR. NO EXTRA COMPENSATION WILL BE ALLOWED FOR THESE TESTS, THE COST THEREOF BEING INCLUDED IN THE LUMP SUM BID FOR THIS CONTRACT.

F. WHERE ANY EVIDENCE OF STOPPAGE IS FOUND IN PIPING OR EQUIPMENT, THIS CONTRACTOR SHALL DISCONNECT, CLEAN, REPAIR AND RECONNECT ALL OBSTRUCTED PIPING OR EQUIPMENT AND SHALL ALSO PAY FOR ALL NECESSARY CUTTING AND REPAIRS TO ADJOINING WORK.

G. ALL PIPING AND EQUIPMENT SHALL BE THOROUGHLY CLEANED INSIDE AND OUT, OF DIRT, CUTTINGS, OILS AND OTHER FOREIGN SUBSTANCES AND SHALL BE LEFT CLEAN.

H. ALL REQUIRED TESTS SHALL BE WITNESSED BY LOCAL AUTHORITIES AND THE OWNER'S REPRESENTATIVE.

I. ALL EQUIPMENT WILL BE FACTORY TESTED.

J. CONTRACTOR SHALL IDENTIFY TO THE OWNER'S REPRESENTATIVE ANY LEAKS OR DAMAGE THAT OCCURS AS A RESULT OF SYSTEM TESTING. CONTRACTOR SHALL TAKE NECESSARY PRECAUTIONS TO LIMIT ANY POTENTIAL DAMAGE. CORRECTIVE ACTION REQUIRED AS A RESULT OF TESTING SHALL BE PERFORMED IMMEDIATELY AND AT THE CONTRACTOR'S EXPENSE.

K. REPORT IN WRITING TO AUTHORITIES HAVING JURISDICTION, THE ARCHITECT AND THE OWNER THE RESULTS OF ALL TESTING.

L. TESTING REQUIREMENTS

a. TEST ALL DOMESTIC WATER PIPING HYDROSTATICALLY TO 125 PSIG.

b. HYDROSTATIC TEST PRESSURES SHALL REMAIN CONSTANT WITH NO VARIATION FOR 120 MINUTES.

c. TESTS SHALL BE WITNESSED BY THE BUILDING ENGINEER.

d. THE PLUMBING CONTRACTOR WILL BE HELD RESPONSIBLE FOR ALL DAMAGE DUE TO TEST FAILURES AND LEAKAGE IN THE TEST AREA AND ADJACENT TENANT OR ESB SPACES.

M. REFILL ENTIRE POTABLE HOT AND COLD WATER SUPPLY SYSTEM WITH CHLORINE SOLUTION (HTH OLIN CHEMICAL CORP.) AT A STRENGTH TO MEET STANDARDS OF THE DEPARTMENT OF HEALTH, AND FOR A PERIOD OF RETENTION AS STIPULATED.

N. THOROUGHLY FLUSH PIPING SYSTEM WITH FRESH WATER IMMEDIATELY PRIOR TO FINAL ACCEPTANCE.

O. INSPECTION & TESTING SHALL BE AS PER 2018 NATIONAL STANDARD PLUMBING CODE (2018 NSPC).

4. WARRANTY

A. EQUIPMENT, MATERIALS AND WORKMANSHIP FURNISHED UNDER THIS CONTRACT SHALL BE GUARANTEED BY THE CONTRACTOR FOR A PERIOD OF ONE YEAR FROM THE DATE OF FINAL ACCEPTANCE OF THE WORK BY THE OWNER. THE CONTRACTOR SHALL KEEP THE WORK IN GOOD REPAIR FOR ONE YEAR AFTER THE DATE OF FINAL APPROVAL. THE CONTRACTOR SHALL, AT HIS OWN EXPENSE, PROMPTLY CORRECT AND REPAIR ANY AND ALL BREAKS, FAILURES OR WEAR DUE TO FAULTY MATERIALS, WORKMANSHIP OR EQUIPMENT. ALL SETTLEMENTS OF SURFACES THAT MAY OCCUR WITHIN THAT PERIOD SHALL ALSO BE PROMPTLY REPAIRED.




MARK	FIXTURE	CONN.			MANUFAC. & MODEL	DESCRIPTION
		W	CW	HW		
WC	WATER CLOSET	4"	3/4"	—	AM. STD. 3043.102	VITREOUS CHINA, 16—3/4" HIGH ELONGATED BOWL, 1.6 GPF, SIPHON JET; W/ZURN Z—6000—WS1—YBYC FLUSH TANK MOUNTED 11" ABOVE WATER CLOSET; CHURCH 9500CT OPEN FRONT SEAT, WHITE SOLID PLASTIC.
LAV	LAVATORY	2"	1/2"	1/2"	COMMERCIAL INTERIORS MANUFACTURING MODEL R—2030	WITH AM. STANDARD 6056.205—V10 — INNSBROOK AC VERSION PROXIMITY FAUCET, WITH V10 1.0 GPM VANDAL RESISTANT AERATOR, AND 605XTMV MIXING VALVE, POLISH CHROME FINISH
FD	FLOOR DRAIN	3"	—	—	ZURN Z—1732—33	ALL TYPE 304 STAINLESS STEEL HEAVY DUTY ADJUSTABLE FLOOR DRAIN WITH INTEGRAL ANCHOR FLANGE.
FS	FLOOR SINK	3"	—	—	ZURN Z—1900—2—33 12"x12"x6" A.R.E	3" FLOOR SINK, 12"x12" A.R.E SANI—FLOR RECEPTOR, ANTI SPLASH STRAINER, ACID RESIST. PORCELAIN ENAMEL INTERIOR AND SQ. TOP
WH	WATER HEATER	—	1"	1"	STATESMAN SSE—80	ELECTRIC STORAGE TANK HEATER, 15KW(3ø, 208V) SIMULTANEOUS OPERATION, 61 GPH @ 100°F RISE. DIMENSION 28" DIA X 52—1/4" H FLOOR MOUNTED .
GI	GREASE INTERCEPTOR	4"	—	—	SCHIER GB—75	INDOOR, BELOW GRADE INSTALLATION 75 GPM FLOW RATE, 861 LBS. GREASE CAPACITY. DIM 33"x47"x40"
RCP	RECIRCULATION PUMP	—	—	—	GRUNDFOS UPS 15—18	2 GPM FLOW RATE, 10 FT TOTAL HEAD, 0.115 HP MOTOR
ET	EXPANSION TANK	—	—	—	THERMXTROL ST—5	2 GALLON TANK VOLUME , DIM. DIA 8" X 13" H SHIPPING WEIGHT 5 LBS

NOTES:

1. ALL VITREOUS CHINA FIXTURES SHALL BE WHITE.	4. FIRST 10' OF GREASE WASTE PIPING FROM
2. INSULATE ALL WATER AND WASTE PIPING UNDER LAVATORIES WITH HAND-ON SHIELD MAXX: 2003W (WHITE) BY PLUMBEREX: (800) 475-8629.	5"FS-B INSTALLED NEAR FRYERS SHALL BE MADE OF CAST IRON.
3. PC SHALL VERIFY ALL KITCHEN EQUIPMENT AND INDIRECT DRAINS LOCATIONS WITH K1 SHEET.	

GREASE TRAP SIZING CALCULATION										
FIXTURE	QUANTITY	DIMENSIONS			VOLUME		PERCENTAGE USAGE(%)	ACTUAL USAGE (GALLONS)	FLOW RATE(GPM)	
		LENGTH(IN)	WIDTH(IN)	DEPTH(IN)	CUBIC INCHES	GALLONS			1 MIN.	2 MIN.
3 COMP. SINK	1	18	18	14	13608	58.9	0.75	44.2	44.2	22.1
MOP SINK	1	16	20	6	1920	8.3	0.75	6.2	6.2	3.1
1 COMP SINK	1	18	18	14	4536	19.6	0.75	14.7	14.7	7.4
HAND SINK	2	14	10	5.5	1540	6.7	0.75	5.0	5.0	2.5
FLOOR SINK	1	N/A	N/A	N/A	N/A	N/A	N/A	5.0	5.0	2.5
								TOTAL:	75.1	37.57
							PROPOSED GREASE TRAP:		GB-75	
GREASE INTERCEPTOR SIZED AS PER SECTION 6.2.10. OF 2018 NATIONAL STANDARD PLUMBING CODE. PROPOSED GREASE INTERCEPTOR MODEL: SCHIER GB-75										

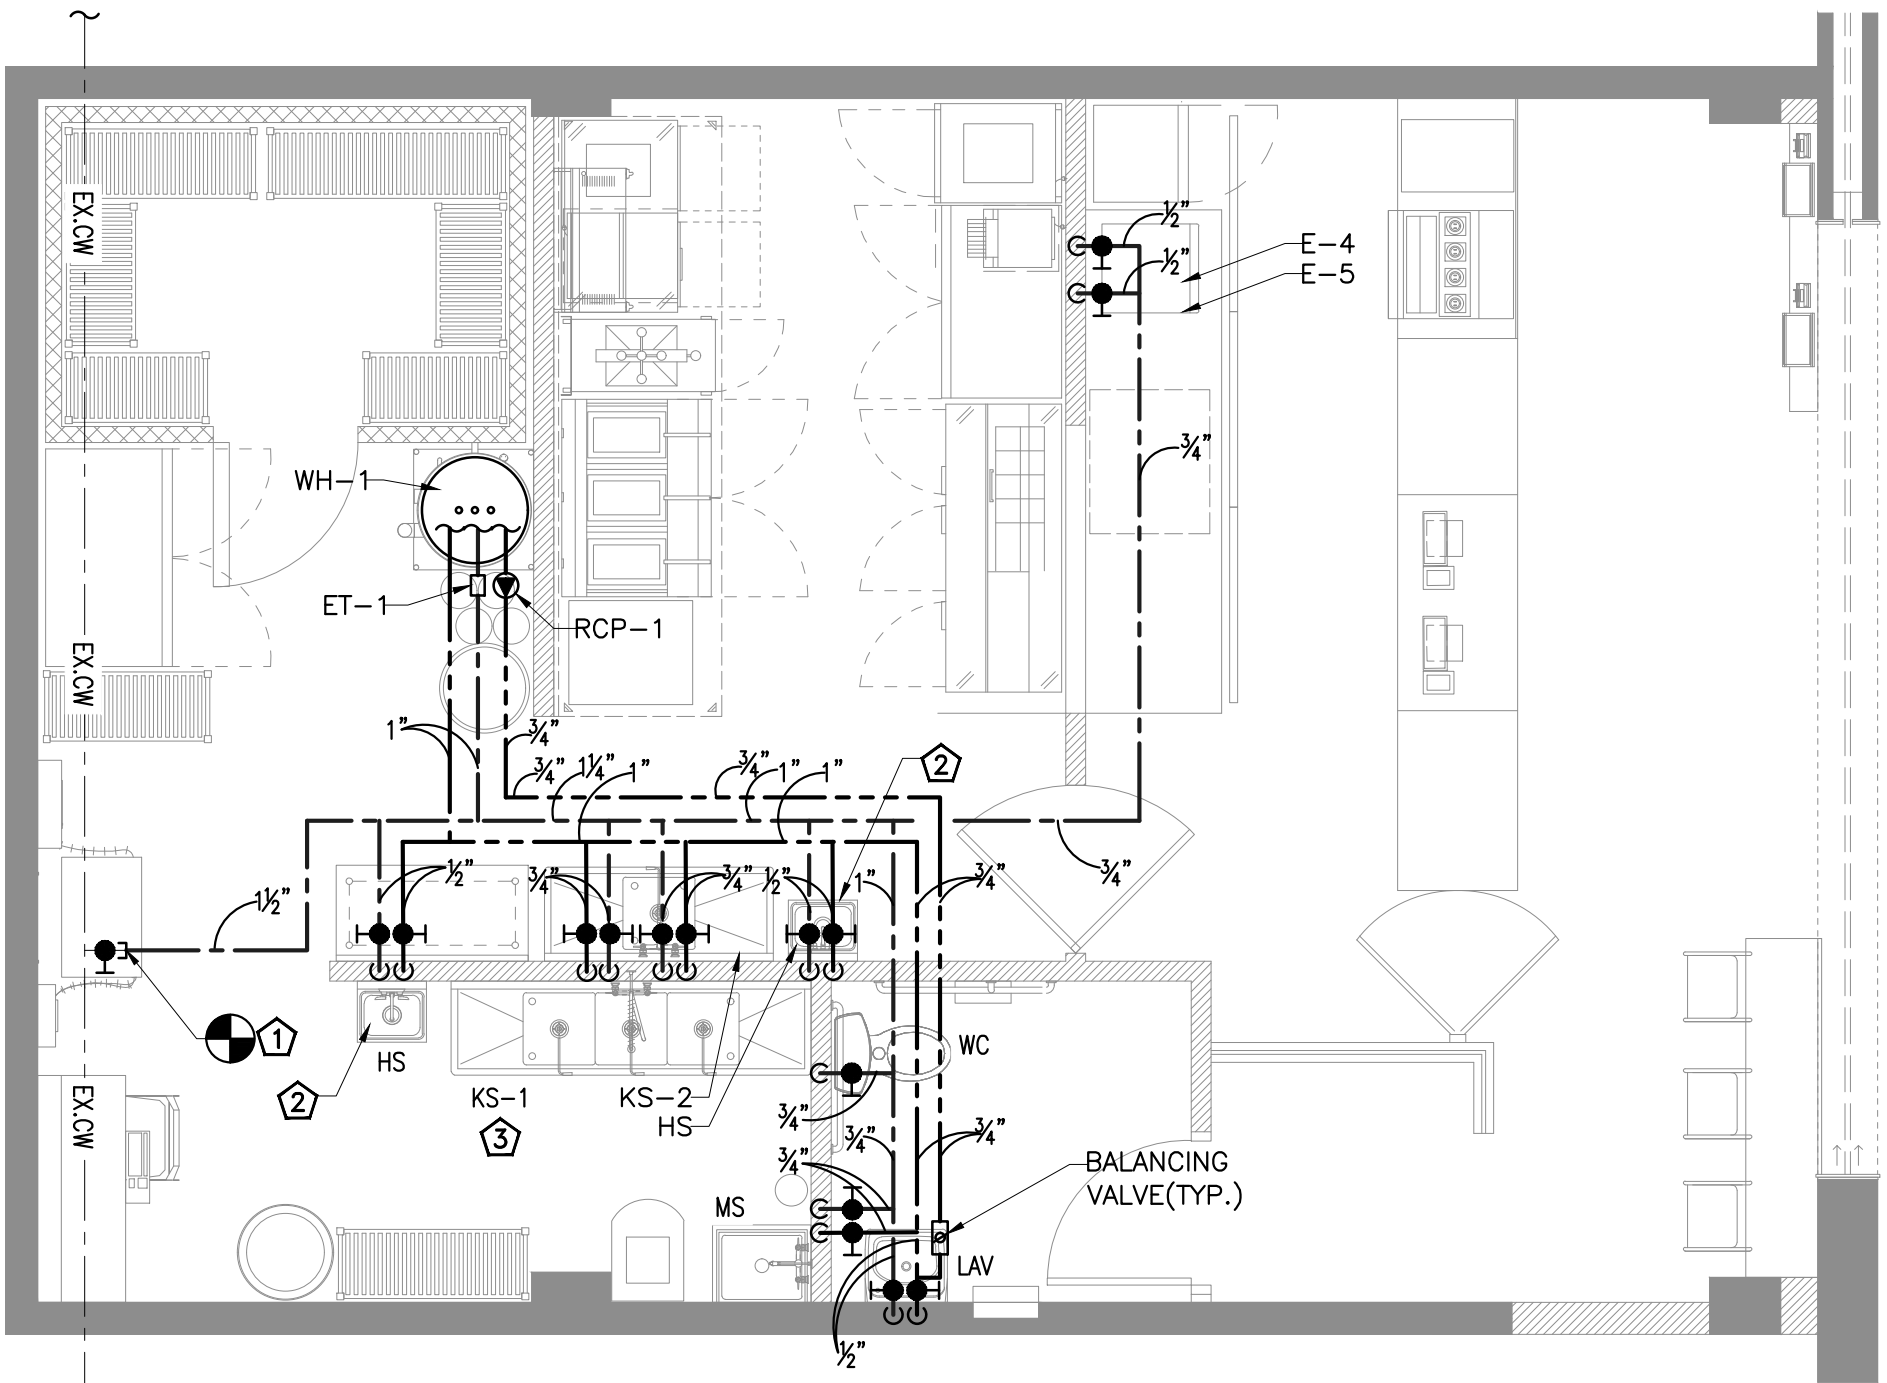


1 PLUMBING DOMESTIC WATER FLOOR PLAN
1/4"=1'-0"

PLUMBING KEYNOTES:

- CONNECT NEW 1-1/2" DOMESTIC WATER PIPE TO EXISTING WATER LINE INTO THE BUILDING. CONTRACTOR TO VERIFY WATER SUBMETER AND BACKFLOW PREVENTER REQUIREMENT WITH LANDLORD PRIOR TO BID. CONTRACTOR TO FIELD VERIFY EXACT SIZE AND LOCATION CONTRACTOR TO FIELD
- PROVIDE TEMPERATURE MIXING VALVE, SET AT 110°F, ON ALL HANDSINKS, LAVATORIES.
- CHEMICAL DISPENSING SYSTEM SHALL BE PROVIDED WITH VACUUM BREAKER AND INTEGRAL FAUCET CHECK VALVE.

KITCHEN EQUIPMENT SCHEDULE							
QTY	TAG	DESCRIPTION	WATER		WASTE		REMARKS
			COLD	HOT	DIRECT	INDIRECT	
1	MS	MOP SINK	3/4"	3/4"	3"		
1	KS-1	SINK, 3 COMPARTMENT	3/4"	3/4"	-		PROVIDE BACKFLOW PREVENTOR TO 3-COMP SINK.
2	HS	HAND SINK	1/2"	1/2"	1 1/2"		
1	KS-2	SINK, 1 COMPARTMENT	3/4"	3/4"	-		PROVIDE BACKFLOW PREVENTOR TO 1-COMP SINK.
1	E-4	ICE MACHINE	1/2"	-	-		
1	E-5	SODA DISPENSER	1/2"	-	-		








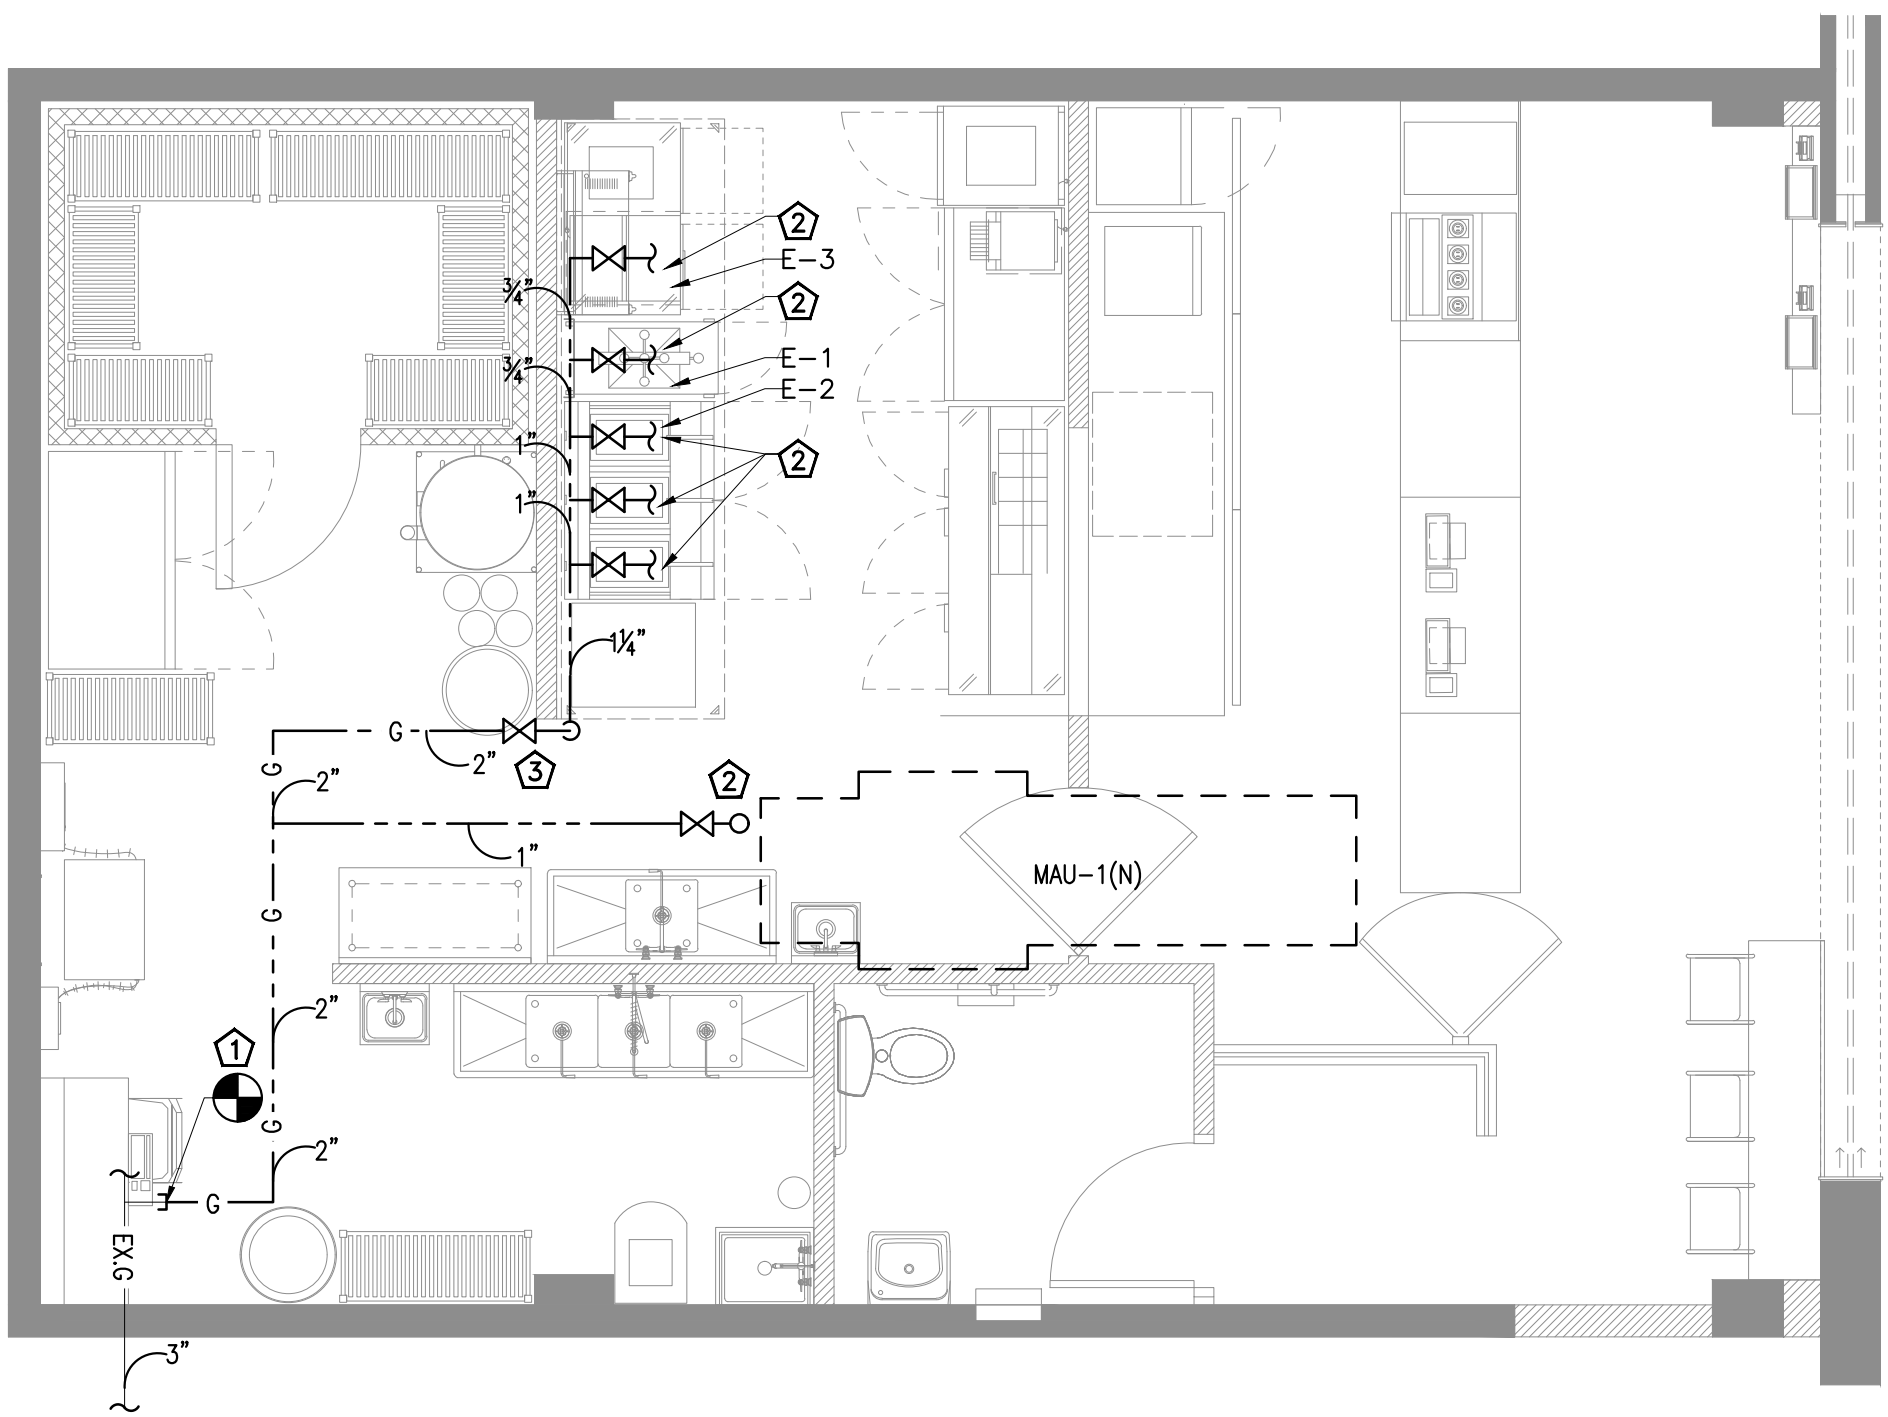



- PLUMBING KEYNOTES:**
- ① CONNECT NEW 2" GAS PIPING TO EXISTING GAS LINE. CONTRACTOR TO VERIFY LOCATION AND SIZE OF EXISTING GAS PIPING, UPGRADE THE SIZE IF REQUIRED.
 - ② CONTRACTOR TO FIELD VERIFY EXISTING AVAILABLE GAS PRESSURE AND MAKE SURE TO PROVIDE ADEQUATE INLET PRESSURE REQUIRED FOR E-1, E-2, E-3 AND MAU-1.
 - ③ CONTRACTOR TO PROVIDE EMERGENCY GAS SOLENOID SHUT OFF VALVE. COORDINATE WITH KITCHEN HOOD MANUFACTURER, ANSUL SYSTEM CONTROLS AND ELECTRICAL CONTRACTOR FOR LOCATION.

1 PLUMBING GAS PLAN
1/4"=1'-0"


GAS PIPE SIZING PER TABLE 402.4(2),
INTERNATIONAL FUEL GAS CODE, 2018.
TOTAL EQUIVALENT LENGTH OF PIPE = 70 FEET

KITCHEN EQUIPMENT SCHEDULE (GAS)				
QTY	TAG	DESCRIPTION	GAS	REMARKS
			MBTUH	
1	E-1	PRESSURE FRYER, GAS	80	
1	E-2	GAS FRYER, BATTERY	255	
1	E-3	CHEESEMELTER, GAS	43	
1	MAU-1(N)	MAKE UP AIR UNIT	194	
		TOTAL	572	

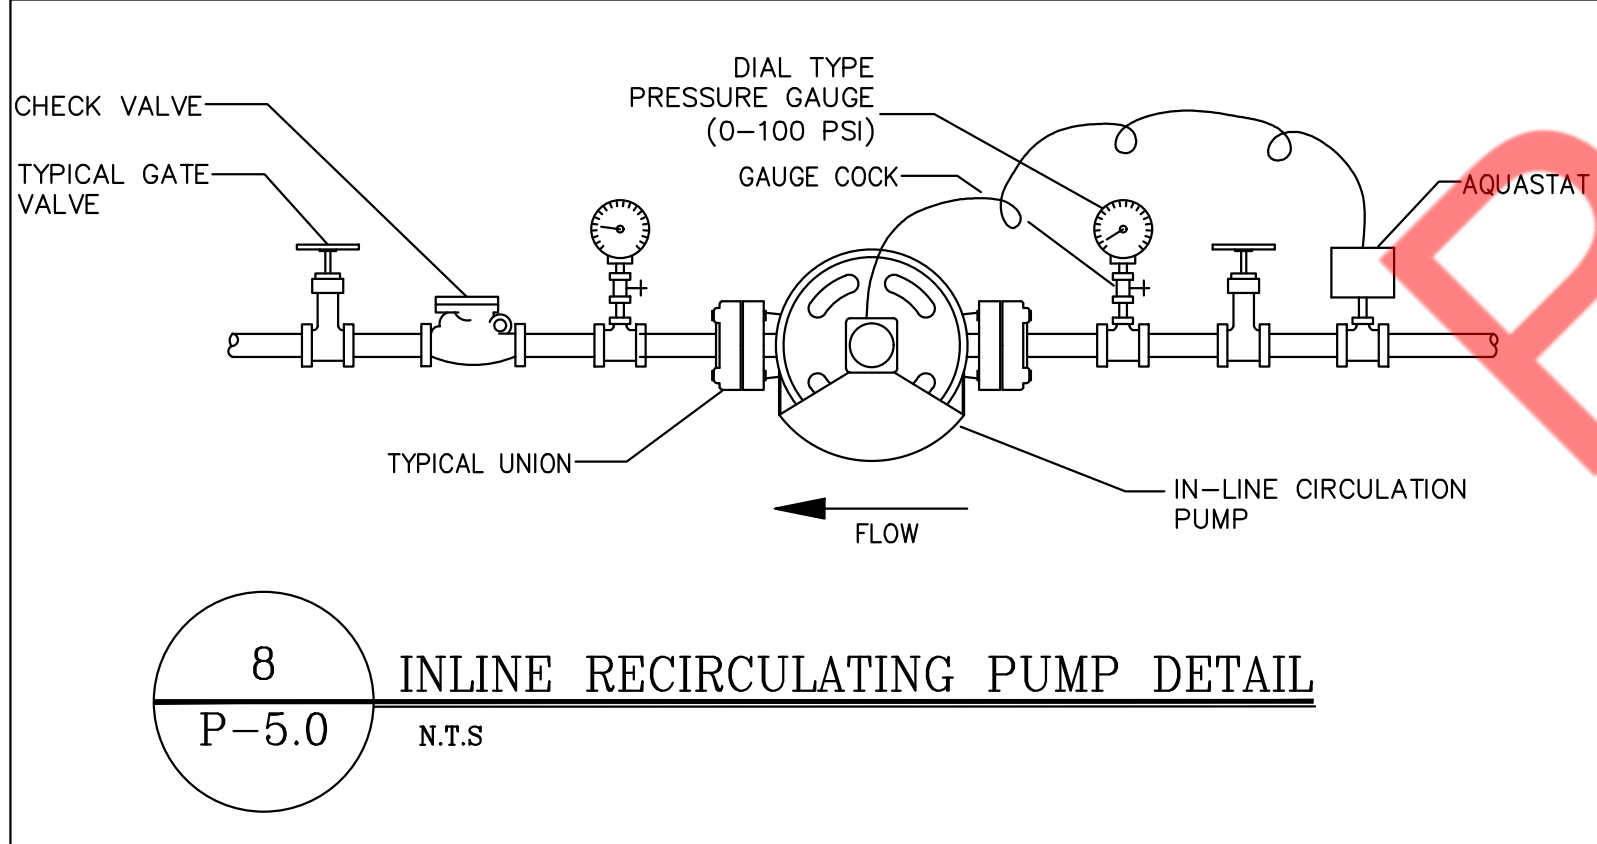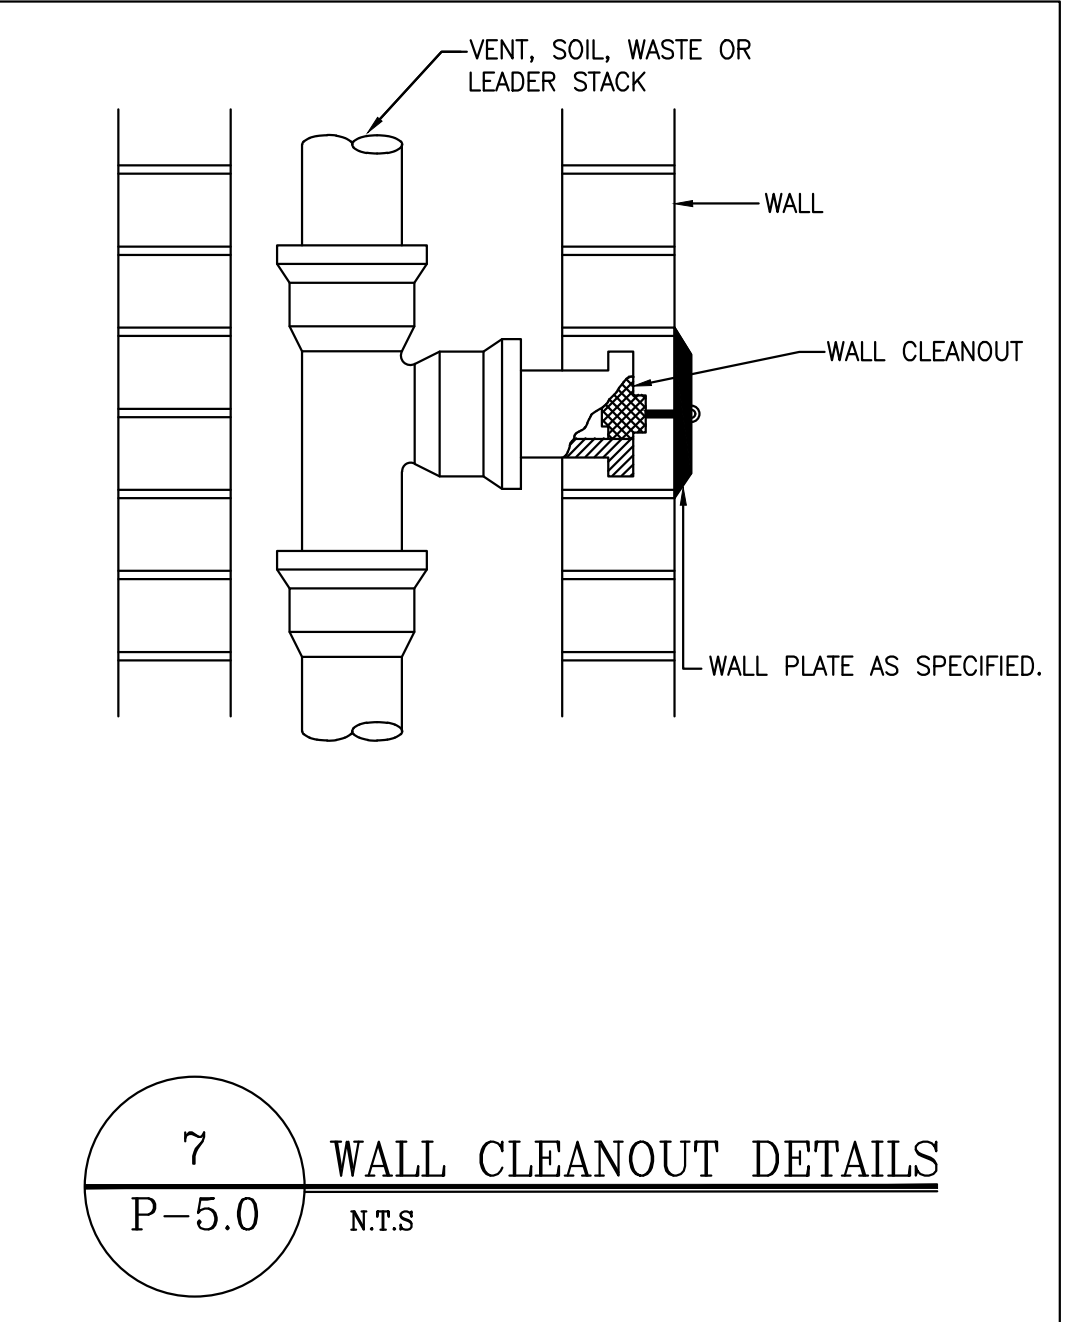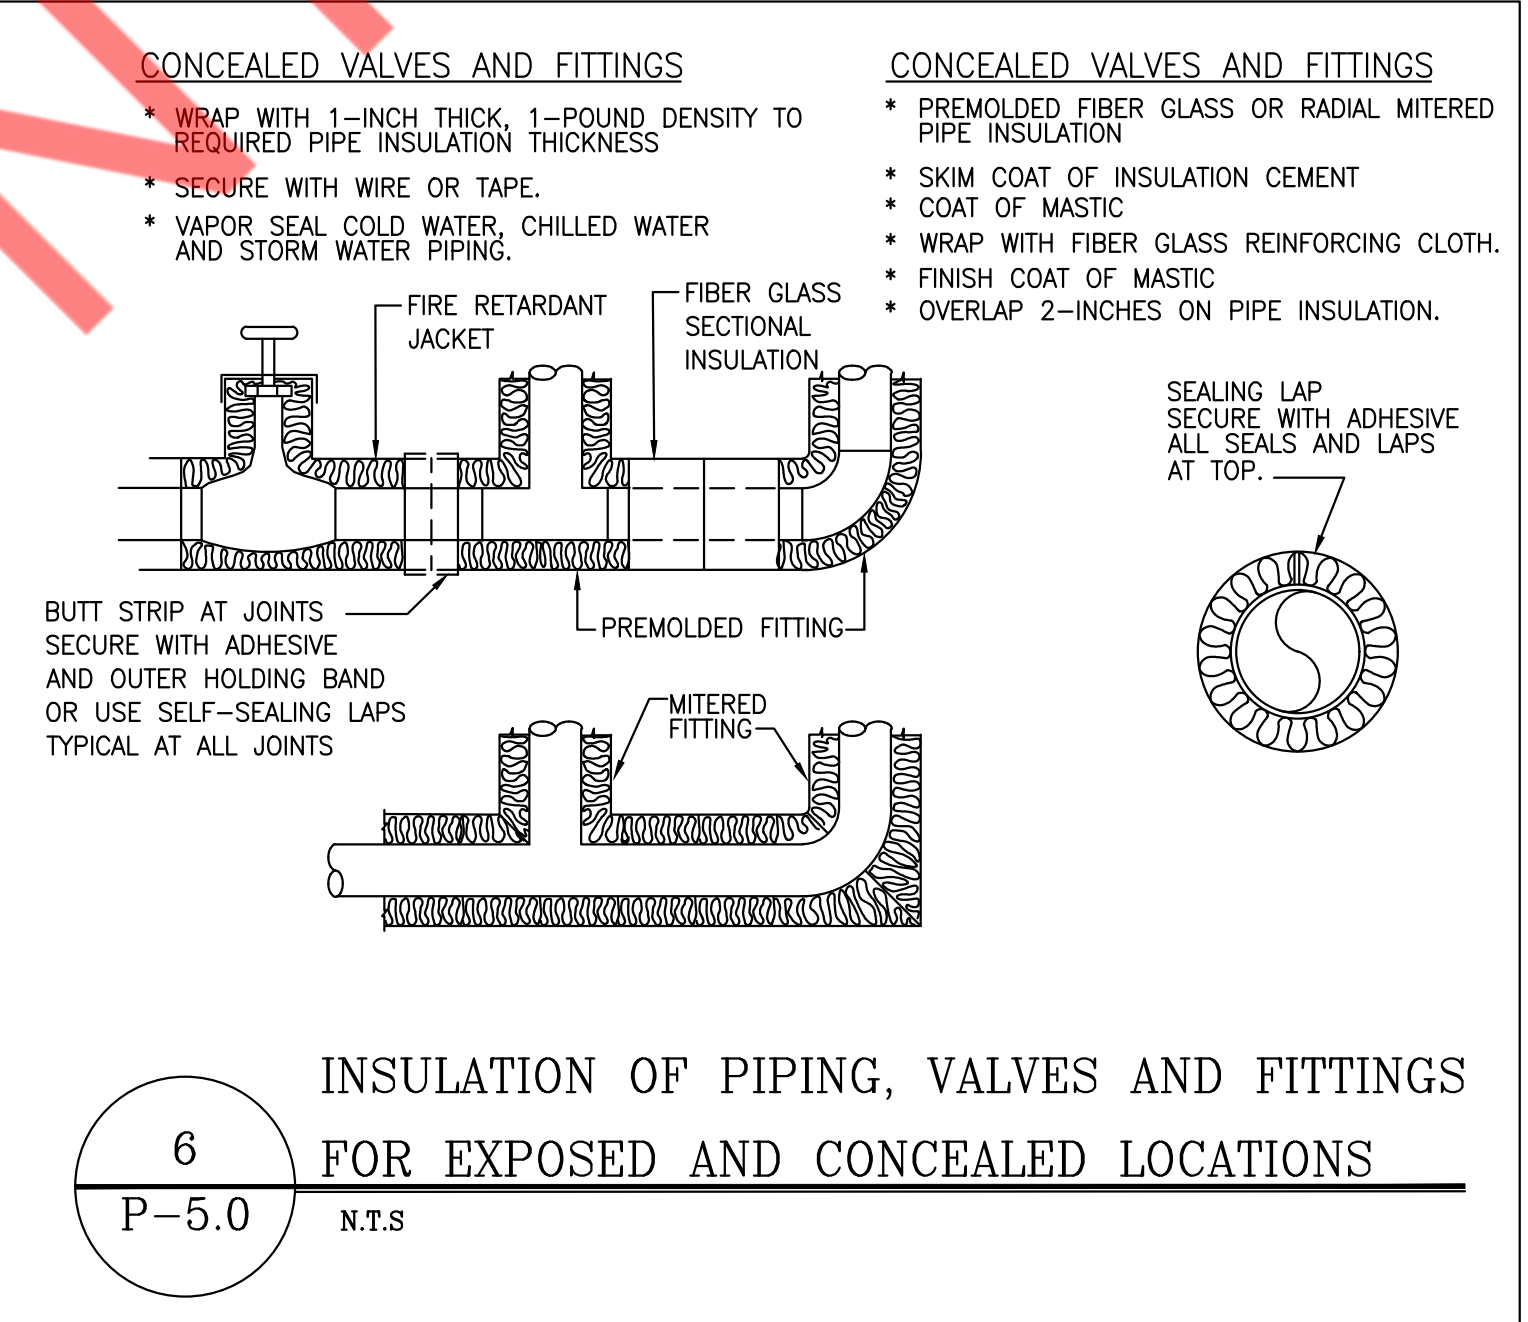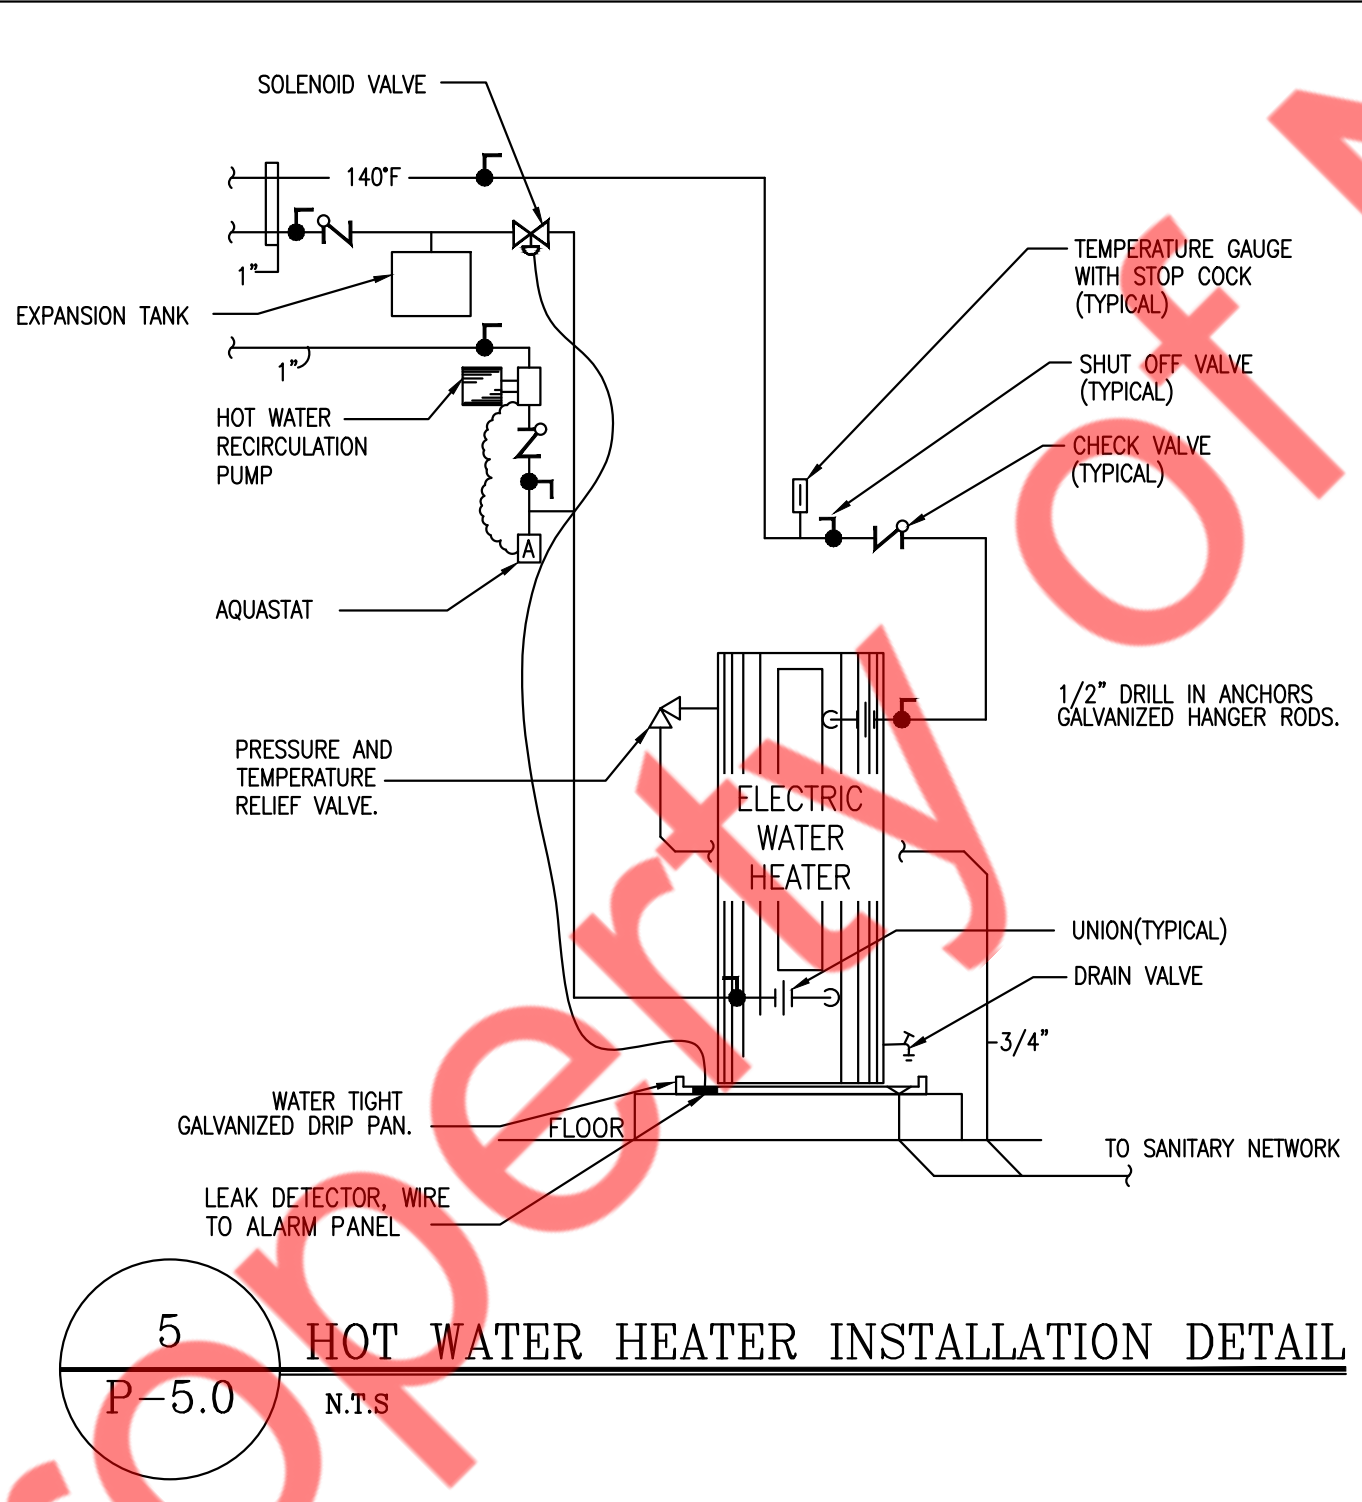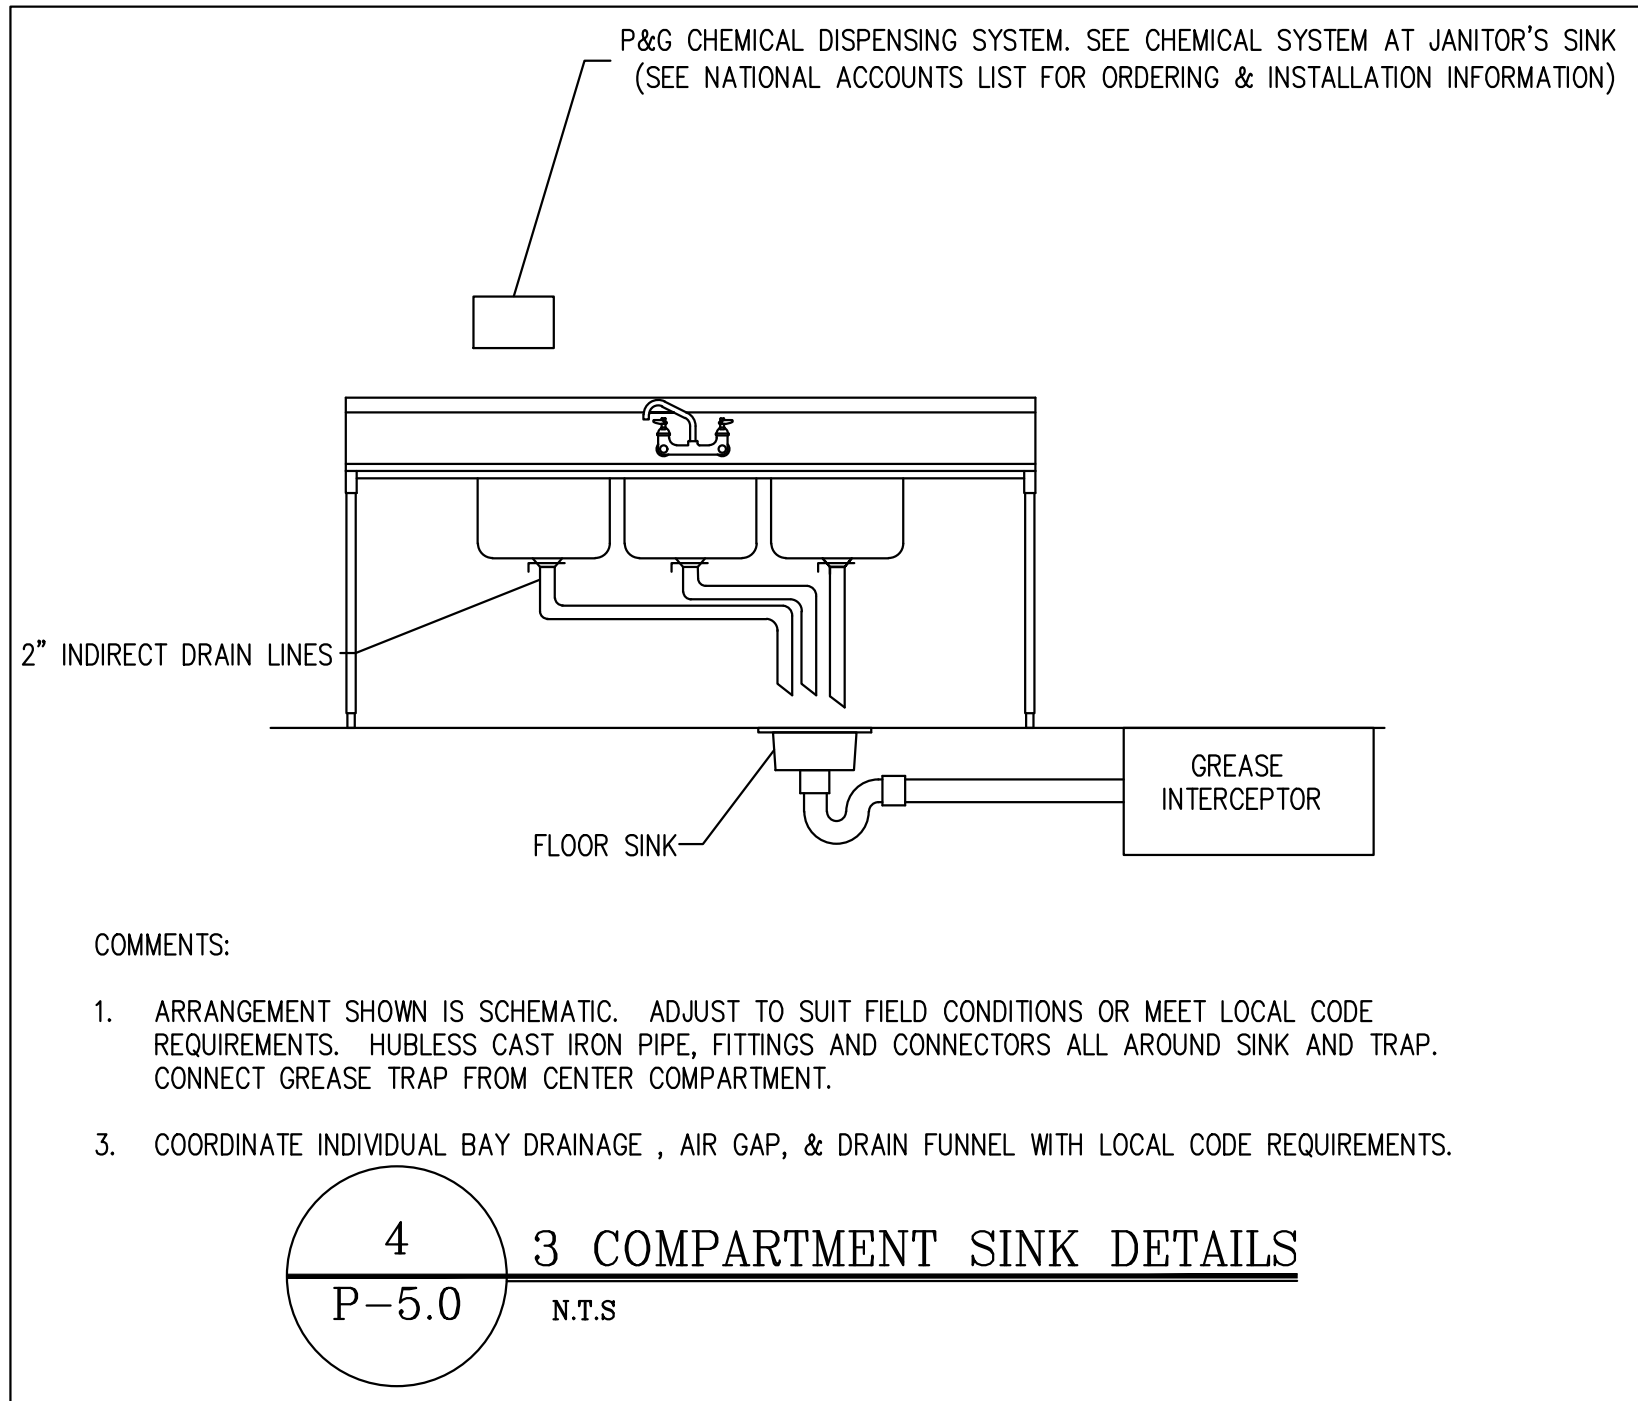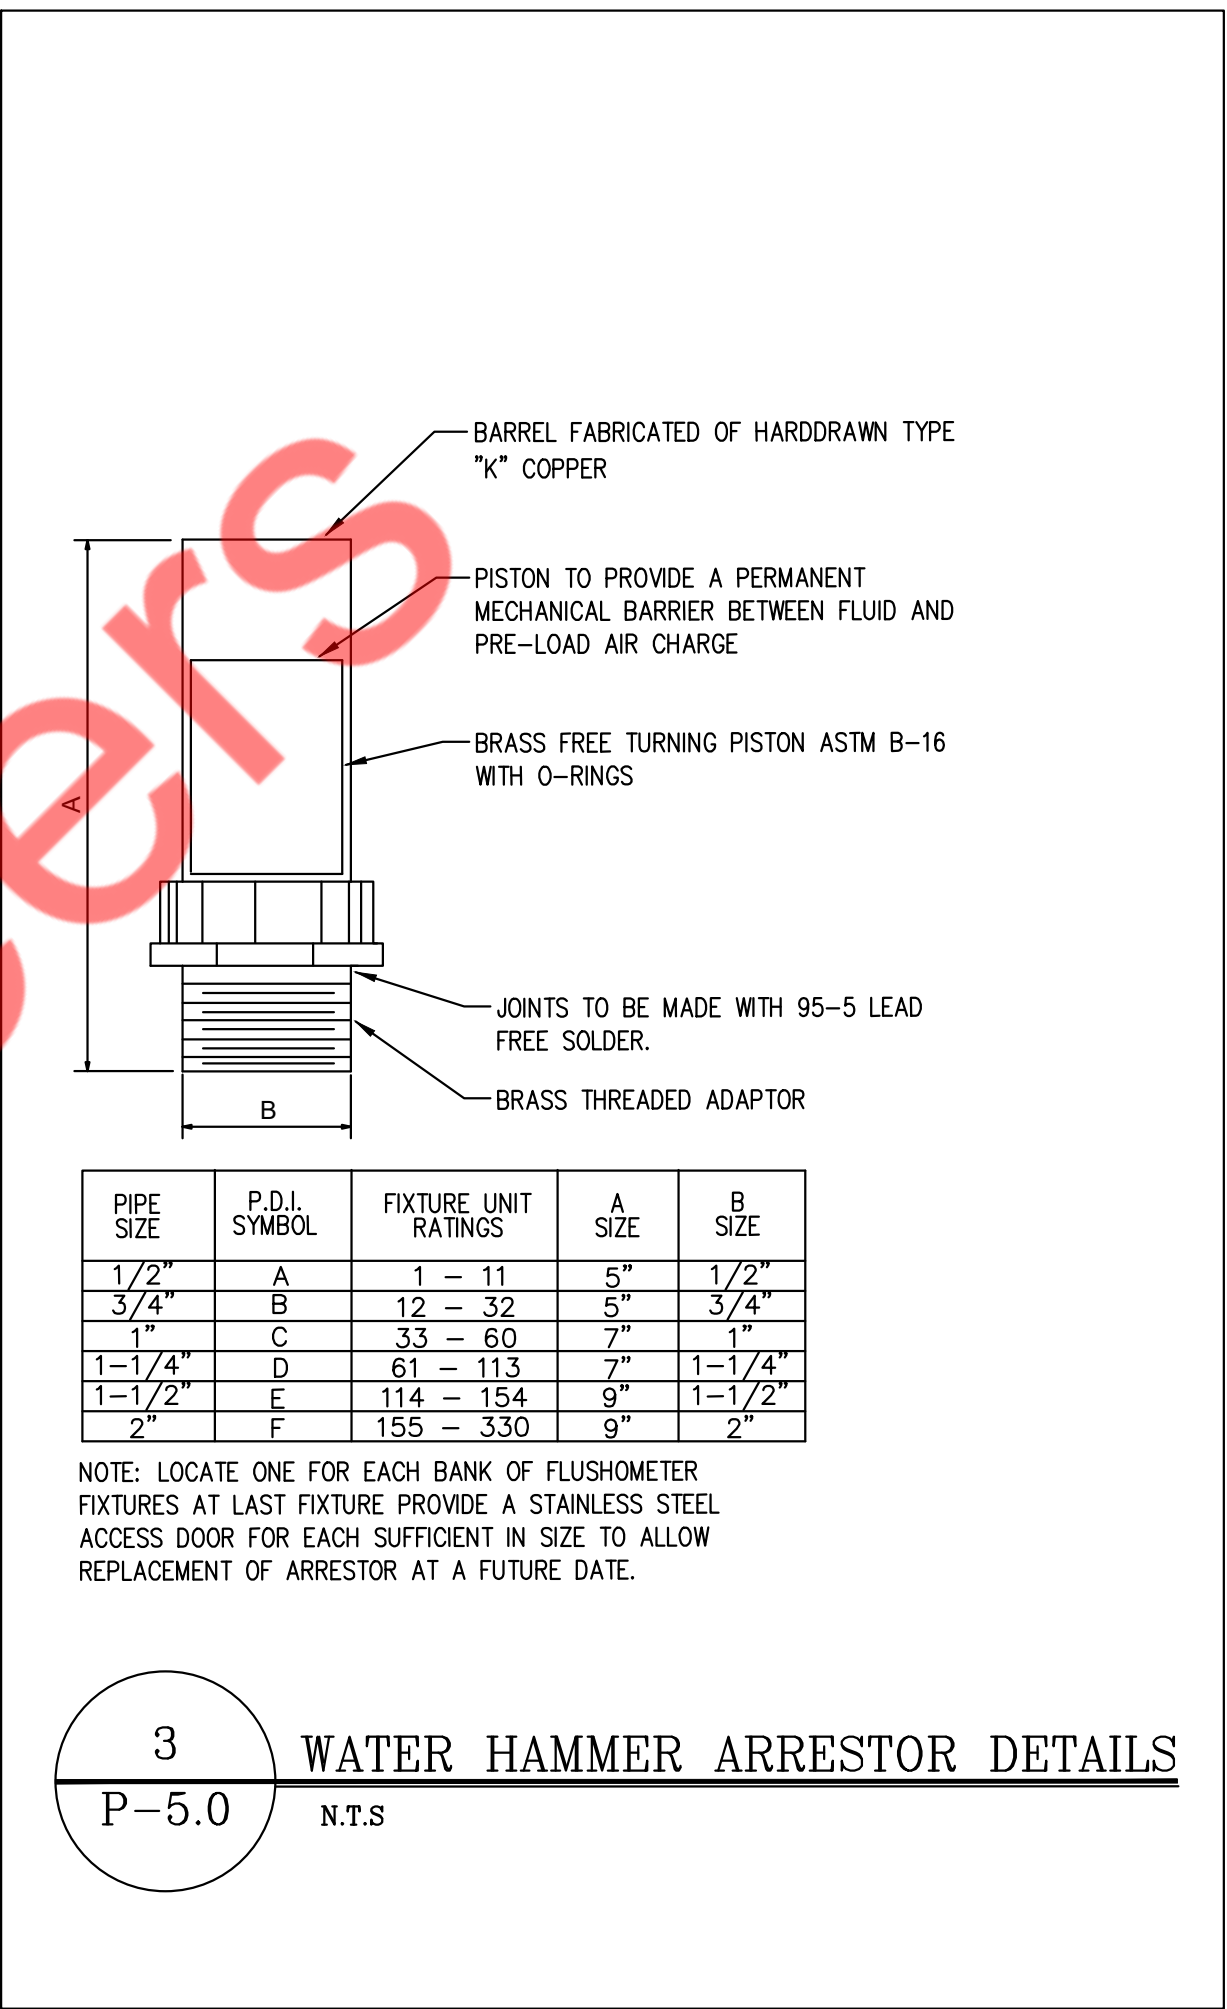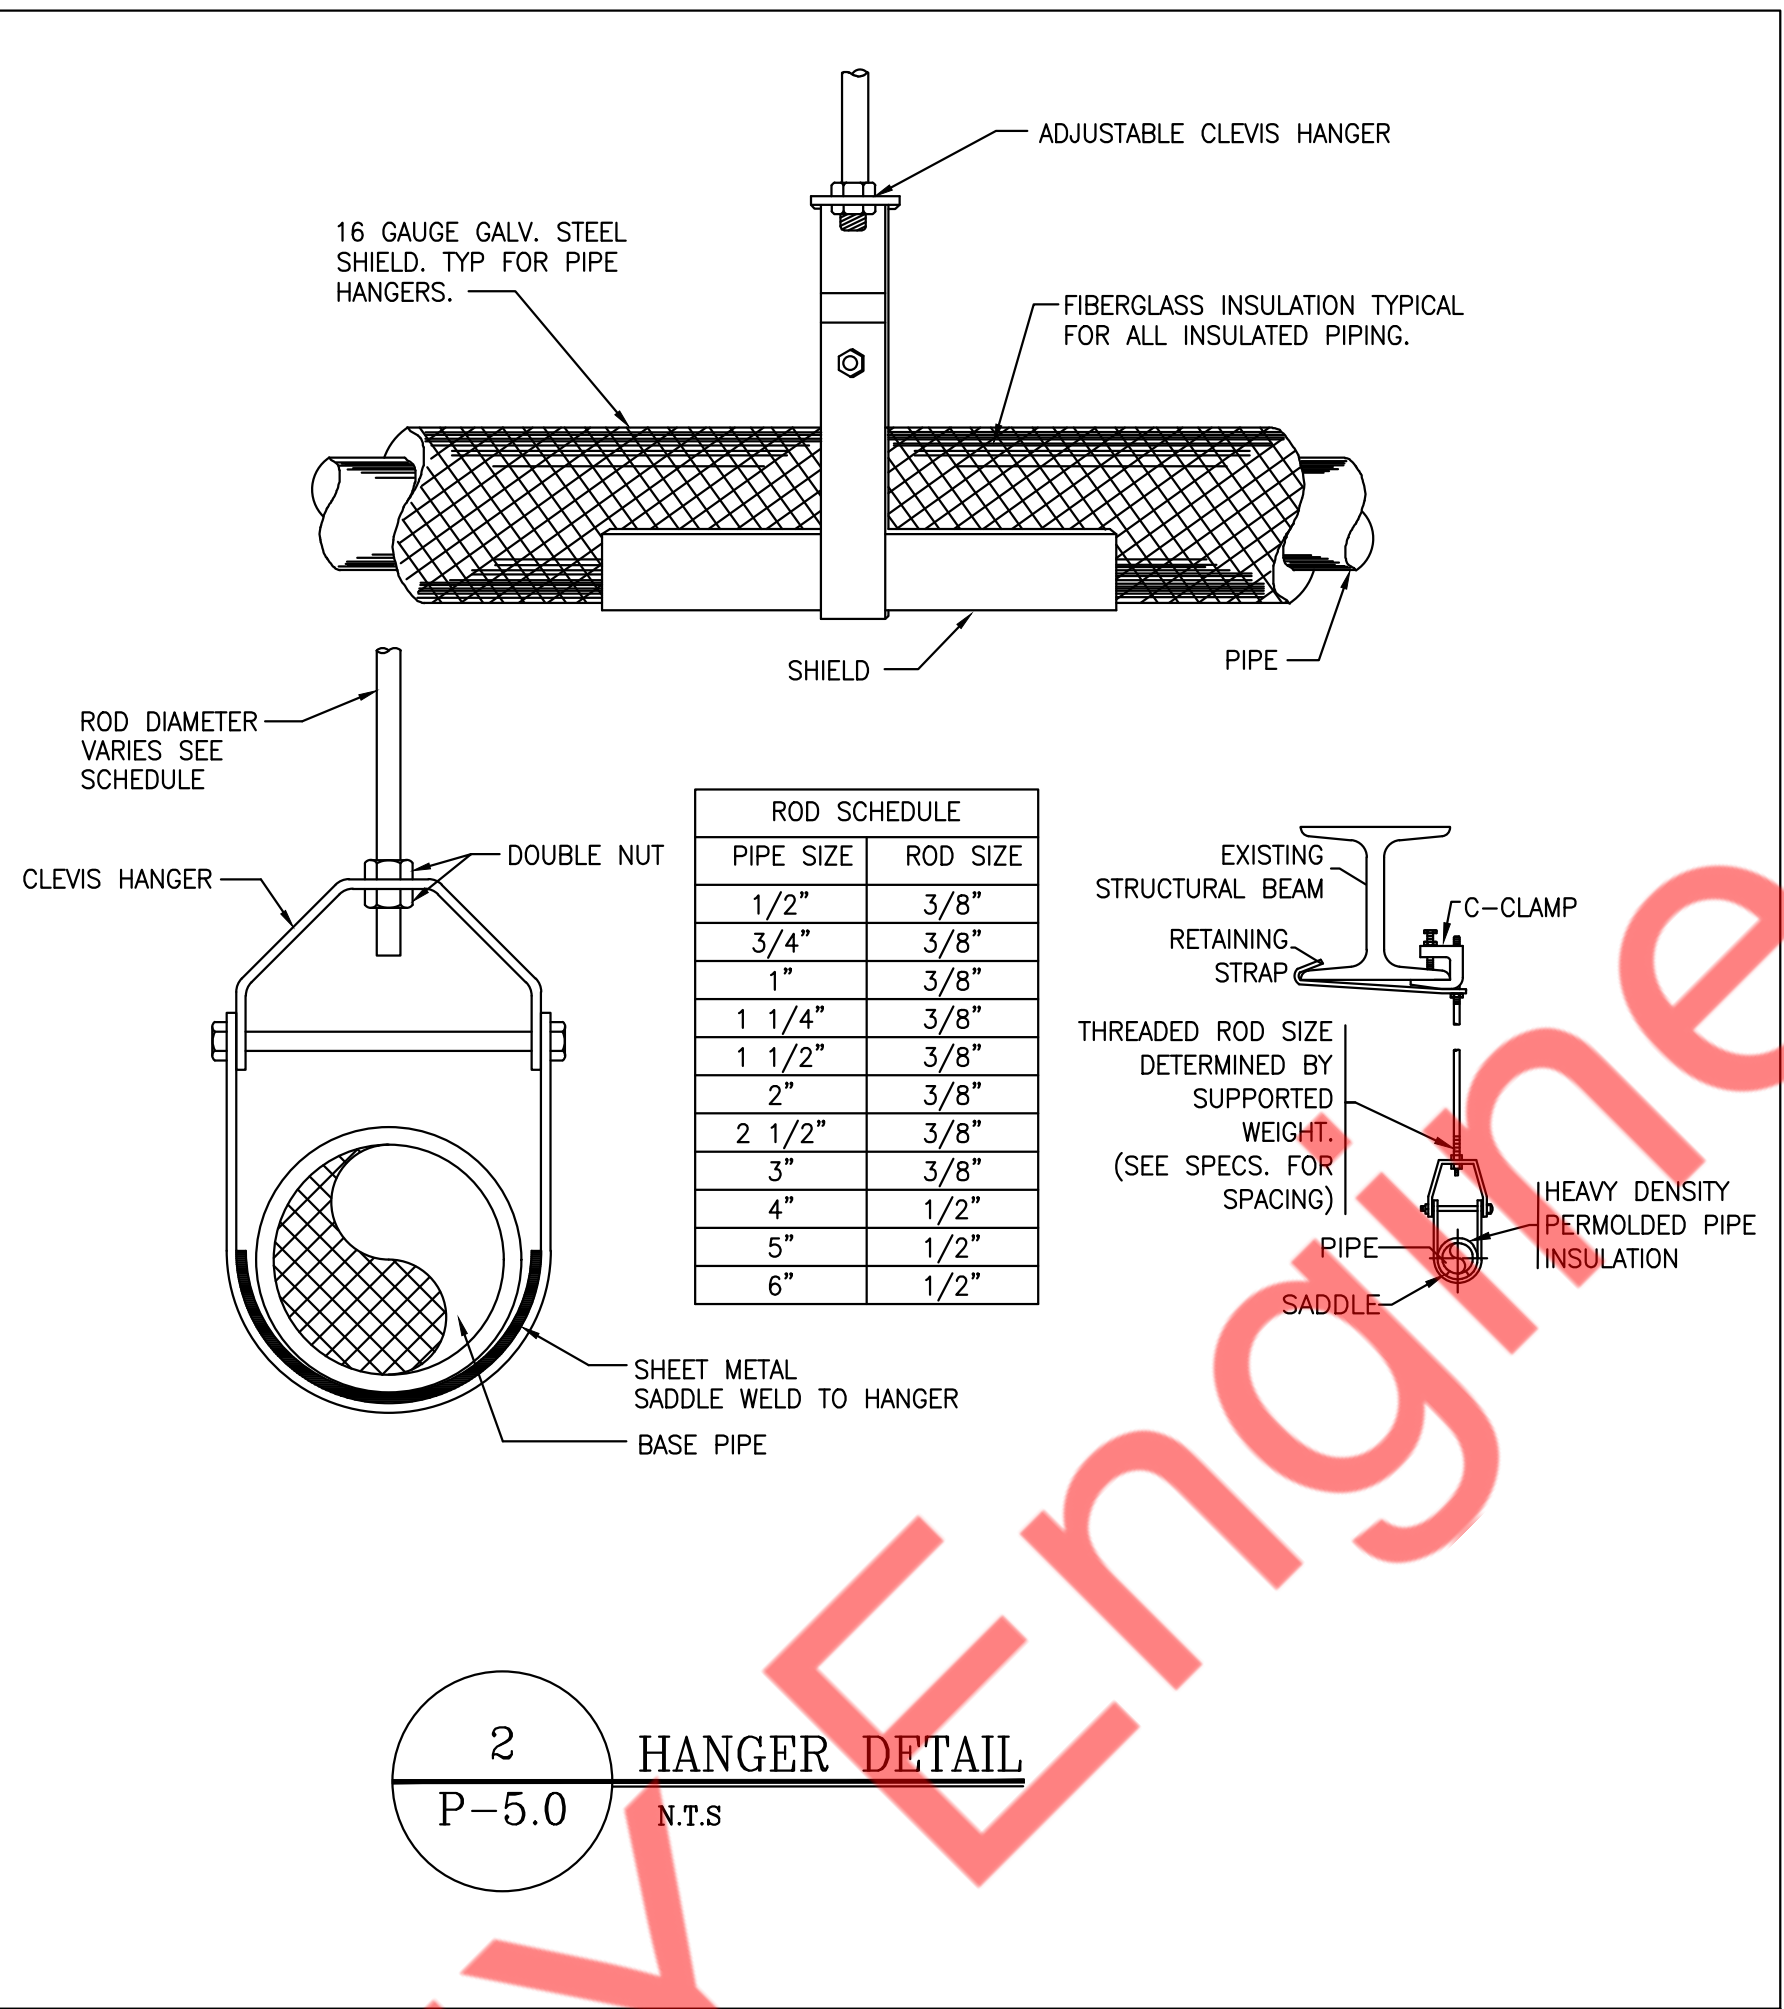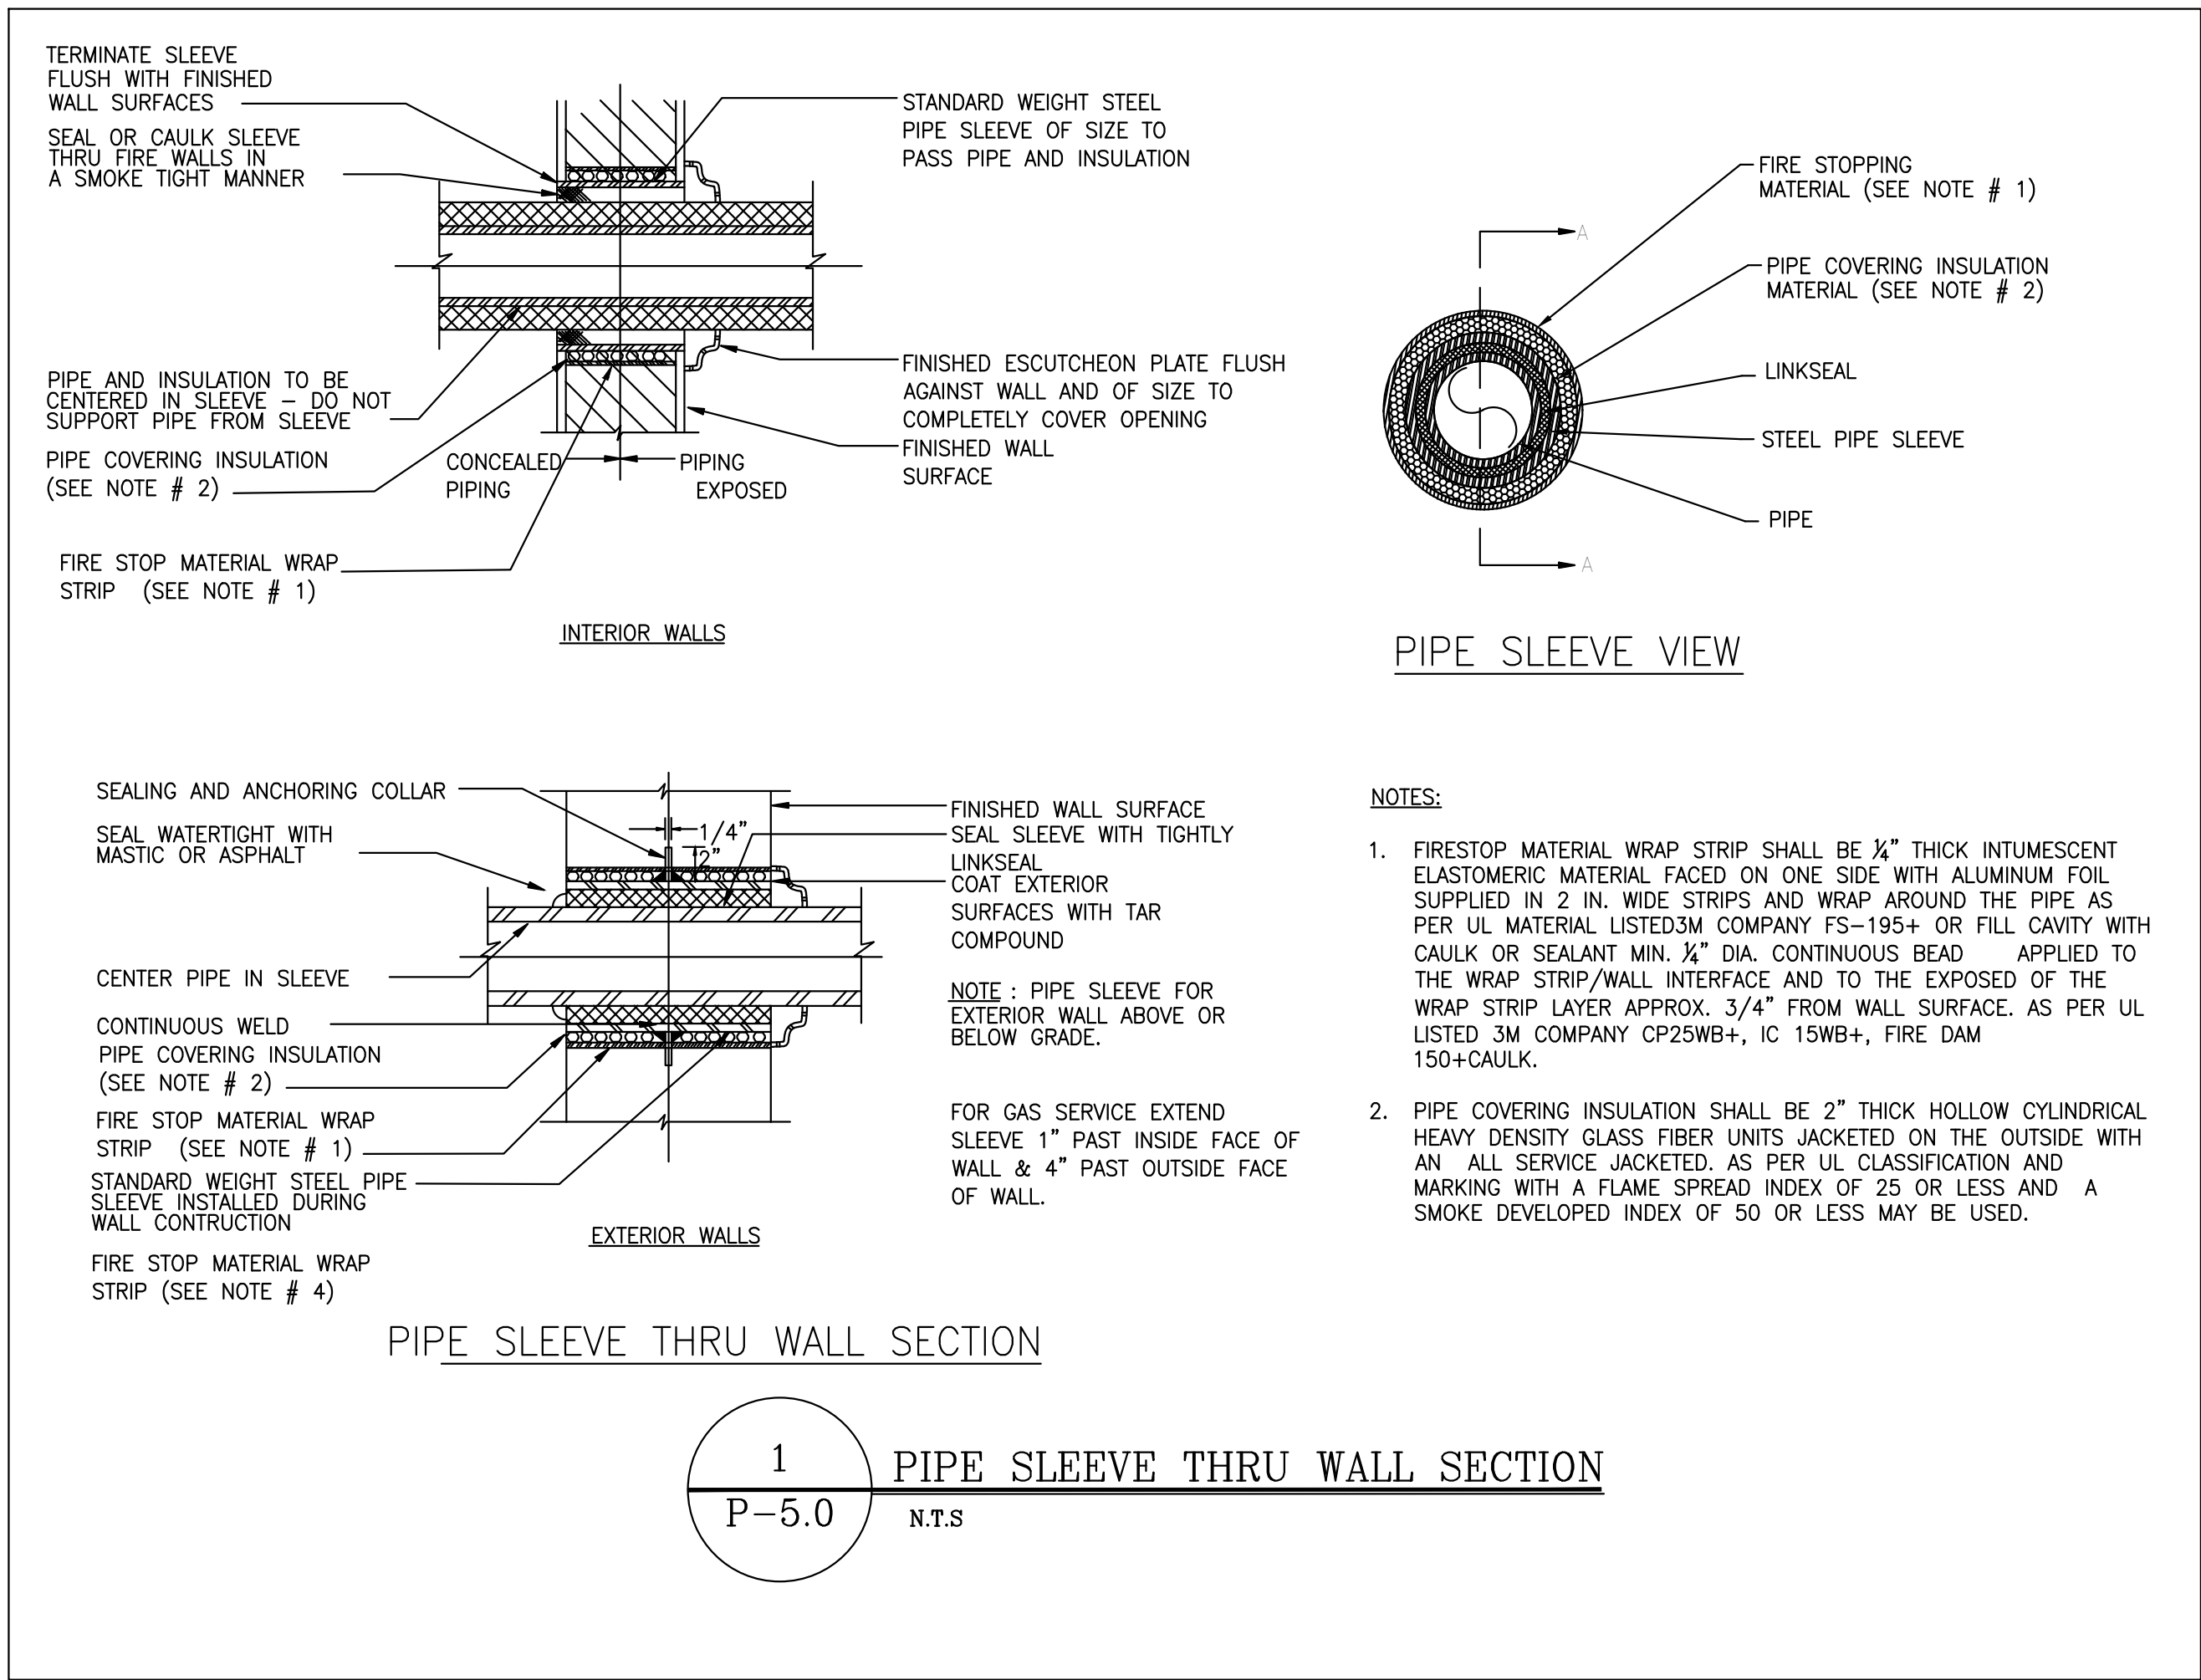

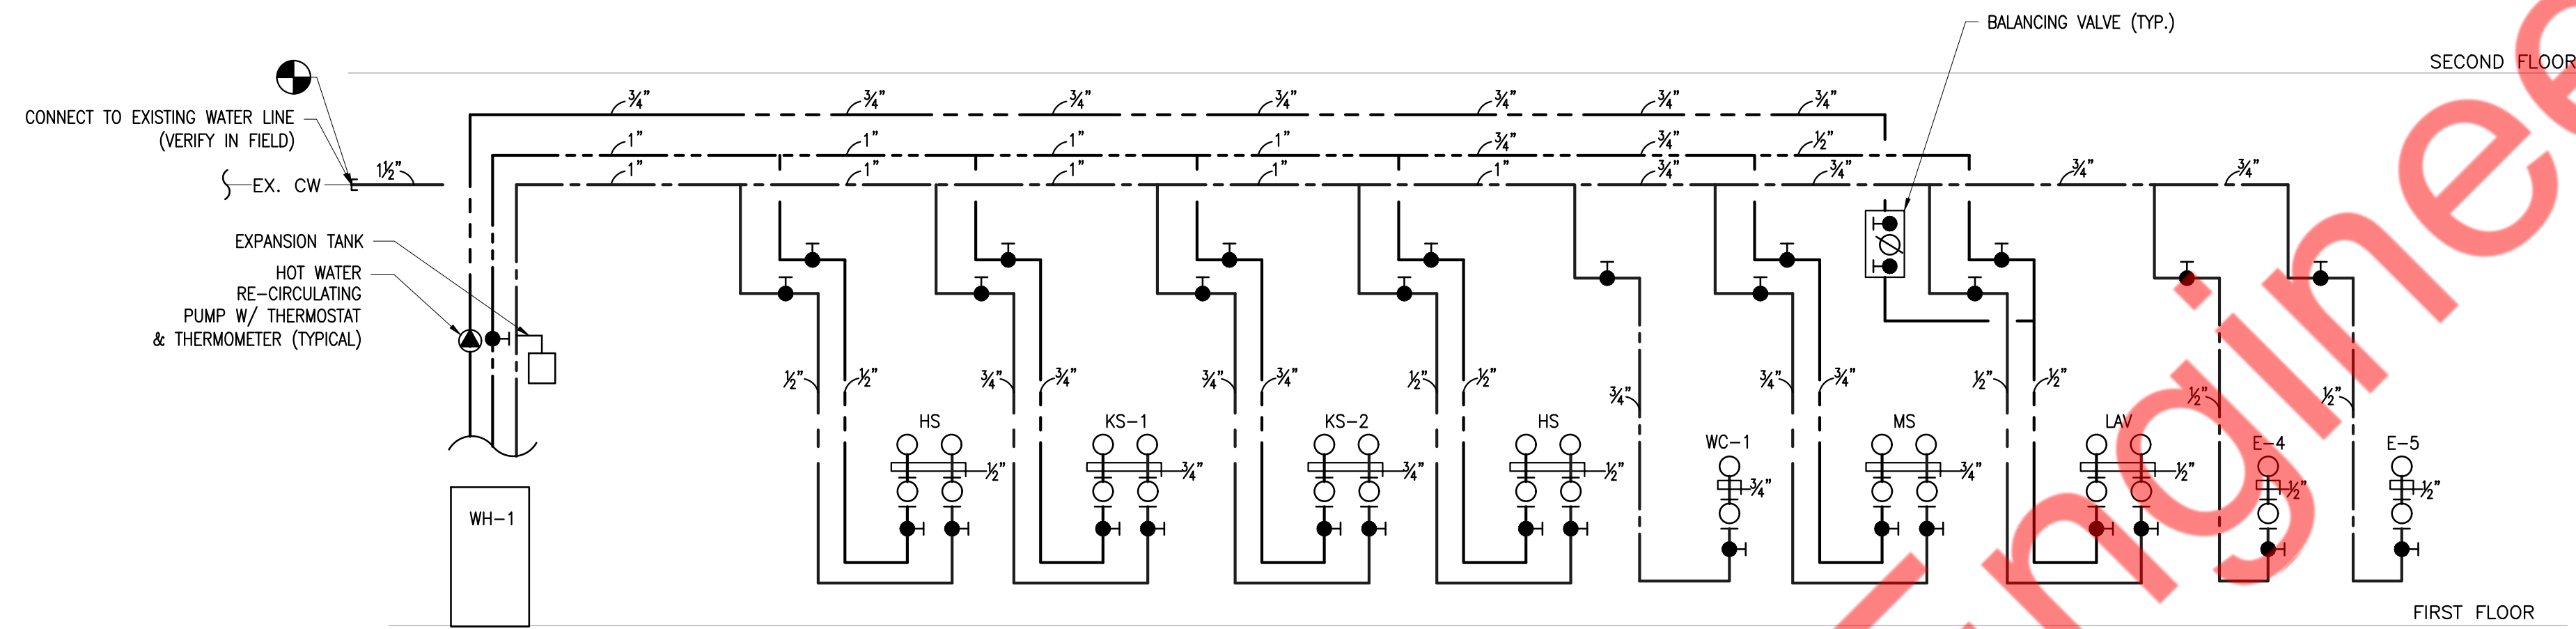


3 PLUMBING DOMESTIC WATER RISER DIAGRAM

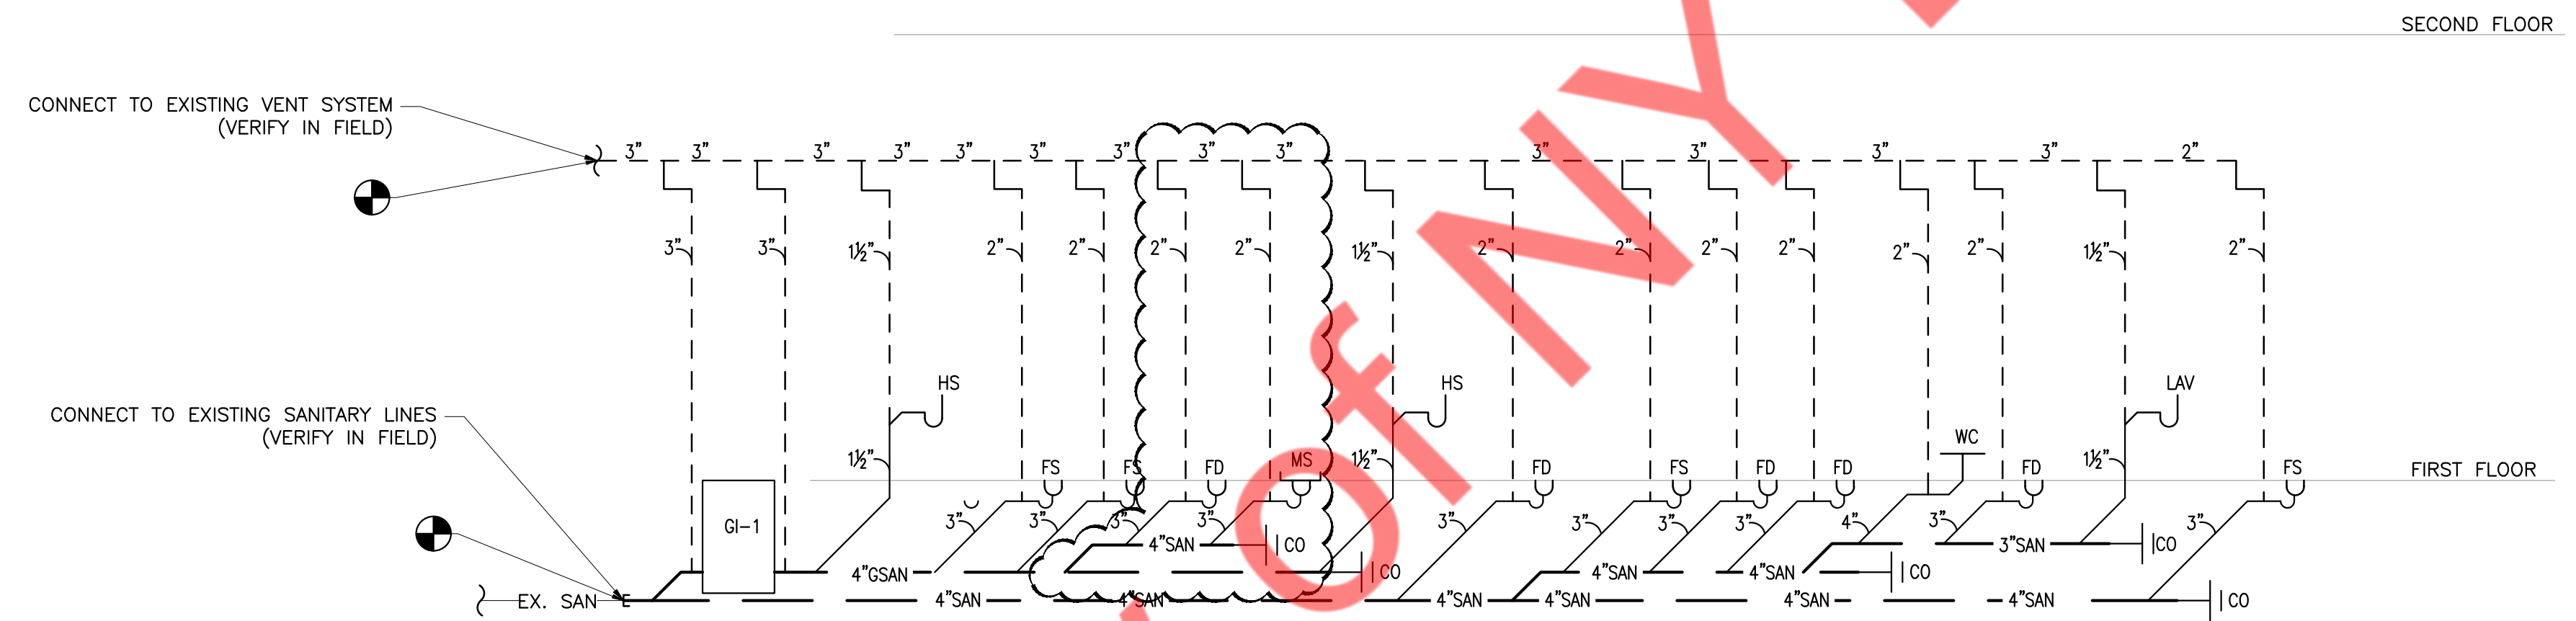

2 PLUMBING SANITARY RISER DIAGRAM

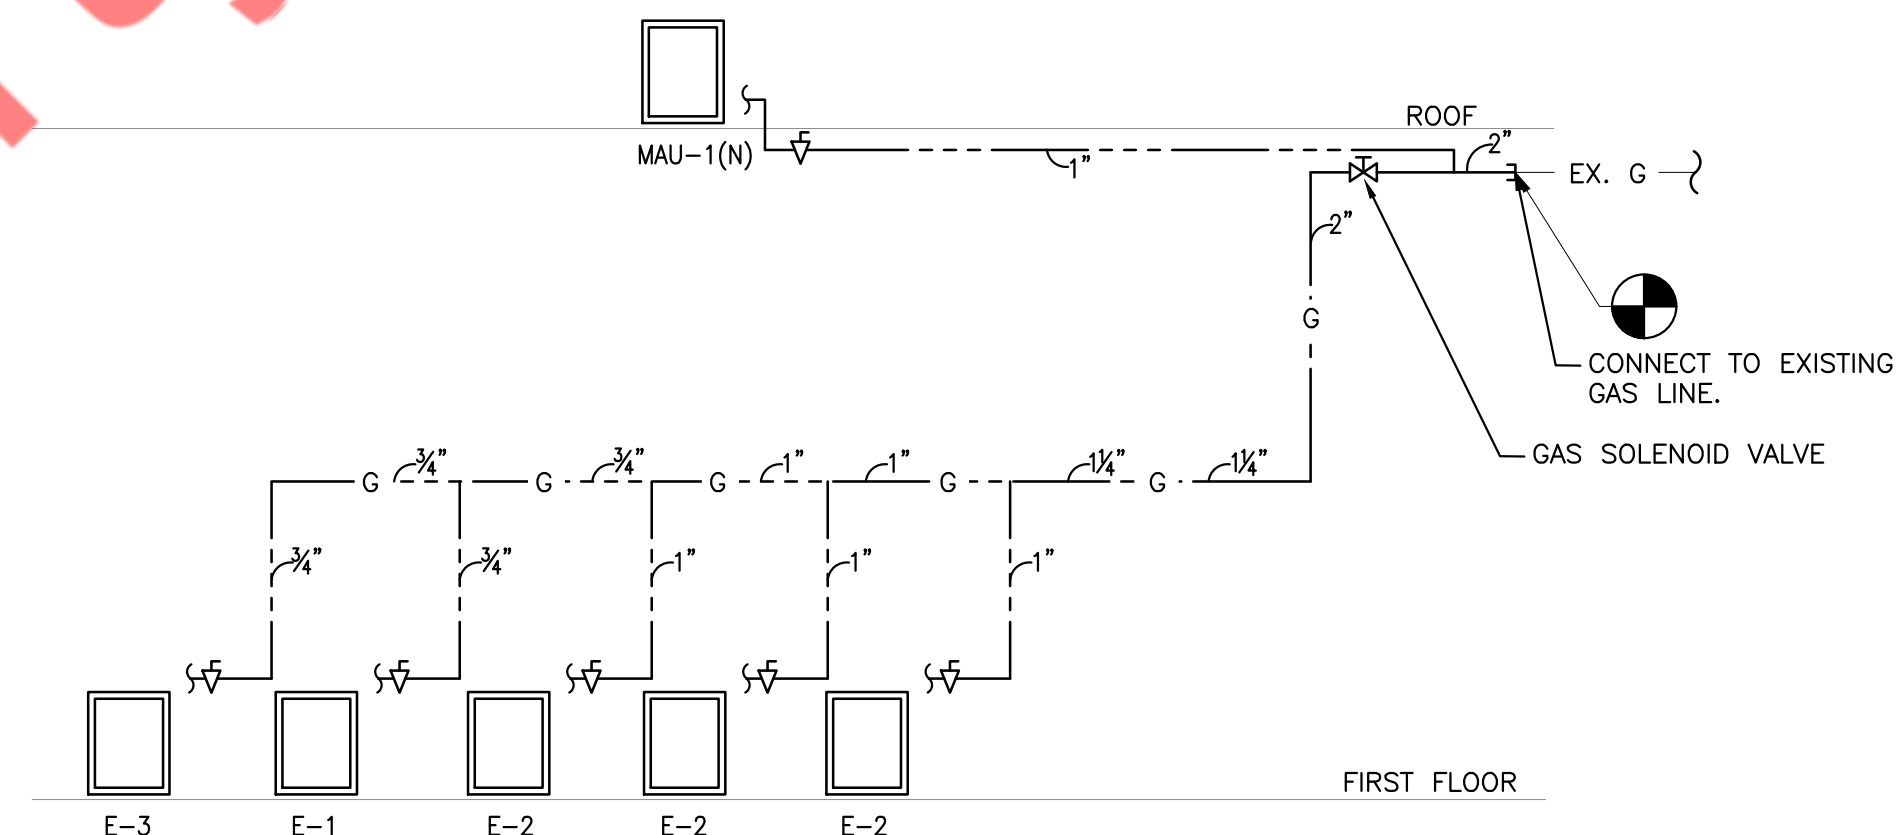GAS PIPING SIZED AS PER 2018
INTERNATIONAL FUEL GAS CODE TABLE 404.2(4)
INLET PRESSURE - LESS THAN 2 PSI
PRESSURE DROP - 0.5 IN W.C.
SPECIFIC GRAVITY - 0.60
TOTAL EQUIVALENT LENGTH OF PIPE - 70 FT




1 GAS RISER DIAGRAM

PROJECT DATA									
PROJECT DESCRIPTION		BUILDING OCCUPANCY			PROJECT DESCRIPTION				FIRE ALARM SYSTEM FEATURES
	NEW BUILDING		ASSEMBLY GROUP A (A1,A2,A3,A4 AND A5)	RESIDENTIAL GROUP R (R1,R2 AND R3)	1	TOTAL NUMBER OF LEVELS		ATRIUM	X NON-VOICE EVACUATION
	FIRE ALARM SYSTEM UPGRADE	X	BUSINESS GROUP B	STORAGE GROUP S (S1 AND S2)	1	ABOVE GROUND LEVELS		FIRE DEPARTMENT ACCESS	VOICE EVACUATION
	LIFE SAFETY SYSTEM UPGRADE		EDUCATIONAL GROUP E	UTILITY AND MISCELLANEOUS GROUP U	0	BELOW GROUND LEVELS	X	FULLY SPRINKLERED	PARTIAL/SELECTIVE EVACUATION
X	RENOVATION		FACTORY INDUSTRIAL GROUP F (F1 AND F2)	OTHER:	0	NUMBER OF ELEVATOR BANKS		PARTIALLY SPRINKLERED	GENERAL EVACUATION
	EMERGENCY REPAIR		HIGH-HAZARD GROUP H (H1,H2,H3,H4 AND H5)		0	NUMBER OF EGRESS STAIRS		NON-SPRINKLERED	OTHER: DIGITAL ALARM COMMUNICATOR
	TENANT ADDITION		INSTITUTIONAL GROUP I (I1,I2 AND I3)					PRE-ACTION SPRINKLER	OTHER: PRE-SIGNAL SYSTEM
	OTHER:		MERCANTILE GROUP M						FIRE FIGHTER'S TELEPHONE SYSTEM

SYSTEM INPUTS INITIATING DEVICES		SYSTEM OUTPUTS INDICATING/CONTROLLED DEVICES		CONTROL UNIT ANNUNCIATION			NOTIFICATION							
				ACTIVATE COMMON ALARM SIGNAL INDICATOR ON LCD OF FIRE ALARM CONTROL PANEL & OUTLYING ANNUNCIATORS.	ACTIVATE COMMON SUPERVISORY SIGNAL INDICATOR ON LCD OF FIRE ALARM CONTROL PANEL & OUTLYING ANNUNCIATORS.	ACTIVATE COMMON TROUBLE SIGNAL INDICATOR ON LCD OF FIRE ALARM CONTROL PANEL & OUTLYING ANNUNCIATORS.	SOUND INTERNAL BUZZER AT FIRE ALARM CONTROL PANEL & OUTLYING ANNUNCIATORS.	TEXT MESSAGE DISPLAY DEVICE TYPE & LOCATION OF THE ACTIVATING DEVICES ON LCD OF FIRE ALARM CONTROL PANEL & OUTLYING ANNUNCIATORS.	ACTIVATE EVACUATION SIGNAL THROUGH HORNS AND FLASH THE STROBES THROUGHOUT THE BUILDING.	TRANSMIT "MANUAL" ALARM SIGNAL TO FIRE DEPARTMENT MONITORING COMPANY.	TRANSMIT "SMOKE/HEAT/CO" ALARM SIGNAL TO FIRE DEPARTMENT MONITORING COMPANY.	TRANSMIT "WATERFLOW" ALARM SIGNAL TO FIRE DEPARTMENT MONITORING COMPANY.	TRANSMIT "SUPERVISORY" ALARM SIGNAL TO FIRE DEPARTMENT MONITORING COMPANY.	TRANSMIT "TROUBLE" ALARM SIGNAL TO FIRE DEPARTMENT MONITORING COMPANY.
		A	B	C	D	E	F	G	H	I	J	K	L	
1	MANUAL PULL STATION	●			●	●	●	●						1
2	TENANT FACP												●	2
3	AREA SMOKE DETECTOR	●			●	●	●		●					3
4	SPRINKLER CONTROL VALVE/TAMPER SWITCH		●			●					●			4
5	ALARM ACTIVATION OF OTHER SUBSYSTEM	●				●			●					5
6	FIRE ALARM AC POWER FAILURE			●	●	●						●		6
7	FIRE ALARM SYSTEM LOW BATTERY			●	●	●						●		7
8	OPEN CIRCUIT				●	●						●		8
9	GROUND CIRCUIT			●	●	●						●		9
10	NOTIFICATION APPLIANCE CIRCUIT SHORT			●		●						●		10
11	HEAT DETECTOR	●			●		●		●					11
12	CARBON MONOXIDE (CO) DETECTOR	●			●		●		●					12

FIRE ALARM NOTES:

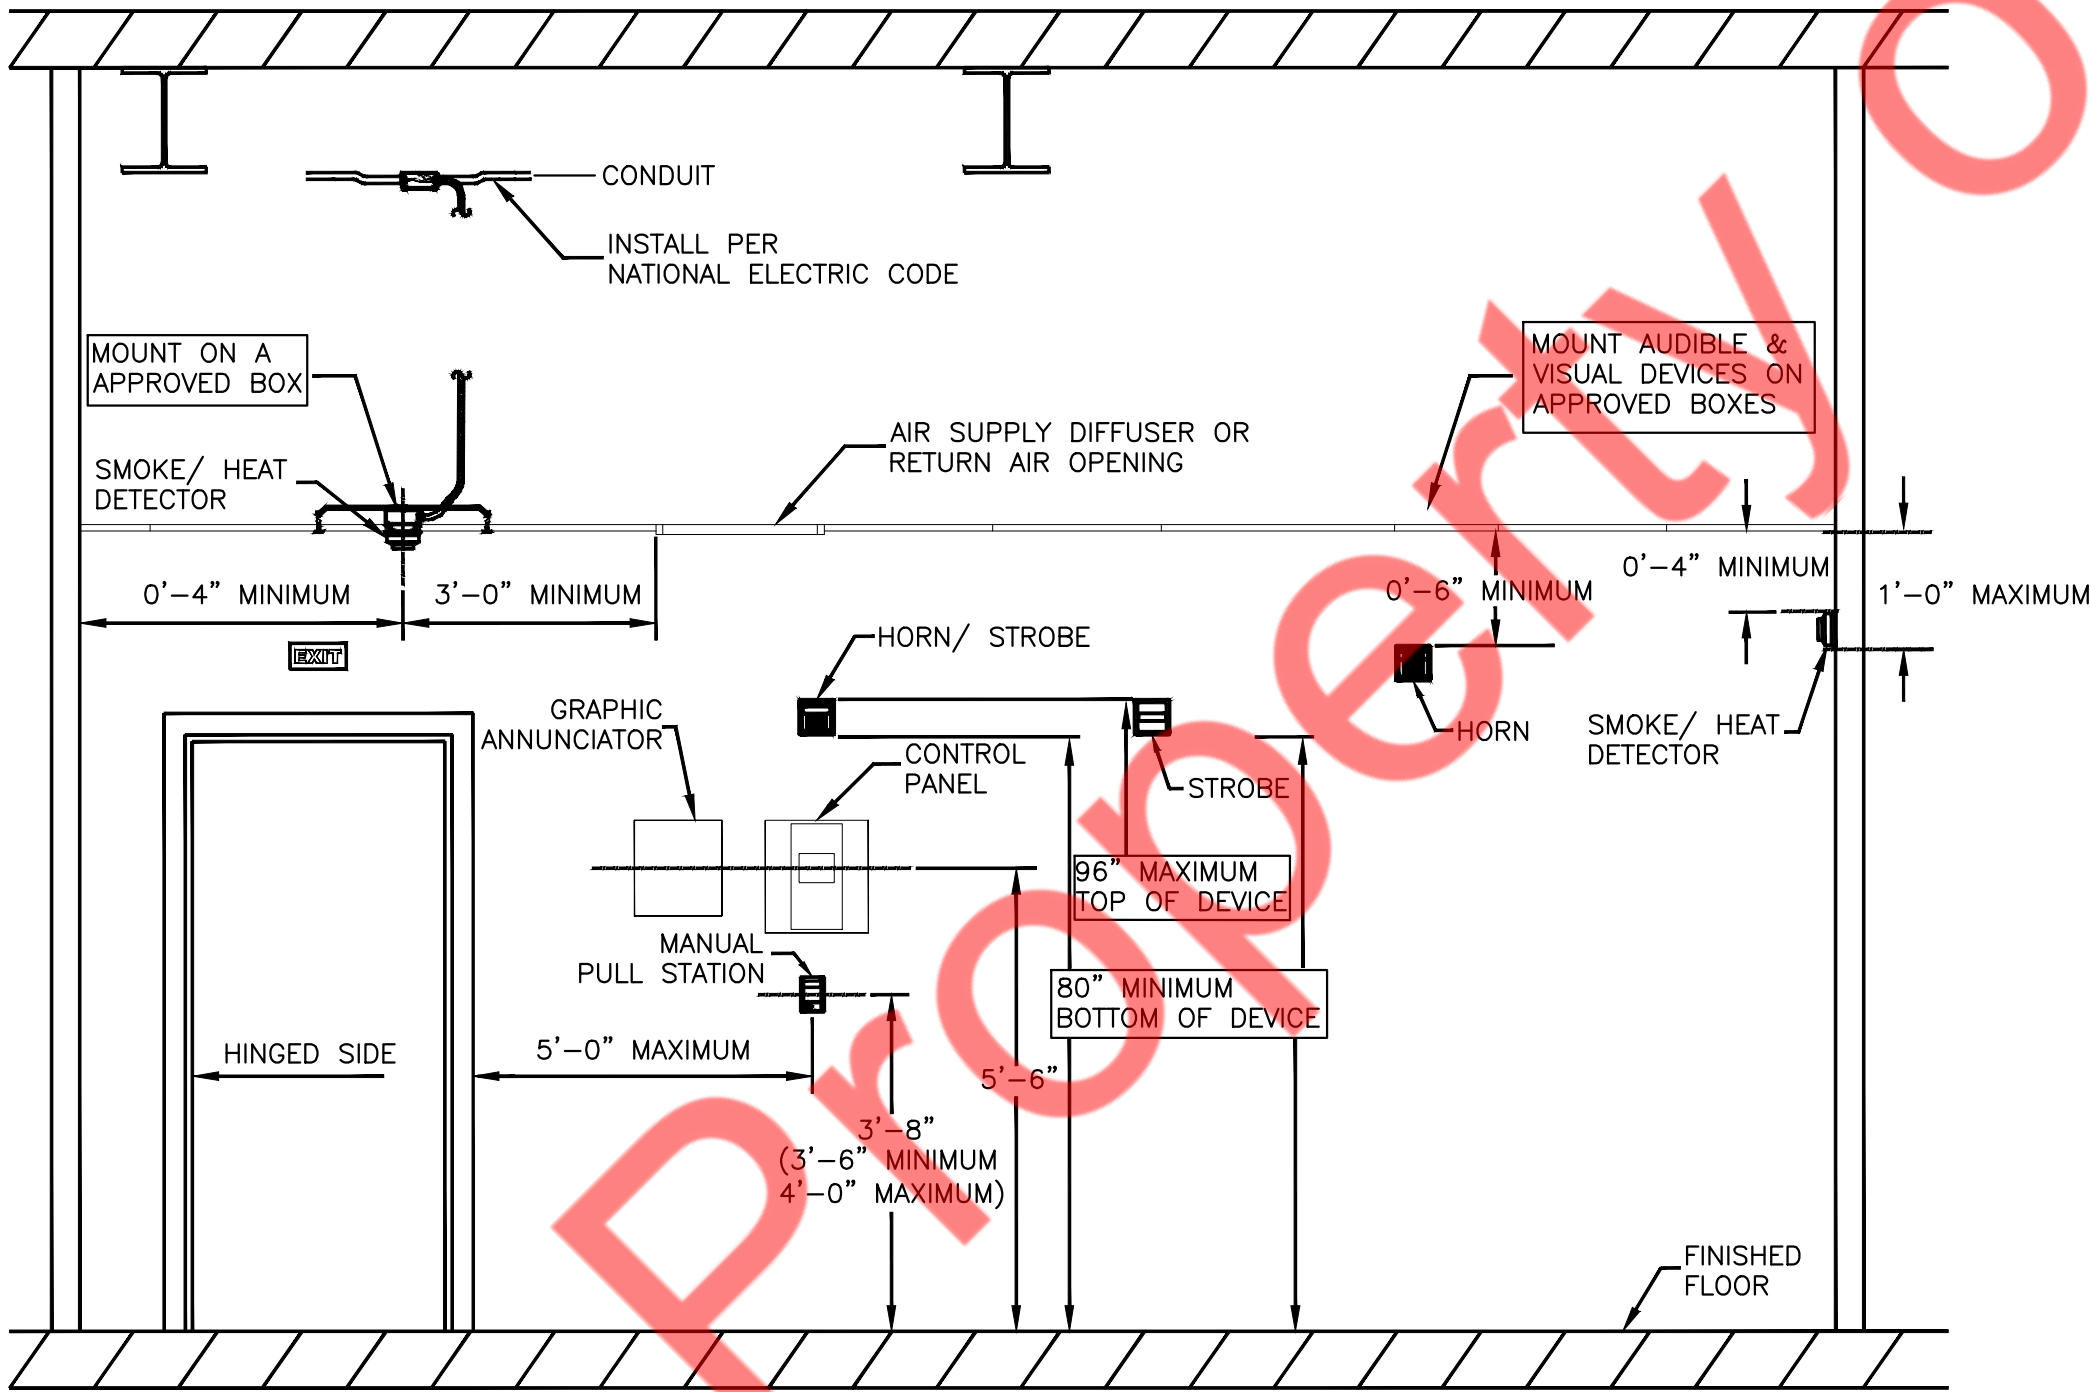- ALL EQUIPMENT AND WIRING INDICATED ON THESE PLANS IS NEW (U.O.N.).
- PROVIDE WIRING AS REQUIRED BETWEEN ALL DEVICES AND EQUIPMENT AS REQUIRED TO PERFORM FIRE ALARM SYSTEM FUNCTIONS.
- WIRING FOR FIRE ALARM DEVICES IN FINISHED SPACES WITHOUT HUNG CEILING SHALL BE INSTALLED IN EMT CONDUIT.
- ALL STROBES AND HORN/STROBES SHALL BE FLUSH WALL MOUNTED FINISH BY ARCHITECT, APPROVED FOR USE IN AUTHORITY HAVING JURISDICTION (AHJ).
- FOR WALL MOUNTED F.A. DEVICES PROVIDE 3/4" CONDUIT TERMINATED IN NEAREST ACCESSIBLE CEILING.
- WIRING FOR FIRE ALARM DEVICES IN UNFINISHED SPACES SHALL BE INSTALLED IN RGS CONDUIT UP TO 8'-0" AFF AND THEN IN EMT CONDUIT ABOVE 8'-0" AFF.
- CONTRACTOR SHALL VERIFY ALL WIRING WITH FIRE ALARM VENDOR AND OBTAIN WIRING DIAGRAMS BEFORE PROCEEDING WITH THE START OF ANY WORK.
- ALL WIRING SHALL BE IN ACCORDANCE WITH THE AHJ.
- PROVIDE ALL REQUIRED EXPANSION PANELS, PC BOARDS, POWER SUPPLIES, BATTERIES, FUSE COUTOUTS AND BRANCH CIRCUITS, ETC, FOR A COMPLETE AND OPERATIONAL FIRE ALARM SYSTEM.
- STROBES AND HORNS SHALL BE WIRED ON ALTERNATING A-B CIRCUITING IN ALL AREAS, AS INDICATED ON THE RISER DIAGRAM.
- FIRE ALARM DEVICES SHOULD BE COMPATIBLE AND CONNECTED WITH BASE BUILDING FACP.
- CONTRACTOR SHALL PERFORM ALL LOCAL BUILDING DEPT. FILINGS AND OBTAIN ALL APPROVALS. CONTRACTOR SHALL OBTAIN ALL REQUIRED SIGNED & SEALED LOCAL BUILDING DEPT. FORMS AND ALL REQUIRED SETS OF DRAWINGS FROM ENGINEER OF RECORD AND BUILDING DEPT. EXPEDITOR.
- UPON COMPLETION OF INSTALLATION THE SYSTEM SHALL BE 100% PRE-TESTED BY THE FIRE ALARM VENDOR AND THE LICENSED ELECTRICAL CONTRACTOR PRIOR TO LOCAL FIRE DEPARTMENT INSPECTION.



TYPICAL DEVICE MOUNTING DETAIL
N.T.S

DIVISION 16 — FIRE ALARM

PART 1 — GENERAL

1.1 DESCRIPTION OF WORK

- WORK UNDER THIS SECTION INCLUDES, BUT IS NOT NECESSARILY LIMITED TO, FURNISHING AND INSTALLING THE FOLLOWING:
 - FIRE ALARM PANEL, WIRING AND DEVICES
- ALL WORK SHALL BE COMPLETE AND ITEMS, EQUIPMENT, ETC., SHALL BE ELECTRICALLY CONNECTED FOR PROPER AND CORRECT OPERATION.
- ALL WORK UNDER THIS CONTRACT SHALL BE INSTALLED IN ACCORDANCE WITH THE LATEST EDITION OF THE FOLLOWING CODES AND STANDARDS IN SO FAR AS THEY APPLY:
 - NATIONAL ELECTRICAL CODE
 - NFPA 72
 - UNDERWRITER'S LABORATORIES, INC., STANDARDS AND APPROVED LISTINGS
 - ELECTRICAL TESTING LABORATORIES STANDARDS
 - NORTH CAROLINA BUILDING CODE, LATEST EDITION AND REVISIONS
 - ALL LOCAL CODES AND ORDINANCES
- THE FIRE ALARM CONTRACTOR SHALL BE LICENSED IN THE STATE OF NORTH CAROLINA AND HAVE ALL LICENSES REQUIRED FOR THE WORK.
- OBTAIN ALL PERMITS, LICENSES, INSPECTIONS, ETC. REQUIRED FOR THE WORK AND PAY FOR THE SAME. FURNISH FINAL CERTIFICATE OF INSPECTION AND APPROVAL FROM THE ELECTRICAL INSPECTOR HAVING JURISDICTION PRIOR TO ACCEPTANCE OF THE WORK.
- ALL WORK SHALL BE DONE BY SKILLED MECHANICS AND SHALL PRESENT A NEAT, TRIM, WORKMANLIKE CONDITION WHEN COMPLETED.

1.2 INTENT

- THE INTENT OF THESE SPECIFICATIONS AND ACCOMPANYING DRAWINGS IS TO CONVEY AS REASONABLY AS POSSIBLE THE REQUIREMENTS FOR A COMPLETE JOB READY FOR THE BUILDING TO OPERATE. THE FIRE ALARM CONTRACTOR SHALL TAKE THIS INTO CONSIDERATION AND INCLUDE IN HIS BASE BID ALLOWANCE FOR CONTINGENCIES AS WILL ALLOW HIM TO PROVIDE MINOR PIECES OF EQUIPMENT AND LABOR NOT SPECIFICALLY INDICATED BUT REQUIRED FOR THE JOB TO OPERATE PROPERLY, AT NO ADDITIONAL COST TO THE OWNER.

1.3 COORDINATION

- COORDINATE WORK WITH OTHER CONTRACTORS. NOTIFY ARCHITECT OF APPARENT CONFLICT EARLY TO EXPEDITE CONSTRUCTION. IF STRUCTURAL DAMAGE APPEARS IMMINENT, STOP WORK AND NOTIFY ARCHITECT FOR A DECISION BEFORE RESUMING OPERATIONS.
- LOCATIONS SHOWN ARE APPROXIMATE. THE DRAWINGS DO NOT GIVE EXACT DETAILS AS TO ELEVATIONS AND LOCATIONS OF VARIOUS PIPES, FITTINGS, DUCTS, CONDUITS, ETC., AND DO NOT SHOW ALL OFFSETS AND OTHER INSTALLATION DETAILS WHICH MAY BE REQUIRED. COORDINATE ALL LOCATIONS WITH ARCHITECT BEFORE ANY ROUGH-IN.

1.4 SHOP DRAWINGS

- PROVIDE COMPLETE SHOP DRAWINGS PER NCSFC SECTION 907.1 TO THE LOCAL FIRE MARSHAL INCLUDING:
 - FLOORPLAN WITH ROOM NAMES
 - LOCATION OF ALL FA DEVICES
 - LOCATION OF PANELS
 - POWER CONNECTIONS
 - BATTERY CALCULATIONS
 - CONDUCTOR TYPES AND SIZES
 - VOLTAGE DROP CALCULATIONS
 - EQUIPMENT CUT-SHEETS, MODEL, NUMBERS, ETC.

PART 2 — PRODUCTS AND MATERIALS

2.1 GENERAL

- ALL MATERIAL SHOULD BE NEW AND SHALL BEAR THE MANUFACTURER'S NAME TRADE, AND UL LABEL WHERE SUCH STANDARD HAS BEEN ESTABLISHED FOR THE PARTICULAR MATERIAL. MATERIALS SHALL BE STANDARD PRODUCTS OF MANUFACTURER'S REGULARLY ENGAGED IN MANUFACTURER OF THE REQUIRED TYPE OF EQUIPMENT AND THE MANUFACTURER'S LATEST APPROVED DESIGN.
 - BOXES INSTALLED IN CONCEALED LOCATIONS SHALL BE SET FLUSH WITH THE FINISHED SURFACES.
 - PROVIDE RATED BOXES ON ALL FIRE BARRIERS AND WALLS INSTALLED PER CODE.

PART 3 — EXECUTION

3.1 FIRE ALARM SYSTEM EQUIPMENT

- PROVIDE A COMPLETE OPERABLE FIRE ALARM SYSTEM AS SHOWN ON THE DRAWINGS AND AS REQUIRED BY STATE AND LOCAL CODES.
- ALL FIRE ALARM SYSTEM CABLES SHALL BE INSTALLED IN CONDUIT. SIZE AS REQUIRED BY THE EQUIPMENT SUPPLIER. PROVIDE A SUBMITTAL OF ALL DEVICES AND A RISER DIAGRAM FOR APPROVAL BEFORE INSTALLATION OF ANY EQUIPMENT.

3.2 CLEAN UP

- DURING CONSTRUCTION, KEEP THE SITE CLEAN OF DEBRIS. UPON COMPLETION, AND BEFORE FINAL INSPECTION, CLEAN UP THE PREMISES TO REMOVE ALL EVIDENCE OF WORK. IN ADDITION UPON COMPLETION OF CONSTRUCTION LEAVE EQUIPMENT CLEAN.

3.3 GUARANTEE

- GUARANTEE ALL MATERIALS AND LABOR INCLUDED IN THE FIRE ALARM WORK FOR A PERIOD OF ON YEAR FROM DATE OF FINAL ACCEPTANCE BY THE OWNER. ANY PART OR PARTS OF THE WORK OR EQUIPMENT WHICH PROVE TO BR DEFECTIVE DURING THE GUARANTEE PERIOD SHALL BE REPLACED AT NO ADDITIONAL COST TO THE OWNER.

SPRINKLER GENERAL NOTES

- ALL SPRINKLER WORK SHALL BE IN ACCORDANCE WITH THE REQUIREMENTS OF N.F.P.A.-13-2016 AND ALL LOCAL AUTHORITIES.
- ALL SPRINKLER WORK SHALL COMPLY WITH BUILDING STANDARDS AND REQUIREMENTS.
- ALL SPRINKLER HEADS SHALL BE INSTALLED AT CENTER OF TILE IF CEILING IS PROVIDED.
- GENERAL CONTRACTOR SHALL COORDINATE FINAL FURNITURE/EQUIPMENT HEIGHT ELEVATIONS AND LOCATIONS WITH SPRINKLER INSTALLATION. ENGINEER SHALL BE NOTIFIED WHEN FURNITURE/EQUIPMENT IS LESS THAN 18" TO UNDERSIDE OF CEILING.
- THE SPRINKLER SYSTEMS ARE TO BE HYDROSTATIC TESTED FOR A (1) HOUR MINIMUM AT 200 PSI. PRESSURE AND ARE TO BE WITNESSED BY AUTHORIZED BUILDING PERSONNEL. COORDINATE ALL TESTING WITH BUILDING MANAGER.
- PIPES SIZES SHOWN ARE BASED ON DESIGN PIPING LAYOUTS ONLY. ACTUAL PIPE SIZES SHALL BE DETERMINED BY CONTRACTORS HYDRAULIC CALCULATIONS BASED ON HIS INSTALLATION DRAWINGS. CONTRACTOR SHALL ALLOW FOR THIS AND INCLUDE THIS IN HIS CONTRACT PRICE.
- DRAWING INDICATES SPRINKLER SYSTEM DESIGN ONLY. CONTRACTOR RESPONSIBLE FOR OFFSETS, DROPS AND RISES FOR COORDINATION WITH OTHER TRADES.
- G.C. SHALL BE RESPONSIBLE FOR ALL FINAL TESTS AND INSPECTIONS OF COMPLETED WORK REQUIRED BY THE BUILDING MANAGEMENT PRIOR TO OCCUPANCY OF SPACE.
- ALL SPRINKLER WORK SHALL BE TESTED AND MADE OPERATIONAL PRIOR TO CARPET AND FURNITURE INSTALLATION. G.C. SHALL REPAIR AND/OR REPLACE ALL FINISHES DAMAGED BY DEFECTIVE SPRINKLER WORK AT HIS EXPENSE.
- ALL BURNING, CUTTING, SOLDERING AND WELDING SHALL BE COORDINATED WITH BUILDING FIRE SYSTEMS WITH BUILDING MANAGEMENT, AS REQUIRED.
- G.C. SHALL BE RESPONSIBLE FOR OBTAINING PERMITS AND APPROVALS REQUIRED BY BUILDING INSPECTOR AND FIRE MARSHALL IN CONJUNCTION WITH CHANGES TO EXISTING SPRINKLER SYSTEM.
- REFER TO ENGINEERING DRAWINGS FOR SPRINKLER HEADS, LIGHT SENSORS AND FIRE DETECTION DEVICES.
- ALL WORK TO BE DONE DURING THE HOURS DESIGNATED BY OWNER.
- UPON COMPLETION OF ALL SPRINKLER WORK, CONTRACTOR SHALL TEST AND INSPECT ENTIRE SPRINKLER SYSTEM. ENTIRE SYSTEM SHALL BE FULLY OPERATIONAL AND APPROVED IN COMPLIANCE WITH ALL AHJ.
- UPON SUCCESSFUL COMPLETION OF ALL TESTING, CONTRACTOR SHALL PRIME AND PAINT ALL EXPOSED SPRINKLER PIPING. COLOR AND FINISH SHALL BE AS PER ARCHITECT.
- CONTRACTOR SHALL INCLUDE IN HIS BID THE COST TO PROVIDE (5) FIVE ADDITIONAL SPRINKLERS INSTALLED. EXACT LOCATIONS OF THESE SPRINKLER HEADS SHALL BE DETERMINED IN FIELD.
- FOR SPRINKLER WORK DONE IN ACCORDANCE WITH THE REQUIREMENTS OF N.F.P.A.-13-2016, HYDROSTATIC TESTS IN ACCORDANCE WITH REFERENCE STANDARD NFPA 13-2016, AS MODIFIED FOR CITY OF NEWARK, NEW JERSEY, ARE NECESSARY.
- CONTRACTOR SHALL COORDINATE WITH OTHER TRADES AND SHALL INSTALL NEW WORK TO CLEAR DUCTWORK AND LIGHTING FIXTURES.
- ALL SPRINKLER WORK SHALL COMPLY WITH BUILDING STANDARDS AND REQUIREMENTS.
- DRAWING INDICATES SPRINKLER SYSTEM DESIGN ONLY. CONTRACTOR RESPONSIBLE FOR OFFSETS, DROPS AND RISES FOR COORDINATION WITH OTHER TRADES.
- PIPES SIZES SHOWN ARE BASED ON SCHEDULE OF PIPE SIZE PIPING LAYOUTS ONLY. ACTUAL PIPE SIZES SHALL BE DETERMINED BY CONTRACTORS HYDRAULIC CALCULATIONS BASED ON HIS INSTALLATION DRAWINGS. CONTRACTOR SHALL ALLOW FOR THIS AND INCLUDE THIS IN HIS CONTRACT PRICE.
- PROVIDE AUXILIARY DRAINS AT TRAPPED SECTIONS OF PIPING AS REQUIRED BY NFPA.
- GENERAL CONTRACTOR SHALL COORDINATE FINAL FURNITURE/ EQUIPMENT HEIGHT ELEVATIONS AND LOCATIONS WITH SPRINKLER INSTALLATION. ENGINEER SHALL BE NOTIFIED WHEN FURNITURE/EQUIPMENT IS LESS THAN 18" TO UNDERSIDE OF CEILING PRIOR TO INSTALLATION.
- COMPOSITE DRAWINGS
CONTRACTOR SHALL BE GIVEN A SEPIA TRANSPARENCIES TO IMPOSE THEIR WORK FOR A COORDINATED ALLOCATION OF SPACE. PROCEDURE SHALL INCLUDE HVAC CONTRACTOR TO INDICATE DUCT WORK, PIPING, STRUCTURAL AND ARCHITECTURAL DETAILS. SEPIAS SHALL BE GIVEN TO PLUMBING, SPRINKLER AND ELECTRICAL TRADES WHO WILL DRAW HIS WORK ON DRAWINGS. HVAC CONTRACTORS SHALL HOLD A COORDINATION MEETING WITH ALL CONTRACTORS TO ELIMINATE INTERFERENCE OR CONFLICTS IN INSTALLING WORK. IF UNABLE TO EACH AGREEMENT ISSUE, ARCHITECT SHALL MAKE BINDING DECISION.
- CONTRACTOR SHALL COORDINATE SPRINKLER MAIN AND BRANCHES WITH NEW CONSTRUCTION TO AVOID CONFLICTS WITH CEILING HEIGHTS, DUCTWORK, LIGHTING FIXTURES, BEAMS. CONTRACTOR TO ADJUST PIPING ACCORDINGLY TO ACCOMMODATE NEW CONSTRUCTION.

BUILDING DEPARTMENT SPRINKLER NOTES

- THE INSTALLATION, COMPONENTS, SIZING, SPACING, CLEARANCES, POSITION AND TYPE OF SYSTEMS SHALL CONFORM TO THE 2018 INTERNATIONAL BUILDING CODE, NEW JERSEY EDITION SECTION 903.
- ONLY APPROVED MATERIALS SHALL BE USED AS PER INTERNATIONAL FIRE CODE 2015 EDITION SECTION 104.7
- DIRECT CONNECTION OF SPRINKLERS TO THE PUBLIC WATER SYSTEM SHALL CONFORM TO 2018 INTERNATIONAL BUILDING CODE, NEW JERSEY EDITION SECTION 903.3.5
- SPRINKLER SHALL BE PROTECTED AGAINST FREEZING AND INJURY AS PER NFPA 13-2016 SEC. 8.16.4
- THE OCCUPANCY OF THE AREAS TO BE SPRINKLERED IN ACCORDANCE WITH 2018 INTERNATIONAL BUILDING CODE, NEW JERSEY EDITION SECTION 903.2
- PIPING, FITTINGS, SPECIFICATIONS, PIPE SCHEDULES, SYSTEM TEST PIPES, PROTECTION AGAINST CORROSION, DAMAGE, VALVES, HANGERS, SPRINKLERS GUARDS AND SHIELDS SHALL BE AS PER WITH 2018 INTERNATIONAL BUILDING CODE, NEW JERSEY EDITION, SECTION 903.2
- STOCK OF EXTRA SPRINKLERS WILL BE FURNISHED AS PER NFPA 13-2016 SECTION 6.2.9 (REQUIRED FOR EACH TEMPERATURE RATING).
- SPRINKLER ALARM SHALL BE IN ACCORDANCE WITH 2018 INTERNATIONAL BUILDING CODE, NEW JERSEY EDITION, SECTION 907.
- SPACING, LOCATION AND POSITION OF SPRINKLER WILL BE AS PER 2018 INTERNATIONAL BUILDING CODE, NEW JERSEY EDITION, SECTION 903.3
- ALL BLIND SPACES EXCEEDING 6" IN WIDTH OR DEPTH WHICH CONTAIN COMBUSTIBLE MATERIAL WILL BE SPRINKLERED.
- ALL PIPE PASSING THROUGH WALLS WILL COMPLY WITH SECTION 2018 INTERNATIONAL BUILDING CODE NEW JERSEY EDITION SECTION 714.
- THERE IS NO HIGH PILED STORAGE AS DEFINED IN INTERNATIONAL FIRE CODE 2015 SECTION 3201
- DISTANCE OF SPRINKLERS FROM HEAT SOURCE SHALL BE AS PER NFPA 13-2016 SECTION 8.3.2.5
- ALL PIPES PASSING THROUGH FOUNDATION WALLS SHALL BE PROTECTED AS PROVIDED BY SECTION 2.9.1 OF 2018 NATIONAL STANDARD PLUMBING CODE.
- THIS APPLICATION IS NOT FILED AS A RESULT OF ACTION BY THE FIRE COMMISSIONER AS AUTHORIZED BY BS & A TO MODIFY THE CERTIFICATE OF OCCUPANCY NOR IS SUCH ACTION PENDING.
- ALL VALVES SHALL BE IDENTIFIED AS REQUIRED BY NFPA 13 SECTION 6.6.
- A ONE-PIECE REDUCING FITTING OF GOOD DESIGN SHOULD BE USED WHEREVER A CHANGE IS MADE IN THE SIZE OF PIPE, AS PER NFPA 13 SECTION 6.4.7.1
- ALL VALVES ON CONNECTIONS TO WATER SUPPLIES TO SPRINKLER SHALL BE APPROVED O.S. & Y. OR APPROVED INDICATOR TYPE.
- DRAIN VALVES AND TEST VALVES SHALL BE APPROVED TYPE AS PER NFPA-13-2016 SECTION 6.6.3
- HANGERS SHOULD BE SUPPORTED BY WROUGHT IRON U TYPE OR APPROVED ADJUSTABLE HANGERS. HANGERS SHALL BE OF THE TYPE APPROVED FOR USE WITH THE PIPE OR TUBE INVOLVED, AS PER NFPA-13 SECTION 9.1
- TEMPERATURE RATING SHALL COMPLY WITH NFPA-13-2016 SECTION 8.3.2
- 18" MINIMUM CLEARANCE TO BELOW SPRINKLER DEFLECTOR AS PER NFPA-13-2016 SECTION 8.5.6
- AUTOMATIC INTERLOCK CUTOFF SWITCH FOR VENTILATION WILL CONFORM TO CHAPTER 6 OF THE MECHANICAL CODE (APPLICABLE ONLY IF THERE IS AN AIR SYSTEM UTILIZING RECIRCULATED AIR AND REQUIRING A THERMOSTATIC DEVICE).
- MINIMUM BRANCH PIPE SIZE TO BE ONE INCH (1").
- THIS APPLICATION IS MADE ONLY FOR WORK INDICATED ON THE SPECIFICATION SHEET. ALL OTHER MATTERS SHOWN ARE NOT TO BE RELIED UPON OR TO BE CONSIDERED AS EITHER BEING APPROVED OR IN ACCORDANCE WITH APPLICABLE CODES.
- WET SPRINKLER SYSTEM SUBJECTED TO FREEZING SHOULD COMPLY WITH NFPA 13-2016 SEC. 8.16.4.
- INSPECTION AND TESTS OF SPRINKLERS SHALL BE CONDUCTED AS PER 2018 INTERNATIONAL BUILDING CODE, NEW JERSEY EDITION, SECTION 901.

SPRINKLER DRAWING LIST

- SP0.1 SPRINKLER SYMBOLS, ABBREVIATIONS, NOTES, PLOT PLAN & RISER DIAGRAM
- SP0.2 SPRINKLER NOTES & SPECIFICATIONS
- SP1.0 SPRINKLER PLAN
- SP5.0 SPRINKLER DETAILS

SPACING BETWEEN SPRINKLER HEADS

LIGHT HAZARD: 15' MAX.
ORDINARY HAZARD: 15' MAX

NOTE: MAXIMUM DISTANCE BETWEEN SPRINKLER HEADS & WALLS IS ½ THE DISTANCE BETWEEN HEADS.

PROTECTION AREA OF SPRINKLER HEADS

LIGHT HAZARD : 225 SQ. FT.
ORDINARY HAZARD : 130 SQ. FT.

DESIGN CRITERIA SUMMARY:

HYDRAULIC CALCULATIONS FOR RESTAURANT SERVING AREA BASED ON THE FOLLOWING:

OCCUPANCY: ORDINARY I
MINIMUM DESIGN DENSITY: 0.15 GPM/SQ. FT.
DESIGN AREA OF APPLICATION: 1500 SQ. FT.

OCCUPANCY: LIGHT
MINIMUM DESIGN DENSITY: 0.1 GPM/SQ. FT.
DESIGN AREA OF APPLICATION: 1500 SQ. FT.

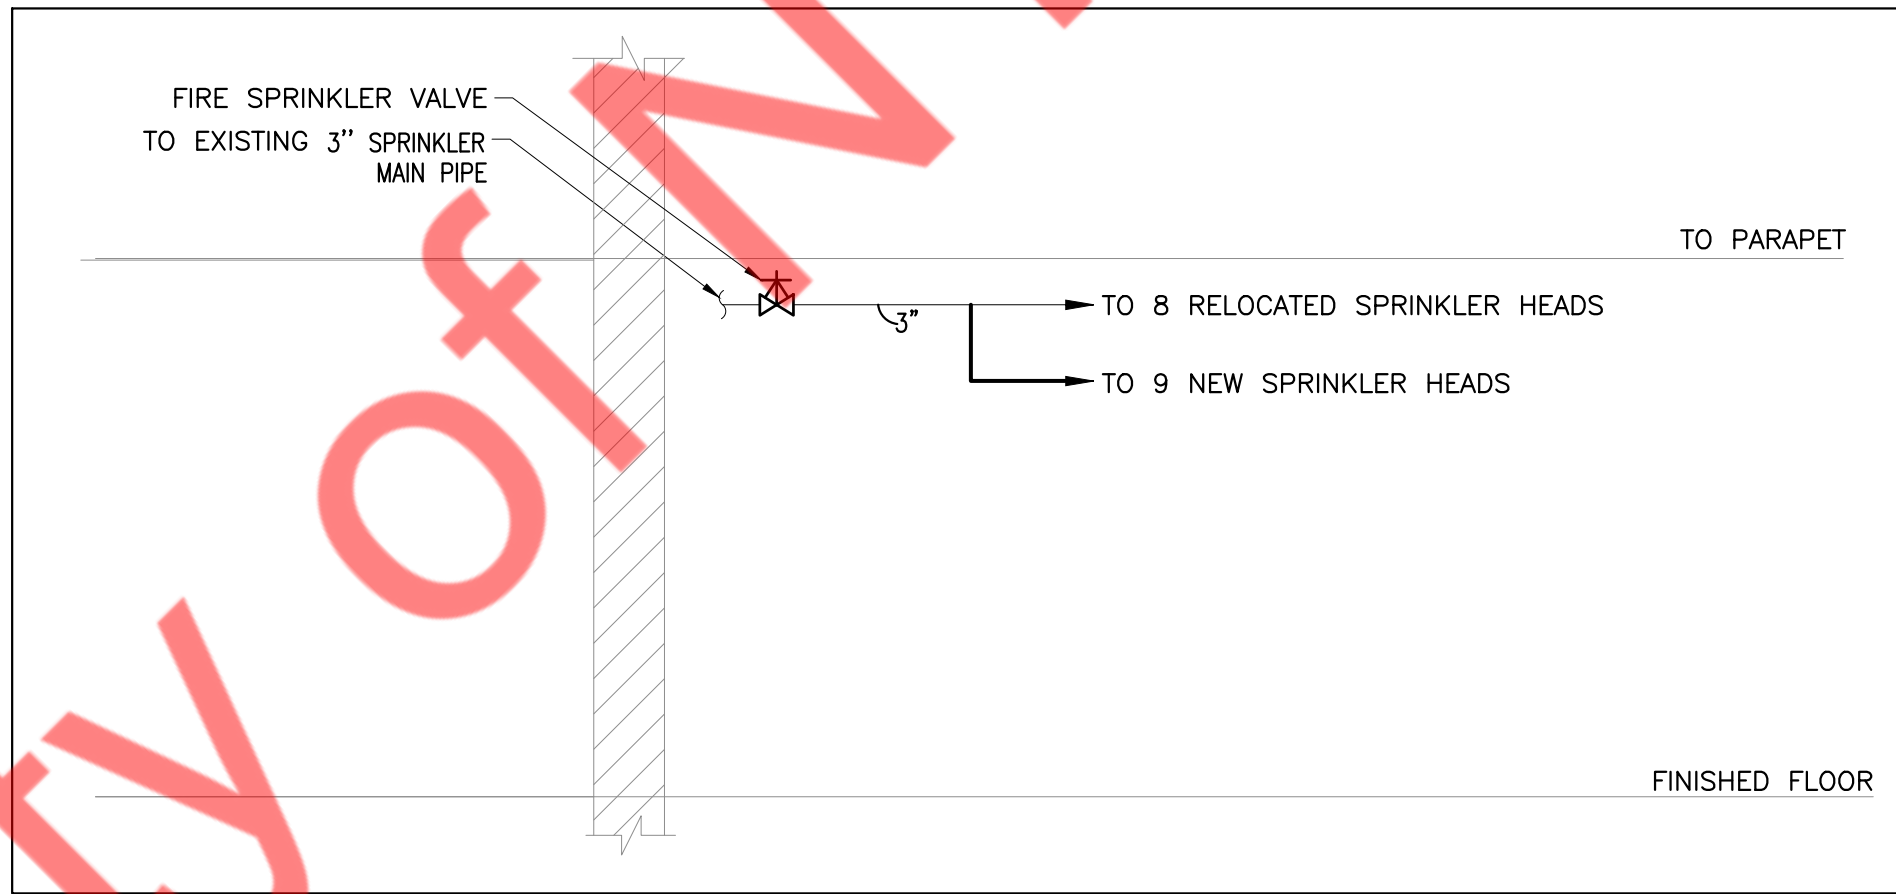
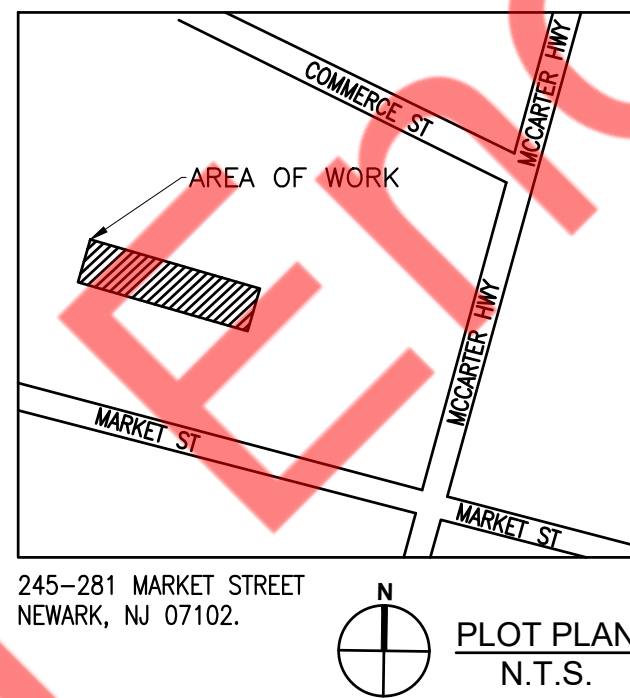
GENERAL NOTES:

- FOR SPRINKLER WORK ONLY.
- ALL SPRINKLER HEADS MEET DESIGN CRITERIA PER COVERAGE.

SPRINKLER LEGEND

- EX.SP — EXISTING SPRINKLER RISER PIPING TO REMAIN
— SP — NEW SPRINKLER PIPING
● (N) CONCEALED SPRINKLER HEAD (NEW)
○ (N) UPRIGHT SPRINKLER HEAD (NEW)
⌵ (REL) (N) DISCONNECT AND REMOVE EXISTING UPRIGHT SPRINKLER HEAD WITH BRANCH PIPING AND CAP (TYP.). CONNECT NEW UPRIGHT SPRINKLER HEAD WITH BRANCH PIPING AND EXTEND TO NEW LOCATION AS SHOWN ON FLOOR PLAN
⌵ SPRINKLER PIPE TO BE DEMOLISHED
┌ SPRINKLER CAPPED OUTLET
● SPRINKLER PIPING POINT OF CONNECTION
● SPRINKLER PIPING POINT OF DISCONNECTION
+ PIPE THRU RATED WALL
⌵ EXISTING SPRINKLER VALVE
● EXISTING DRAIN VALVE

KEY PLAN:



SPRINKLER RISER DIAGRAM

SPRINKLER SCHEDULE

SYMBOL	NAME	COVERAGE	AREA	METAL	TEMPERATURE (°F)	K-FACTOR	NPT	MFG	MODEL#	APPROVALS
●	CONCEALED	STANDARD	LH/OH AREAS WITH CEILING	BRASS	155	5.6	½"	TYCO	SERIES RF-II TY3531	UL
○	DRY CONCEALED	STANDARD	LH/OH OPEN AREAS	BRASS	155	5.6	¾"	TYCO	SERIES DS-C TY3535	UL
⊙	UPRIGHT	STANDARD	LH/OH OPEN AREAS	BRASS	155	5.6	½"	TYCO	SERIES TY-FRL TY3121	UL

- NOTE: 1. COORDINATE ALL SPRINKLER COLOR FINISHES WITH ARCHITECT.
2. ALL SPRINKLER SHOULD BE MEA APPROVED

SPRINKLER SPECIFICATIONS

PART 1 – GENERAL

1.01 REQUIREMENTS

- A. THE SPRINKLER CONTRACTOR SHALL BE A LICENSED, AUTHORIZED INSTALLER OF SPRINKLER SYSTEMS AND SHALL HAVE HAD A MINIMUM OF FIVE YEARS EXPERIENCE IN THE INSTALLATION OF SPRINKLER SYSTEMS IN THE CITY OF NEWARK, NJ.
- B. BEFORE SUBMITTING HIS BID, THE SPRINKLER CONTRACTOR SHALL VISIT THE SITE AND SHALL FULLY FAMILIARIZE HIMSELF WITH, AND BECOME FAMILIAR WITH THE DIFFICULTIES THAT WILL ATTEND THE EXECUTION OF THIS WORK. CONTRACTOR SHALL PERFORM THIS PRIOR TO SUBMITTING HIS PROPOSAL. SUBMISSION OF A PROPOSAL WILL BE CONSTRUED AS EVIDENCE THAT SUCH AN EXAMINATION HAS BEEN MADE, AND LATER CLAIMS WILL NOT BE RECOGNIZED FOR EXTRA LABOR, EQUIPMENT OR MATERIALS REQUIRED BECAUSE OF DIFFICULTIES ENCOUNTERED WHICH COULD HAVE BEEN FORESEEN HAD SUCH AN EXAMINATION BEEN MADE.
- C. UPON REVIEW OF THE DRAWINGS AND SPECIFICATIONS, PRIOR TO SUBMITTING HIS PROPOSAL, THE SPRINKLER CONTRACTOR SHALL INFORM ARCHITECT AND/OR ENGINEER OF ANY DISCREPANCIES OR REQUEST CLARIFICATION IN WRITING, IF NECESSARY, CONCERNING THE INTENT OF THE PLANS AND SPECIFICATIONS TO PROVIDE A COMPLETE SPRINKLER SYSTEM INSTALLATION. LATER CLAIMS WILL NOT BE RECOGNIZED FOR EXTRA LABOR, EQUIPMENT OF MATERIALS SHOULD SUCH PROCEDURE NOT BE FOLLOWED.
- D. THE SCHEDULING OF THE SPRINKLER WORK SHALL BE COORDINATED WITH BUILDING MANAGEMENT, WITH OTHER CONTRACTORS AND WITH THE ENGINEER.
- E. NECESSARY SHUT-DOWNS OF BASE BUILDING SPRINKLER SYSTEM MUST BE COORDINATED WITH BUILDING MANAGEMENT. SHUT-DOWNS OF BASE BUILDING SYSTEMS SHALL TAKE PLACE AFTER OR BEFORE NORMAL BUSINESS HOURS AND SHALL BE CONSIDERED OVERTIME WORK. THE CONTRACTOR MUST GIVE BUILDING MANAGEMENT AND CITY OF NEWARK FIRE DEPARTMENT 48 HOURS NOTICE PRIOR TO SHUT-DOWN OF SPRINKLER, OR OTHER SYSTEMS.

1.02 WORK INCLUDED

- A. WORK SHALL INCLUDE ALL SPRINKLER WORK FURNISHED AND INSTALLED AS INDICATED ON THE PLANS AND AS SPECIFIED HEREIN.
1. ALL WORK SHALL COMPLY WITH REQUIREMENTS OF THE 2018 INTERNATIONAL BUILDING CODE NEW JERSEY EDITION, N.F.P.A. STANDARD 13-2016, INTERNATIONAL FIRE CODE 2015, CITY OF NEWARK FIRE DEPARTMENT AND OWNERS INSURANCE RATING ORGANIZATION.
2. THESE DRAWINGS ARE DIAGRAMMATIC AND INDICATE THE GENERAL LOCATION OF WORK. SCALED DIMENSIONS SHALL NOT BE USED. ANY DIMENSIONS NOT SHOWN SHALL BE OBTAINED FROM FIELD MEASUREMENTS.
3. PROVIDE COMPUTER GENERATED HYDRAULIC CALCULATIONS IN ACCORDANCE WITH CITY OF NEWARK BUILDING DEPARTMENT AND NFPA STANDARDS.

1.03 SHOP DRAWINGS AND SUBMITTALS

- A. THE CONTRACTOR SHALL SUBMIT, FOR APPROVAL, FULLY COORDINATED SHOP DRAWINGS, CAPACITY, DATA, AND CATALOG CUTS OF THE FOLLOWING:
1. PIPE AND FITTINGS
2. VALVES
3. HANGERS AND SUPPORTS
4. SPRINKLER PIPING LAYOUT
5. TESTS
6. SPRINKLER HEADS
7. HYDRAULIC CALCULATIONS
8. SIAMESE CONNECTION
- A. THE SPRINKLER SYSTEM SHALL BE HYDRAULICALLY DESIGNED. CONTRACTOR SHALL SUBMIT CALCULATIONS WITH SHOP DRAWINGS. CALCULATIONS SHALL BE PERFORMED IN ACCORDANCE WITH REQUIREMENTS OF NFPA 13-2016, INTERNATIONAL FIRE CODE 2015 AND 2018 INTERNATIONAL BUILDING CODE NEW JERSEY EDITION.

1.04 BUILDING DEPARTMENT FILING, PERMITS AND CERTIFICATES

- A. THE SPRINKLER CONTRACTOR SHALL FILE ALL REQUIRED DRAWINGS AND HYDRAULIC CALCULATIONS WITH THE BUILDING DEPARTMENT AND BE RESPONSIBLE FOR OBTAINING FINAL APPROVAL.
- B. ARRANGE FOR INSPECTION AND TESTS OF ANY AND ALL PARTS OF THE WORK AS REQUIRED BY AUTHORITIES HAVING JURISDICTION AND PAY ALL CHARGES FOR SAME.

1.05 INSPECTION AND TESTING

- A. THE SPRINKLER SYSTEM SHALL BE INSPECTED AND TESTED IN ACCORDANCE WITH THE REQUIREMENTS OF THE 2018 INTERNATIONAL BUILDING CODE NEW JERSEY EDITION FIRE DEPARTMENT INSPECTOR.
- B. THE SPRINKLER SYSTEM SHALL BE SUBJECTED TO A HYDROSTATIC PRESSURE TEST FOR A PERIOD OF TWO HOURS AT A PRESSURE OF AT LEAST 200 PSIG OR 50 PSI IN EXCESS OF THE MAXIMUM PRESSURE TO BE MAINTAINED WHEN THE MAXIMUM PRESSURE IN THE SYSTEM IS IN EXCESS OF 150 PSI AS PER NFPA.
- C. THE BUILDING DEPARTMENT SHALL BE NOTIFIED THAT THE SYSTEM IS READY FOR REINSPECTION AND TESTING. THE BUILDING DEPARTMENT INSPECTOR SHALL WITNESS THE TEST. FINAL APPROVAL OF THE SPRINKLER SYSTEM SHALL BE OBTAINED FROM BUILDING DEPARTMENT, AND FIRE DEPARTMENT.

PART 2 – MATERIALS

2.01 GENERAL

- A. THE SPRINKLER SYSTEM SHALL BE COMPLETE WITH ALL PIPE, FITTINGS, VALVES, DRAINAGE SYSTEM AND VALVES, HANGERS AND SUPPORTS. ALSO, MISCELLANEOUS WORK ITEMS, SUCH AS SIGNS AS REQUIRED, VALVE TAGS, ETC., AND ALL OTHER RELATED EQUIPMENT, APPARATUS AND MATERIAL ITEMS NECESSARY FOR COMPLETE, APPROVED TYPE SYSTEM, READY FOR FUTURE EXTENSION.
- B. ALL PIPE, FITTINGS, HANGERS, SUPPORTS, SPRINKLER HEADS, ETC., SHALL CONFORM TO THE 2018 INTERNATIONAL BUILDING CODE AND NATIONAL FIRE PROTECTION ASSOCIATION'S REQUIREMENTS AS TO TYPES OF MATERIALS, ARRANGEMENT, SIZES AND INSTALLATION. PIPING PENETRATING FIRE RATED

PARTITIONS SHALL HAVE OPENING SEALED WITH U.L. APPROVED FIREPROOF SEALANT.

2.02 SPRINKLER PIPING

- A. ALL SPRINKLER PIPING SHALL BE SCHEDULE 40, IN ACCORDANCE WITH NFPA 13-2016. PIPE SHALL BE UL/FM APPROVED.
- B. STEEL PIPE SHALL BE BETHLEHEM STEEL CO., ALLIED TUBE, BERGER INDUSTRIES OR APPROVED.
- C. AS PER NFPA 13-2016 PIPE OR TUBE USED IN SPRINKLER SYSTEMS SHALL BE OF THE MATERIALS SPECIFIED IN TABLE 6.3.1.1 OR SHALL BE IN ACCORDANCE WITH 6.3.1.1.
- D. AS PER NFPA 13-2016, FITTINGS USED IN SPRINKLER SYSTEMS SHALL BE OF THE MATERIALS LISTED IN TABLE 6.4.1 OR SHALL BE IN ACCORDANCE WITH 6.4.1. FITTING SHALL BE UL/FM APPROVED. CONTRACTOR.

2.03 CUTTING AND PATCHING

DO ALL CUTTING AND CORE DRILLING NECESSARY FOR THE INSTALLATION OF SPRINKLER WORK, ACCURATELY LAYOUT WORK FOR WHICH CUTTING IS REQUIRED. PATCH AND RESTORE ANY DAMAGE WORK TO LIKE NEW CONDITION.

2.04 CUTTING AND PATCHING

1. DO ALL CUTTING AND CORE DRILLING NECESSARY FOR THE INSTALLATION OF SPRINKLER WORK. ACCURATELY LAYOUT WORK FOR WHICH CUTTING IS REQUIRED. PATCH AND RESTORE ANY DAMAGE WORK TO LIKE NEW CONDITION.
2. FOR REPLACEMENT OF THE WORK REMOVED, MATCH EXISTING IN NATURE, CONSTRUCTION AND FINISH.
3. MAINTAIN THE PREMISES FREE FROM ACCUMULATION OF WASTE MATERIAL OR RUBBISH COVERED BY THE WORK, REMOVE ALL SURPLUS MATERIALS, TOOLS ETC. AND LEAVE PREMISES CLEAN.

2.05 FIRE STOPPING

INSTALLATION SHALL BE IN STRICT ACCORDANCE WITH THE MANUFACTURERS PUBLISHED DIRECTIONS AND PER FIRE TESTED DESIGNS THAT HAVE BEEN ACCEPTED BY THE APPROPRIATE CODE AUTHORITY HAVING JURISDICTION.

2.06 PHASING

PHASING SHALL BE COORDINATED BETWEEN THE SPRINKLER CONTRACTOR AND GENERAL CONTRACTOR. SPRINKLER INSTALLATION SHALL BE PHASED IN A MANNER WHICH WILL ALLOW FULL OCCUPANCY OF THE EXISTING FACILITY WHILE THE INSTALLATION IS IN PROGRESS.

2.06 ALTERNATES/SUBSTITUTIONS

CONTRACTOR SHALL STATE IN THEIR PROPOSAL ANY CONTRACTOR PROPOSED SUBSTITUTIONS OF THE MATERIALS OR METHODS OF INSTALLATION FROM THAT SPECIFIED. THESE ALTERATIONS SHALL BE LISTED ON THE PROPOSAL AS CONTRACTOR ALTERNATIVE.

2.07 LEAK DAMAGE

THE SPRINKLER CONTRACTOR SHALL BE RESPONSIBLE DURING THE INSTALLATION AND TESTING PERIODS OF THE SPRINKLER SYSTEM FOR ANY LOSS OR DAMAGE TO THE WORK OF OTHERS, TO THE BUILDING, IT'S CONTENTS ETC. CAUSED BY LEAKS IN THE EQUIPMENT. BY UNPLUGGED OR DISCONNECTED PIPES, FITTINGS ETC. OR BY OVERFLOW, AND SHALL PAY FOR THE NECESSARY REPLACEMENTS OR REPAIRS TO THE WORK OF OTHERS, DAMAGED BY SUCH LEAKAGE.

2.08 INSERTS, HANGERS, ETC.

- A. ALL SPRINKLER PIPING SHALL BE SUBSTANTIALLY SUPPORTED AND SHALL COMPLY WITH THE STANDARDS FOR THE NATIONAL FIRE PROTECTION ASSOCIATION FOR THE INSTALLATION OF SPRINKLER SYSTEMS AND AS REQUIRED BY THE 2018 INTERNATIONAL BUILDING CODE NEW JERSEY EDITION.
- B. HANGERS AND THEIR COMPONENTS SHALL BE FERROUS. HANGERS SHALL BE ADJUSTABLE FLAT IRON TYPE OF CLEVIS TYPE.

- C. SPRINKLER PIPING OR HANGERS SHALL NOT BE USED TO SUPPORT NON-SYSTEM COMPONENTS.

- D. SPRINKLER PIPING SHALL BE SUBSTANTIALLY SUPPORTED FROM THE BUILDING STRUCTURE WHICH MUST SUPPORT THE ADDED LOAD OF THE WATER-FILLED PIPE PLUS A MINIMUM OF 250 LBS. APPLIED AT THE POINT OF HANGING. CONTRACTOR SHALL SUBMIT DETAIL OF SUPPORT FOR REVIEW AND APPROVAL.

- E. SPRINKLER PIPING SHALL BE SUPPORTED INDEPENDENTLY OF THE CEILING SHEATHING.

- F. WHEN SPRINKLER PIPING IS INSTALLED BELOW DUCTWORK, PIPING SHALL BE SUBSTANTIALLY SUPPORTED FROM THE BUILDING STRUCTURE, NOT FROM THE DUCTWORK.

- G. MAXIMUM DISTANCE BETWEEN HANGERS SHALL NOT EXCEED 12 FT. FOR 1 AND 1-1/4" SIZES NOR 15' FOR SIZES 1-1/2" AND LARGER.

- H. EXPANSION SHIELDS FOR SUPPORTING PIPES UNDER CONCRETE CONSTRUCTION MAYBE USED IN A HORIZONTAL POSITION IN THE SIDES OF BEAMS, IN CONCRETE HAVING GRAVEL OR AGGREGATE. EXPANSION SHIELDS MAY BE USED IN THE VERTICAL POSITION TO SUPPORT PIPES 4" OR LESS IN DIAMETER.

2.09 ESCUTCHEONS

PROVIDE ESCUTCHEONS ON ALL EXPOSED PIPING PASSING THROUGH WALLS, PARTITIONS, FLOORS AND CEILINGS. ESCUTCHEON SHALL BE HELD IN PLACE BY INTERNAL TENSION OR SET SCREW.

2.10 AS-BUILT DRAWINGS

PREPARE AND SUBMIT "AS BUILT" DRAWINGS AT THE COMPLETION OF THE

PROJECT.

2.11 SPRINKLER HEADS

- A. SPRINKLERS SHALL BE RATED FOR ORDINARY TEMPERATURES (135/165 DEG. F) EXCEPT AS REQUIRED NEAR HEATERS OR LOCATIONS WHERE ELEVATED TEMPERATURES MAY NORMALLY BE EXPECTED OR AS OTHERWISE INDICATED ON THE CONTRACT DRAWINGS.
- B. SPRINKLER HEADS SHALL BE BY TYCO SPRINKLER CO., INC. MANUFACTURE OR APPROVED EQUAL, UL AND FM APPROVED, AS FOLLOWS:
1. SPRINKLER HEADS IN FINISHED CEILINGS WITH CONCEALED PIPING SHALL BE AUTOMATIC TYCO MODEL TY3531.
2. SPRINKLER HEADS IN OPEN CEILING AREA SHALL BE AUTOMATIC TYCO MODEL TY3121.
3. PROVIDE SPARE SPRINKLER EMERGENCY CABINETS CONFORMING TO NFPA.
4. SPRINKLER EMERGENCY CABINETS SHALL BE OF TYCO SPRINKLER CO., INC. OR APPROVED EQUAL, UL AND FM APPROVED.
5. CABINET SHALL BE CONSTRUCTED OF 22 GAUGE STEEL WITH PRIME COAT AND MANUFACTURER'S BAKED ENAMEL FINISH IN COLOR SELECTED BY THE ARCHITECT.
6. CABINET SHALL CONTAIN A MINIMUM OF 6 SPRINKLER HEADS OF EACH TYPE EMPLOYED.

2.12 PRESSURE GAUGE

- A. ASHCROFT SERIES 1079, OR APPROVED OTHER, 4--1/2" DIAMETER, 0-200 P.S.I. RANGE, 20 P.S.I. INTERVALS.

PART 3 – EXECUTION

3.01 GUARANTEE

- A. GUARANTEE FOR A PERIOD OF ONE (1) YEAR FROM THE DATE OF ACCEPTANCE BY THE OWNER. ALL MATERIALS, APPARATUS AND WORKMANSHIP WHETHER FURNISHED BY HIMSELF OR BY HIS SUBCONTRACTORS AND HE SHALL REPLACE OR REPAIR IN A MANNER APPROVED BY THE ARCHITECTS, WITHOUT COST TO THE OWNER, ANY PART OR PARTS OF THE WORK WHICH MAY PROVE DEFECTIVE OR UNSATISFACTORY WITH IN THE PERIOD OF THE GUARANTEE.

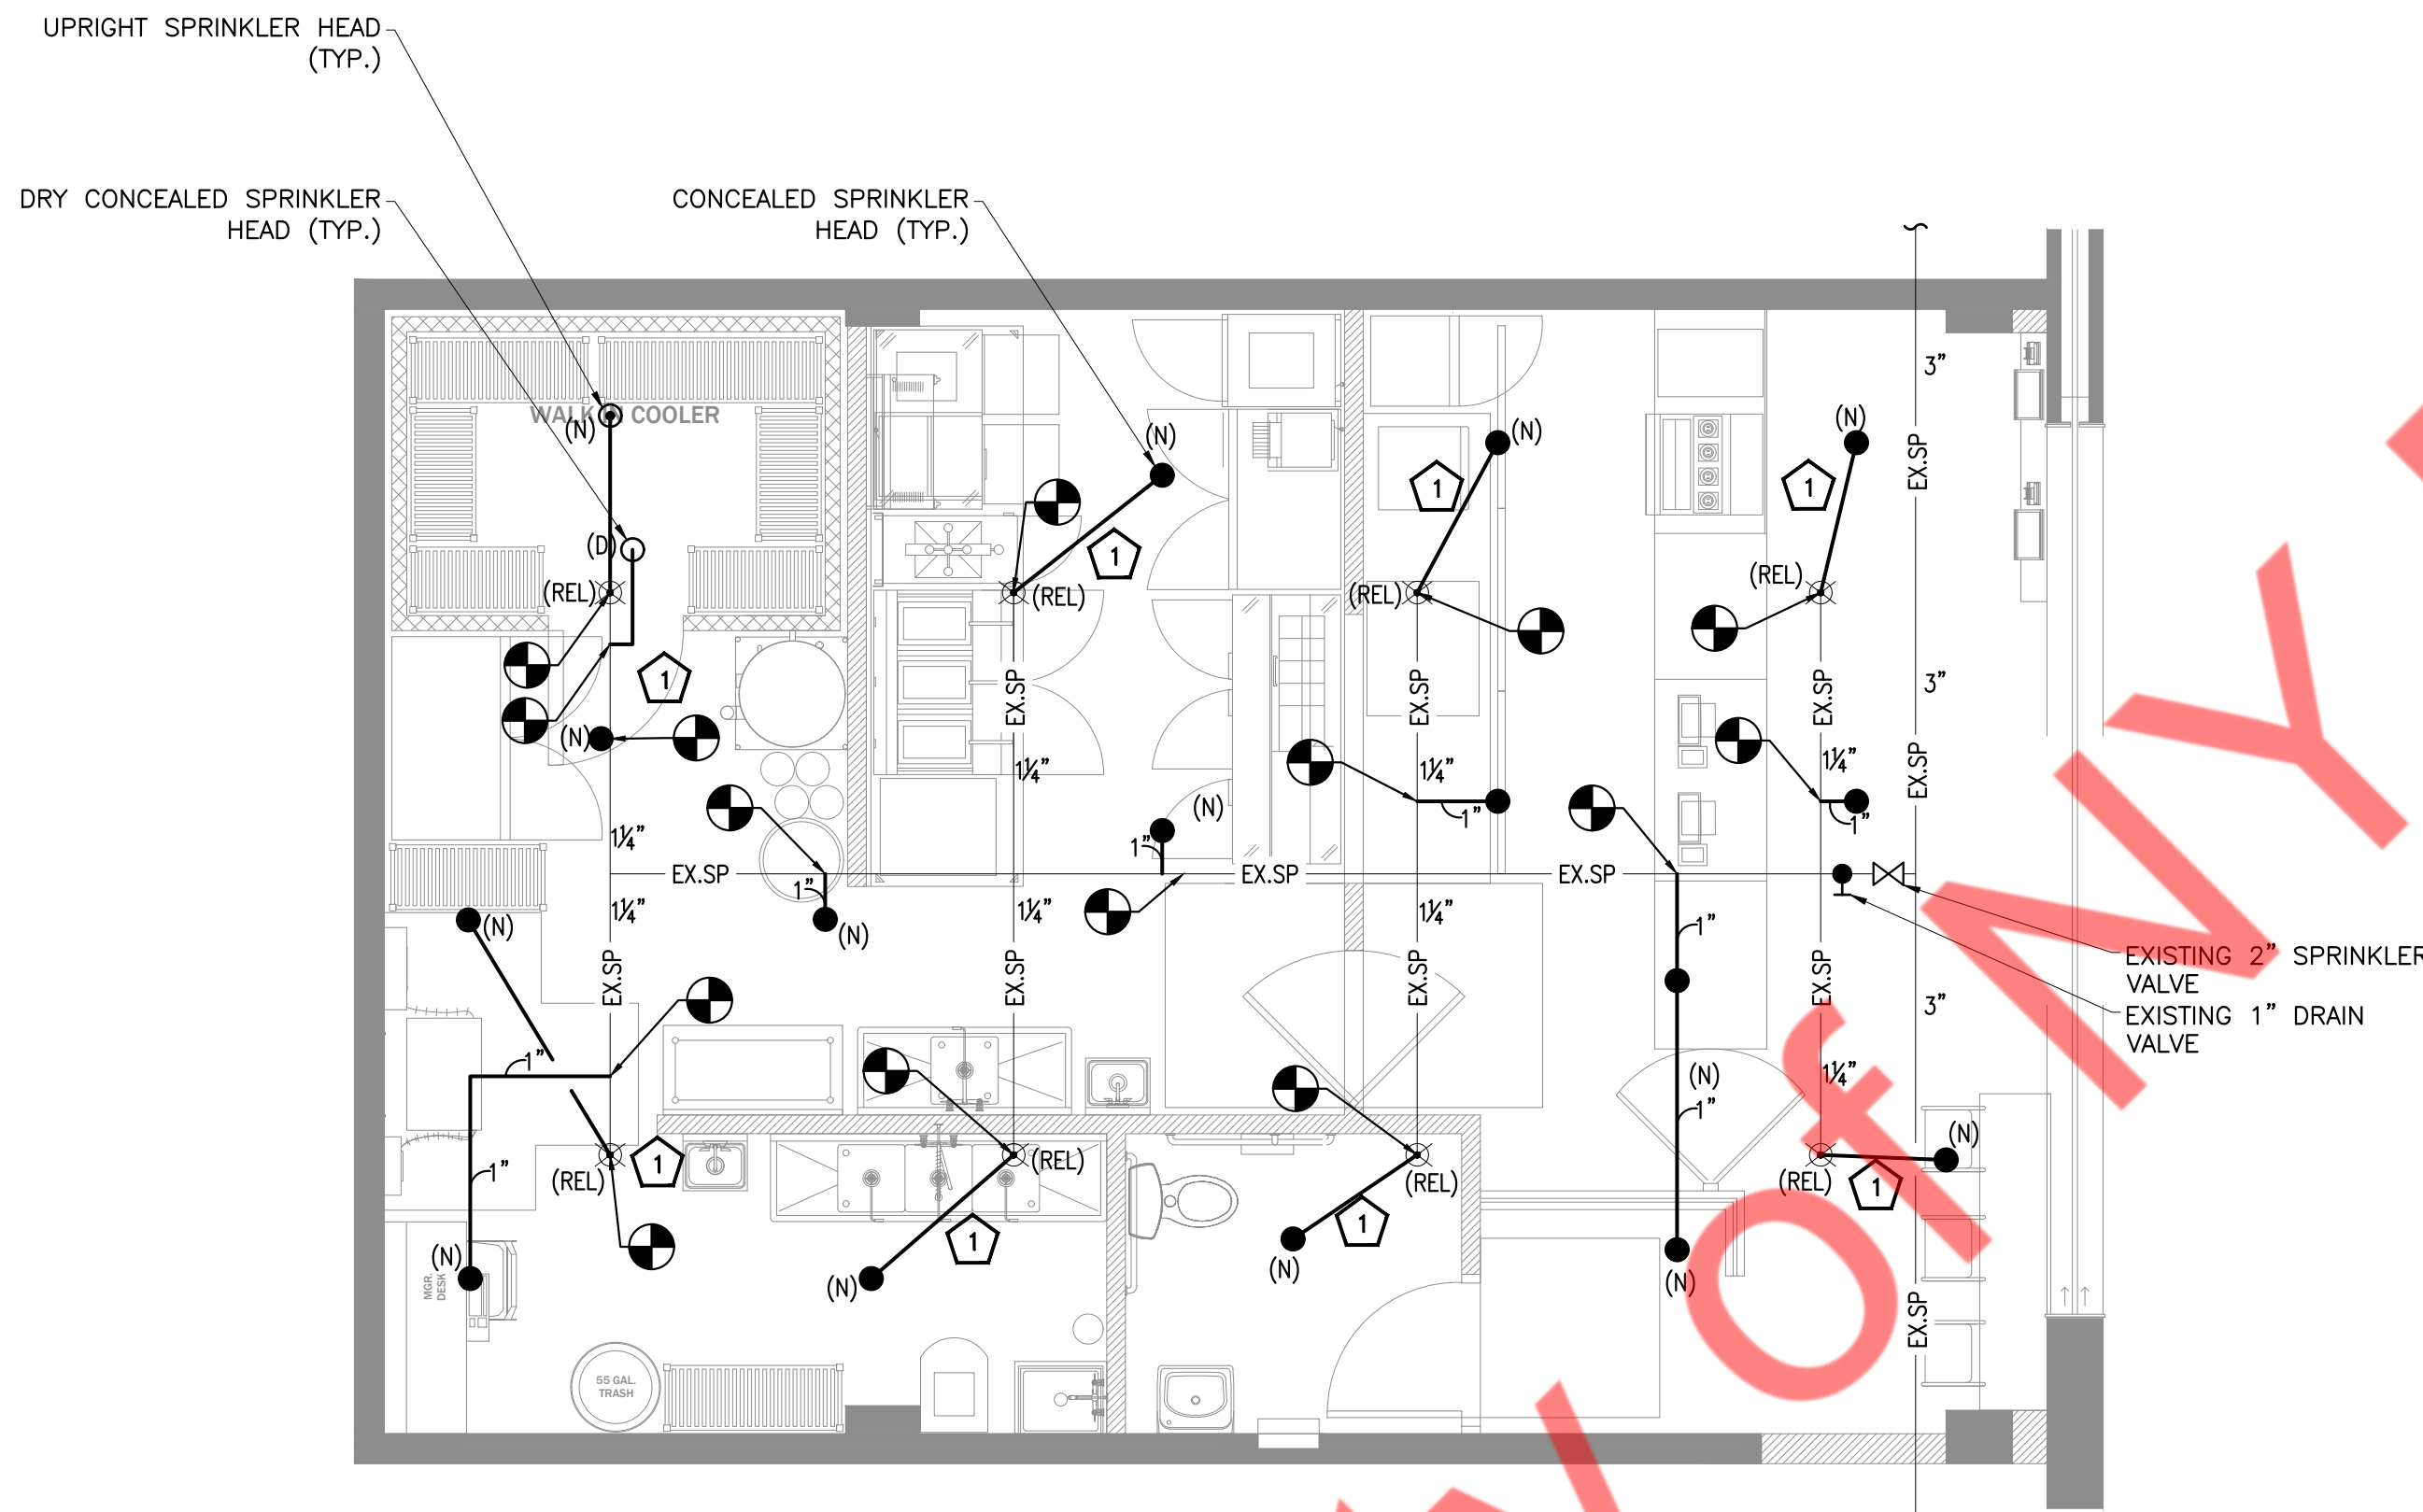
3.02 INSTALLATION

A. PIPING

1. INSTALL PIPING AS SHOWN ON THE CONTRACT DRAWINGS AND STRAIGHT AND DIRECT AS POSSIBLE, FORMING RIGHT ANGLES OR PARALLEL LINES WITH BUILDING WALLS, NEATLY SPACED, WITH RISERS PLUMB AND TRUE.
2. SPRINKLER PIPING SHALL BE INSTALLED SO THAT THE SYSTEM CAN BE DRAINED.
3. PIPE SHALL BE REMOVED BY REAMING.
4. BEFORE INSTALLING PIPE, THOROUGHLY CLEAN THE INSIDE FREE OF CUTTING AND FOREIGN MATTER. CUT ALL PIPE SQUARE AND SMOOTH AND MAKE UP ALL JOINTS TO REQUIRED LIMITS.

B. PIPE JOINTS

1. THREADED JOINTS SHALL BE MADE UP OF TIGHT USING PIPE JOINT TEFLON COMPOUND OR TAPE, APPLIED ON THE MALE THREADS ONLY.



1 SPRINKLER FLOOR PLAN - CONOURSE LEVEL
1/4\"=1'-0\"

GENERAL NOTES:

1. CONTRACTOR TO FIELD VERIFY TO INSTALL ALL SPRINKLER HEADS TO BE MAX. 12\" FROM CEILING.
2. ALL NEW SPRINKLER HEADS LOCATION TO BE COORDINATED WITH LIGHTING AND DIFFUSERS TO AVOID CONFLICT.
3. ALL SPRINKLER HEADS & PIPING TO BE COORDINATED WITH EXISTING & NEW SERVICES.
4. ANY WORK SHOWN ON THE DRAWINGS AND NOT PARTICULARLY DESCRIBED IN THE SPECIFICATIONS OR DETAILS, OR ANY WORK WHICH MAY BE DEEMED NECESSARY TO COMPLETE THE CONTRACT SHALL BE PROVIDED BY THE CONTRACTOR AS PART OF THIS CONTRACT.
5. FOR PURPOSES OF CLEARNESS AND LEGIBILITY, SPRINKLER DRAWINGS ARE ESSENTIALLY DIAGRAMMATIC AND SIZE AND LOCATION OF EQUIPMENT ARE DRAWN TO SCALE WHEREVER POSSIBLE. THE DRAWINGS INDICATE SIZE, CONNECTION POINTS, AND ROUTED OFF PIPES. IT IS NOT INTENDED, HOWEVER, THAT ALL OFFSETS, RISES AND DROPS ARE SHOWN. PROVIDE PIPING AS REQUIRED TO FIT STRUCTURE, AVOID OBSTRUCTIONS, AND RETAIN CLEARANCES, HEADROOM OPENINGS AND PASSAGEWAYS. ALL SPRINKLER PIPING AT CEILING SHALL BE ROUTED TIGHT TO EXISTING SLAB AS REQUIRED.
6. CONTRACTOR TO FIELD VERIFY FEASIBILITY OF SLAB PENETRATION IF REQUIRED AS PER STRUCTURAL REQUIREMENT.
7. ALL SPRINKLER HEADS & PIPING TO BE COORDINATED WITH EXISTING & NEW SERVICES.
8. CONTRACTOR TO FIELD VERIFY EXACT LOCATION AND SIZE OF EXISTING SYSTEM AND RELOCATE HEADS WHEREVER SHOWN.
9. ALL PENDANT SPRINKLERS MUST BE SPACED AS FOLLOWS -
 1. MAXIMUM 7.5' FROM WALL
 2. MAXIMUM DISTANCE BETWEEN 2 SPRINKLER HEADS IS 15'.
 3. MINIMUM DISTANCE BETWEEN 2 SPRINKLER HEADS IS 6'.
 4. COVERAGE AREA PER SPRINKLER SHALL BE MAX. 150 SQ.FT.
10. ALL SPRINKLER HEADS MEET DESIGN CRITERIA PER COVERAGE.
11. AUXILIARY DRAIN SHALL BE PROVIDED AT THE TRAPPED SECTIONS.
12. ALL EXISTING SPRINKLER SYSTEM AT THIS FLOOR TO BE DEMOLISHED UNLESS OTHERWISE NOTED.
13. FOR SPRINKLER WORK ONLY.

SPRINKLER KEYNOTES

- 1 ALL BRANCH TAKE-OFF FOR EACH SPRINKLER TO BE MIN. 1\".

SPRINKLERS	
EXISTING UPRIGHT HEADS TO BE RELOCATED	08
NEW CONCEALED HEAD	08
NEW DRY CONCEALED HEAD	01
TOTAL	17

HAZARD CLASSIFICATION AND DESIGN DENSITY:	
AREA : KITCHEN AREA	
OCCUPANCY:	ORDINARY HAZARD
MINIMUM DESIGN DENSITY:	0.15 GPM/SQ. FT.
AREA : HALL AREA	
OCCUPANCY:	LIGHT HAZARD
MINIMUM DESIGN DENSITY:	0.1 GPM/SQ. FT.

