 
 
 
 
 
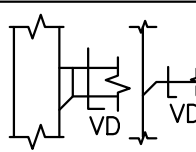
 
 
 


MECHANICAL SYMBOLS LIST			MECHANICAL ABBREVIATIONS	
CONTROLS AND SENSORS			RTU	ROOF TOP UNIT
	EQUIPMENT SYMBOL		ACCU	CONDENSING UNIT
	RISER SYMBOL		AFF	ABOVE FINISHED FLOOR
	POINT OF NEW CONNECTION TO EXISTING		AL	ACOUSTIC LINING
AIR DEVICES			CDE	CEILING DIFFUSER EXHAUST
	CEILING DIFFUSER SUPPLY		CDS	CEILING DIFFUSER SUPPLY
	CEILING DIFFUSER RETURN		CDR	CEILING DIFFUSER RETURN
	SIDEWALL/DUCT MOUNTED GRILLE-SUPPLY		CFM	CUBIC FEET OF AIR PER MINUTE
	SIDEWALL/DUCT MOUNTED GRILLE-RETURN	DUCTWORK		
DUCT ACCESSORIES			COP	COEFFICIENT OF PERFORMANCE
	GRAVITY DAMPER		CP	CONDENSATE PUMP
	VOLUME DAMPER W/ ACCESS DOOR		DN	DOWN
	MOTORIZED DAMPER W/ ACCESS DOOR		EER	ENERGY EFFICIENCY RATIO
HVAC PIPING			EN	ENERGY ANALYSIS
	NEW CONDENSATE PIPING		FC	FLEXIBLE CONNECTION
	NEW REFRIGERANT PIPING		FD/AD	FIRE DAMPER W/ACCESS DOOR
	FLUID FLOW DIRECTION		GXF	GENERAL EXHAUST FAN
	PIPE TURNING DOWN		HSPF	HEATING SEASONAL PERFORMANCE FACTOR
	PIPE GOING UP		IEER	INTEGRATED ENERGY EFFICIENCY RATIO

MECHANICAL DRAWING LIST	
M0.1	MECHANICAL SYMBOL, DRAWING LIST, ABBREVIATION & NOTES
M0.2	GENERAL HVAC NOTES & MECHANICAL SPECIFICATIONS
M0.3	MECHANICAL SPECIFICATIONS
M1.0	MECHANICAL FLOOR PLAN
M1.1	MECHANICAL ROOF PLAN
M5.1	MECHANICAL DETAILS (1 OF 3)
M5.2	MECHANICAL DETAILS (2 OF 3)
M5.3	MECHANICAL DETAILS (3 OF 3)
M6.0	MECHANICAL EQUIPMENT SCHEDULE
M7.1	HOOD, MAKE-UP AIR UNIT & DOAS DETAILS (1 OF 3)
M7.2	HOOD, MAKE-UP AIR UNIT & DOAS DETAILS (2 OF 3)
M7.3	HOOD, MAKE-UP AIR UNIT & DOAS DETAILS (3 OF 3)

FIELD VERIFY ALL CONDITIONS
• DESIGN DRAWINGS ARE SCHEMATIC. THIS CONTRACTOR SHALL VISIT THE SITE PRIOR TO BIDDING OR AWARD OF CONTRACT TO INSPECT EXISTING FIELD CONDITIONS. THIS CONTRACT SHALL INCLUDE ALL LABOR AND MATERIALS NECESSARY FOR FIELD MODIFICATIONS DUE TO EXISTING CONDITIONS.
• THE CONTRACTOR SHALL CONTACT THE ARCHITECT, ENGINEER OR OWNER PRIOR TO BIDDING FOR INTERPRETATIONS AND CLARIFICATIONS OF THE DESIGN AND INCLUDE IN HIS BID ALL COSTS TO MEET THE DESIGN INTENT. CLARIFICATIONS MADE BY THE ARCHITECT, ENGINEER OR OWNER AFTER BIDDING WILL BE FINAL AND SHALL BE IMPLEMENTED AT CONTRACTORS COST.
• BIDDING CONTRACTORS SHALL HAVE A WORKING KNOWLEDGE OF LOCAL CODES AND ORDINANCES AND SHALL INCLUDE IN THEIR BIDS THE COSTS FOR ALL WORK INSTALLED IN STRICT ACCORDANCE WITH GOVERNING CODES. THE PLANS AND SPECIFICATIONS NOT WITHSTANDING, THE CONTRACTOR SHALL ALERT ARCHITECT, ENGINEER OR OWNER OF ANY APPARENT DISCREPANCIES BETWEEN GOVERNING CODES AND DESIGN INTENT.

CHICAGO BUILDING DEPARTMENT NOTES	
ALL WORK SHALL COMPLY WITH APPLICABLE SECTIONS OF CHICAGO BUILDING CODE 2018 AND ALL AMENDMENTS AND RULES AND REGULATIONS OF THE DEPARTMENT OF BUILDINGS TO DATE.	
1. THE CONTRACTOR SHALL ENGAGE THE THE SERVICES OF A PROFESSIONAL ENGINEER TO PROVIDE THE REQUIRED SPECIAL INSPECTIONS AND TESTS.	
2. THE LICENSED PROFESSIONAL ENGINEER, ARCHITECT OR OTHER PERSON HAVING NOT LESS THAN FIVE (5) YEARS EXPERIENCE SUPERVISING THE INSTALLATION OF SUCH MECHANICAL SYSTEMS AND CONDUCTING SUCH TESTS WILL FILE DOCUMENTATION AND REPORTS OF TESTS THAT THE SYSTEM COMPLIES WITH THE CONSTRUCTION DOCUMENTS AND APPLICABLE LAWS.	
3. TESTS OF MECHANICAL SYSTEMS SHALL BE PERFORMED IN ACCORDANCE WITH THE FOLLOWING SECTIONS OF THE INTERIM CHICAGO MECHANICAL CODE (TITLE 14M): A. REFRIGERATION SYSTEMS – MC 18-28-1108	
4. THE FOLLOWING WORK ITEMS, COMPONENTS, MATERIALS, CAPACITIES, ETC. SHALL COMPLY WITH THE REFERENCED CODE OR STANDARD: A. DUCT CONSTRUCTION AND INSTALLATION- 18-28-601. B. AIR INTAKES, EXHAUSTS AND RELIEFS – MC 18-28-401.5 C. GAS FIRED EQUIPMENT – INTERIM CHICAGO FUEL GAS CODE	
5. MINIMUM TEMPERATURE TO BE MAINTAINED IN OCCUPIED SPACES DURING HEATING SEASON: 68 DEG. FAHRENHEIT.	
6. A STATEMENT SHALL BE FILED BY THE OWNER OR TENANT IN POSSESSION THAT THE VENTILATION SYSTEM WILL BE KEPT IN CONTINUOUS OPERATION AT ALL TIMES DURING THE NORMAL OCCUPANCY OF THE STRUCTURE AS REQUIRED BY MC 18-28-401.	
7. THESE PLANS ARE APPROVED ONLY FOR THE WORK INDICATED ON THE APPLICATION SPECIFICATION SHEET. ALL OTHER MATTERS SHOWN ARE NOT TO BE RELIED UPON OR TO BE CONSIDERED AS EITHER BEING APPROVED OR IN ACCORDANCE WITH APPLICABLE CODES.	
8. MECHANICAL SYSTEMS SHALL BE COMMISSIONED PER IECC 2018 C403.2.2, C408.2.1, C408.2.5 FINAL COMMISSIONING REPORT SHALL BE DUE WITHIN 90 DAYS OF RECEIPT OF CERTIFICATE OF OCCUPANCY.	
9. A COMMISSIONING PLAN SHALL BE DEVELOPED BY A LICENSED DESIGN PROFESSIONAL, MECHANICAL ENGINEER OR APPROVED AGENCY.	
10. A PRELIMINARY REPORT OF COMMISSIONING TEST PROCEDURES AND RESULTS SHALL BE COMPLETED AND CERTIFIED BY THE LICENSED DESIGN PROFESSIONAL, ELECTRICAL ENGINEER, MECHANICAL ENGINEER OR APPROVED AGENCY AND PROVIDED TO THE BUILDING OWNER OR OWNER'S AUTHORIZED AGENT AS PER IECC 2018 C408.2.4.	

11. A FINAL REPORT OF TEST PROCEDURES AND RESULTS IDENTIFIED AS "FINAL COMMISSIONING REPORT" SHALL BE DELIVERED TO THE BUILDING OWNER OR OWNER'S AUTHORIZED AGENT. THE REPORT SHALL BE ORGANIZED WITH MECHANICAL SYSTEM AND SERVICE HOT WATER SYSTEM FINDINGS IN SEPARATE SECTIONS TO ALLOW INDEPENDENT REVIEW.	
12. A WRITTEN REPORT DESCRIBING THE ACTIVITIES AND MEASUREMENTS COMPLETED IN ACCORDANCE WITH SECTION IECC 2018 C408.2.5.2.	
13. ALL HEATING AND COOLING LOADS CALCULATED PER ASHRAE/ACCA 183.	
14. VENTILATION FOR ALL AREA SHALL COMPLY WITH 2018 INTERNATIONAL MECHANICAL CODE, CHAPTER 4.	
15. THESE PLANS ARE APPROVED ONLY FOR THE WORK INDICATED ON THE APPLICATION SPECIFICATION SHEET. ALL OTHER MATTERS SHOWN ARE NOT TO BE RELIED UPON OR TO BE CONSIDERED AS EITHER BEING APPROVED OR IN ACCORDANCE WITH APPLICABLE CODES.	
16. A MECHANICAL SYSTEM SHALL BE COMMISSIONED AS PER 2018 IECC 408.2.4, 408.2.5.4, 408.2.1, 408.2.5.1.	
17. SMOKE DETECTOR SHALL MEET UL268A.	

GENERAL NOTES	
1. CONTRACTOR SHALL SURVEY THE AREA OF THIS WORK BEFORE SUBMITTING A BID AND SHALL BE RESPONSIBLE FOR NOTIFYING THE ARCHITECT OF ANY CONDITIONS WHICH WOULD PREVENT THE INSTALLATION OF THE WORK AS SHOWN ON DRAWINGS.	
2. ALL APPLICABLE CODES, LAWS AND REGULATIONS GOVERNING OR RELATING TO ANY PORTION OF THIS WORK ARE HEREBY INCORPORATED INTO AND MADE A PART OF THESE SPECIFICATIONS, AND THEIR PROVISIONS SHALL BE CARRIED OUT BY THE CONTRACTOR WHO SHALL INFORM THE OWNER, PRIOR TO SUBMITTING A PROPOSAL, OF ANY WORK OR MATERIALS WHICH VIOLATE ANY OF THE ABOVE LAWS AND REGULATIONS. ANY WORK DONE BY THE CONTRACTOR CAUSING SUCH VIOLATION SHALL BE CORRECTED BY THE CONTRACTOR.	
3. BEFORE PROCEEDING WITH ANY WORK IN OCCUPIED OR USED AREAS, THE CONTRACTOR SHALL APPLY TO OWNER FOR PERMISSION TO ENTER SUCH AREAS. THE CONTRACTOR IS OBLIGED TO PERFORM HIS WORK ONLY AT THE TIMES DESIGNATED BY OWNER. THERE WILL BE NO ADDITIONAL COMPENSATION FOR THE WORK PERFORMED AFTER HOURS OR ON OFF-DAYS WITHOUT PRIOR WRITTEN APPROVAL.	
4. THE WORK IN THE BUILDING SHALL BE DONE WHEN AND AS DIRECTED, AND IN A MANNER SATISFACTORY TO THE OWNER. THE WORK SHALL BE PERFORMED SO AS TO CAUSE THE LEAST POSSIBLE INCONVENIENCE AND DISTURBANCE TO THE PRESENT OCCUPANTS.	
5. THE CONTRACTOR'S PROPOSAL FOR ALL WORK SHALL BE PREDICATED ON THE PERFORMANCE OF THE WORK DURING REGULAR WORKING HOURS. WHEN SO DIRECTED, HOWEVER, THE CONTRACTOR SHALL INSTALL WORK IN OVERTIME AND THE ADDITIONAL COST TO BE CHARGED THEREFORE SHALL BE ONLY THE "PREMIUM" PORTION OF THE WAGES PAID.	
6. CONTRACTOR SHALL ASCERTAIN THE APPROPRIATE METHOD FOR BRINGING THE UNITS INTO AND THROUGH THE BUILDING TO POSITION UNIT IN LOCATION SHOWN ON THE PLANS. WHERE NECESSARY, EQUIPMENT SHALL BE SHIPPED FROM MANUFACTURER IN SECTIONS OF SIZE SUITABLE FOR MOVING THROUGH RESTRICTIVE SPACES. COORDINATE WITH BUILDING OWNER APPROPRIATE TIMES OF DAY SUCH EQUIPMENT MAY BE MOVED THROUGH ALL AREAS.	

7. REMOVAL AND RELOCATION OF CERTAIN EXISTING WORK WILL BE NECESSARY FOR THE PERFORMANCE OF THE GENERAL WORK. ALL EXISTING CONDITIONS CANNOT BE COMPLETELY DETAILED ON THE DRAWINGS. THE CONTRACTOR SHALL SURVEY THE SITE AND INCLUDE ALL CHANGES IN MAKING UP THE WORK PROPOSAL.	
8. DISCONNECT, REMOVE AND/OR RELOCATE EXISTING MATERIAL, EQUIPMENT AND OTHER WORK AS NOTED OR REQUIRED FOR PROPER INSTALLATION OF NEW SYSTEM.	
9. CONNECT NEW WORK TO EXISTING WORK IN NEAT AND APPROVED MANNER. RESTORE EXISTING WORK DISTURBED WHILE INSTALLING NEW WORK TO ACCEPTABLE CONDITION AS DETERMINED BY ARCHITECT.	
10. PLAN INSTALLATION OF NEW WORK AND CONNECTIONS TO EXISTING WORK TO INSURE MINIMUM INTERFERENCE WITH REGULAR OPERATION OF EXISTING FACILITIES. ALL SYSTEM SHUTDOWNS AFFECTING OTHER AREAS SHALL BE COORDINATED WITH BUILDING OWNER. INSTALL ISOLATION VALVES AT POINT OF CONNECTION TO THE EXISTING PIPING. PROVIDE TEMPORARY DUCT CAPS AND/OR CONNECTIONS TO MINIMIZE SHUTDOWN TIME.	
11. SUPPORT ALL DUCTWORK AND PIPING FROM BUILDING STRUCTURE AND/OR FRAMING IN AN APPROVED MANNER. WHERE OVERHEAD CONSTRUCTION DOES NOT PERMIT FASTENING OR SUPPORTS FOR EQUIPMENT, FURNISH ADDITIONAL FRAMING. INSERTS SHALL BE STEEL, SLOTTED TYPE AND FACTORY PAINTED. SINGLE ROD SHALL BE SIMILAR TO GRINNELL FIG. 281. MULTI-ROD SHALL BE SIMILAR TO FEE & MASON SERIES 3000 WITH END CAPS AND CLOSURE STRIPS. MAXIMUM LOADING INCLUDING PIPES, DUCTWORK, CONTENTS AND COVERING SHALL NOT EXCEED 75% OF RATED INSERT CAPABILITY. WHEN SUPPORTING FROM BUILDING USE BEAM CLAMPS IN APPROVED MANNER.	
12. PROVIDE ALL NECESSARY FLASHING AND COUNTER FLASHING TO MAINTAIN THE WATERPROOFING INTEGRITY OF THIS BUILDING AS REQUIRED BY THE INSTALLATION OR REMOVAL OF PIPES, DUCTS, LOUVERS, CONDUIT, AND EQUIPMENT. PROVIDE EQUIPMENT CURBS AND DUNNAGE STEEL AS REQUIRED.	
13. SEAL OPENINGS AROUND DUCTS AND PIPING THROUGH PARTITIONS, WALLS AND FLOORS (NOT IN SHAFTS) WITH MINERAL WOOL OR OTHER NONCOMBUSTIBLE MATERIAL (FIBERGLASS INSULATION IS NOT ACCEPTABLE).	
14. WHERE PENETRATIONS THROUGH FIRE RATED WALLS ARE NOT FIRE PROOFED THIS CONTRACTOR SHALL BE RESPONSIBLE TO SEAL SAME TO MAINTAIN THE RATED INTEGRITY.	
15. INSTALL WORK SO AS TO BE READILY ACCESSIBLE FOR OPERATION, MAINTENANCE AND REPAIR. MINOR DEVIATIONS FROM DRAWINGS MAY BE MADE TO ACCOMPLISH THIS, BUT CHANGES WHICH INVOLVE EXTRA COST SHALL NOT BE MADE WITHOUT APPROVAL.	
16. ACCESS DOORS ARE REQUIRED FOR ALL BUILDING SERVICE VALVES THAT RUN THROUGH THE SPACE, AND ACCESS DOOR SHALL HAVE THE EQUAL RATED CAPACITY (1HR, 2HR, ETC.) AS WALL. COORDINATE ALL LOCATIONS OF ACCESS DOORS WITH THE ARCHITECT.	
17. REMOVABLE ACCESS TILE AND/OR ACCESS DOOR ARE REQUIRED IN HUNG CEILINGS, SHAFTS AND WALLS FOR ALL VOLUME AND FIRE DAMPERS, AUTOMATIC DAMPERS AND ALL OTHER MECHANICAL EQUIPMENT AND DEVICES. HVAC CONTRACTOR TO FURNISH ACCESS LOCATION REQUIREMENTS TO GENERAL CONTRACTOR. ACCESS TILE IDENTIFICATION: PROVIDE BUTTONS, TABS, AND MARKERS TO IDENTIFY LOCATION OF CONCEALED VALVES, DAMPERS AND EQUIPMENT.	
18. THE CONTRACTOR SHALL KEEP ALL EQUIPMENT AND MATERIALS, AND ALL PARTS OF THE BUILDING, EXTERIOR SPACES AND ADJACENT STREETS, SIDEWALKS AND PAVEMENTS, FREE FROM MATERIAL AND DEBRIS RESULTING FROM THE EXECUTION OF THIS WORK. EXCESS MATERIALS WILL NOT BE PERMITTED TO ACCUMULATE EITHER ON THE INTERIOR OR THE EXTERIOR.	
19. UNLESS OTHERWISE SPECIFICALLY SPECIFIED, INCLUDE ALL EXISTING AND PATCHING OF EXISTING FLOORS, WALLS, PARTITIONS AND OTHER MATERIALS IN THE EXISTING BUILDING. THE CONTRACTOR SHALL RESTORE THESE AREAS TO ORIGINAL CONDITION.	
20. MATERIALS AND WORKMANSHIP, UNLESS OTHERWISE NOTED, SHALL BE IN ACCORDANCE WITH BUILDING STANDARDS.	
21. ALL EQUIPMENT SHALL BE PROVIDED WITH ONE YEAR WARRANTY. PARTS AND LABOR AND FIVE YEARS ON COMPRESSORS. WARRANTY PERIOD BEGINS UPON PROJECT ACCEPTANCE	
22. ALL MATERIAL AND EQUIPMENT TO BE NEW UNLESS OTHERWISE NOTED AND SHALL BE IN ACCORDANCE WITH BUILDING STANDARDS.	
23. THE CONTRACTOR SHALL BE RESPONSIBLE FOR HIS WORK WITH ITS COMPLETION AND FINAL ACCEPTANCE AND SHALL REPLACE ANY OF THE SAME WHICH MAY BE DAMAGED, LOST, OR STOLEN WITHOUT ADDITIONAL COST TO THE OWNER.	
24. THE CONTRACTOR SHALL BE RESPONSIBLE FOR THE FAILURE OF ANY DUCTWORK SYSTEM OR EQUIPMENT TO FUNCTION PROPERLY UPON COMPLETION OF HIS WORK UPON SAID SYSTEM OR EQUIPMENT.	
25. SUBMIT SHOP DRAWING OF ALL WORK WHICH MUST BE APPROVED BY THE ARCHITECT AND ENGINEER BEFORE WORK COMMENCES.	
26. ALL MATERIAL AND EQUIPMENT TO BE NEW UNLESS OTHERWISE NOTED AND SHALL BE IN ACCORDANCE WITH BUILDING STANDARDS.	
27. SUBMISSION OF A PROPOSAL SHALL BE CONSTRUED AS EVIDENCE THAT A CAREFUL EXAMINATION OF THE PORTIONS OF THE EXISTING BUILDING, EQUIPMENT, ETC. WHICH AFFECT THIS WORK, AND THE ACCESS TO SUCH SPACES, HAS BEEN MADE AND THAT THE CONTRACTOR IS FAMILIAR WITH EXISTING CONDITIONS AND DIFFICULTIES THAT WILL AFFECT THE EXECUTION OF THE WORK. LATER CLAIMS SHALL NOT BE MADE FOR LABOR, EQUIPMENT OR MATERIALS REQUIRED BECAUSE OF DIFFICULTIES ENCOUNTERED WHICH COULD HAVE BEEN FORESEEN DURING SUCH AN EXAMINATION. THE ON-SITE INSPECTION SHALL VERIFY EXISTING DUCTWORK, PIPING (SIZES, CLEARANCES, ETC) AND CONDITIONS.	
28. INSURANCE: IN ACCORDANCE WITH BUILDING REQUIREMENTS THE CONTRACTOR SHALL INCLUDE A HOLD HARMLESS CLAUSE FOR OWNER AND ENGINEER.	

29. THE FINAL ACCEPTANCE WILL BE MADE AFTER THE CONTRACTOR HAS ADJUSTED HIS EQUIPMENT, BALANCED THE VARIOUS SYSTEMS, DEMONSTRATED THAT IT FULFILLS THE REQUIREMENTS OF THE DRAWINGS AND SPECIFICATIONS AND HAS FURNISHED ALL THE REQUIRED CERTIFICATES OF INSPECTION AND APPROVAL.
30. SPECIFICATIONS ARE OF SIMPLIFIED FORM AND INCLUDE INCOMPLETE SENTENCES. WORDS OR PHRASES SUCH AS "THE CONTRACTOR SHALL," "SHALL BE," "FURNISH," "PROVIDE," "A," "THE," AND "ALL" HAVE BEEN OMITTED FOR BREVITY.
31. WHERE A CONFLICT EXISTS BETWEEN THE DRAWINGS, THE SPECIFICATIONS OR ANY OTHER CONSTRUCTION DOCUMENT, THE ONE WITH THE MOST STRINGENT REQUIREMENT(S) SHALL APPLY.
DEFINITIONS:
1) "PROVIDE": TO SUPPLY, INSTALL AND CONNECT UP COMPLETE AND READY FOR SAFE AND REGULAR OPERATION THE PARTICULAR WORK REFERRED TO UNLESS SPECIFICALLY OTHERWISE NOTED.
2) "INSTALL": TO ERECT, MOUNT AND CONNECT COMPLETE WITH RELATED ACCESSORIES.
3) "FURNISH" OR "SUPPLY": TO PURCHASE, PROCURE, ACQUIRE AND DELIVER COMPLETE WITH RELATED ACCESSORIES.

SCOPE OF WORK
SCOPE OF WORK
1.THE WORK UNDER CONTRACT INCLUDES ALL LABOR, MATERIALS AND APPLIANCES NECESSARY FOR THE FURNISHING, INSTALLING AND TESTING, COMPLETE AND READY FOR SAFE OPERATION OF THE SYSTEMS AS DESCRIBED IN THE SPECIFICATIONS, FLOOR PLAN(S) DESIGN, DETAIL DRAWINGS, NOTES, RFI'S, ETC. FOR THIS PROJECT. WORK SHALL BE INSTALLED IN A NEAT, WORKMANLIKE MANNER.
2.THE CONTRACTOR SHALL GIVE NECESSARY NOTICE, FILE DRAWINGS AND SPECIFICATIONS WITH THE DEPARTMENT HAVING JURISDICTION, OBTAIN PERMITS OR LICENSES NECESSARY TO CARRY OUT THIS WORK AND PAY ALL FEES THEREFORE. THE CONTRACTOR SHALL ARRANGE FOR INSPECTION AND TESTS OF ANY OR ALL PARTS OF THE WORK IF SO REQUIRED BY AUTHORITIES AND PAY ALL CHARGES FOR SAME. THE CONTRACTOR SHALL PAY ALL COSTS FOR, AND FURNISH TO THE OWNER BEFORE FINAL BILLING, ALL CERTIFICATES NECESSARY AS EVIDENCE THAT THE WORK INSTALLED CONFORMS WITH ALL REGULATIONS WHERE THEY APPLY TO THIS WORK.
3.THE CONTRACTOR SHALL FURNISH A WRITTEN GUARANTEE TO REPLACE OR REPAIR PROMPTLY AND ASSUME RESPONSIBILITY FOR ALL EXPENSES INCURRED FOR ANY WORKMANSHIP AND EQUIPMENT IN WHICH DEFECTS DEVELOP WITHIN ONE YEAR FROM THE DATE OF FINAL CERTIFICATE FOR PAYMENT AND/OR FROM DATE OF ACTUAL USE OF EQUIPMENT OR OCCUPANCY OF SPACES, BY OWNER, INCLUDED UNDER THE VARIOUS PARTS OF THE WORK, WHICHEVER DATE IS EARLIER. THIS WORK SHALL BE DONE AS DIRECTED BY THE OWNER. THIS GUARANTEE SHALL ALSO PROVIDE THAT WHERE DEFECTS OCCUR, THE CONTRACTOR WILL ASSUME RESPONSIBILITY FOR ALL EXPENSES INCURRED IN REPAIRING AND REPLACING WORK OF OTHER TRADES AFFECTED BY DEFECTS, REPAIRS OR REPLACEMENTS IN EQUIPMENT SUPPLIED BY THE CONTRACTOR.

DEMOLITION NOTES
1.DEMOLITION AND OTHER WORK WHICH CREATES DIRT AND/OR DISTURBING NOISE IN OR ADJACENT TO TENANT-OCCUPIED SPACES MUST BE PERFORMED AFTER 5 PM OR ON WEEKENDS. THE DELIVERY, HANDLING, AND INSTALLING OF MATERIALS, EQUIPMENT, AND DEBRIS MUST BE ARRANGED TO AVOID ANY INCONVENIENCE AND ANNOYANCE TO OTHER TENANTS. CLEANING MUST BE CONTROLLED TO PREVENT DIRT AND DUST FROM INFILTRATING INTO ADJACENT TENANT OR MECHANICAL AREAS. WELDING OR BURNING MUST BE PERFORMED ONLY DURING TIMES SPECIFICALLY APPROVED BY THE OWNER.
2.THE DEMOLITION SPECIFICATION SHALL BE CONSIDERED ONLY AS A GUIDE AND IS NOT INTENDED TO SHOW EVERY SINGLE ITEM OF WORK AS REQUIRED. ACTUAL FIELD CONDITIONS WILL DETERMINE THE PRECISE WORK TO BE DONE. SHOULD ANY QUESTION ARISE AS TO WHETHER OR NOT ANY PIPING, EQUIPMENT OR OTHER ITEM SHOULD BE REMOVED, OR REMAIN AS PRESENTLY INSTALLED, THIS CONTRACTOR SHALL REQUEST, IN WRITING, CLARIFICATION FROM THE ARCHITECT. BECAUSE THE MECHANICAL DRAWINGS INDICATE THE INTENT OF THE SCOPE OF WORK, NO EXTRA CHARGES WILL BE ALLOWED FOR ANY REMOVALS NECESSARY FOR THE COMPLETION OF THE WORK UNDER THIS PROJECT.
3.CONTRACTOR SHALL DEMOLISH ALL EXISTING HVAC EQUIPMENT, DUCTWORK, AND APPURTENANCES AS SHOWN ON THIS DRAWING.
4.THIS CONTRACTOR SHALL CAP ALL REMAINING DUCTS, AT ALL POINTS OF DISCONNECTION, AIRTIGHT.
5.ALL PRESENT MATERIAL, EQUIPMENT AND CONSTRUCTION DEBRIS TO BE REMOVED UNDER THIS CONTRACT SHALL BECOME THE PROPERTY OF THE CONTRACTOR WITH THE EXCEPTION OF SPECIFIC EQUIPMENT AND APPARATUS REQUESTED BY THE BUILDING REPRESENTATIVE, ARCHITECT OR AS NOTED TO BE RELOCATED ON THE DRAWINGS AND SHALL BE PROPERLY DISPOSED OF BY THIS CONTRACTOR.
6.REMOVAL SHALL INCLUDE TAKING FROM THE PREMISES AND DISPOSAL OF REMOVED ITEMS AND DEBRIS IN A MANNER ACCORDING TO ALL STATE AND LOCAL RULES REGULATIONS AND CODES.

REVISION SCHEDULE	
NO.REV. / SUBMISSION DATE	ISSUED BY
	PERMIT SET 06/21/22 NYE
ISSUE DATE: 4/6/2022 5:19:23 PM	
RENOVATION	
FOUR STAR MUSHROOMS	
DRAWN BY:	NYE
QAQC:	
APPROVED BY:	NYE
PROJECT NUMBER:	2206
MECHANICAL SYMBOL, DRAWING LIST, ABBREVIATION & NOTES	

M0.1

GENERAL HVAC NOTES

GENERAL:	1. PROVIDE ALL MATERIAL AND EQUIPMENT AND PERFORM ALL LABOR REQUIRED TO INSTALL COMPLETE AND OPERABLE MECHANICAL SYSTEMS AS INDICATED ON THE DRAWINGS, AS SPECIFIED AND AS REQUIRED BY CODE. 2. CONTRACT DOCUMENT DRAWINGS FOR MECHANICAL WORK (HVAC, PLUMBING, AND FIRE PROTECTION) ARE DIAGRAMMATIC AND ARE INTENDED TO CONVEY SCOPE AND GENERAL ARRANGEMENT ONLY. 3. THE LOCATIONS OF ALL ITEMS SHOWN ON THE DRAWINGS OR CALLED FOR IN THE SPECIFICATIONS THAT ARE NOT FIXED BY DIMENSIONS ARE APPROXIMATE ONLY. THE EXACT LOCATIONS NECESSARY TO SECURE THE BEST CONDITIONS AND RESULTS MUST BE DETERMINED BY THE PROJECT SITE CONDITIONS AND SHALL HAVE THE APPROVAL OF THE ENGINEER BEFORE BEING INSTALLED. DO NOT SCALE DRAWINGS. 4. WHEN MECHANICAL WORK (HVAC, PLUMBING, SHEET METAL, FIRE PROTECTION, ETC.) IS SUBCONTRACTED, IT SHALL BE THE MECHANICAL CONTRACTOR'S RESPONSIBILITY TO COORDINATE SUBCONTRACTORS AND THE ASSOCIATED CONTRACTS. WHEN DISCREPANCIES ARISE PERTAINING TO WHICH CONTRACTOR PROVIDES A PARTICULAR ITEM OF THE MECHANICAL CONTRACT OR WHICH CONTRACTOR PROVIDES FINAL CONNECTIONS FOR A PARTICULAR ITEM OF THE MECHANICAL CONTRACT, IT SHALL BE BROUGHT TO THE ATTENTION OF THE MECHANICAL CONTRACTOR, WHOSE DECISION SHALL BE FINAL. 5. COORDINATE CONSTRUCTION OF ALL MECHANICAL WORK WITH ARCHITECTURAL, STRUCTURAL, CIVIL, ELECTRICAL WORK, ETC., SHOWN ON OTHER CONTRACT DOCUMENT DRAWINGS. 6. INSTALL ALL MECHANICAL EQUIPMENT AND APPURTENANCES IN ACCORDANCE WITH MANUFACTURER'S RECOMMENDATIONS, CONTRACT DOCUMENTS, AND APPLICABLE CODES AND REGULATIONS. 7. WHERE TWO OR MORE ITEMS OF THE SAME TYPE OF EQUIPMENT ARE REQUIRED, THE PRODUCT OF ONE MANUFACTURER SHALL BE USED. 8. COORDINATE ALL EQUIPMENT CONNECTIONS WITH MANUFACTURERS' CERTIFIED DRAWINGS. COORDINATE AND PROVIDE ALL DUCT AND PIPING TRANSITIONS REQUIRED FOR FINAL EQUIPMENT CONNECTIONS TO FURNISHED EQUIPMENT. FIELD VERIFY AND COORDINATE ALL DUCT AND PIPING DIMENSIONS BEFORE FABRICATION. 9. ALL CONTROL WIRE AND CONDUIT SHALL COMPLY WITH THE NATIONAL ELECTRIC CODE AND ELECTRICAL DIVISION OF THE SPECIFICATION. 10. PROVIDE VIBRATION ISOLATION FOR ALL MECHANICAL EQUIPMENT TO PREVENT TRANSMISSION OF VIBRATION TO BUILDING STRUCTURE. 11. LOCATE ALL TEMPERATURE, AND FLOW MEASURING DEVICES IN ACCESSIBLE LOCATIONS WITH THE STRAIGHT SECTION OF PIPE OR DUCT UP- AND DOWNSTREAM AS RECOMMENDED BY THE MANUFACTURER FOR GOOD ACCURACY. 12. WHERE BEAMS ARE INDICATED TO BE PENETRATED WITH DUCTWORK OR PIPING, COORDINATE DUCTWORK AND PIPING LAYOUT WITH BEAM OPENING SIZE AND OPENING LOCATIONS. COORDINATION SHALL BE DONE PRIOR TO THE FABRICATION OF DUCTWORK, CUTTING OF PIPING, OR FABRICATION OF BEAMS. 13. ALL MISCELLANEOUS STEEL REQUIRED TO ENSURE PROPER INSTALLATION AND AS SHOWN IN THE DETAILS FOR DUCTWORK, AND EQUIPMENT (UNLESS OTHERWISE NOTED) SHALL BE FURNISHED AND INSTALLED BY THE MECHANICAL CONTRACTOR. 14. PROVIDE ACCESS PANELS FOR INSTALLATION IN WALLS AND CEILINGS, WHERE REQUIRED, TO SERVICE DAMPERS, VALVES, SMOKE DETECTORS, AND OTHER CONCEALED MECHANICAL EQUIPMENT. ACCESS PANELS SHALL BE TURNED OVER TO THE GENERAL CONTRACTOR FOR INSTALLATION. ACCESS PANELS SHALL HAVE THE EQUAL RATED CAPACITY (1HR, 2HR, ETC.) AS WALL. 15. MECHANICAL EQUIPMENT, DUCTWORK, AND PIPING SHALL NOT BE SUPPORTED FROM A METAL DECK. 16. ALL EQUIPMENT, PIPING, DUCTWORK, ETC., SHALL BE SUPPORTED AS DETAILED, SPECIFIED AND REQUIRED TO PROVIDE A VIBRATION-FREE INSTALLATION. 17. ALL DUCTWORK, PIPING, AND EQUIPMENT SUPPORTED FROM STRUCTURAL STEEL SHALL BE COORDINATED WITH THE GENERAL CONTRACTOR. ALL ATTACHMENTS TO STEEL BAR JOISTS, TRUSSES, OR JOIST GIRDERS SHALL BE AT PANEL POINTS. PROVIDE BEAM CLAMPS MEETING MSS STANDARDS. WELDING TO STRUCTURAL MEMBERS SHALL NOT BE PERMITTED. THE USE OF C-CLAMPS SHALL NOT BE PERMITTED. 18. LOCATIONS AND SIZES OF ALL FLOOR, WALL, AND ROOF OPENINGS SHALL BE COORDINATED WITH ALL OTHER TRADES INVOLVED. 19. ALL OPENINGS IN FIRE WALLS DUE TO DUCTWORK, PIPING, CONDUIT, ETC., SHALL BE FIRE STOPPED WITH A PRODUCT SIMILAR TO 3M OR APPROVED EQUAL. 20. ALL AIR CONDITIONING CONDENSATE DRAIN LINES FROM EACH AIR HANDLING UNIT SHALL BE PIPED FULL SIZE OF THE UNIT DRAIN OUTLET, WITH "P" TRAP, AND PIPED TO THE NEAREST DRAIN. SEE THE DETAILS SHOWN IN THE DRAWINGS OR THE CONTRACT SPECIFICATIONS FOR THE DEPTH OF THE AIR CONDITIONING CONDENSATE TRAP. 21. REFER TO TYPICAL DETAILS FOR DUCTWORK, PIPING, AND EQUIPMENT INSTALLATION. 22. ALL TESTS SHALL BE COMPLETED BEFORE ANY MECHANICAL EQUIPMENT OR PIPING INSULATION IS APPLIED. 23. TESTING, ADJUSTING, AND BALANCING AGENCY SHALL BE A MEMBER OF THE ASSOCIATED AIR BALANCE COUNCIL (AABC) OR THE NATIONAL ENVIRONMENTAL BALANCING BUREAU (NEBB). TESTING, ADJUSTING, AND BALANCING SHALL BE PERFORMED IN ACCORDANCE WITH THE AABC STANDARDS. <td> 2. CONTRACTOR TO CHECK AND CORRECT ANY AND ALL DEFICIENCIES IN EXISTING DUCTS. ALL NEW DUCTWORK WILL COMPLY WITH THE LATEST SMACNA GUIDELINES AND CONFORM WITH REQUIREMENTS OF THE LATEST HANDBOOKS PUBLISHED BY ASHRAE. 3. PROVIDE VOLUME DAMPER AT EACH TAP TO MAIN DUCT AND WHERE NECESSARY TO PROPERLY BALANCE SYSTEM. 4. SUPPLY AND RETURN DUCTWORK 20' FROM ALL AC UNITS SHALL BE LINED WITH 1.5" ACOUSTICAL LINING. 5. RE-INSULATE ALL DUCTWORK AND PIPING IN WHICH INSULATION HAS BEEN REMOVED OR DAMAGED WITH INSULATION EQUAL TO THE EXISTING INSULATION. 6. CONTRACTOR SHALL SUPPLY AND INSTALL ALL NECESSARY SUPPLY DIFFUSERS AND RETURN AIR REGISTERS WHERE INDICATED ON THE DRAWING. COORDINATE LOCATION OF DIFFUSERS AND REGISTERS WITH REFLECTED CEILING PLAN. 7. IN CORRIDORS WHERE CEILING SPEAKERS AND AIR DIFFUSERS ARE INDICATED BETWEEN THE SAME LIGHT FIXTURES, INSTALL BOTH DEVICES AT THE QUARTER POINTS BETWEEN THE FIXTURES. 8. UNLESS OTHERWISE SHOWN, LOCATE ALL ROOM THERMOSTATS 4'-0" (CENTER LINE) ABOVE THE FINISHED FLOOR. NOTIFY THE ENGINEER OF ANY ROOMS WHERE THE PRECEDING LOCATION CANNOT BE MAINTAINED OR WHERE THERE IS A QUESTION ON LOCATION. 9. ALL DUCTWORK SHALL CLEAR DOORS AND WINDOWS. 10. ALL DUCTWORK DIMENSIONS, AS SHOWN ON THE DRAWINGS, ARE INTERNAL CLEAR DIMENSIONS AND DUCT SIZE SHALL BE INCREASED TO COMPENSATE FOR DUCT LINING THICKNESS. 11. PROVIDE ALL 90-DEGREE SQUARE ELBOWS WITH DOUBLE RADIUS TURNING VANES UNLESS OTHERWISE INDICATED. ELBOWS IN DISHWASHER, KITCHEN, AND LAUNDRY EXHAUSTS SHALL BE OF UN-VANED SMOOTH RADIUS CONSTRUCTION WITH A RADIUS EQUAL TO 1-1/2 TIMES THE WIDTH OF THE DUCT. PROVIDE ACCESS DOORS UPSTREAM OF ALL ELBOWS WITH TURNING VANES. 12. COORDINATE DIFFUSER, REGISTER, AND GRILL LOCATIONS WITH ARCHITECTURAL REFLECTED CEILING PLANS, LIGHTING, AND OTHER CEILING ITEMS AND MAKE MINOR DUCT MODIFICATIONS TO SUIT. 13. ALL AIR HANDLING UNITS SHALL OPERATE WITHOUT MOISTURE CARRYOVER. 14. LOCATE ALL MECHANICAL EQUIPMENT FOR UNOBSTRUCTED ACCESS TO UNIT ACCESS PANELS, CONTROLS, AND VALVING. 15. PROVIDE FLEXIBLE CONNECTIONS IN ALL DUCTWORK SYSTEMS (SUPPLY, RETURN, AND EXHAUST) CONNECTED TO AIR HANDLING UNITS, FANS, AND OTHER EQUIPMENT THAT REQUIRE VIBRATION ISOLATION. FLEXIBLE CONNECTIONS SHALL BE PROVIDED AT THE POINT OF CONNECTION TO THE EQUIPMENT UNLESS OTHERWISE INDICATED. 16. UNLESS OTHERWISE NOTED, ALL DUCTWORK IS OVERHEAD, TIGHT TO THE UNDERSIDE OF THE STRUCTURE, WITH SPACE FOR INSULATION IF NEEDED. 17. RUNS OF FLEXIBLE DUCT SHALL NOT EXCEED 5 FT. 18. ALL DUCTWORK SHALL BE COORDINATED WITH ALL TRADES INVOLVED. OFFSETS IN DUCTS, INCLUDING DIVIDED DUCTS AND TRANSITIONS AROUND OBSTRUCTIONS, SHALL BE PROVIDED AT NO ADDITIONAL COST TO THE OWNER. 19. PROVIDE ACCESS DOORS IN DUCTWORK TO PROVIDE ACCESS FOR ALL SMOKE DETECTORS, FIRE DAMPERS, SMOKE DAMPERS, VOLUME DAMPERS, COILS, AND OTHER ITEMS LOCATED IN THE DUCTWORK THAT REQUIRE SERVICE AND/OR INSPECTION. 20. PROVIDE ACCESS DOORS IN DUCTWORK FOR THE OPERATION, ADJUSTMENT, AND MAINTENANCE OF ALL FANS, VALVES, AND MECHANICAL EQUIPMENT. 21. ALL DUCTS SHALL BE GROUNDED ACROSS FLEXIBLE CONNECTIONS WITH FLEXIBLE COPPER GROUNDING STRAPS. GROUNDING STRAPS SHALL BE BOLTED OR SOLDERED TO BOTH THE EQUIPMENT AND THE DUCT. 22. SMOKE DETECTORS SHALL BE FURNISHED AND WIRED BY THE ELECTRICAL CONTRACTOR. THE MECHANICAL CONTRACTOR SHALL BE RESPONSIBLE FOR MOUNTING THE SMOKE DETECTOR IN DUCTWORK AS SHOWN ON THE DRAWINGS AND IN ACCORDANCE WITH THE MANUFACTURER'S PRINTED INSTRUCTIONS. 23. SEE SPECIFICATIONS FOR DUCTWORK GAUGES, BRACING, HANGERS, AND OTHER REQUIREMENTS. 24. EXTERIOR LOUVERS ARE INDICATED FOR SIZE, GENERAL LOCATION AND PERFORMANCE ONLY. DETAILED LOUVER DESCRIPTIONS ARE PROVIDED IN THE ARCHITECTURAL SPECIFICATIONS. </td> <td> 6. ALL VALVES (EXCEPT CONTROL VALVES) AND STRAINERS SHALL BE THE FULL SIZE OF THE PIPE BEFORE REDUCING IN SIZE TO MAKE CONNECTIONS TO EQUIPMENT AND CONTROLS. 7. INSTALL ALL PIPING WITHOUT FORCING OR SPRINGING. 8. ALL PIPING SHALL CLEAR DOORS AND WINDOWS. 9. ALL VALVES SHALL BE ADJUSTED FOR SMOOTH AND EASY OPERATION. 10. ALL PIPING SHALL BE COORDINATED WITH ALL TRADES INVOLVED. OFFSETS IN PIPING AROUND OBSTRUCTIONS SHALL BE PROVIDED AT NO ADDITIONAL COST TO THE OWNER. 11. SLOPED REFRIGERANT PIPING 1% IN THE DIRECTION OF OIL RETURN. LIQUID LINES MAY BE INSTALLED LEVEL. 12. INSTALL HORIZONTAL REFRIGERANT HOT GAS DISCHARGE PIPING WITH 1/2" PER 10 FT. DOWNWARD SLOPE AWAY FROM THE COMPRESSOR. 13. INSTALL HORIZONTAL REFRIGERANT SUCTION LINES WITH 1/2" PER 10 FT. DOWNWARD SLOPE TO THE COMPRESSOR, WITH NO LONG TRAPS OR DEAD ENDS THAT MAY CAUSE OIL TO SEPARATE FROM THE SUCTION GAS AND RETURN TO THE COMPRESSOR IN DAMAGING SLUGS. 14. PROVIDE LINE SIZE LIQUID INDICATORS IN THE MAIN LIQUID LINE LEAVING THE CONDENSER OR RECEIVER. INSTALL MOISTURE-LIQUID INDICATORS IN LIQUID LINES BETWEEN FILTER DRYERS AND THERMOSTATIC EXPANSION VALVES, AND IN LIQUID LINE TO RECEIVER. 15. PROVIDE A LINE SIZE STRAINER UPSTREAM OF EACH AUTOMATIC VALVE. PROVIDE A SHUT-OFF VALVE ON EACH SIDE OF A STRAINER. 16. PROVIDE PERMANENT FILTER DRYERS IN LOW-TEMPERATURE SYSTEMS AND SYSTEMS USING HERMETIC COMPRESSORS. 17. PROVIDE REPLACEABLE CARTRIDGE FILTER DRYERS WITH A THREE-VALVE BYPASS ASSEMBLY FOR SOLENOID VALVES, ADJACENT TO RECEIVERS. 18. PROVIDE REFRIGERANT CHARGING VALVE CONNECTIONS IN THE LIQUID LINE BETWEEN THE RECEIVER SHUTOFF VALVE AND THE EXPANSION VALVE. </td> <td> SECTION 0101 – QUALITY OF WORK 1.1 WORKMANSHIP A. ALL WORK SHALL BE FREE FROM DEFECTS IN MATERIALS AND WORKMANSHIP FOR A PERIOD OF ONE YEAR FROM DATE OF FINAL ACCEPTANCE. B. ALL DEFECTS WHICH DEVELOP OR ARE DISCOVERED WITHIN THIS PERIOD SHALL BE REPAIRED BY THE CONTRACTOR TO THE SATISFACTION OF THE ARCHITECT OR BUILDING MANAGER AT NO ADDITIONAL COST TO THE OWNER. C. UPON COMPLETION OF THE WORK THE CONTRACTOR SHALL REMOVE FROM THE SITE, ALL TOOLS, DEMOLISHED APPLIANCES AND ANY SURPLUS MATERIAL. 1.2 CODE COMPLIANCE A. ALL WORK SHALL MEET ALL STATE AND LOCAL CODES HAVING JURISDICTION. END OF SECTION 0101 SECTION 0102 –REQUIRED DOCUMENTS 1.1 SHOP DRAWINGS A. A SET OF PRINTS FOR ANY MECHANICAL WORK INCLUDING BUT NOT LIMITED TO, DUCTWORK AND PIPING LAYOUT SHALL BE SUBMITTED FOR APPROVAL TO THE ENGINEER PRIOR TO CONSTRUCTION OR PURCHASE OF MATERIALS. 1.2 SUBMITTALS A. EQUIPMENT SUBMITTALS OF ALL PROPOSED MECHANICAL AND ANCILLARY EQUIPMENT INCLUDING ALL ACCESSORIES SHALL BE SUBMITTED TO THE ENGINEER FOR REVIEW. ALL PERTINENT MODELS, SIZES, ACCESSORIES AND CHOICES SHALL BE CLEARLY CHECKED, PRINTED OR OTHERWISE INDICATED ON THE SUBMITTALS. 1.3 RECORD DRAWINGS A. UPON COMPLETION OF THE WORK, A RECORD DRAWING SHALL BE SUBMITTED TO THE OWNER DEPICTING ALL SUBSEQUENT CHANGES, ADDITIONS AND OR CORRECTIONS TO THE CONTRACT DRAWINGS AND OR CONTRACT SCOPE MADE DURING CONSTRUCTION. THIS DRAWING SHALL REPRESENT A COMPLETE RECORD OF THE WORK INSTALLED. 1.4 EQUIPMENT OPERATING INSTRUCTIONS A. ON COMPLETION AND ACCEPTANCE OF WORK, THIS CONTRACTOR SHALL FURNISH WRITTEN INSTRUCTIONS, EQUIPMENT MANUALS AND DEMONSTRATE TO THE OWNER THE PROPER OPERATION AND MAINTENANCE OF ALL EQUIPMENT AND APPARATUS FURNISHED UNDER THIS CONTRACT. B. THESE INSTRUCTIONS SHALL BE TYPED ON 8-1/2 IN. X 11 IN. PAPER AND BOUND IN THREE-RING BINDERS WITH CLEAR ACETATE COVERS. THE CONTRACTOR SHALL GIVE THREE COPIES OF THE INSTRUCTIONS TO THE OWNER AND ONE ELECTRONIC COPY TO THE ENGINEER. C. THE INSTRUCTION BOOKLET SHALL BE ORGANIZED IN SECTIONS, WITH ONE SECTION PER SYSTEM. THE COVER OF THE INSTRUCTION BOOKLET SHALL BEAR THE NAME, ADDRESS AND PHONE NUMBER OF THE PROJECT, ARCHITECT, ENGINEER, MECHANICAL CONTRACTOR AND SUBCONTRACTORS. END OF SECTION 0102 SECTION 078413-PENETRATION FIRE-STOPPING 1.1 QUALITY ASSURANCE A. INSTALLER QUALIFICATIONS: AN FM GLOBAL-APPROVED FIRE-STOP CONTRACTOR OR A UL-QUALIFIED FIRE-STOP CONTRACTOR. B. FIRE-TEST-RESPONSE CHARACTERISTICS: UL, INTERTEK ETL SEMKO OR FM GLOBAL 1.2 PENETRATION FIRESTOPPING A. PENETRATIONS IN FIRE-RESISTANCE-RATED WALLS: F-RATINGS PER ASTM E 814 OR UL 1479. B. PENETRATIONS IN HORIZONTAL ASSEMBLIES: F- AND T-RATINGS PER ASTM E 814 OR UL 1479: C. PENETRATIONS IN SMOKE BARRIERS: L-RATINGS PER UL 1479. D. W-RATINGS: PER UL 1479. 1.3 INSTALLATION A. IDENTIFICATION: PREPRINTED METAL OR PLASTIC LABELS. 1.4 FIELD QUALITY CONTROL A. REPLACE BROKEN AND DAMAGED ESCUTCHEONS AND FLOOR PLATES USING NEW MATERIALS. END OF SECTION 078413 SECTION 230517 – SLEEVES AND SLEEVE SEALS FOR HVAC PIPING 1.1 PERFORMANCE REQUIREMENTS A. DELEGATED DESIGN: DESIGN TRAPEZE PIPE HANGERS AND EQUIPMENT SUPPORTS, INCLUDING COMPREHENSIVE ENGINEERING ANALYSIS BY A QUALIFIED PROFESSIONAL ENGINEER, USING PERFORMANCE REQUIREMENTS AND DESIGN CRITERIA INDICATED. B. STRUCTURAL PERFORMANCE: HANGERS AND SUPPORTS FOR HVAC PIPING AND EQUIPMENT SHALL WITHSTAND THE EFFECTS OF GRAVITY LOADS AND STRESSES WITHIN LIMITS AND UNDER CONDITIONS INDICATED ACCORDING TO ASCE/SEI 7. 1. DESIGN SUPPORTS FOR MULTIPLE PIPES CAPABLE OF SUPPORTING COMBINED WEIGHT OF SUPPORTED SYSTEMS, SYSTEM CONTENTS, AND TEST WATER. 2. DESIGN EQUIPMENT SUPPORTS CAPABLE OF SUPPORTING COMBINED OPERATING WEIGHT OF SUPPORTED EQUIPMENT AND CONNECTED SYSTEMS AND </td>	2. CONTRACTOR TO CHECK AND CORRECT ANY AND ALL DEFICIENCIES IN EXISTING DUCTS. ALL NEW DUCTWORK WILL COMPLY WITH THE LATEST SMACNA GUIDELINES AND CONFORM WITH REQUIREMENTS OF THE LATEST HANDBOOKS PUBLISHED BY ASHRAE. 3. PROVIDE VOLUME DAMPER AT EACH TAP TO MAIN DUCT AND WHERE NECESSARY TO PROPERLY BALANCE SYSTEM. 4. SUPPLY AND RETURN DUCTWORK 20' FROM ALL AC UNITS SHALL BE LINED WITH 1.5" ACOUSTICAL LINING. 5. RE-INSULATE ALL DUCTWORK AND PIPING IN WHICH INSULATION HAS BEEN REMOVED OR DAMAGED WITH INSULATION EQUAL TO THE EXISTING INSULATION. 6. CONTRACTOR SHALL SUPPLY AND INSTALL ALL NECESSARY SUPPLY DIFFUSERS AND RETURN AIR REGISTERS WHERE INDICATED ON THE DRAWING. COORDINATE LOCATION OF DIFFUSERS AND REGISTERS WITH REFLECTED CEILING PLAN. 7. IN CORRIDORS WHERE CEILING SPEAKERS AND AIR DIFFUSERS ARE INDICATED BETWEEN THE SAME LIGHT FIXTURES, INSTALL BOTH DEVICES AT THE QUARTER POINTS BETWEEN THE FIXTURES. 8. UNLESS OTHERWISE SHOWN, LOCATE ALL ROOM THERMOSTATS 4'-0" (CENTER LINE) ABOVE THE FINISHED FLOOR. NOTIFY THE ENGINEER OF ANY ROOMS WHERE THE PRECEDING LOCATION CANNOT BE MAINTAINED OR WHERE THERE IS A QUESTION ON LOCATION. 9. ALL DUCTWORK SHALL CLEAR DOORS AND WINDOWS. 10. ALL DUCTWORK DIMENSIONS, AS SHOWN ON THE DRAWINGS, ARE INTERNAL CLEAR DIMENSIONS AND DUCT SIZE SHALL BE INCREASED TO COMPENSATE FOR DUCT LINING THICKNESS. 11. PROVIDE ALL 90-DEGREE SQUARE ELBOWS WITH DOUBLE RADIUS TURNING VANES UNLESS OTHERWISE INDICATED. ELBOWS IN DISHWASHER, KITCHEN, AND LAUNDRY EXHAUSTS SHALL BE OF UN-VANED SMOOTH RADIUS CONSTRUCTION WITH A RADIUS EQUAL TO 1-1/2 TIMES THE WIDTH OF THE DUCT. PROVIDE ACCESS DOORS UPSTREAM OF ALL ELBOWS WITH TURNING VANES. 12. COORDINATE DIFFUSER, REGISTER, AND GRILL LOCATIONS WITH ARCHITECTURAL REFLECTED CEILING PLANS, LIGHTING, AND OTHER CEILING ITEMS AND MAKE MINOR DUCT MODIFICATIONS TO SUIT. 13. ALL AIR HANDLING UNITS SHALL OPERATE WITHOUT MOISTURE CARRYOVER. 14. LOCATE ALL MECHANICAL EQUIPMENT FOR UNOBSTRUCTED ACCESS TO UNIT ACCESS PANELS, CONTROLS, AND VALVING. 15. PROVIDE FLEXIBLE CONNECTIONS IN ALL DUCTWORK SYSTEMS (SUPPLY, RETURN, AND EXHAUST) CONNECTED TO AIR HANDLING UNITS, FANS, AND OTHER EQUIPMENT THAT REQUIRE VIBRATION ISOLATION. FLEXIBLE CONNECTIONS SHALL BE PROVIDED AT THE POINT OF CONNECTION TO THE EQUIPMENT UNLESS OTHERWISE INDICATED. 16. UNLESS OTHERWISE NOTED, ALL DUCTWORK IS OVERHEAD, TIGHT TO THE UNDERSIDE OF THE STRUCTURE, WITH SPACE FOR INSULATION IF NEEDED. 17. RUNS OF FLEXIBLE DUCT SHALL NOT EXCEED 5 FT. 18. ALL DUCTWORK SHALL BE COORDINATED WITH ALL TRADES INVOLVED. OFFSETS IN DUCTS, INCLUDING DIVIDED DUCTS AND TRANSITIONS AROUND OBSTRUCTIONS, SHALL BE PROVIDED AT NO ADDITIONAL COST TO THE OWNER. 19. PROVIDE ACCESS DOORS IN DUCTWORK TO PROVIDE ACCESS FOR ALL SMOKE DETECTORS, FIRE DAMPERS, SMOKE DAMPERS, VOLUME DAMPERS, COILS, AND OTHER ITEMS LOCATED IN THE DUCTWORK THAT REQUIRE SERVICE AND/OR INSPECTION. 20. PROVIDE ACCESS DOORS IN DUCTWORK FOR THE OPERATION, ADJUSTMENT, AND MAINTENANCE OF ALL FANS, VALVES, AND MECHANICAL EQUIPMENT. 21. ALL DUCTS SHALL BE GROUNDED ACROSS FLEXIBLE CONNECTIONS WITH FLEXIBLE COPPER GROUNDING STRAPS. GROUNDING STRAPS SHALL BE BOLTED OR SOLDERED TO BOTH THE EQUIPMENT AND THE DUCT. 22. SMOKE DETECTORS SHALL BE FURNISHED AND WIRED BY THE ELECTRICAL CONTRACTOR. THE MECHANICAL CONTRACTOR SHALL BE RESPONSIBLE FOR MOUNTING THE SMOKE DETECTOR IN DUCTWORK AS SHOWN ON THE DRAWINGS AND IN ACCORDANCE WITH THE MANUFACTURER'S PRINTED INSTRUCTIONS. 23. SEE SPECIFICATIONS FOR DUCTWORK GAUGES, BRACING, HANGERS, AND OTHER REQUIREMENTS. 24. EXTERIOR LOUVERS ARE INDICATED FOR SIZE, GENERAL LOCATION AND PERFORMANCE ONLY. DETAILED LOUVER DESCRIPTIONS ARE PROVIDED IN THE ARCHITECTURAL SPECIFICATIONS.	6. ALL VALVES (EXCEPT CONTROL VALVES) AND STRAINERS SHALL BE THE FULL SIZE OF THE PIPE BEFORE REDUCING IN SIZE TO MAKE CONNECTIONS TO EQUIPMENT AND CONTROLS. 7. INSTALL ALL PIPING WITHOUT FORCING OR SPRINGING. 8. ALL PIPING SHALL CLEAR DOORS AND WINDOWS. 9. ALL VALVES SHALL BE ADJUSTED FOR SMOOTH AND EASY OPERATION. 10. ALL PIPING SHALL BE COORDINATED WITH ALL TRADES INVOLVED. OFFSETS IN PIPING AROUND OBSTRUCTIONS SHALL BE PROVIDED AT NO ADDITIONAL COST TO THE OWNER. 11. SLOPED REFRIGERANT PIPING 1% IN THE DIRECTION OF OIL RETURN. LIQUID LINES MAY BE INSTALLED LEVEL. 12. INSTALL HORIZONTAL REFRIGERANT HOT GAS DISCHARGE PIPING WITH 1/2" PER 10 FT. DOWNWARD SLOPE AWAY FROM THE COMPRESSOR. 13. INSTALL HORIZONTAL REFRIGERANT SUCTION LINES WITH 1/2" PER 10 FT. DOWNWARD SLOPE TO THE COMPRESSOR, WITH NO LONG TRAPS OR DEAD ENDS THAT MAY CAUSE OIL TO SEPARATE FROM THE SUCTION GAS AND RETURN TO THE COMPRESSOR IN DAMAGING SLUGS. 14. PROVIDE LINE SIZE LIQUID INDICATORS IN THE MAIN LIQUID LINE LEAVING THE CONDENSER OR RECEIVER. INSTALL MOISTURE-LIQUID INDICATORS IN LIQUID LINES BETWEEN FILTER DRYERS AND THERMOSTATIC EXPANSION VALVES, AND IN LIQUID LINE TO RECEIVER. 15. PROVIDE A LINE SIZE STRAINER UPSTREAM OF EACH AUTOMATIC VALVE. PROVIDE A SHUT-OFF VALVE ON EACH SIDE OF A STRAINER. 16. PROVIDE PERMANENT FILTER DRYERS IN LOW-TEMPERATURE SYSTEMS AND SYSTEMS USING HERMETIC COMPRESSORS. 17. PROVIDE REPLACEABLE CARTRIDGE FILTER DRYERS WITH A THREE-VALVE BYPASS ASSEMBLY FOR SOLENOID VALVES, ADJACENT TO RECEIVERS. 18. PROVIDE REFRIGERANT CHARGING VALVE CONNECTIONS IN THE LIQUID LINE BETWEEN THE RECEIVER SHUTOFF VALVE AND THE EXPANSION VALVE.	SECTION 0101 – QUALITY OF WORK 1.1 WORKMANSHIP A. ALL WORK SHALL BE FREE FROM DEFECTS IN MATERIALS AND WORKMANSHIP FOR A PERIOD OF ONE YEAR FROM DATE OF FINAL ACCEPTANCE. B. ALL DEFECTS WHICH DEVELOP OR ARE DISCOVERED WITHIN THIS PERIOD SHALL BE REPAIRED BY THE CONTRACTOR TO THE SATISFACTION OF THE ARCHITECT OR BUILDING MANAGER AT NO ADDITIONAL COST TO THE OWNER. C. UPON COMPLETION OF THE WORK THE CONTRACTOR SHALL REMOVE FROM THE SITE, ALL TOOLS, DEMOLISHED APPLIANCES AND ANY SURPLUS MATERIAL. 1.2 CODE COMPLIANCE A. ALL WORK SHALL MEET ALL STATE AND LOCAL CODES HAVING JURISDICTION. END OF SECTION 0101 SECTION 0102 –REQUIRED DOCUMENTS 1.1 SHOP DRAWINGS A. A SET OF PRINTS FOR ANY MECHANICAL WORK INCLUDING BUT NOT LIMITED TO, DUCTWORK AND PIPING LAYOUT SHALL BE SUBMITTED FOR APPROVAL TO THE ENGINEER PRIOR TO CONSTRUCTION OR PURCHASE OF MATERIALS. 1.2 SUBMITTALS A. EQUIPMENT SUBMITTALS OF ALL PROPOSED MECHANICAL AND ANCILLARY EQUIPMENT INCLUDING ALL ACCESSORIES SHALL BE SUBMITTED TO THE ENGINEER FOR REVIEW. ALL PERTINENT MODELS, SIZES, ACCESSORIES AND CHOICES SHALL BE CLEARLY CHECKED, PRINTED OR OTHERWISE INDICATED ON THE SUBMITTALS. 1.3 RECORD DRAWINGS A. UPON COMPLETION OF THE WORK, A RECORD DRAWING SHALL BE SUBMITTED TO THE OWNER DEPICTING ALL SUBSEQUENT CHANGES, ADDITIONS AND OR CORRECTIONS TO THE CONTRACT DRAWINGS AND OR CONTRACT SCOPE MADE DURING CONSTRUCTION. THIS DRAWING SHALL REPRESENT A COMPLETE RECORD OF THE WORK INSTALLED. 1.4 EQUIPMENT OPERATING INSTRUCTIONS A. ON COMPLETION AND ACCEPTANCE OF WORK, THIS CONTRACTOR SHALL FURNISH WRITTEN INSTRUCTIONS, EQUIPMENT MANUALS AND DEMONSTRATE TO THE OWNER THE PROPER OPERATION AND MAINTENANCE OF ALL EQUIPMENT AND APPARATUS FURNISHED UNDER THIS CONTRACT. B. THESE INSTRUCTIONS SHALL BE TYPED ON 8-1/2 IN. X 11 IN. PAPER AND BOUND IN THREE-RING BINDERS WITH CLEAR ACETATE COVERS. THE CONTRACTOR SHALL GIVE THREE COPIES OF THE INSTRUCTIONS TO THE OWNER AND ONE ELECTRONIC COPY TO THE ENGINEER. C. THE INSTRUCTION BOOKLET SHALL BE ORGANIZED IN SECTIONS, WITH ONE SECTION PER SYSTEM. THE COVER OF THE INSTRUCTION BOOKLET SHALL BEAR THE NAME, ADDRESS AND PHONE NUMBER OF THE PROJECT, ARCHITECT, ENGINEER, MECHANICAL CONTRACTOR AND SUBCONTRACTORS. END OF SECTION 0102 SECTION 078413-PENETRATION FIRE-STOPPING 1.1 QUALITY ASSURANCE A. INSTALLER QUALIFICATIONS: AN FM GLOBAL-APPROVED FIRE-STOP CONTRACTOR OR A UL-QUALIFIED FIRE-STOP CONTRACTOR. B. FIRE-TEST-RESPONSE CHARACTERISTICS: UL, INTERTEK ETL SEMKO OR FM GLOBAL 1.2 PENETRATION FIRESTOPPING A. PENETRATIONS IN FIRE-RESISTANCE-RATED WALLS: F-RATINGS PER ASTM E 814 OR UL 1479. B. PENETRATIONS IN HORIZONTAL ASSEMBLIES: F- AND T-RATINGS PER ASTM E 814 OR UL 1479: C. PENETRATIONS IN SMOKE BARRIERS: L-RATINGS PER UL 1479. D. W-RATINGS: PER UL 1479. 1.3 INSTALLATION A. IDENTIFICATION: PREPRINTED METAL OR PLASTIC LABELS. 1.4 FIELD QUALITY CONTROL A. REPLACE BROKEN AND DAMAGED ESCUTCHEONS AND FLOOR PLATES USING NEW MATERIALS. END OF SECTION 078413 SECTION 230517 – SLEEVES AND SLEEVE SEALS FOR HVAC PIPING 1.1 PERFORMANCE REQUIREMENTS A. DELEGATED DESIGN: DESIGN TRAPEZE PIPE HANGERS AND EQUIPMENT SUPPORTS, INCLUDING COMPREHENSIVE ENGINEERING ANALYSIS BY A QUALIFIED PROFESSIONAL ENGINEER, USING PERFORMANCE REQUIREMENTS AND DESIGN CRITERIA INDICATED. B. STRUCTURAL PERFORMANCE: HANGERS AND SUPPORTS FOR HVAC PIPING AND EQUIPMENT SHALL WITHSTAND THE EFFECTS OF GRAVITY LOADS AND STRESSES WITHIN LIMITS AND UNDER CONDITIONS INDICATED ACCORDING TO ASCE/SEI 7. 1. DESIGN SUPPORTS FOR MULTIPLE PIPES CAPABLE OF SUPPORTING COMBINED WEIGHT OF SUPPORTED SYSTEMS, SYSTEM CONTENTS, AND TEST WATER. 2. DESIGN EQUIPMENT SUPPORTS CAPABLE OF SUPPORTING COMBINED OPERATING WEIGHT OF SUPPORTED EQUIPMENT AND CONNECTED SYSTEMS AND
REVISION SCHEDULE NO. REV. / SUBMISSION DATE ISSUED BY PERMIT SET 06/21/22 NYE ISSUE DATE: 4/6/2022 5:19:23 PM RENOVATION FOUR STAR MUSHROOMS DRAWN BY: NYE QAQC: APPROVED BY: NYE PROJECT NUMBER: 2206 GENERAL HVAC NOTES & MECHANICAL SPECIFICATIONS MO.2				

HVAC DUCTWORK -- SHEET METAL

3.DESIGN SEISMIC-RESTRAINT HANGERS AND SUPPORTS FOR PIPING AND EQUIPMENT AND OBTAIN APPROVAL FROM AUTHORITIES HAVING JURISDICTION.

- 1.2 SUBMITTALS
- A. SHOP DRAWINGS: SIGNED AND SEALED BY A PROFESSIONAL ENGINEER
- 1.3 QUALITY ASSURANCE
- A. AWS D1.1/D1.1M, "STRUCTURAL WELDING CODE – STEEL."
- 1.4 COMPONENTS
- A. METAL PIPE HANGERS AND SUPPORTS: CARBON OR STAINLESS STEEL
- B. TRAPEZE PIPE HANGERS: CARBON OR STAINLESS STEEL
- C. FIBERGLASS PIPE HANGERS: –CLEVIS, CENTURY COMPOSITES, COOPER B–LINE
- D. METAL FRAMING SYSTEMS: MFMA MANUFACTURER
- E. FIBERGLASS STRUT SYSTEMS: COOPER B–LINE
- F. THERMAL–HANGER SHIELD INSERTS:
- G. FASTENER SYSTEMS: POWDER–ACTUATED FASTENERS OR MECHANICAL–EXPANSION ANCHORS
- H. PIPE STANDS: COMPACT, LOW TYPE, SINGLE PIPE, HIGH TYPE, SINGLE PIPE, HIGH TYPE, MULTIPLE PIPES, CURB–MOUNTED TYPE
- I. EQUIPMENT SUPPORTS.
- END OF SECTION 230529

SECTION 230548 – VIBRATION CONTROLS FOR HVAC PIPING AND EQUIPMENT

PART 1 – GENERAL

- 1.1 COMPONENTS
- A. VIBRATION ISOLATORS:
1. ISOLATOR PADS: NEOPRENE, RUBBER, HERMETICALLY AND/OR SEALED COMPRESSED FIBERGLASS
2. MOUNTS: DOUBLE–DEFLECTION TYPE.
3. RESTRAINED MOUNTS: ALL DIRECTIONAL MOUNTINGS WITH SEISMIC RESTRAINT; CAST–DUCTILE–IRON HOUSING.
4. SPRING ISOLATORS: FREESTANDING, Laterally STABLE, OPEN–SPRING TYPE.
5. RESTRAINED SPRING ISOLATORS: FREESTANDING, STEEL, OPEN–SPRING TYPE WITH SEISMIC RESTRAINT.
6. HOUSED SPRING MOUNTS: DUCTILE–IRON OR STEEL HOUSING, WITH INTEGRAL, VERTICALLY ADJUSTABLE SEISMIC SNUBBERS.
7. ELASTOMERIC HANGERS: DOUBLE–DEFLECTION TYPE.
8. SPRING HANGERS: COMBINATION COIL–SPRING AND ELASTOMERIC–INSERT HANGERS WITH SPRING AND INSERT IN COMPRESSION.
9. SPRING HANGERS WITH VERTICAL–LIMIT STOP: COMBINATION COIL–SPRING AND ELASTOMERIC–INSERT HANGERS WITH SPRING AND INSERT IN COMPRESSION AND WITH VERTICAL–LIMIT STOP.
10. PIPE RISER RESILIENT SUPPORT: ALL–DIRECTIONAL, ACOUSTICAL PIPE ANCHOR.
11. RESILIENT PIPE GUIDES.
- B. AIR–MOUNTING SYSTEMS:
1. AIR MOUNTS: FREESTANDING, SINGLE OR MULTIPLE, COMPRESSED–AIR BELLOW.
2. RESTRAINED AIR MOUNTS: HOUSED COMPRESSED–AIR BELLOW.
- C. RESTRAINED VIBRATION ISOLATION ROOF–CURB RAILS: FACTORY–ASSEMBLED, FULLY ENCLOSED, INSULATED, AIR–AND WATERTIGHT CURB RAIL; WITH SPRING ISOLATORS MOUNTED ON ELASTOMERIC ISOLATION PADS, AND SNUBBER BUSHINGS.
- D. VIBRATION ISOLATION EQUIPMENT BASES:
1. STEEL BASE: FACTORY–FABRICATED, WELDED, STRUCTURAL–STEEL BASES AND RAILS.
2. INERTIA BASE: FACTORY–FABRICATED, WELDED, STRUCTURAL–STEEL BASES AND RAILS READY FOR FIELD–APPLIED, CAST–IN–PLACE CONCRETE

- 1.2 FIELD QUALITY CONTROL
- A. TESTING: BY EITHER: OWNER–ENGAGED AGENCY, CONTRACTOR–ENGAGED AGENCY, OR CONTRACTOR.

- PART–2 PRODUCTS
- 1.1 VIBRATION ISOLATORS & SEISMIC–RESTRAINT DEVICES
- A. AVAILABLE MANUFACTURERS: SUBJECT TO COMPLIANCE WITH REQUIREMENTS, MANUFACTURERS OFFERING PRODUCTS THAT MAY BE INCORPORATED INTO THE WORK INCLUDE, BUT ARE NOT LIMITED TO, THE FOLLOWING:
- B. MANUFACTURERS: SUBJECT TO COMPLIANCE WITH REQUIREMENTS, PROVIDE PRODUCTS BY ONE OF THE FOLLOWING:
1. ACE MOUNTINGS CO., INC.
2. AMBER/BOOTH COMPANY, INC.
3. CALIFORNIA DYNAMICS CORPORATION.
4. HILTI, INC.
5. ISOLATION TECHNOLOGY, INC.
6. KINETICS NOISE CONTROL.
7. LOOS & CO.; CABLEWARE DIVISION.
8. MASON INDUSTRIES.
9. TOLCO INCORPORATED; A BRAND OF NIBCO INC.
10. UNISTRUT; TYCO INTERNATIONAL, LTD.

END OF SECTION 230548

SECTION 230593 – TESTING, ADJUSTING, AND BALANCING FOR HVAC

1.1 SUMMARY

- A. TESTING, ADJUSTING, AND BALANCING FOR THE FOLLOWING:
1. AIR SYSTEMS: CONSTANT–VOLUME SYSTEMS AND VARIABLE VOLUME.
2. MOTORS.
3. CONDENSING UNITS.
4. EXISTING SYSTEMS.

- 1.2 QUALITY ASSURANCE
- A. THE CONTRACTOR SHALL PROCURE THE SERVICES OF A TESTING, ADJUSTING AND BALANCING (TAB) SPECIALIST WHO SPECIALIZES IN HEATING, VENTILATION AND AIR CONDITIONING SYSTEMS. THE TAB AGENT SHALL HAVE THE FOLLOWING QUALIFICATIONS: AABC, NEBB OR TABB CERTIFIED.

- 1.3 EXECUTION
- A. THE TAB SPECIALIST SHALL PERFORM FLOW MEASUREMENTS OF ALL EXISTING AIR AND HYDRONIC SYSTEMS THAT ARE TO REMAIN OR TO BE INCORPORATED INTO NEW WORK PRIOR TO THE STARTING OF WORK IN THE PROJECT SCOPE. A REPORT OF THESE MEASUREMENTS, INDICATING ANY AND ALL DEFICIENCIES SHALL BE SUBMITTED FOR OWNER REVIEW.
- B. THE TAB SPECIALIST SHALL PERFORM FLOW MEASUREMENTS OF ALL NEW AIR AND HYDRONIC SYSTEMS AS LISTED ABOVE IN THE PROJECT SCOPE. A REPORT OF THESE MEASUREMENTS, INDICATING ANY AND ALL DEFICIENCIES SHALL BE SUBMITTED FOR OWNER REVIEW.
- C. THE REPORT SHALL INDICATE A SCHEMATIC DIAGRAM INDICATING LOCATIONS OF ALL EQUIPMENT TESTED AND MEASUREMENT LOCATIONS.
- D. PRIOR TO FINAL INSPECTION OF THE WORK, THE TAB SPECIALIST SHALL BALANCE ALL SYSTEMS AS INDICATED ABOVE TO THE REQUIREMENTS OF THE DESIGN.
- E. THE CONTRACTOR SHALL HAVE FURNISH AND INSTALL ALL ADDITIONAL BALANCING EQUIPMENT, PRESSURE TAPS, GAUGES AND OTHER EQUIPMENT AS REQUIRED FOR A PROPERLY BALANCED SYSTEM AT NO ADDITIONAL COST TO THE OWNER. SUCH ADDITIONAL EQUIPMENT SHALL ADHERE IN STRICT ACCORDANCE WITH THE RESPECTIVE EQUIPMENT MANUFACTURER'S RECOMMENDATIONS.
- F. THE CONTRACTOR SHALL HAVE THE TESTING AND BALANCING SPECIALIST COORDINATE ALL WORK OF THIS S3ECTION WITH THE BUILDING MANAGER. BALANCING WORK SHALL NOT CONFLICT WITH OTHER WORK SO AS TO MAINTAIN COMPLETION WITHIN THE SPECIFIED TIME.
- G. ALL INSTRUMENTS USED FOR TAB SHALL BE MAINTAINED IN GOOD WORKING CONDITION AND ACCURATELY CALIBRATED.
- H. TOLERANCES: PLUS OR MINUS 5 PERCENT OF DESIGN VALUES.
- I. INSPECTIONS: RANDOM CHECKS BY OWNER OR ARCHITECT TO VERIFY FINAL TESTING, ADJUSTING, AND BALANCING REPORT.
- J. ADDITIONAL TESTS: RANDOM TESTS WITHIN 90 DAYS OF COMPLETING TAB TO VERIFY BALANCE CONDITIONS AND SEASONAL TESTS.

END OF SECTION 230593

SECTION 230713 – DUCT INSULATION

- 1.1 QUALITY ASSURANCE
- SURFACE–BURNING CHARACTERISTICS: ALL INSULATION SHALL HAVE COMPOSITE (INSULATION JACKET OR FACING AND ADHESIVE USED TO ADHERE THE FACING OR JACKET TO THE INSULATION) A FLAME–SPREAD INDEX OF 25, AND SMOKE–DEVELOPED INDEX OF 50 FOR INSULATION INSTALLED INDOOR, 75, AND SMOKE–DEVELOPED INDEX OF 50 FOR INSULATION INSTALLED OUTDOORS; ACCORDING TO ASTM E 84.
- 1.2 FIELD QUALITY CONTROL
- A. FIELD INSPECTIONS: BY OWNER–ENGAGED AGENCY.
- 1.3 INDOOR DUCT AND PLENUM INSULATION SCHEDULE;
- A. CONCEALED, RECTANGULAR, ROUND AND FLAT–OVAL, SUPPLY–RETURN, OUTDOOR–AND EXHAUST–AIR DUCT AND AIR PLENUM INSULATION:
- B. FLEXIBLE ELASTOMERIC, MINERAL–FIBER BLANKET, MINERAL–FIBER BOARD OR POLYOLEFIN WITH MINIMUM INSTALLED THERMAL RESISTANCE AS FOLLOWS: UNCONDITIONED SPACES WITHIN BUILDING: R–6 WITHIN BUILDING ENVELOPE ASSEMBLY: R–12 OUTSIDE OF BUILDING: R–12

- 1.4 ITEMS NOT INSULATED:
1. FIBROUS–GLASS DUCTS.
2. METAL DUCTS WITH DUCT LINER OR SUFFICIENT THICKNESS TO COMPLY WITH ENERGY CODE ANDASHRAE/IESNA 90.1.
3. FACTORY–INSULATED FLEXIBLE DUCTS.
4. FACTORY–INSULATED PLENUMS AND CASINGS.
5. FLEXIBLE CONNECTORS.
6. VIBRATION–CONTROL DEVICES.
7. FACTORY–INSULATED ACCESS PANELS AND DOORS.
8. DUCTS THAT HAVE INTERNAL ACOUSTICAL LINING.

- 1.5 PRODUCTS
- A. THE FOLLOWING INSULATION MANUFACTURERS WILL BE ACCEPTABLE:
1. JOHNS–MANVILLE
2. OWENS–CORNING

- 1.6 ACOUSTICAL TREATMENT

1. WHERE SHOWN ON THE DRAWINGS, LOW PRESSURE DUCTWORK SHALL BE LINED WITH 1.5" THICK R–6 AS MANUFACTURED BY DUCTMATE, 1–1/2 POUND MINIMUM DENSITY, NEOPRENE COATED, FLEXIBLE FIBERGLASS DUCT LINER, LINING SHALL COMPLY WITH NFPA 90A AND SHALL HAVE A FLAME SPREAD CLASSIFICATION OF NOT MORE THAN 25 AND A SMOKE DEVELOPED RATING NOT MORE THAN 50. DUCT SIZES WHERE LINING IS INDICATED ON PLANS ARE MINIMUM INSIDE CLEAR DIMENSIONS REQUIRED,

END OF SECTION 230713

SECTION 233113 – METAL DUCTS

- 1.1 CONSTRUCTION
- A. EACH DUCT SYSTEM SHALL BE CONSTRUCTED FOR THE SPECIFIC SMACNA DUCT PRESSURE CLASSIFICATIONS SHOWN ON THE CONTRACT DRAWINGS. WHERE NO PRESSURE CLASSES ARE SPECIFIED BY THE DESIGNER, THE SMACNA 2–1/2 INCH WG PRESSURE CLASS IS THE BASIS OF COMPLIANCE WITH THESE STANDARDS, REGARDLESS OF THE VELOCITY IN THE DUCT.
- B. ALL DUCTWORK SHALL BE CONSTRUCTED TO SMACNA 2" WG DESIGN AND NOT LESS THAN THE FOLLOWING STANDARDS:
1. DUCTWORK SHALL BE TRANSVERSELY JOINTED BY CONNECTING SEAMS OF COMPANION ANGLES, FORMED FROM 1–1/2"x1–1/2"x1/8" GALVANIZED ANGLES, TACK–WELDED OR RIVETED TO THE DUCT. THE ANGLE FRAME SHALL BE CONTINUOUSLY FLANGED UP INTO UPRIGHT OF ANGLE AND EACH CORNER SHALL BE FILLED IN AND GROUND SMOOTH. JOINTS SHALL BE GASKETED WITH 1/8" THICK REINFORCED GASKET, OVERLAPPED AT CORNERS, GASKET SIMILAR TO 3M–1202 OR APPROVED EQUAL.
2. RECTANGULAR FITTINGS AND ALL TRANSITION PIECES FROM RECTANGULAR TO ROUND SHALL BE NO. 16 GAUGE ALL WELDED CONSTRUCTION.
3. HORIZONTAL DUCTS SHALL BE SUPPORTED ON NOT MORE THAN 6' CENTERS. VERTICAL RISERS SHALL BE SUPPORTED AT EACH FLOOR.
4. LONGITUDINAL SEAMS FOR RECTANGULAR DUCTWORK SHALL BE PITTSBURGH LOCK SEAMS WITH SEALING COMPOUND, EQUAL TO BENJAMIN FOSTER NO. 30–03 INSERTED INTO SEAM. ALL SEAMS SHALL BE BRUSHED WITH NO. 30–02 AND COVERED WITH APPROVED SEALING TAPE.
5. RECTANGULAR DUCTWORK 18 GAUGE AND HEAVIER, FILLER RODS SHALL BE IN ACCORDANCE WITH SPECIFICATIONS FOR IRON AND STEEL GAS WELDING RODS, ASTM 215; AWG A5.2.
6. ALL FITTINGS SUCH AS ELBOWS, TEES, ETC., SHALL BE NO. 20 GAUGE ZINC COATED STEEL ELBOWS SHALL BE OF FIVE (5) PIECE WELDED AIRTIGHT CONSTRUCTION.
- C. WHERE LATEST EDITION OF SMACNA DOES NOT CLEARLY STATE GAUGES AND/OR STIFFENERS TO BE USED OR, WHERE SMACNA STANDARDS REQUIRE INTERPRETATION, THE FOLLOWING MINIMUM METAL GAUGES AND BRACING SHALL BE USED:

USG	MAX. SIDE INCHES	TRANSVERSE JOINTS AND BRACING
22	UP TO 12	S SLIP, DRIVE SLIP, ONE INCH POCKET LOCK ON 8 FOOT CENTERS
22	13 TO 24	1"x1"x1/8" ANGLES ON 4 FOOT CENTERS
20	25 TO 35	1"x1"x1/8" ANGLES ON 2 FOOT CENTERS

- D. PROVIDE TAPPING IN DUCTS FOR THERMOMETERS WHERE SPECIFIED. IN ADDITION, PROVIDE AN AIRTIGHT PLUGGED TAPPING LOCATED AS FOLLOWS:

1. UPSTREAM OF EACH REHEAT COIL AND VAV BOX.
2. DOWNSTREAM OF EACH REHEAT COIL AND VAV BOX.

- E. FLAT OVAL OR ROUND DUCTWORK MAY BE PROVIDED IN LIEU RECTANGULAR DUCTWORK WITH THE REINFORCEMENT FOR FLAT SIDES SAME AS SPECIFIED FOR THE RECTANGULAR DUCTWORK, AND AS PER SMACNA FLAT OVAL DUCT CONSTRUCTION STANDARDS SHOWN IN FIG. 3–6 AND AS SHOWN IN FIG. 3–1 AND 3–2 FOR ROUND DUCTWORK.

- F. ALL DUCTWORK SHALL BE SEALED TO CLASS "A" AND LEAK TESTED TO MEAT SMACNA CLASS 6 FOR RECTANGULAR AND CLASS 3 FOR ROUND DUCTS.

- 1.2 MATERIALS
- A. SINGLE–WALL RECTANGULAR DUCTS AND FITTINGS.
- B. SINGLE–WALL ROUND AND FLAT–OVAL DUCTS AND FITTINGS.
- C. SHEET METAL MATERIALS:
1. GALVANIZED SHEET STEEL.
2. STAINLESS–STEEL SHEETS.
3. ALUMINUM SHEETS.
4. FACTORY–APPLIED ANTI–MICROBIAL COATING.

- D. DUCT LINER:
1. FIBROUS GLASS, TYPE I, FLEXIBLE.
- a. WITH ANTI–MICROBIAL EROSION–RESISTANT COATING.
2. FLEXIBLE ELASTOMERIC.
3. NATURAL FIBER.

- E. SEALANT MATERIALS:

1. TWO–PART TAPE SEALING SYSTEM.
2. WATER–BASED JOINT AND SEAM SEALANT.
3. SOLVENT–BASED JOINT AND SEAM SEALANT.
4. FLANGED JOINT SEALANT.
5. FLANGE GASKETS.
6. ROUND DUCT JOINT O–RING SEALS.

- 1.3 DUCT CLEANING
- A. CLEAN EXISTING DUCT SYSTEM(S) BEFORE TESTING, ADJUSTING, AND BALANCING.
- B. CLEAN THE FOLLOWING ITEMS:

1. AIR OUTLETS AND INLETS.
2. SUPPLY, RETURN, AND EXHAUST FANS.
3. AIR–HANDLING UNITS.
4. COILS AND RELATED COMPONENTS.
5. RETURN–AIR DUCTS, DAMPERS, ACTUATORS, AND TURNING VANES.
6. SUPPLY–AIR DUCTS, DAMPERS, ACTUATORS, AND TURNING VANES.
7. DEDICATED EXHAUST AND VENTILATION COMPONENTS AND MAKEUP AIR SYSTEMS.

- 1.4 DUCT SCHEDULE
- A. ALL DUCTS SHALL BE GALVANIZED STEEL EXCEPT AS FOLLOWS:
8. MOIST ENVIRONMENT DUCT MATERIAL: ALUMINUM.

END OF SECTION 233113

SECTION 233713 – DIFFUSERS, REGISTERS, AND GRILLES

- 1.1 PRODUCTS
- A. DIFFUSERS, REGISTERS AND GRILLES SHALL BE FURNISHED AND INSTALLED FOR CAPACITIES AND IN LOCATIONS INDICATED ON DRAWINGS. ALL REGISTERS AND DIFFUSERS SHALL BE PRIME COATED STEEL OR EXTRUDED ALUMINUM FINISHED UNLESS OTHERWISE NOTED IN BAKED WHITE ENAMEL.
- B. MANUFACTURERS: TITUS
1. SUBJECT TO COMPLIANCE WITH REQUIREMENTS, PROVIDE PRODUCT BY ONE OF THE FOLLOWING:
- a. CARNES.
- b. HART & COOLEY INC.
- c. KRUEGER.
- d. METALAIRE, INC.
- e. NAILOR INDUSTRIES INC.
- C. ALL DIFFUSERS SHALL HAVE CONTROLLING/EQUALIZING GRID AND OPPOSED BLADE DAMPER UNLESS OTHERWISE NOTED.
- D. ALL DUCTED RETURN REGISTERS SHALL HAVE AN OPPOSED BLADE DAMPER UNLESS OTHERWISE NOTED.

END OF SECTION 233713

PIPING INSULATION

- A. INSULATE ALL PIPING IN ACCORDANCE WITH INSULATION SCHEDULE EXCEPT AS OTHERWISE NOTED.

SERVICE	INSULATION SCHEDULE – PIPING	
	SIZE	THICKNESS MATERIAL FINISH

- REFRIGERANT PIPING 1.5" P–6
- CONDENSER DRAIN PIPING 1.0" P–6
- (IF RUNNING THROUGH EXTERIOR WALL)
- B. PIPING, VALVES AND FITTINGS TO BE INSULATED:

- 1) LOW TEMPERATURE PIPING SYSTEMS – 0 TO 55 DEG F INCLUDING:
- a. CHILLED WATER SUPPLY AND RETURN.
- b. CONDENSER WATER SUPPLY AND RETURN.
- c. CONDENSATE DRAIN PIPING.

- 2) LOW TEMPERATURE PIPING SYSTEMS – 0 TO 55 DEG F INCLUDING:
- a. GLYCOL WATER SUPPLY AND RETURN.

- 3) LOW TEMPERATURE HOT PIPING SYSTEMS – 100 TO 200 DEG F INCLUDING:
- a. LOW TEMPERATURE HOT WATER SUPPLY AND RETURN.
- b. PUMPED CONDENSATE DISCHARGE.

- 4) PROTECTIVE COVERINGS SHALL BE INSTALLED ON AREAS OF INSULATION THAT ARE EXPOSED TO WEATHER OR SUBJECT TO MECHANICAL DAMAGE. THE PROTECTIVE COVERING SHALL BE:

- a. ARMA–CHEK SILVER" MULTI–LAYER LAMINATE OF ALUMINUM, COATED WITH A UV PROTECTIVE FILM AND BACKED WITH A FLEXIBLE PVC FILM. THE MATERIAL SHOULD BE ADHERED WITH ARMAFLEX 820 ADHESIVE OR EQUIVALENT, AND ALL JOINS AND SEAMS SECURED WITH "ARMA–CHEK SILVER TAPE". INSTALLATION SHALL BE IN ALL CASES TO THE MANUFACTURER'S RECOMMENDATIONS.
- OR
- b. HIGH DENSITY RUBBER CLADDING OF THE "ARMA–CHECK R" TYPE BONDED USING AN APPROPRIATE FULL CONTACT ADHESIVE WITH A MINIMUM 50 MM OVERLAP AT ALL BUTT JOINTS AND LONGITUDINAL SEAMS. A WEATHER–PROOF MASTIC SEALANT SHALL BE APPLIED OVER ALL SEAMS AND JOINTS. ALL MATERIAL SHALL BE OVERLAPPED AND STAGGERED IN SUCH A WAY AS TO ENSURE A WATERSHED IS ALWAYS PROVIDED. INSTALLATION SHALL BE IN ALL CASES TO THE MANUFACTURER'S RECOMMENDATIONS. ALL EXCESS ADHESIVE VISIBLE ON THE SURFACE OF THE COMPLETED ASSEMBLY SHALL BE REMOVED USING AN APPROPRIATE CLEANING MATERIAL.
- OR
- c. METAL CLADDING, COMPRISED OF COATED SHEET METAL, WITH ALL EXTERNAL JOINTS AND FIXING MADE WEATHER–PROOF WITH SILICONE SEALANT.

- C. MATERIAL:
- 1) TYPE P–1: MINIMUM 4 LB DENSITY MOLDED FIBERGLASS, MAXIMUM 0.24 K–FACTOR AT 75 DEG F MEAN TEMPERATURE WITH FACTORY–APPLIED FIRE–RETARDANT FOIL–SKRIM–KRAFT FACING. ALL SERVICE JACKET. SIMILAR TO OWENS–CORNING 650 ASJ.

- 2) TYPE P–3: MINIMUM 4 LB DENSITY MOLDED FIBERGLASS FITTING, MAXIMUM 0.23 K–FACTOR AT 75 DEG F MEAN TEMPERATURE SIMILAR TO EPOLUX HAMFAB MOLDED FITTINGS.

- 3) TYPE P–4: MINIMUM 1 LB DENSITY FIBERGLASS FITTING INSERTS, MAXIMUM 0.27 K–FACTOR AT 75 DEG F MEAN TEMPERATURE SIMILAR TO MANVILLE HI–LO TEMP INSULATION INSERTS.

- 4) TYPE P–6: MINIMUM 6 LB MOLDED FOAMED PLASTIC. MAXIMUM 0.27 K–FACTOR AT 75 DEG F MEAN TEMPERATURE. MAXIMUM 0.17 PERMEANCE. SIMILAR TO ARMSTRONG ARMAFLEX II.

- D. FINISH:

- 1) TYPE F–1: FITTING COVER, MOLDED WHITE PVC JACKET, UL CLASS 1, MAXIMUM PERMEANCE 0.05 SIMILAR TO MANVILLE ZESTRON.

- 2) TYPE F–2: WHITE VAPOR BARRIER COATING WITH 10X10 OR 20X20 MESH WHITE GLASS, POLYESTER OR NYLON CLOTH REINFORCING MEMBRANE, MINIMUM 31 MIL DRY FILM THICKNESS, SIMILAR TO FOSTER TITE–FIT, UL LABEL.

- 3) TYPE F–4: ALUMINUM JACKETING WITH MINIMUM 0.016 IN. WALL THICKNESS AND LONGITUDINAL JOINTS WITH LOCK SEAMS.

- 4) TYPE F–6: WHITE FINISHING AND INSULATING CEMENT APPLIED OVER HEXAGONAL WIRE MESH. CEMENT SIMILAR TO KEENE SUPERSLICK.

- E. INSTALLATION:

- 3) BEFORE APPLYING INSULATION ALL PRESSURE AND LEAK TESTS SHALL BE COMPLETED AND APPROVED.

- 4) ALL INSULATION AND VAPOR BARRIERS SHALL BE CONTINUOUS PASSING THROUGH SLEEVES, HANGERS, ETC., OR OTHER OPENINGS. PROVIDE SADDLES OR SHIELDS FOR PROTECTION AT ALL HANGINGS.

- 5) INSULATION FOR STRAINERS OR OTHER FITTINGS OR ACCESSORIES REQUIRING SERVICING OR INSPECTION SHALL HAVE INSULATION REMOVABLE AND REPLACEABLE WITHOUT DAMAGE.

THERMOSTATIC CONTROLS:

- A. GENERAL:
- THE SUPPLY OF HEATING AND COOLING ENERGY TO EACH ZONE SHALL BE INDIVIDUALLY CONTROLLED BY THERMOSTATIC CONTROLS RESPONDING TO TEMPERATURE WITHIN THE ZONE. FOR THE PURPOSES OF SECTION 6.4.3.1, A DWELLING UNIT SHALL BE PERMITTED TO BE CONSIDERED A SINGLE ZONE.

- B. DEAD BAND:
- WHERE USED TO CONTROL BOTH HEATING AND COOLING, ZONE THERMOSTATIC CONTROLS SHALL BE CAPABLE OF PROVIDING A TEMPERATURE RANGE OR DEAD BAND OF AT LEAST 5°F WITHIN WHICH THE SUPPLY OF HEATING AND COOLING ENERGY TO THE ZONE IS SHUT OFF OR REDUCED TO A MINIMUM.

- C. SETBACK CONTROLS:
- THERMOSTATIC SETBACK CONTROLS SHALL BE CONFIGURED TO SET BACK OR TEMPORARILY OPERATE THE SYSTEM TO MAINTAIN ZONE TEMPERATURES DOWN TO 55°F (13°C) OR UP TO 85°F (29°C).

- D. AUTOMATIC SETBACK AND SHUTDOWN.
- AUTOMATIC TIME CLOCK OR PROGRAMMABLE CONTROLS SHALL BE CAPABLE OF STARTING AND STOPPING THE SYSTEM FOR SEVEN DIFFERENT DAILY SCHEDULES PER WEEK AND RETAINING THEIR PROGRAMMING AND TIME SETTING DURING A LOSS OF POWER FOR NOT FEWER THAN 10 HOURS. ADDITIONALLY, THE CONTROLS SHALL HAVE A MANUAL OVERRIDE THAT ALLOWS TEMPORARY OPERATION OF THE SYSTEM FOR UP TO 2 HOURS; A MANUALLY OPERATED TIMER CONFIGURED TO OPERATE THE SYSTEM FOR UP TO 2 HOURS; OR AN OCCUPANCY SENSOR.

- E. HEAT PUMP SUPPLEMENTARY HEAT :
- HEAT PUMPS HAVING SUPPLEMENTARY ELECTRIC RESISTANCE HEAT SHALL HAVE CONTROLS THAT, EXCEPT DURING DEFROST, PREVENT SUPPLEMENTARY HEAT OPERATION WHERE THE HEAT PUMP CAN PROVIDE THE HEATING LOAD.

REVISION SCHEDULE		
NO. REV.	/ SUBMISSION DATE	ISSUED BY
	PERMIT SET	06/21/22 NYE

ISSUE DATE: 4/6/2022 5:19:23 PM

RENOVATION

FOUR STAR MUSHROOMS

DRAWN BY: NYE



QAQC:

APPROVED BY: NYE

PROJECT NUMBER: 2206

MECHANICAL SPECIFICATIONS

MO.3

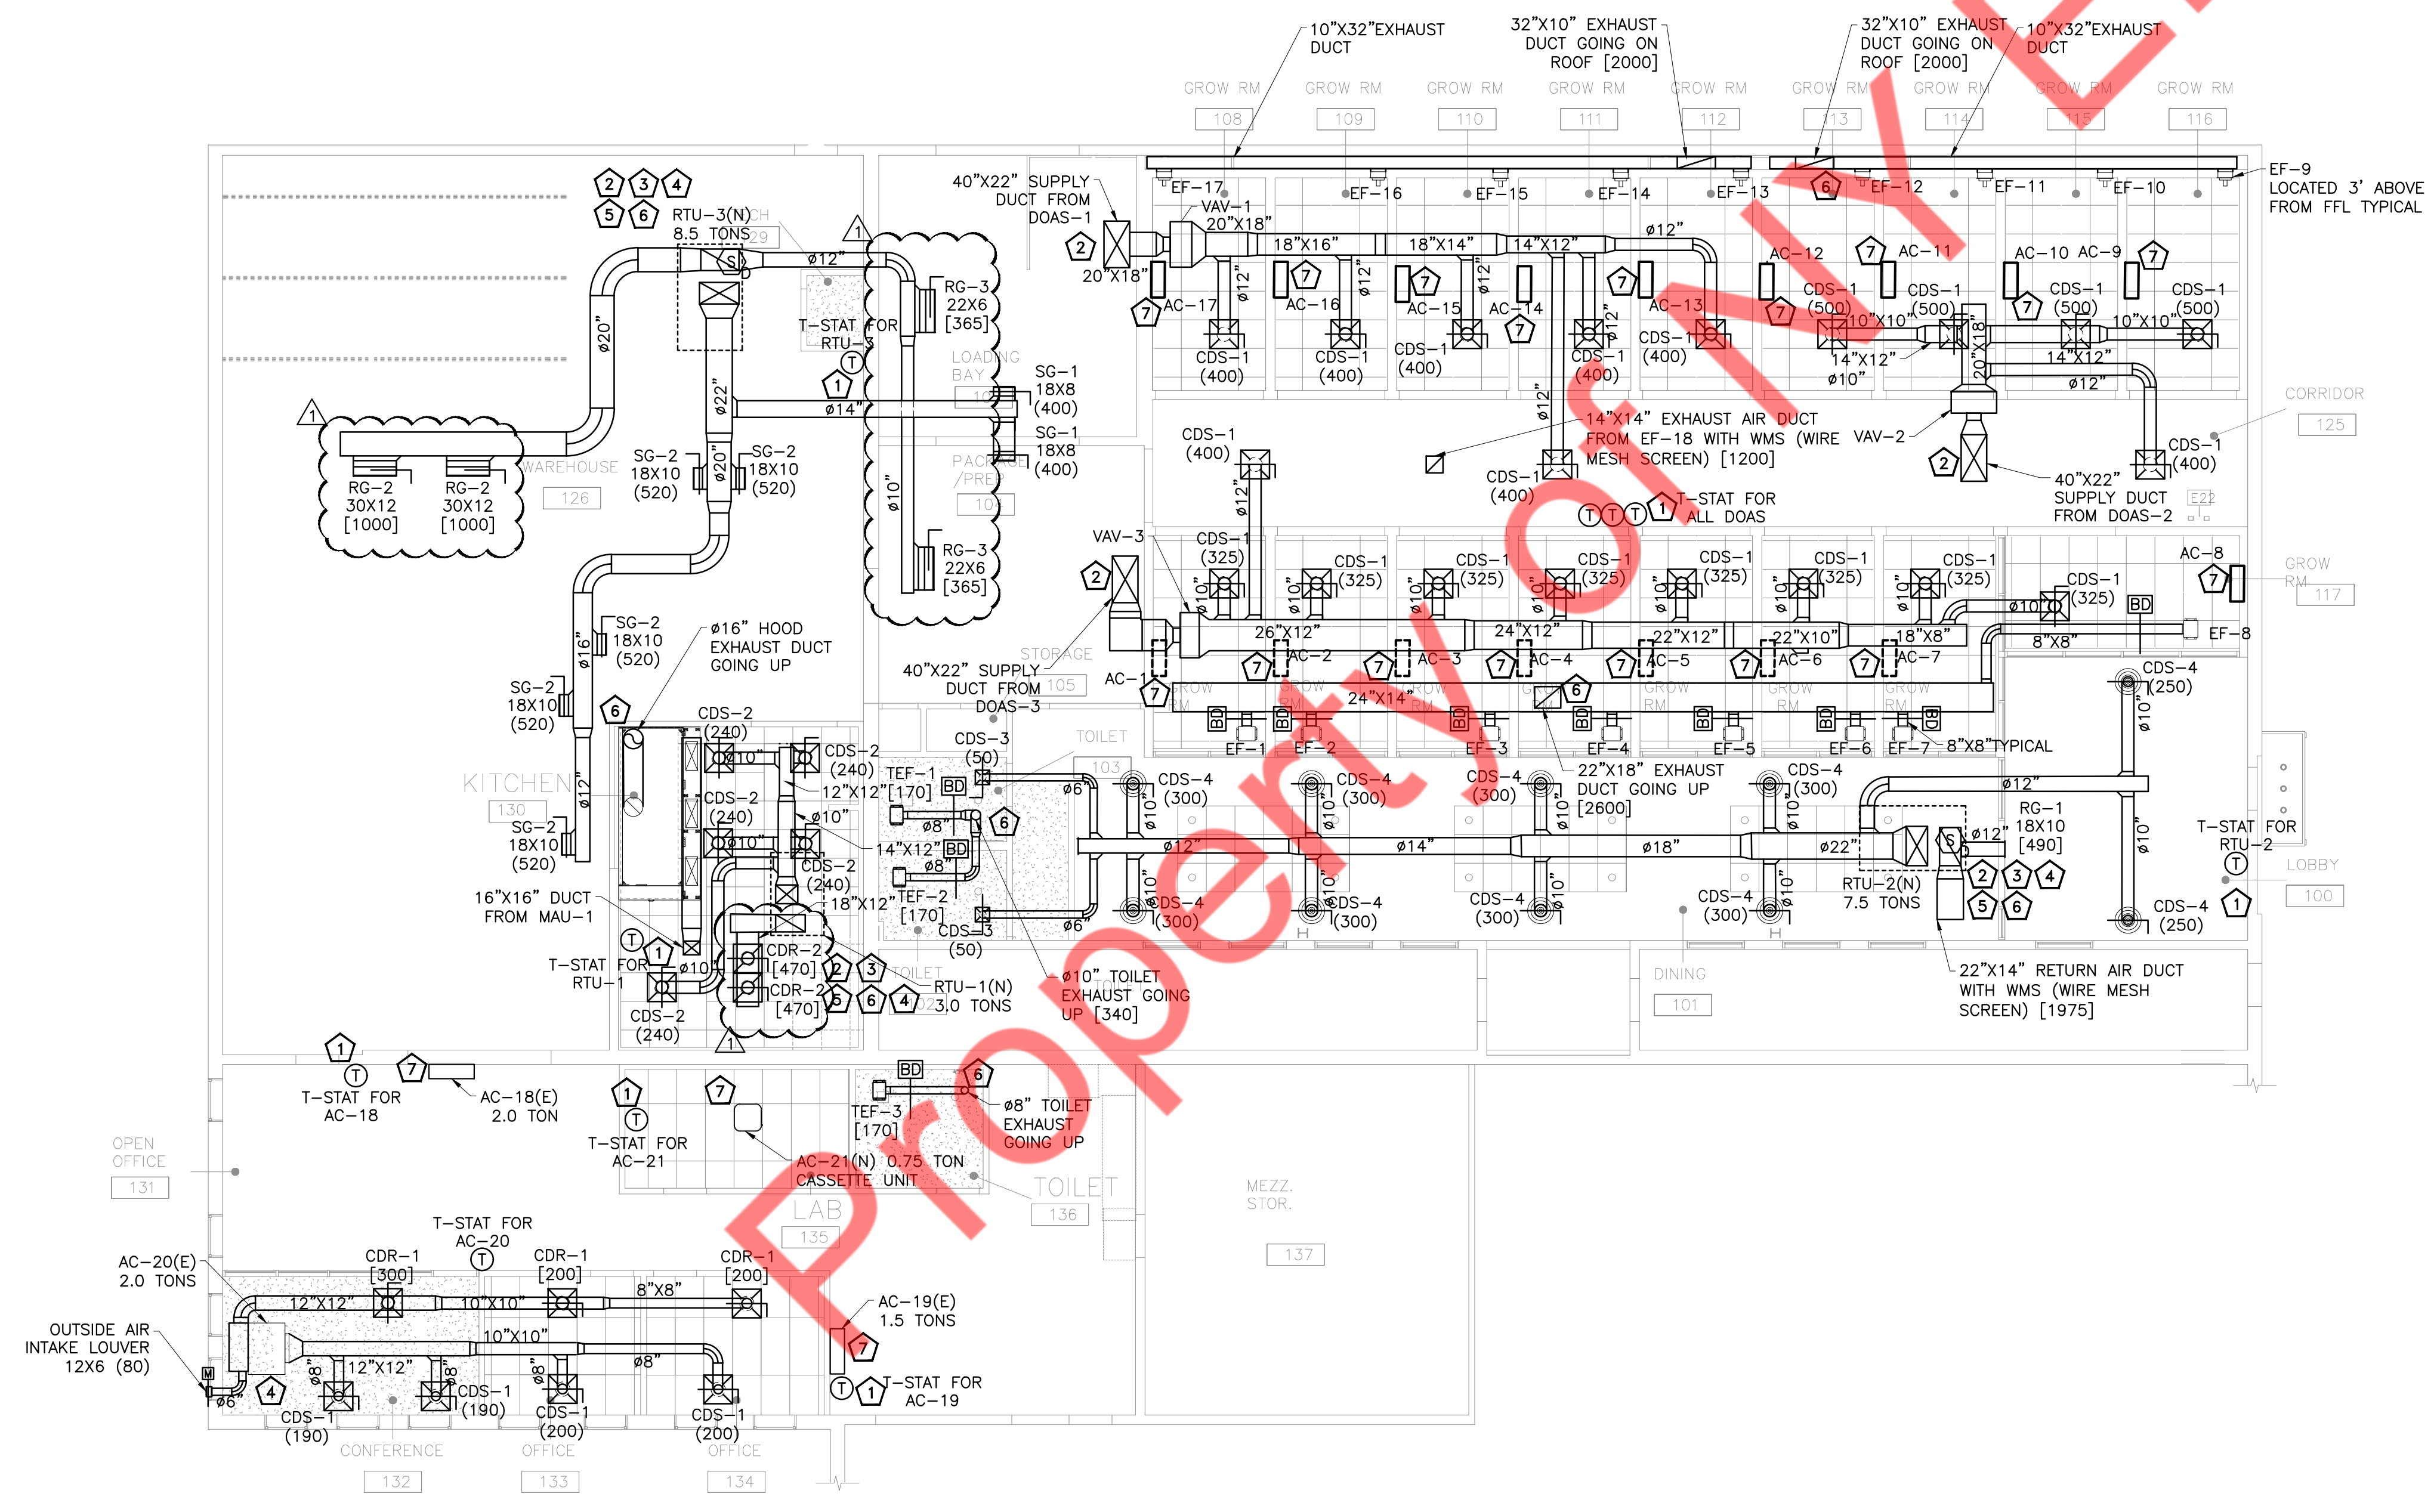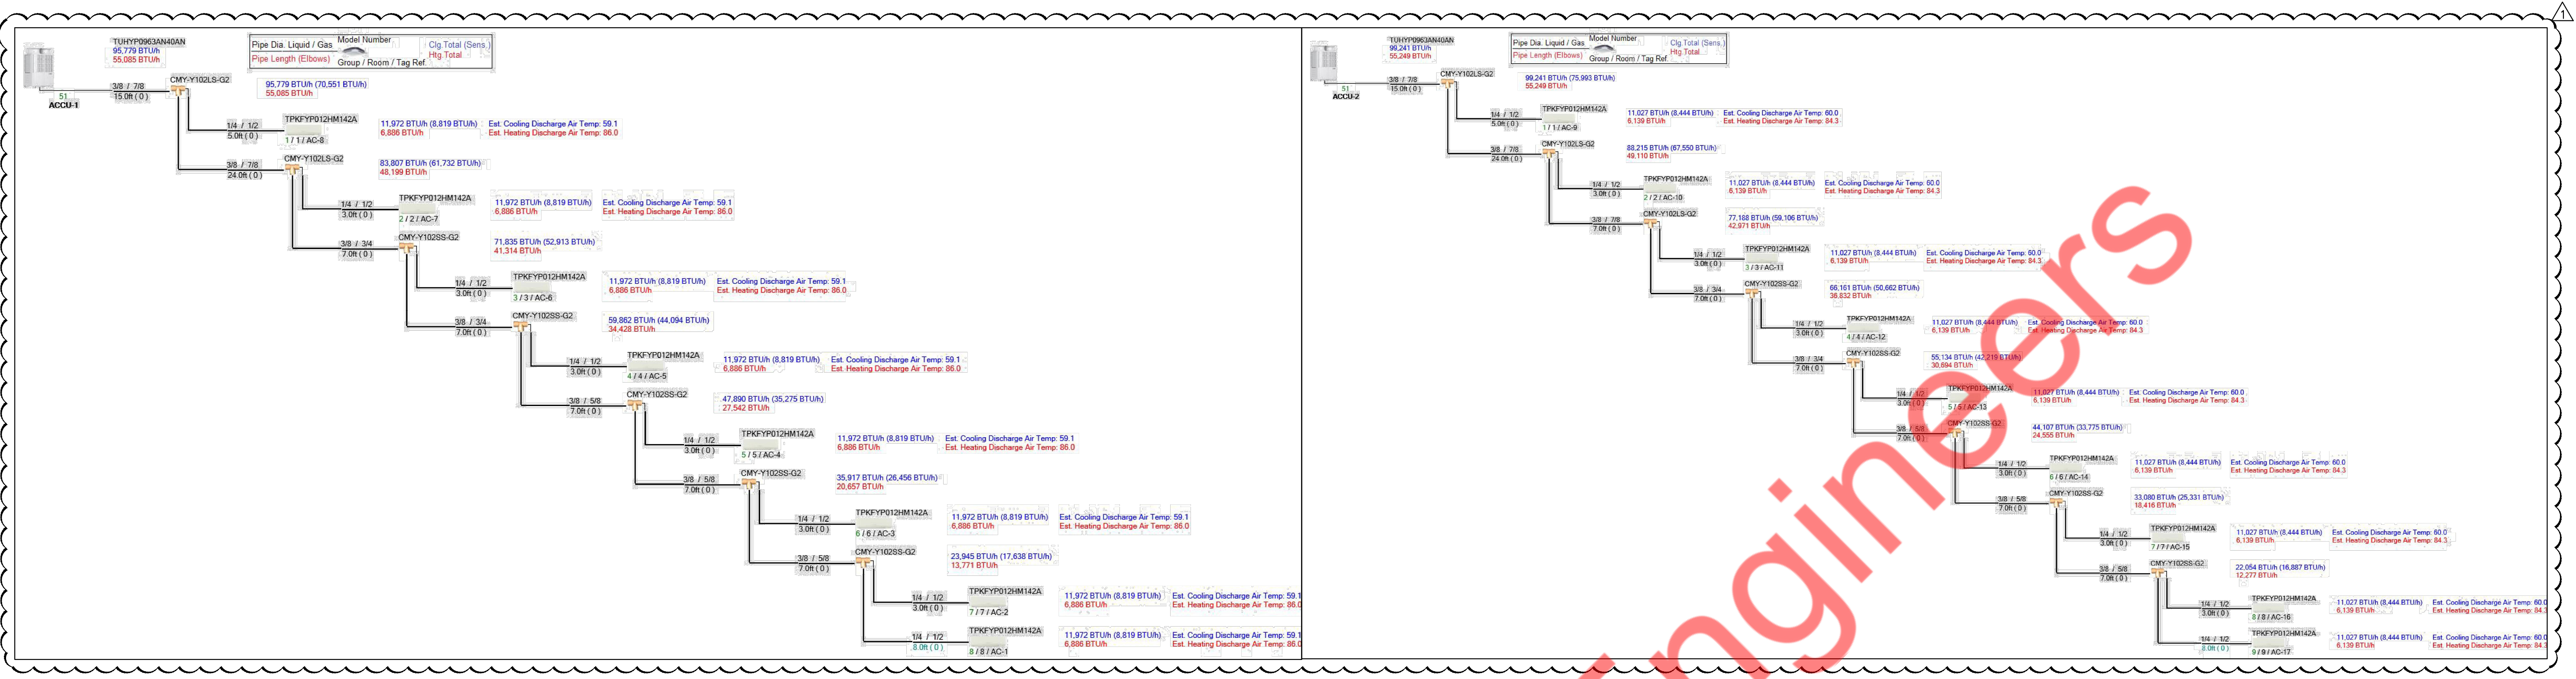

1 MECHANICAL FLOOR PLAN
SCALE: 1/8" = 1'-0"

MECHANICAL GENERAL NOTES

- CONTRACTOR SHALL BALANCE EACH AIR DIFFUSER WITH THE CFM SHOWN ON PLANS.
- DUCTWORK SHOWN ON PLAN ARE SCHEMATIC ONLY. CONTRACTOR SHALL COORDINATE WITH OTHER TRADES FOR DUCTWORK ROUTING, OFFSET AND RUN DUCTWORK INSIDE THE STRUCTURE IF REQUIRED. PROVIDE ANY EXTRA DUCTWORK, FITTINGS, INSULATIONS AND OTHER ACCESSORIES IN ORDER TO COMPLETE THE INSTALLATION.
- COORDINATE LOCATIONS AND SIZES OF ROOF OPENINGS WITH OWNER AND STRUCTURAL ENGINEERS.
- EQUIPMENT SIZES, DIMENSIONS AND REQUIRED CONNECTIONS SHALL BE VERIFIED WITH THE ACTUAL EQUIPMENT SELECTED VENDOR DRAWINGS BEFORE FABRICATION OF DUCTWORK, PIPING ETC.
- DUCT SIZES SHOWN ON PLANS ARE CLEAR INSIDE AIR STREAM DIMENSIONS.
- CONTRACTOR SHALL COORDINATE ALL ELECTRICAL REQUIREMENTS FOR ALL HVAC BASED ON ACTUAL EQUIPMENT SELECTED PRIOR TO INSTALLATION.
- CONTRACTOR SHALL COORDINATE EQUIPMENT WEIGHTS AND SUPPORTS BASED ON ACTUAL EQUIPMENT SELECTED.
- ALL EXPOSED DUCTWORK SHALL BE AS SHOWN, DOUBLE WALL, INSULATED METAL, PRIMED FOR PAINTING. ALL CONCEALED DUCTWORK SHALL BE INSULATED METAL RECTANGULAR UNLESS OTHERWISE ALLOWED IN WRITING BY THE ENGINEER OF RECORD. COORDINATE FINAL FINISH WITH ARCHITECT.
- COORDINATE WITH ALL TRADES FOR MATERIALS IN RATED AND PLENUM SPACES.
- ALL SOURCE OF MECHANICAL INTAKE SHALL MAINTAIN 10 LINEAR FEET SEPARATION BETWEEN ANY SOURCE OF EXHAUST. CONTRACTOR IS RESPONSIBLE TO ADJUST DUCT SIZES AS REQUIRED.
- DUCT SERVING TYPE-I HOODS MUST BE 16 GA STEEL OR 18 GA STAINLESS STEEL. DUCT MUST BE WELDED LIQUID TIGHT.
- ALL CONNECTIONS LOCATED WITHIN A VENTILATION SYSTEM SHALL BE FORMED BY FUSION WELDING OR SOCKET TYPE BRAZED FITTINGS. NO VALVES, DEVICES OR CONNECTIONS THERETO SHALL BE LOCATED IN A VENTILATION SYSTEM, EXCEPT SYSTEMS CONTAINING LESS THAN 100 POUNDS OF REFRIGERANT AND DO NOT CONTAIN A WARM AIR FURNACE OR ELECTRIC RESISTANCE HEATING COIL.
- PROVIDE NEW NOMENCLATURE TAGS ON EACH ACCU LISTING THE TOTAL REFRIGERANT CHARGE IN THE SYSTEM.
- INSTALL PRESSURE RELIEF VALVE ON HIGH PRESSURE SIDE OF SYSTEM, UPSTREAM OF ANY INTERVENING VALVES.
- COPPER TUBE USED FOR REFRIGERANT PIPING ERECTED ON THE PREMISES SHALL BE SEAMLESS COPPER OF TYPE ACR, MANUFACTURED IN ACCORDANCE WITH ASTM B280, WHERE REQUIRED AND APPROVED FOR SYSTEMS IN EXCESS OF THE RATED PRESSURE OF TYPE ACR TUBE, COPPER TUBE SHALL BE SEAMLESS COPPER TUBE OF TYPE K COMPLYING WITH ASTM B819, OR TYPE K COMPLYING WITH ASTM B88 AND SHALL BE INTERNALLY CLEANED AND CAPPED. ANNEALED TEMPER COPPER TUBE SHALL NOT BE USED WHERE THE SYSTEM CONTAINS MORE THAN 100 POUNDS (45.36 KG) OF REFRIGERANT IN SIZES LARGER THAN 7/8 INCH NOMINAL SIZE. FITTINGS SHALL BE FORGED BRASS, WROUGHT COPPER, OR BRONZE ALLOY.
- COPPER TUBING USED IN REFRIGERATING SYSTEMS CONTAINING GROUP A2, A3, B1, B2 OR B3 REFRIGERANTS SHALL BE BRAZED. SOLDERED JOINTS AND MECHANICAL JOINTS SHALL NOT BE USED IN SUCH REFRIGERATING SYSTEMS.

MECHANICAL FLOOR PLAN KEY NOTES:

- LOCATION OF DIGITAL THERMOSTAT CONTROL. INSTALL AND WIRE NEW 7-DAY PROGRAMMABLE THERMOSTAT & HUMIDISTAT. COORDINATE FINAL LOCATION WITH ARCHITECT AND OWNER PRIOR TO ROUGH-IN. PROVIDE LOCKABLE COVER.
- EXTEND FULL SIZE SUPPLY & RETURN DUCTWORK FROM ROOFTOP UNITS TO SPACE. EXTEND AS SHOWN. ACOUSTICALLY LINE THE FIRST 10'-0" OF BOTH SUPPLY AND RETURN MAIN DUCTS.
- PROVIDE SMOKE DETECTOR. SMOKE DETECTOR SHALL BE FURNISHED/INSTALLED BY MECHANICAL CONTRACTOR AND WIRED BY ELECTRICAL CONTRACTOR TO SHUT DOWN CORRESPONDING RTU UNDER ALARM CONDITIONS. ALL WIRING SHALL BE IN CONDUIT PER N E C SMOKE DETECTOR SHALL BE SYSTEM SENSOR MODEL DH100ACDCLP OR EQUAL.
- PROVIDE FLEXIBLE CONNECTORS ON SUPPLY AND RETURN DUCT CONNECTIONS. SET OUTSIDE AIR AS INDICATED ON ROOFTOP UNIT SCHEDULES. MECHANICAL CONTRACTOR SHALL SCRIBE INTO UNIT POSITION OF OUTSIDE AIR DAMPER AND LABEL OUTSIDE AIR VOLUME AND PERCENT OF OUTSIDE AIR TRANSITION AND CONNECT SUPPLY AND RETURN DUCTWORK FROM BELOW. COORDINATE ROUTING THROUGH STRUCTURAL TRUSSES AND OFFSET AS REQUIRED IN CURB SPACE.
- COORDINATE FINAL LOCATION OF EQUIPMENT WITH STRUCTURAL REQUIREMENT.
- TERMINATE EXHAUST DUCT UP THROUGH ROOF. MAINTAIN A MINIMUM OF 15'-0" FROM ALL OUTSIDE AIR INTAKES AND TERMINATE 36" ABOVE ROOF.
- IF REQUIRED, PROVIDE CONDENSATE PUMP. CONNECT 1" CD FROM AC TO NEAREST PLUMBING DRAIN WITH AIR GAP FITTING.

REVISION SCHEDULE		
NO. REV.	/ SUBMISSION DATE	ISSUED BY
1	PERMIT SET	06/21/22 NYE


ISSUE DATE: 4/6/2022 5:19:23 PM

RENOVATION
FOUR STAR
MUSHROOMS


DRAWN BY:	NYE
QAQC:	
APPROVED BY:	NYE
PROJECT NUMBER:	2206

MECHANICAL FLOOR PLAN


M1.0

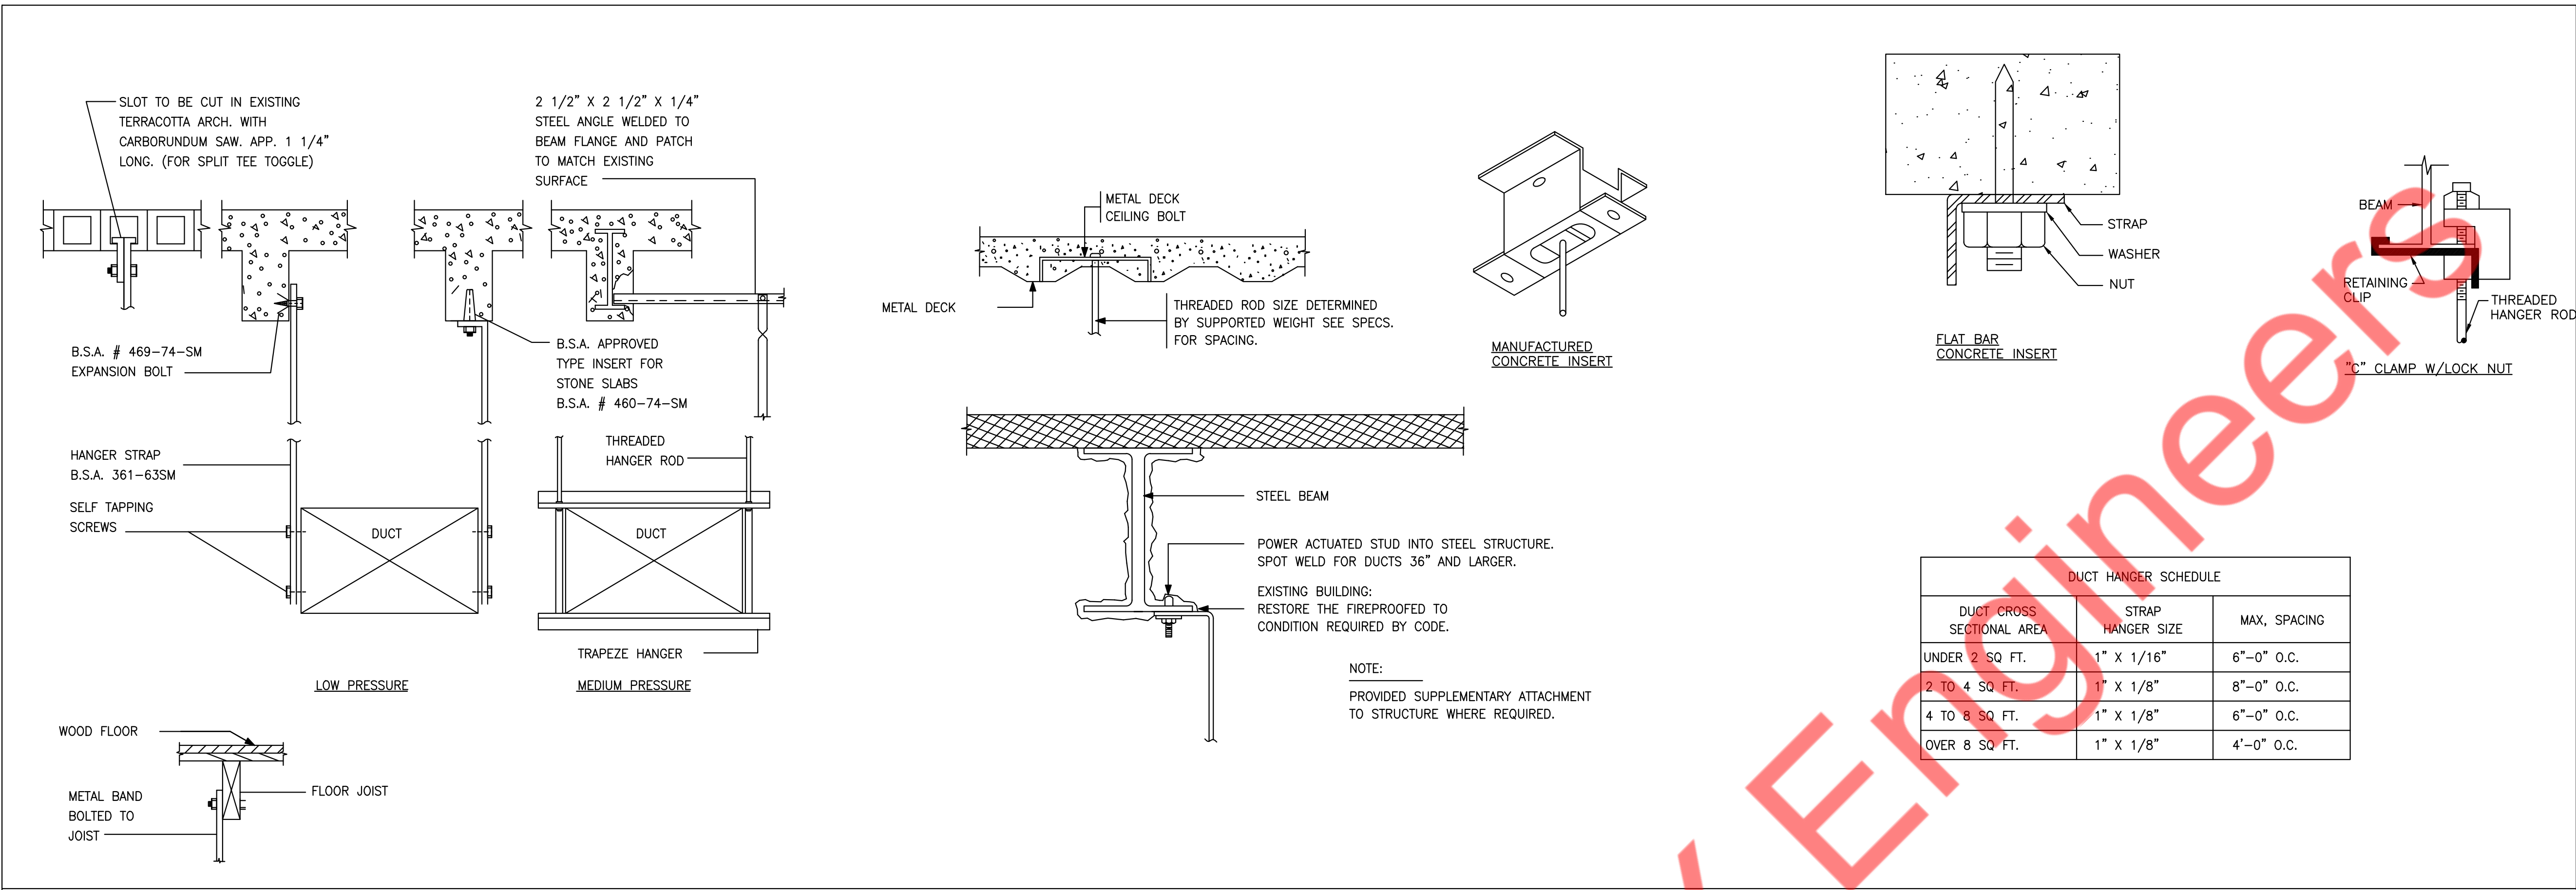


1 METHOD OF HANGING DUCTWORK
M5.1 N.T.S

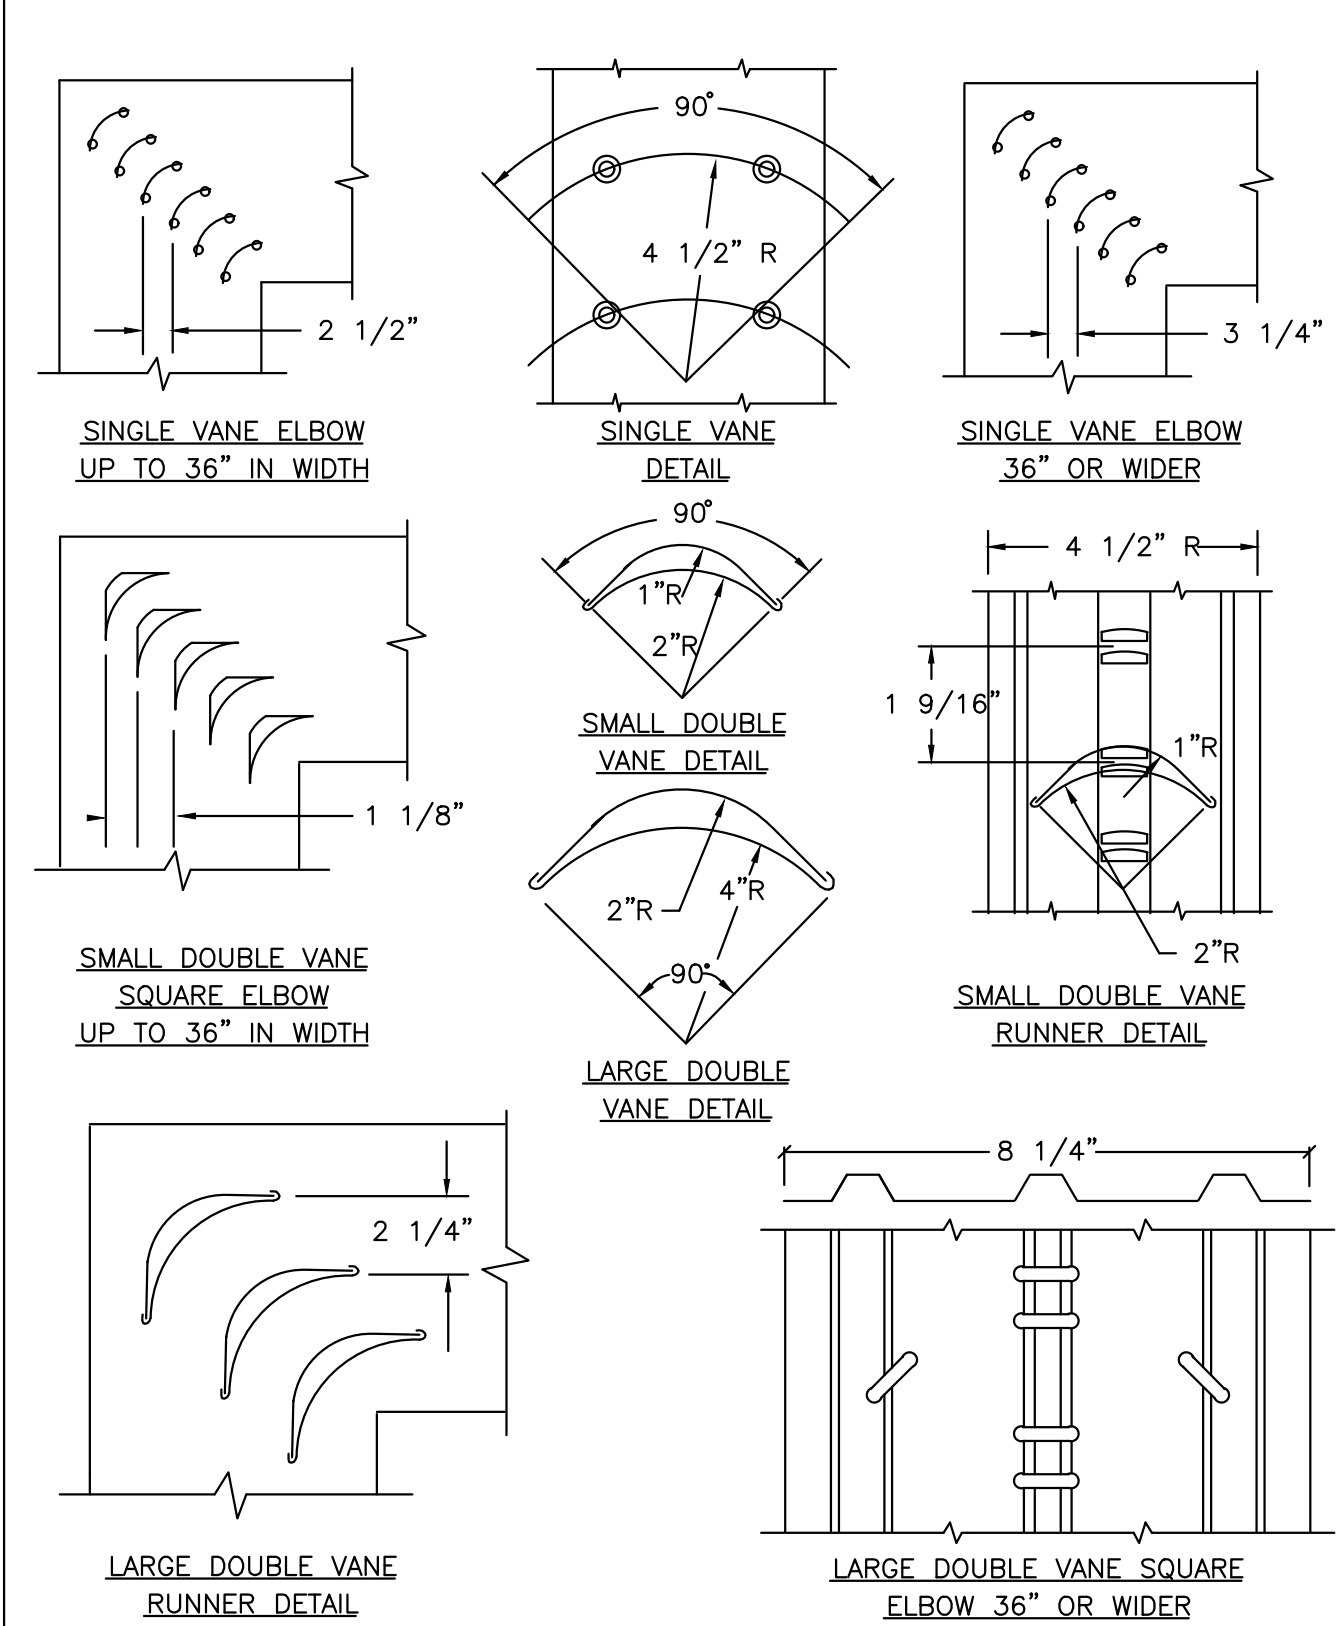

2 LOW VELOCITY DUCTWORK ELBOWS
M5.1 N.T.S

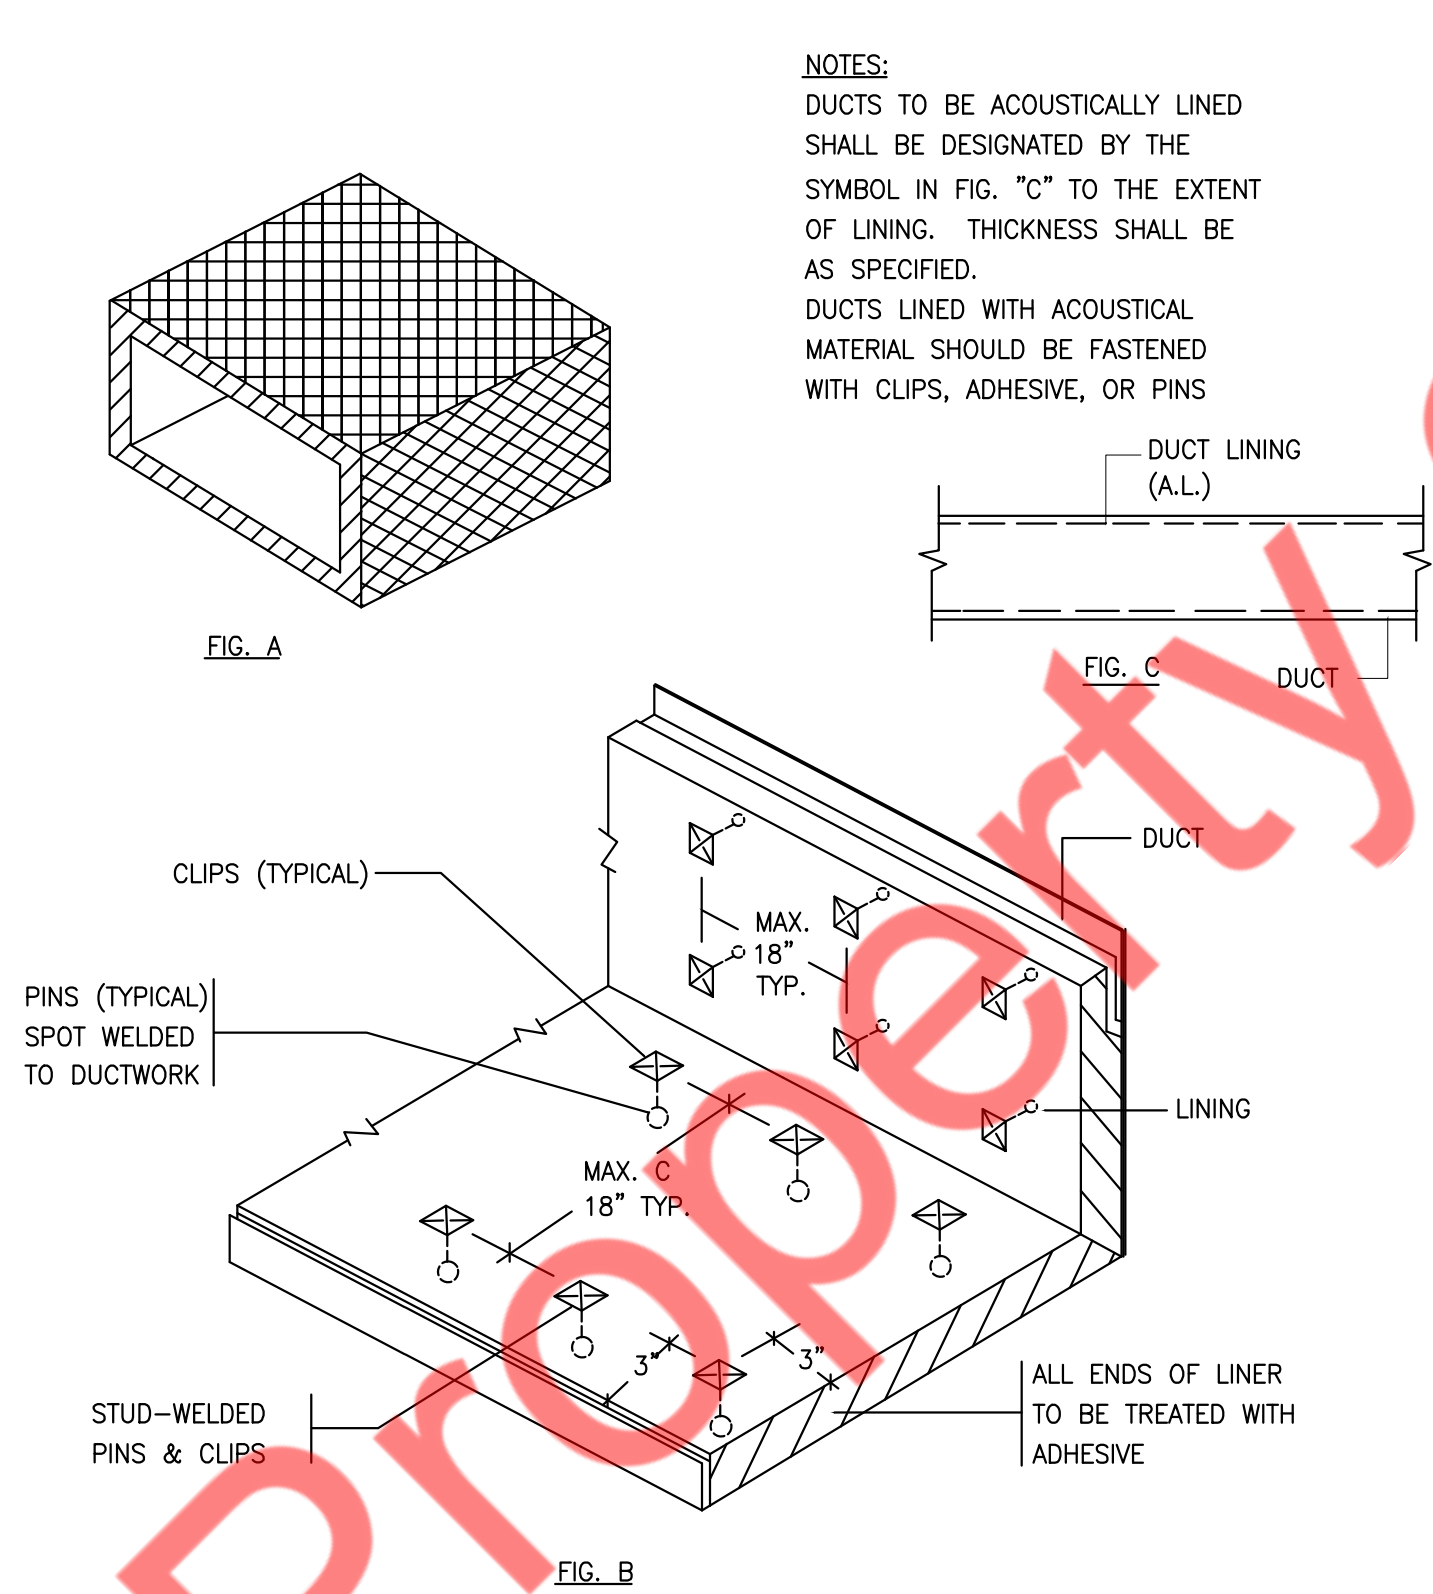

3 ACOUSTICAL TREATMENT DUCT LINING
M5.1 N.T.S

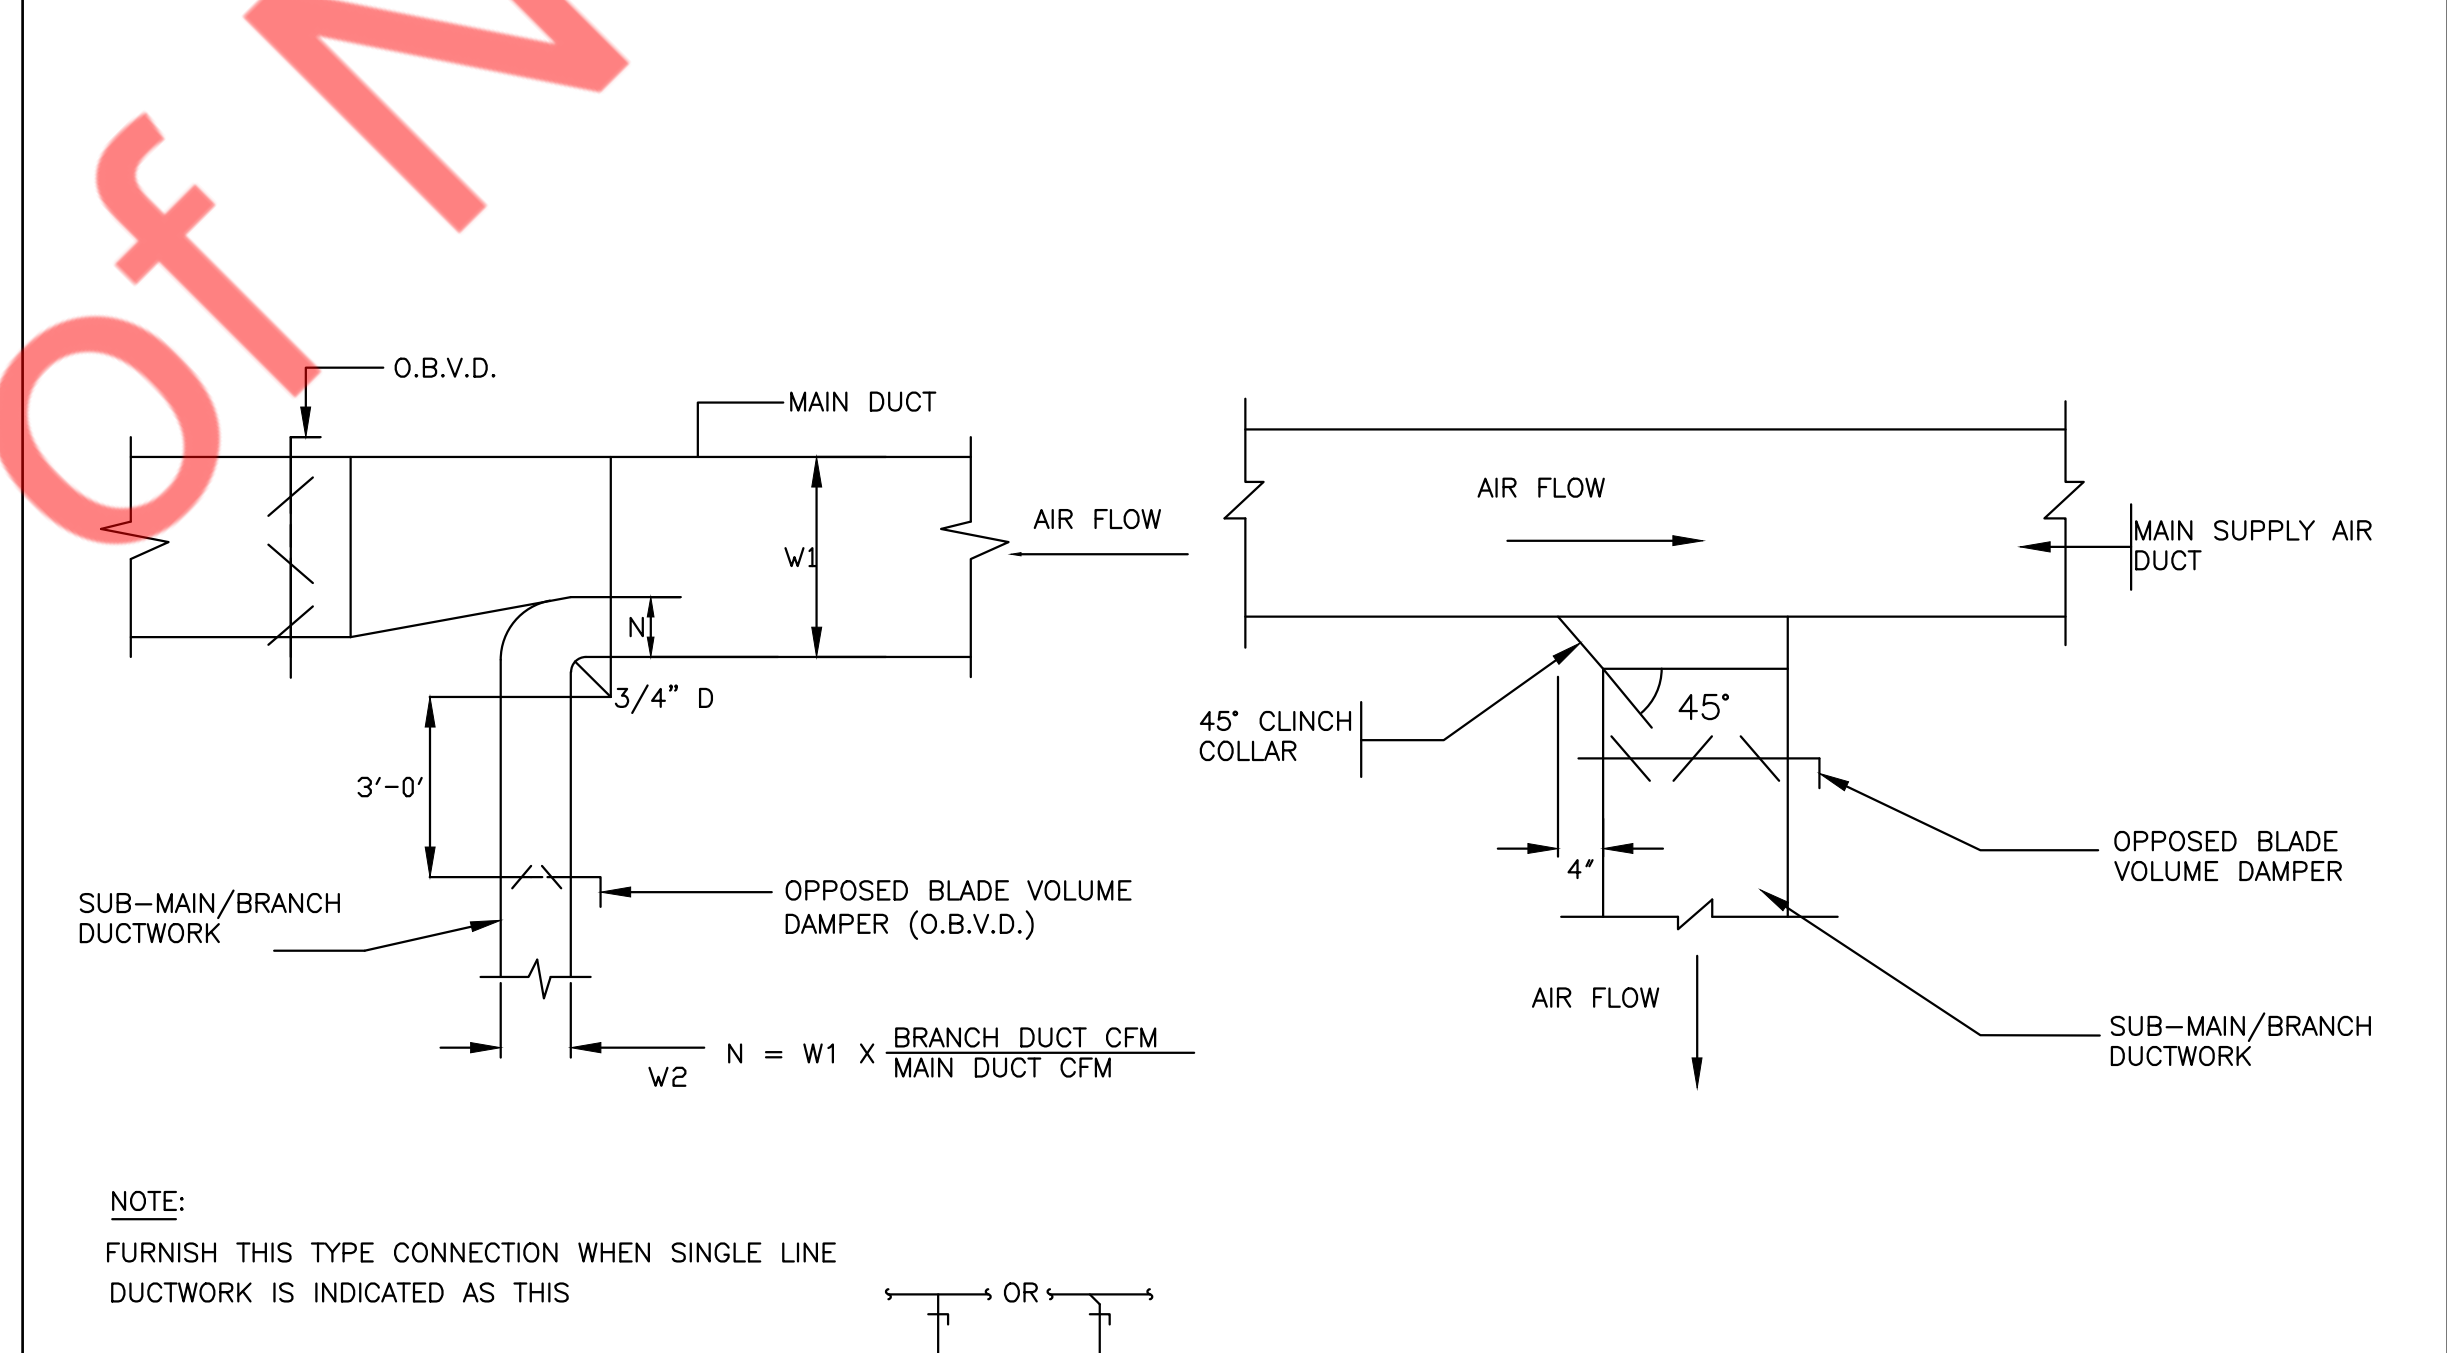

4 SUPPLY AIR DUCTWORK SUB-MAIN/BRANCH DUCT CONNECTION
M5.1 N.T.S

REVISION SCHEDULE		
NO. REV.	SUBMISSION DATE	ISSUED BY
1	PERMIT SET	06/21/22 NYE

ISSUE DATE: 4/6/2022 5:19:23 PM

RENOVATION
FOUR STAR
MUSHROOMS

DRAWN BY: NYE


QAQC:

APPROVED BY: NYE


PROJECT NUMBER: 2206

MECHANICAL DETAILS
(1 OF 3)


M5.1

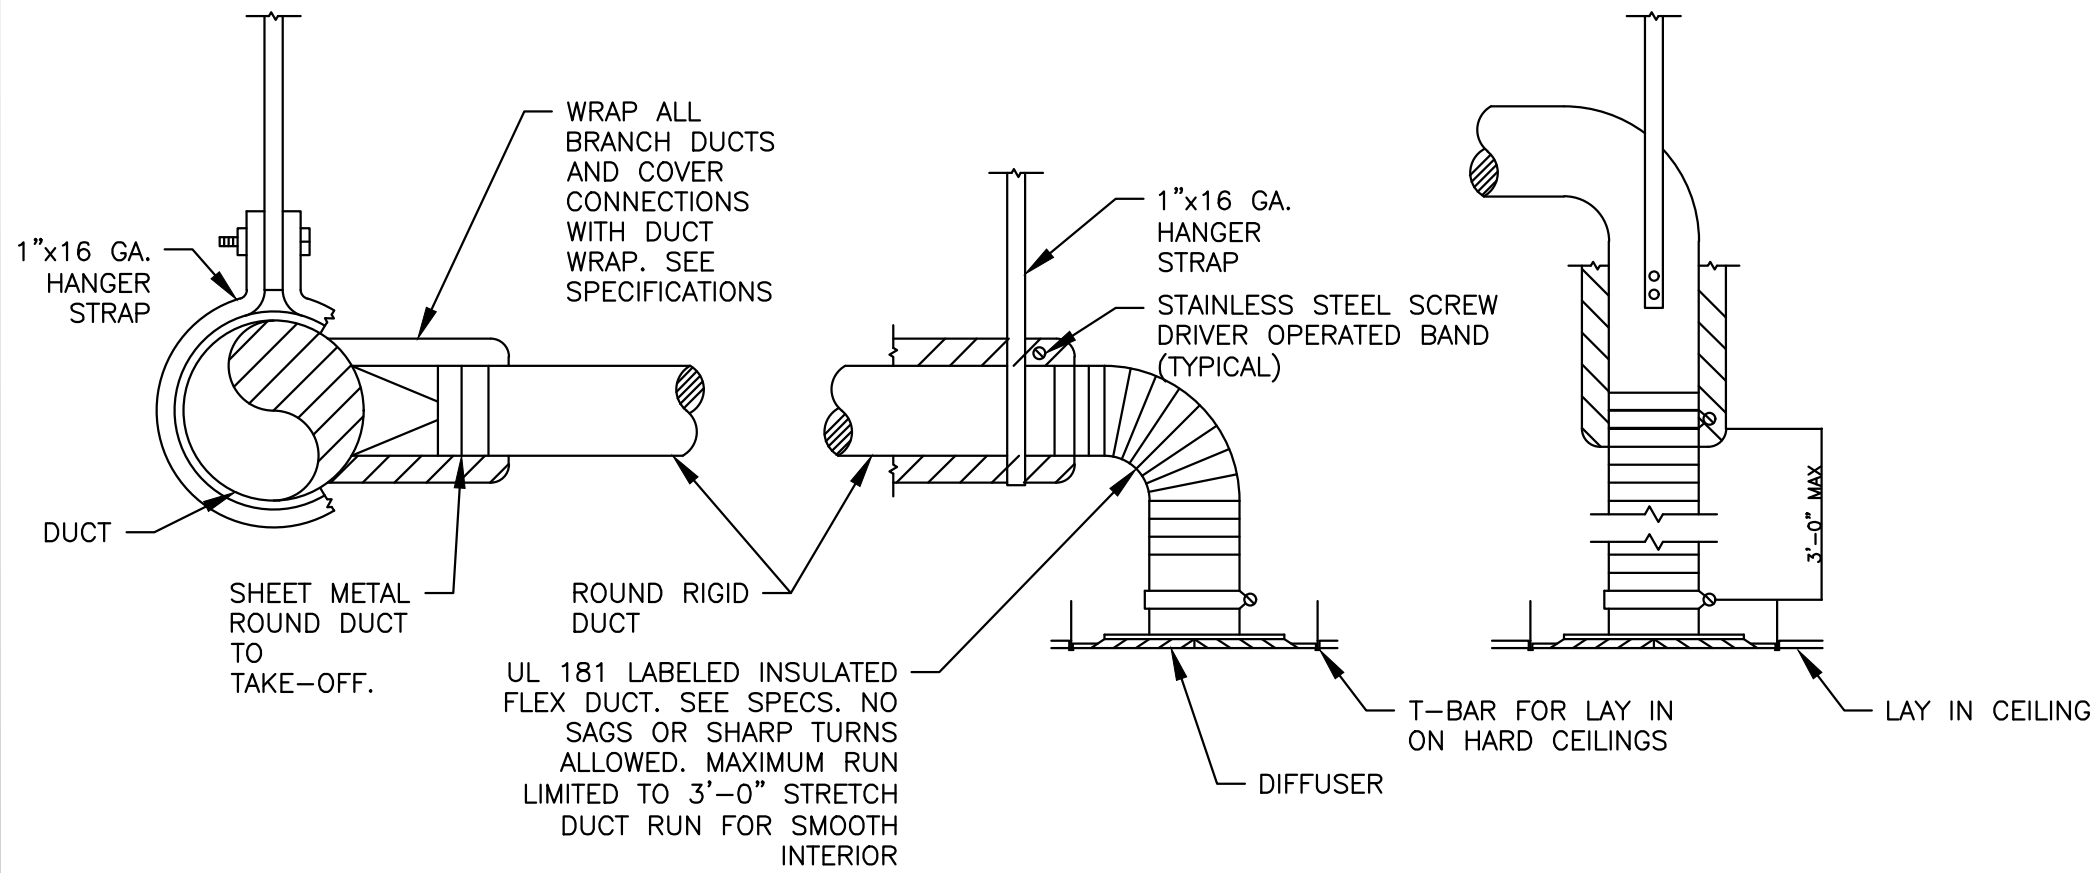


1 TYPICAL DIFFUSER CONNECTION DETAIL
M5.2 N.T.S

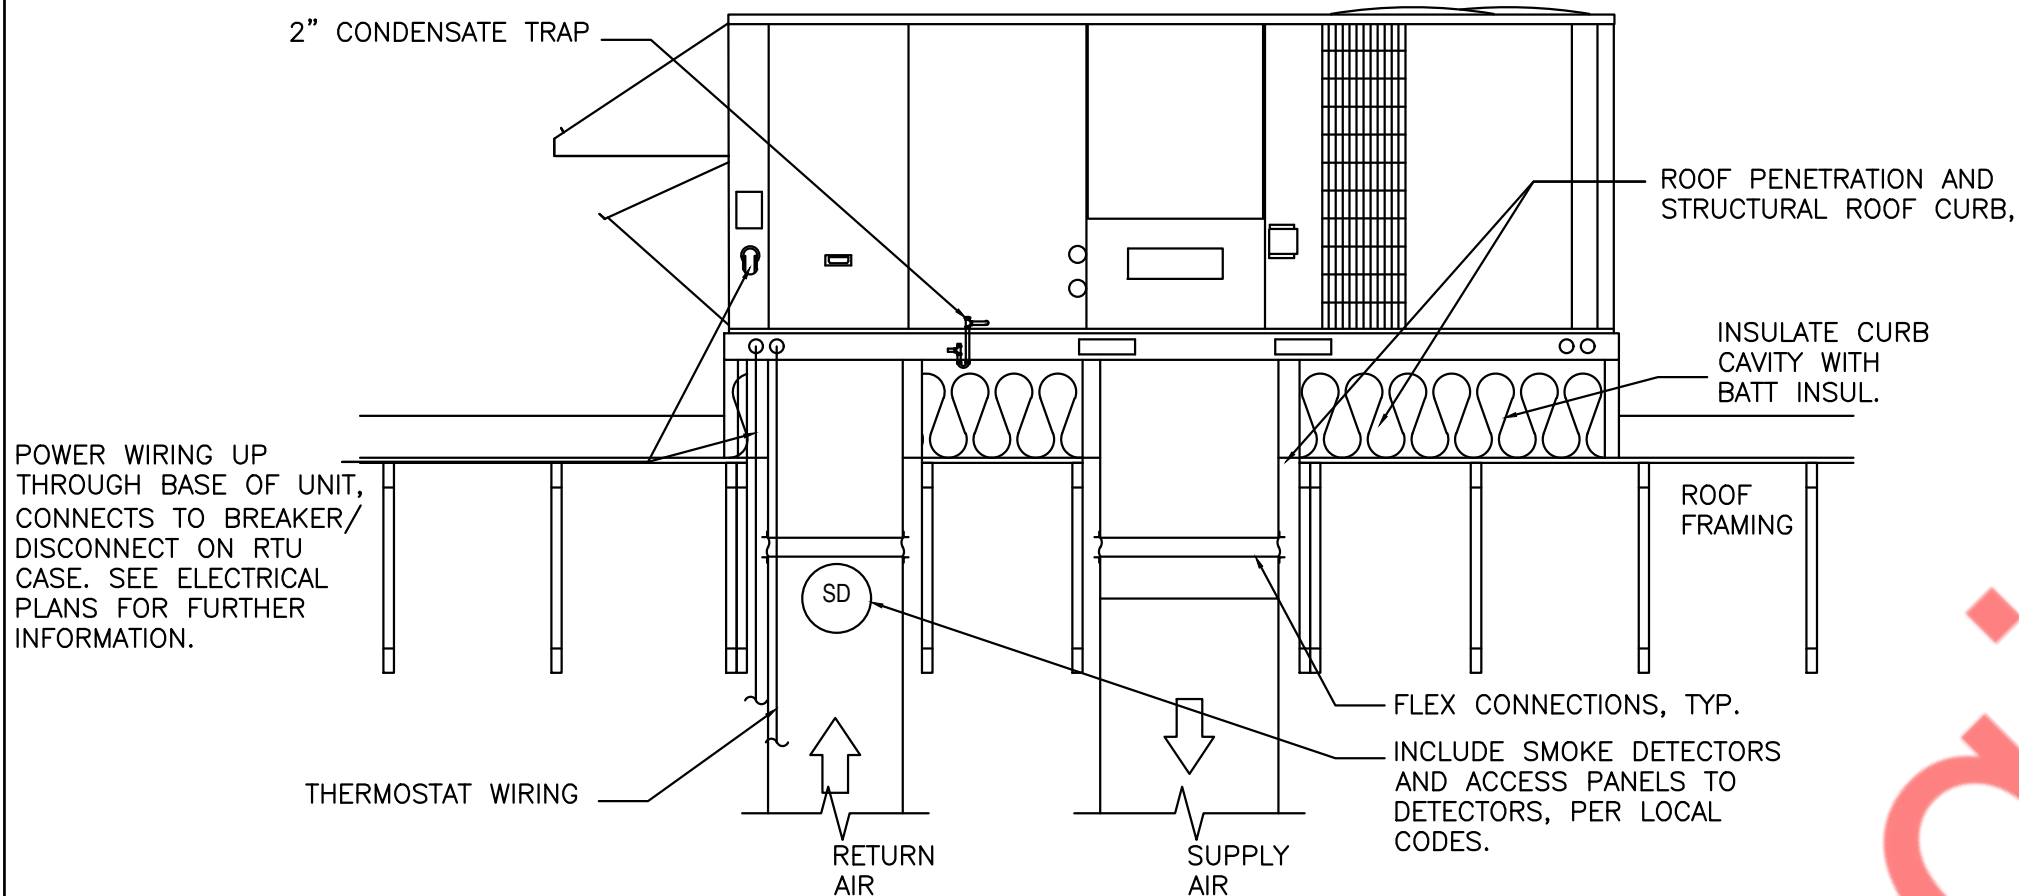

2 TYPICAL ROOF TOP UNIT DETAIL
M5.2 N.T.S

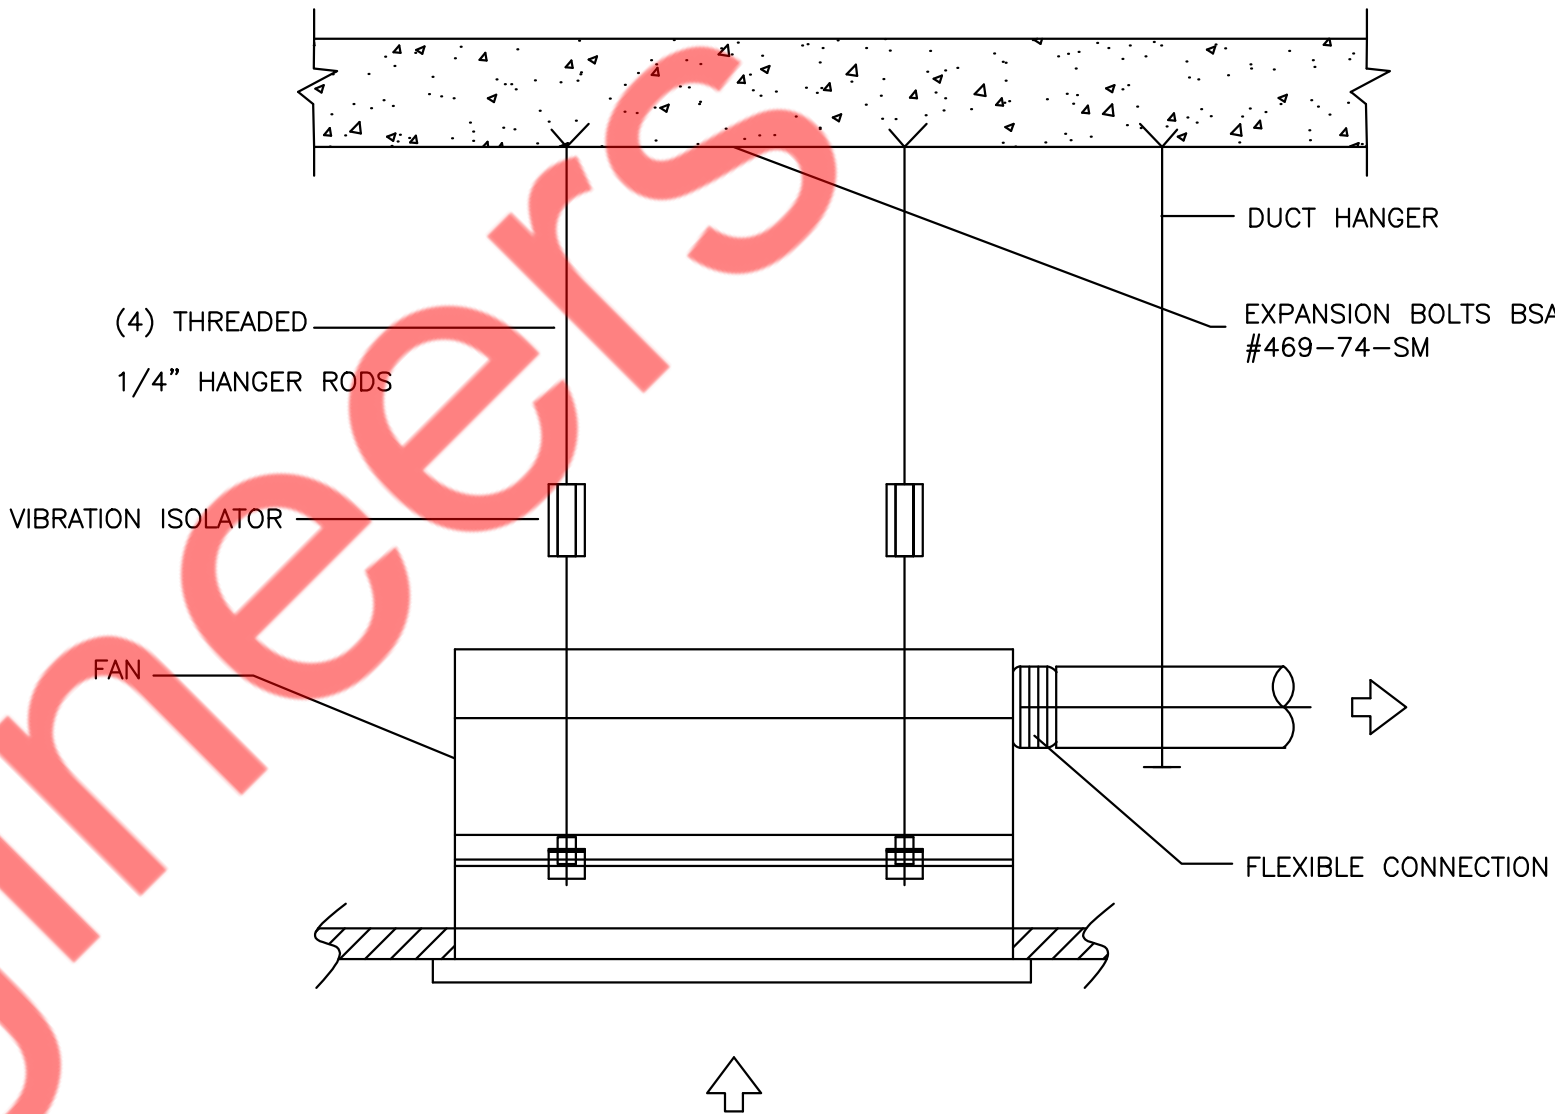


3 CEILING FAN HANGING SUPPORT DETAIL
M5.2 N.T.S

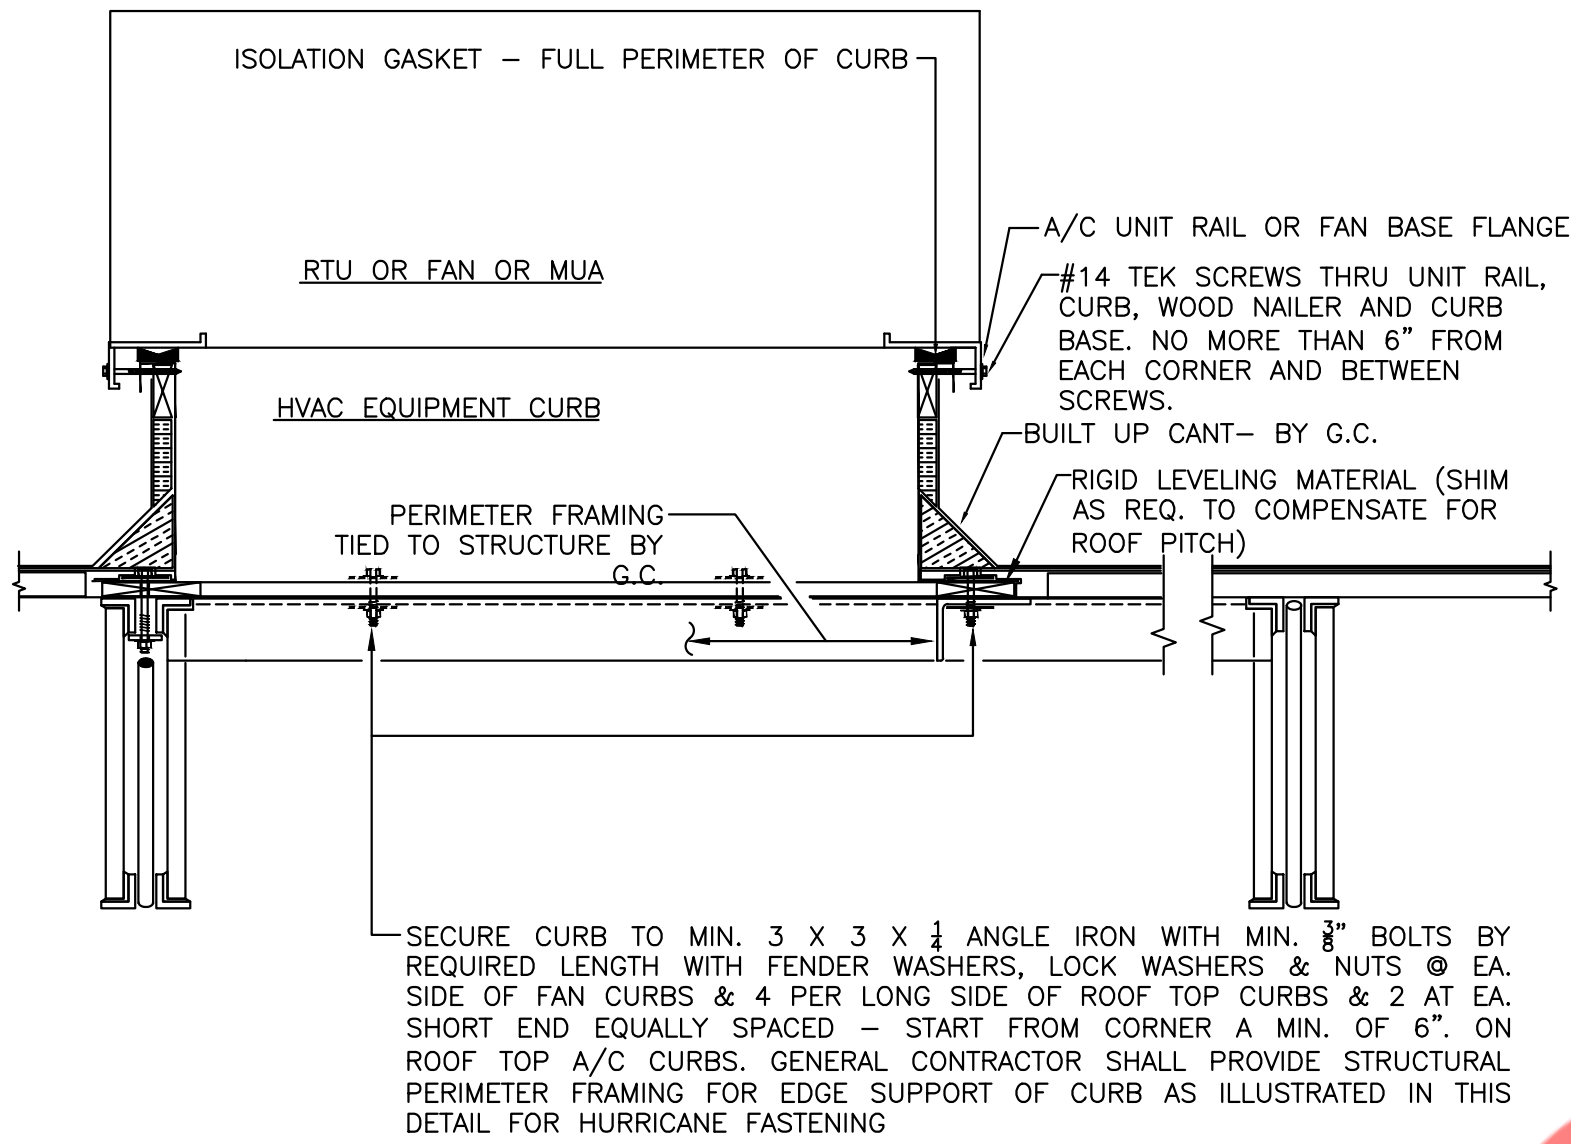


ACCEPTABLE FOR 170 MPH ZONE
VERIFY ON SITE WITH GENERAL CONTRACTOR


4 UNIT INSTALLATION ON ROOF
M5.2 N.T.S

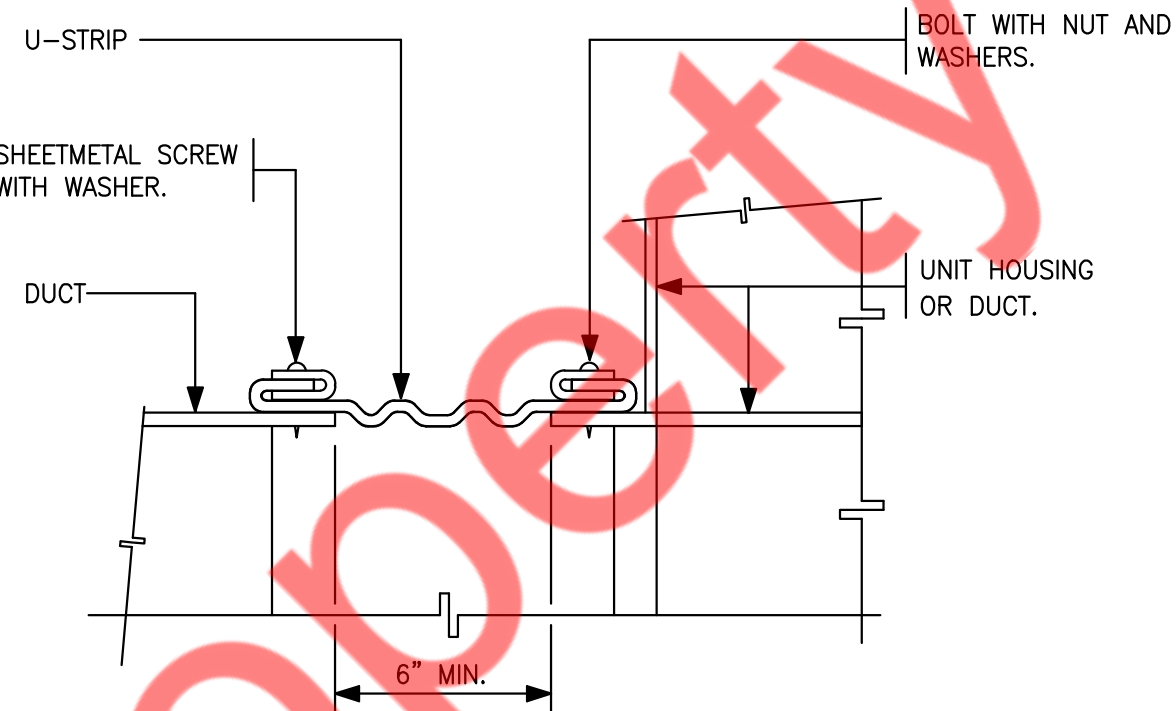

5 FLEXIBLE CONNECTION (DUCT-EQUIPMENT)
M5.2 N.T.S

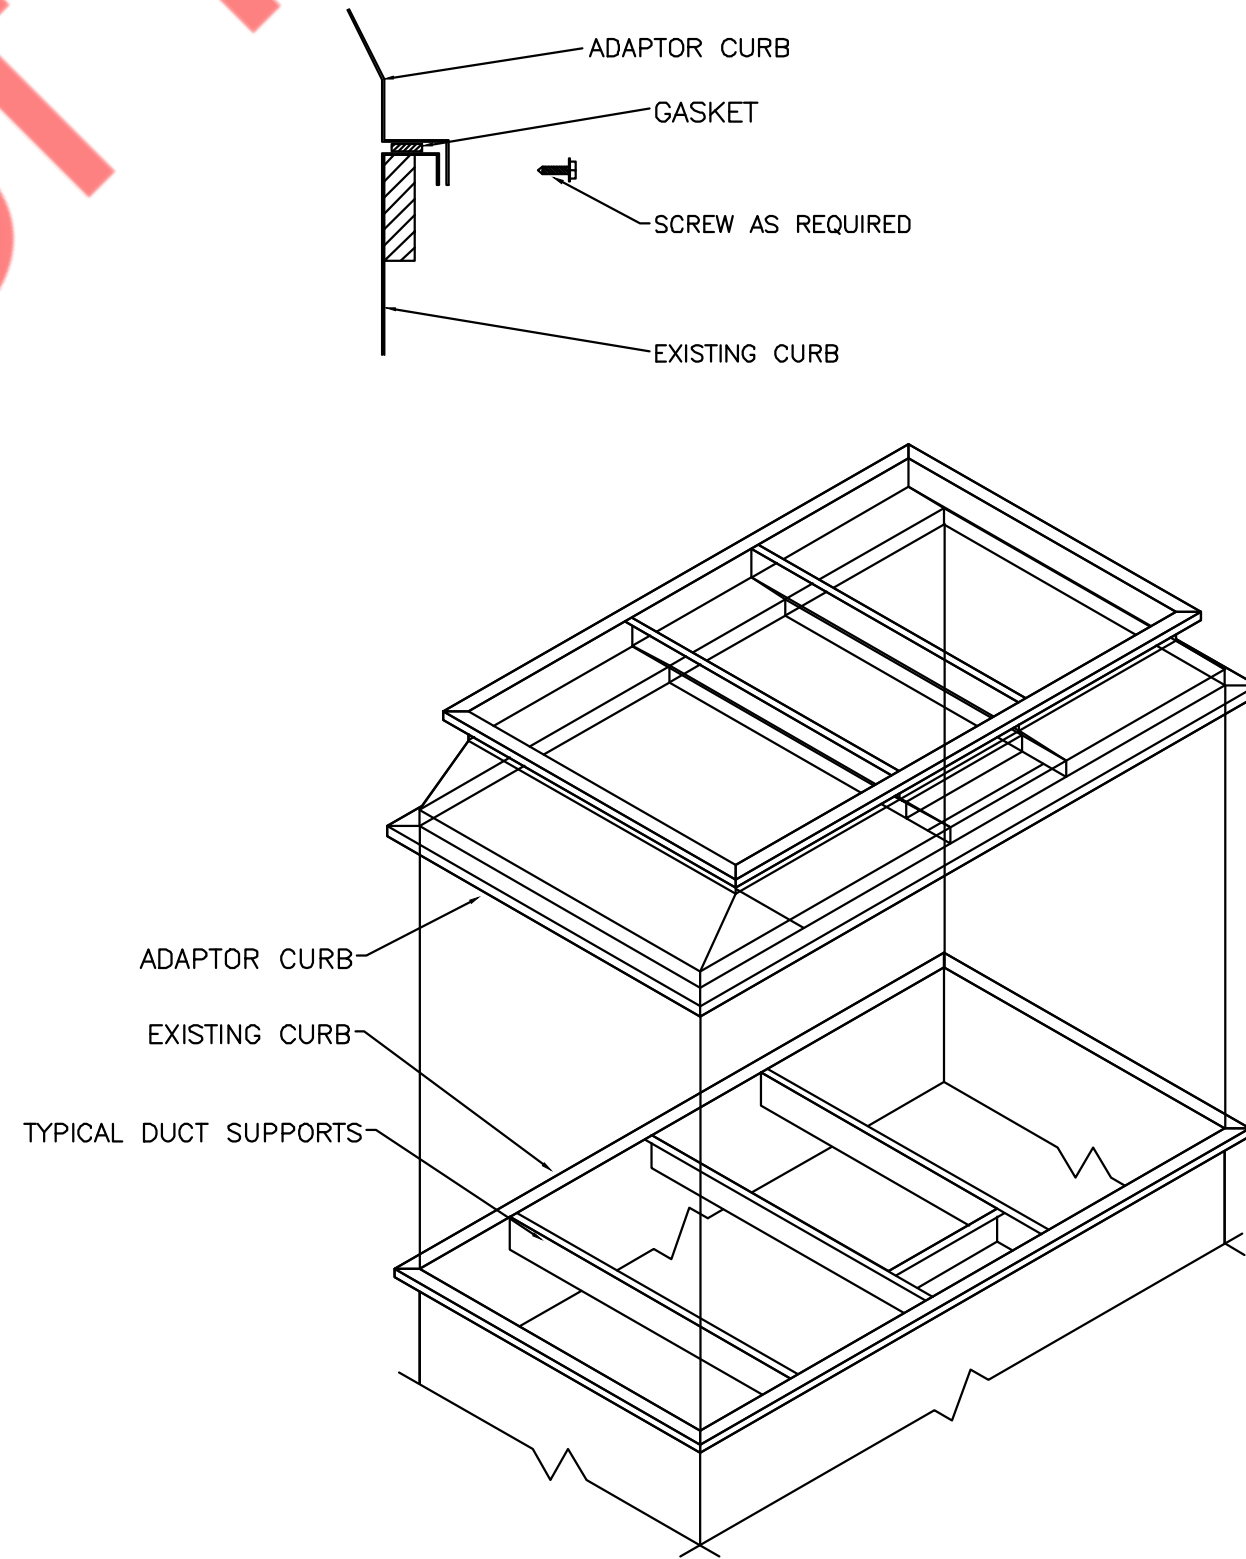

6 ROOF CURB ADAPTOR DETAILS
M5.2 N.T.S

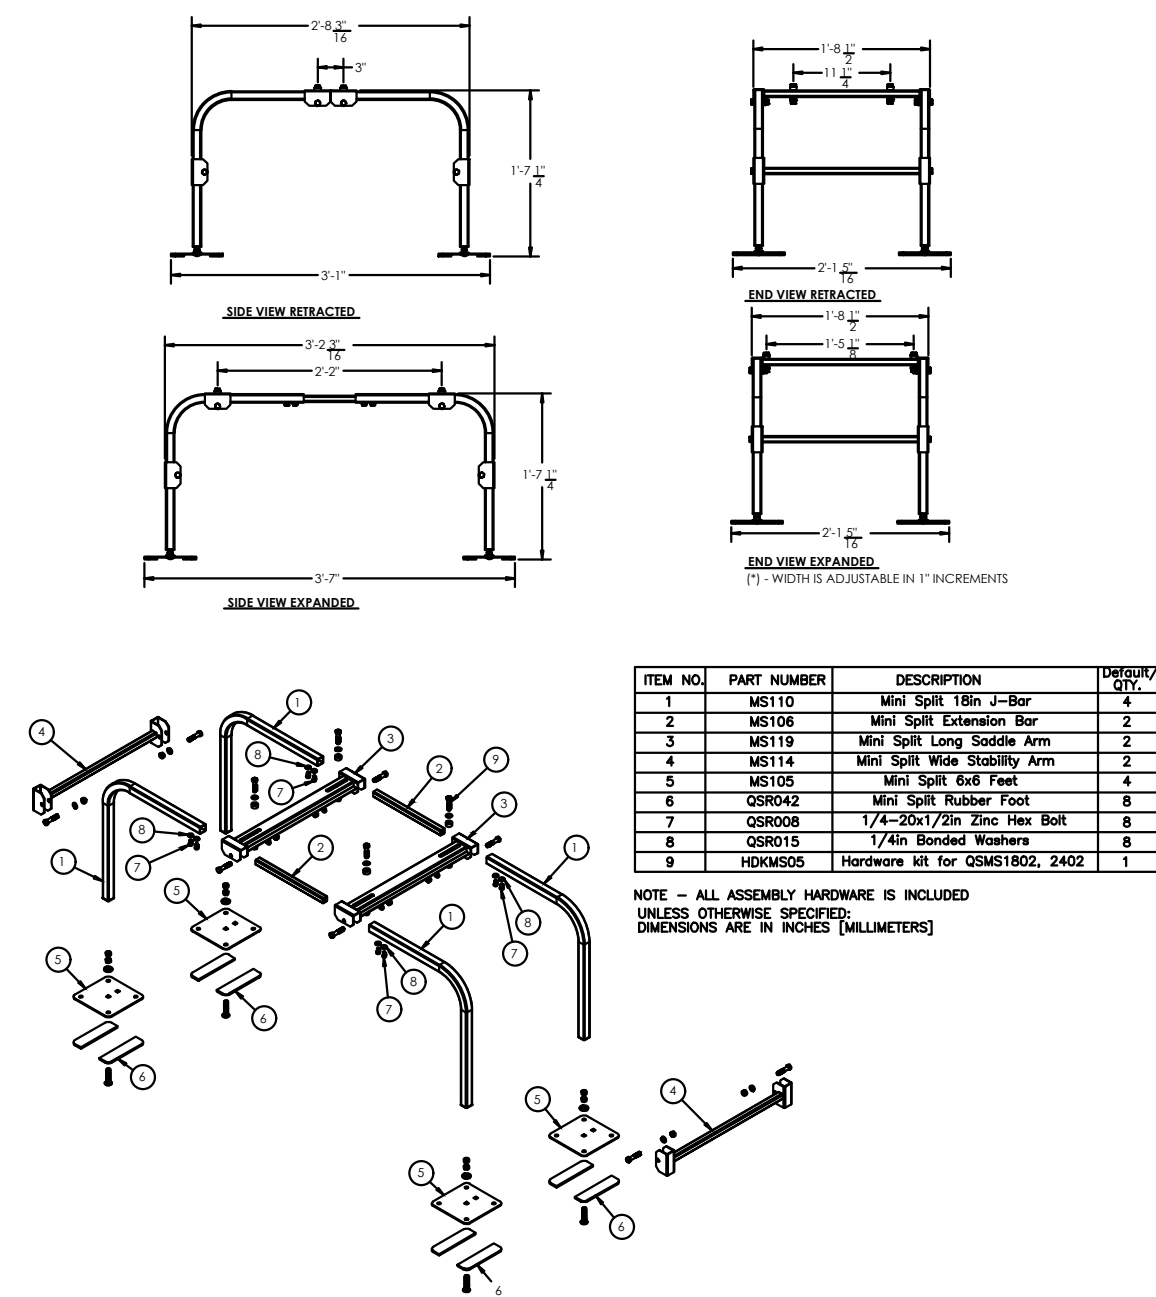

7 CONDENSING UNIT MOUNTING DETAIL
M5.2 N.T.S

REVISION SCHEDULE			
NO.	REV.	SUBMISSION DATE	ISSUED BY
1	PERMIT SET	06/21/22	NYE


ISSUE DATE: 4/6/2022 5:19:23 PM

RENOVATION FOUR STAR MUSHROOMS


DRAWN BY:	NYE
QAQC:	
APPROVED BY:	NYE
PROJECT NUMBER:	2206

MECHANICAL DETAILS
(2 OF 3)


M5.2

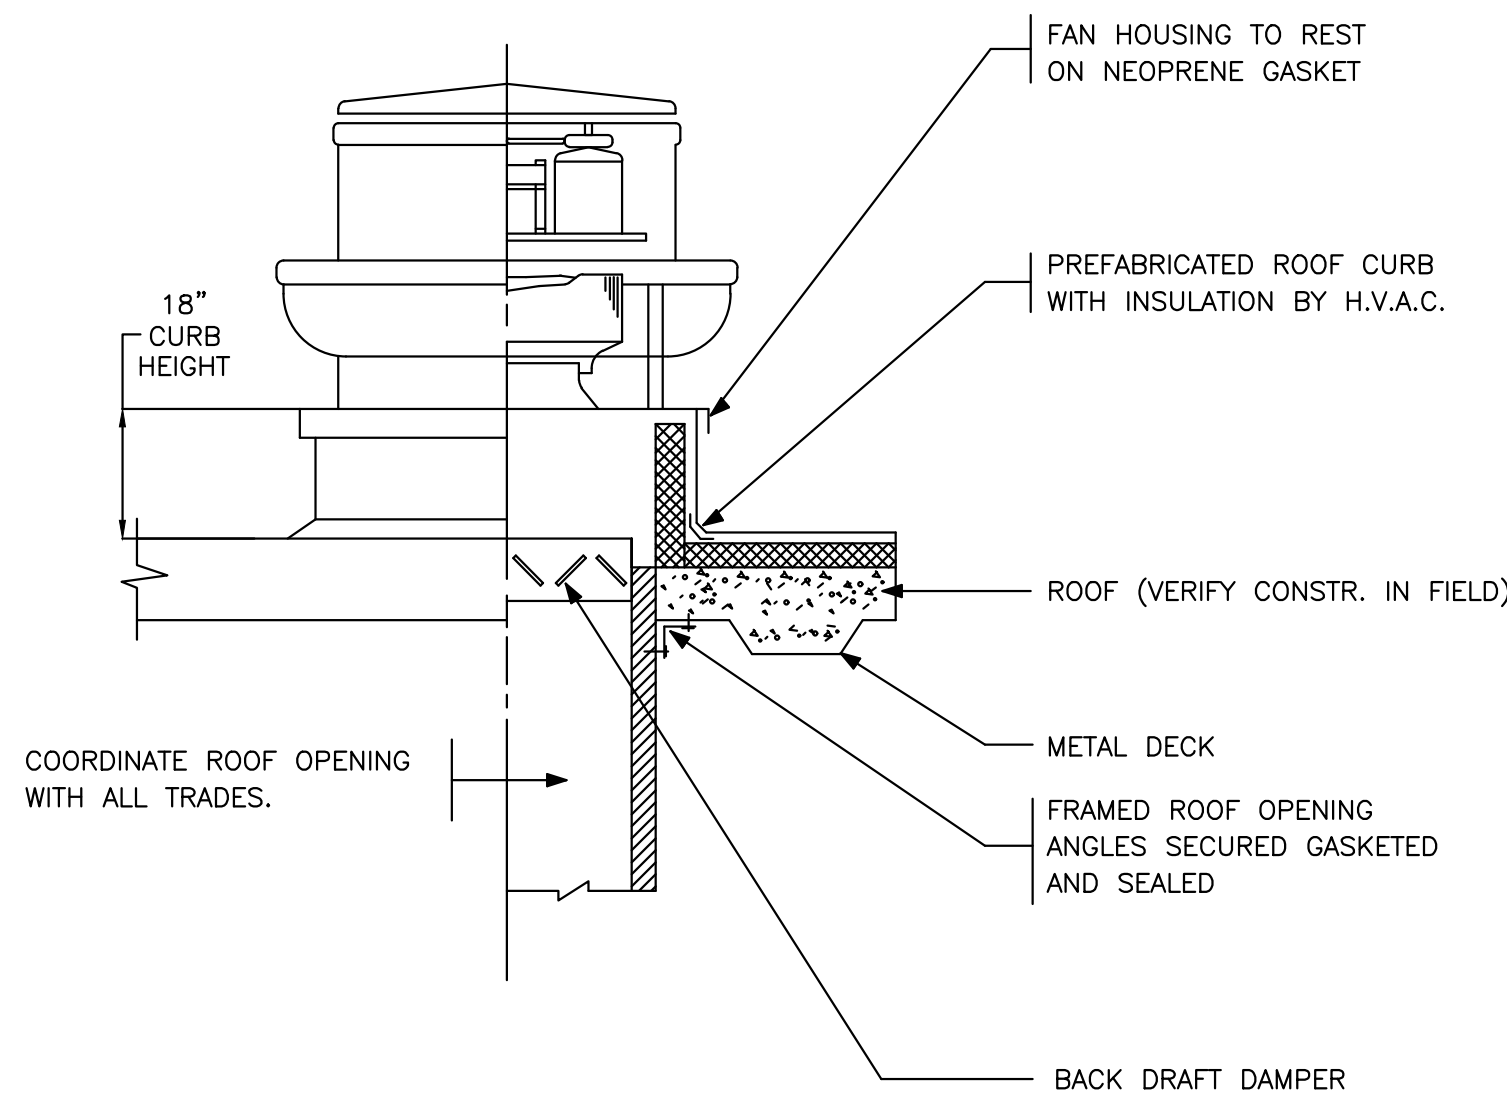


1 ROOF MOUNTED EXHAUST FAN DETAIL (KXF)
M5.3 N.T.S

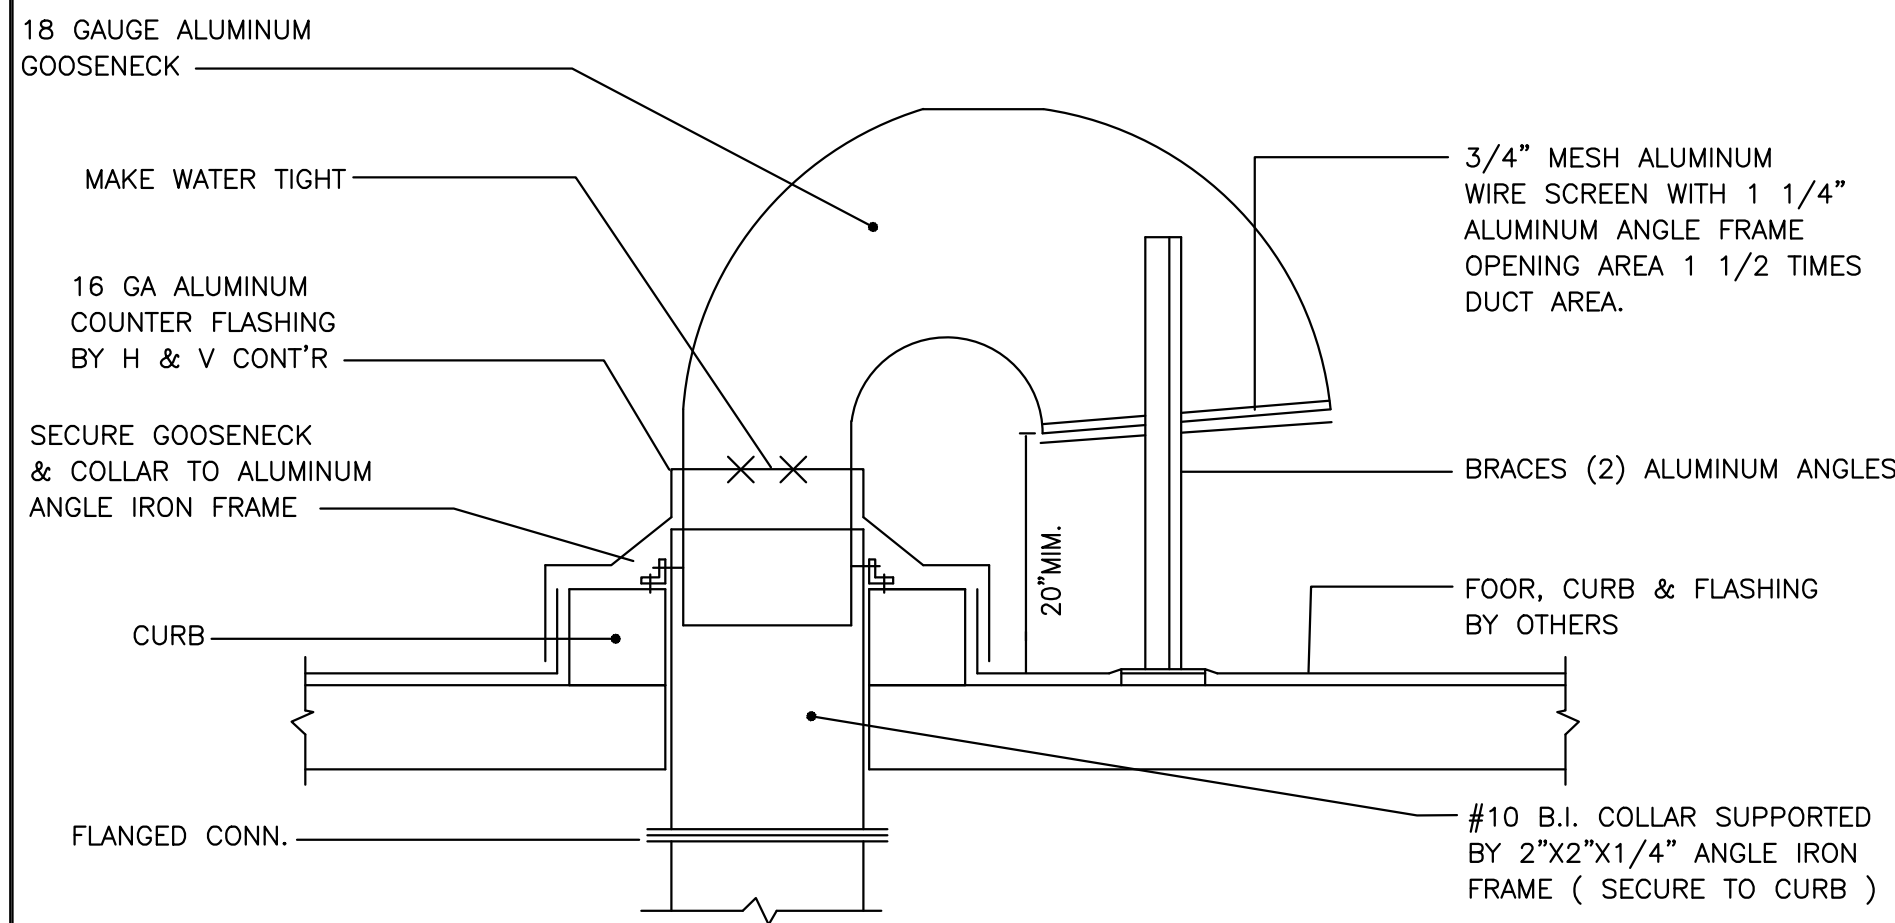


2 TYPICAL DETAIL OF ROOF GOOSENECK
M5.3 N.T.S

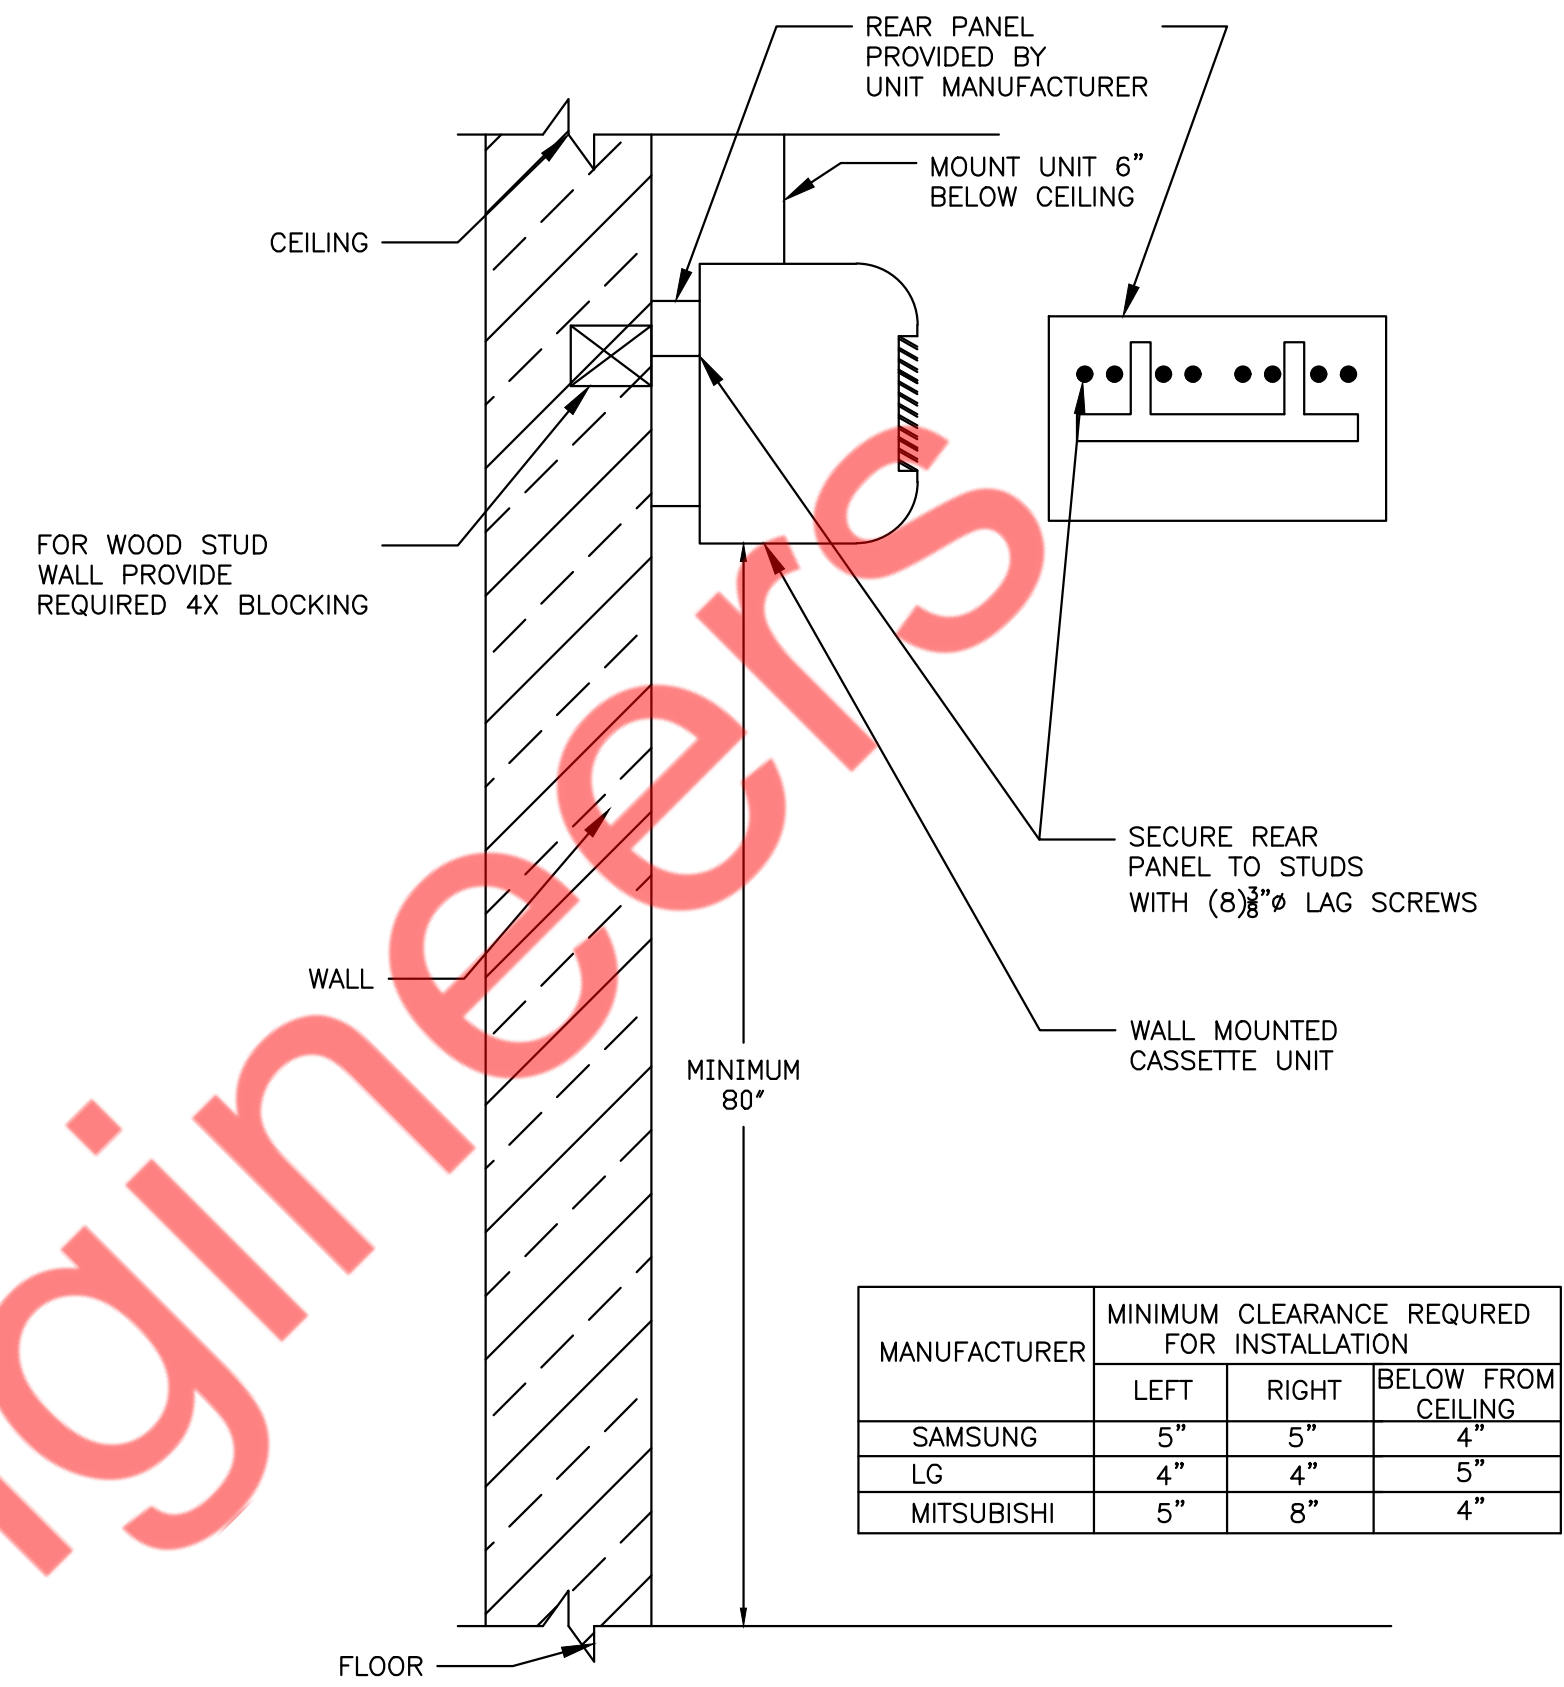

3 WALL MOUNTED UNIT DETAIL
M5.3 N.T.S

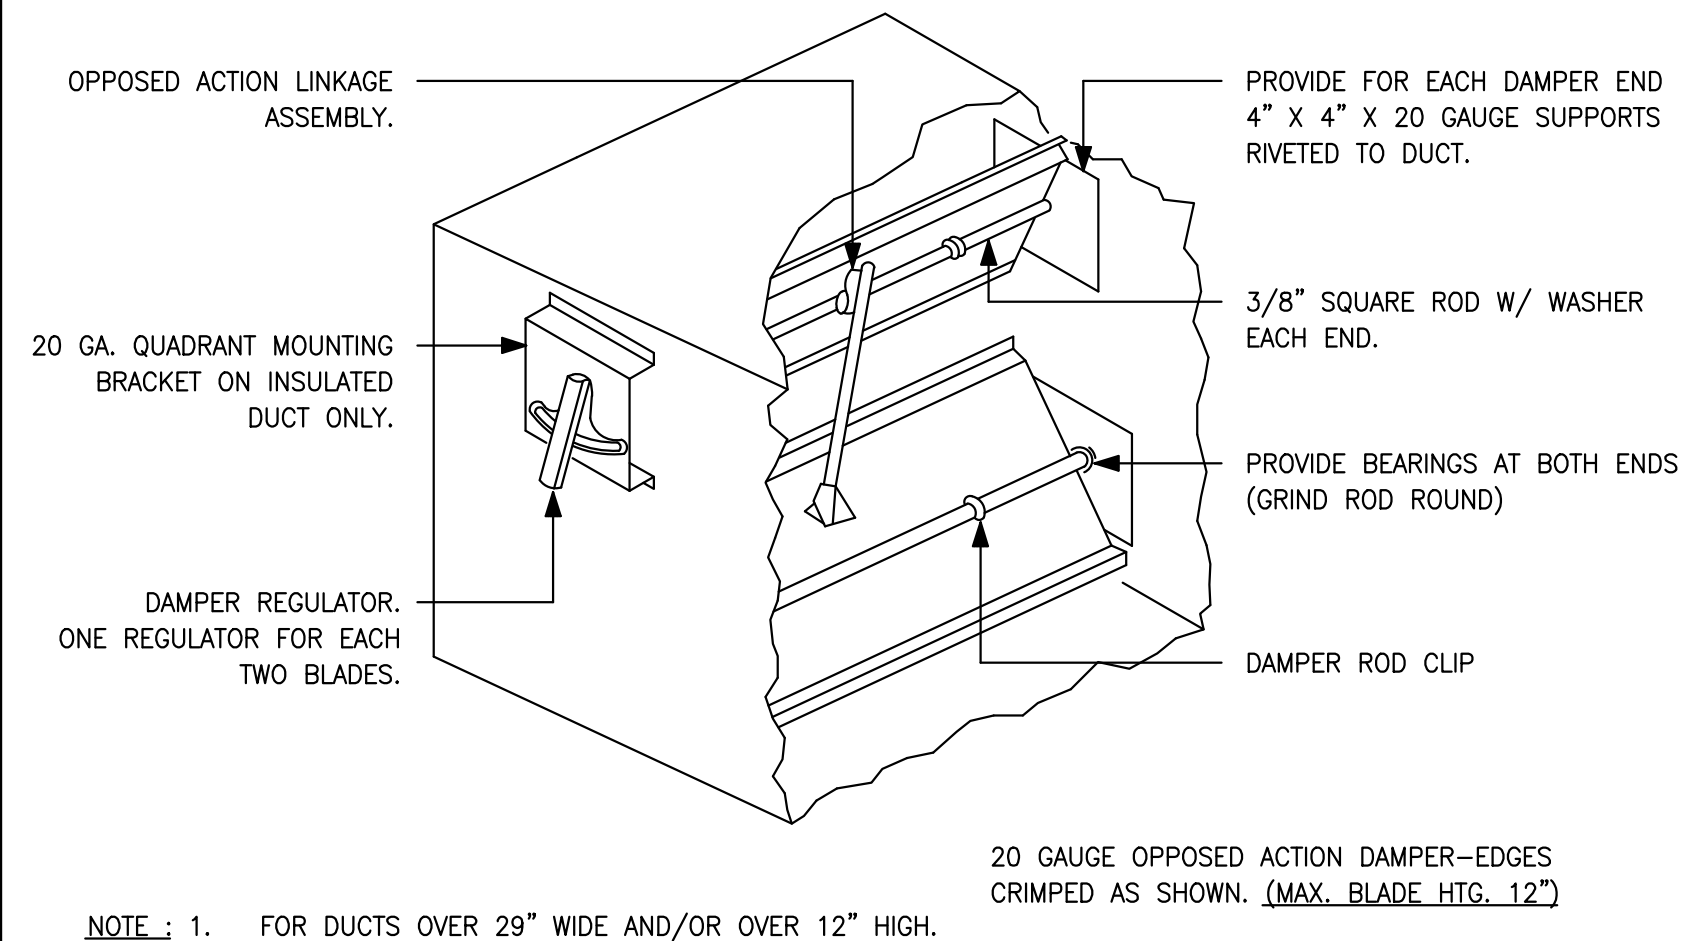

4 LOW PRESSURE BALANCING DAMPER
M5.3 N.T.S

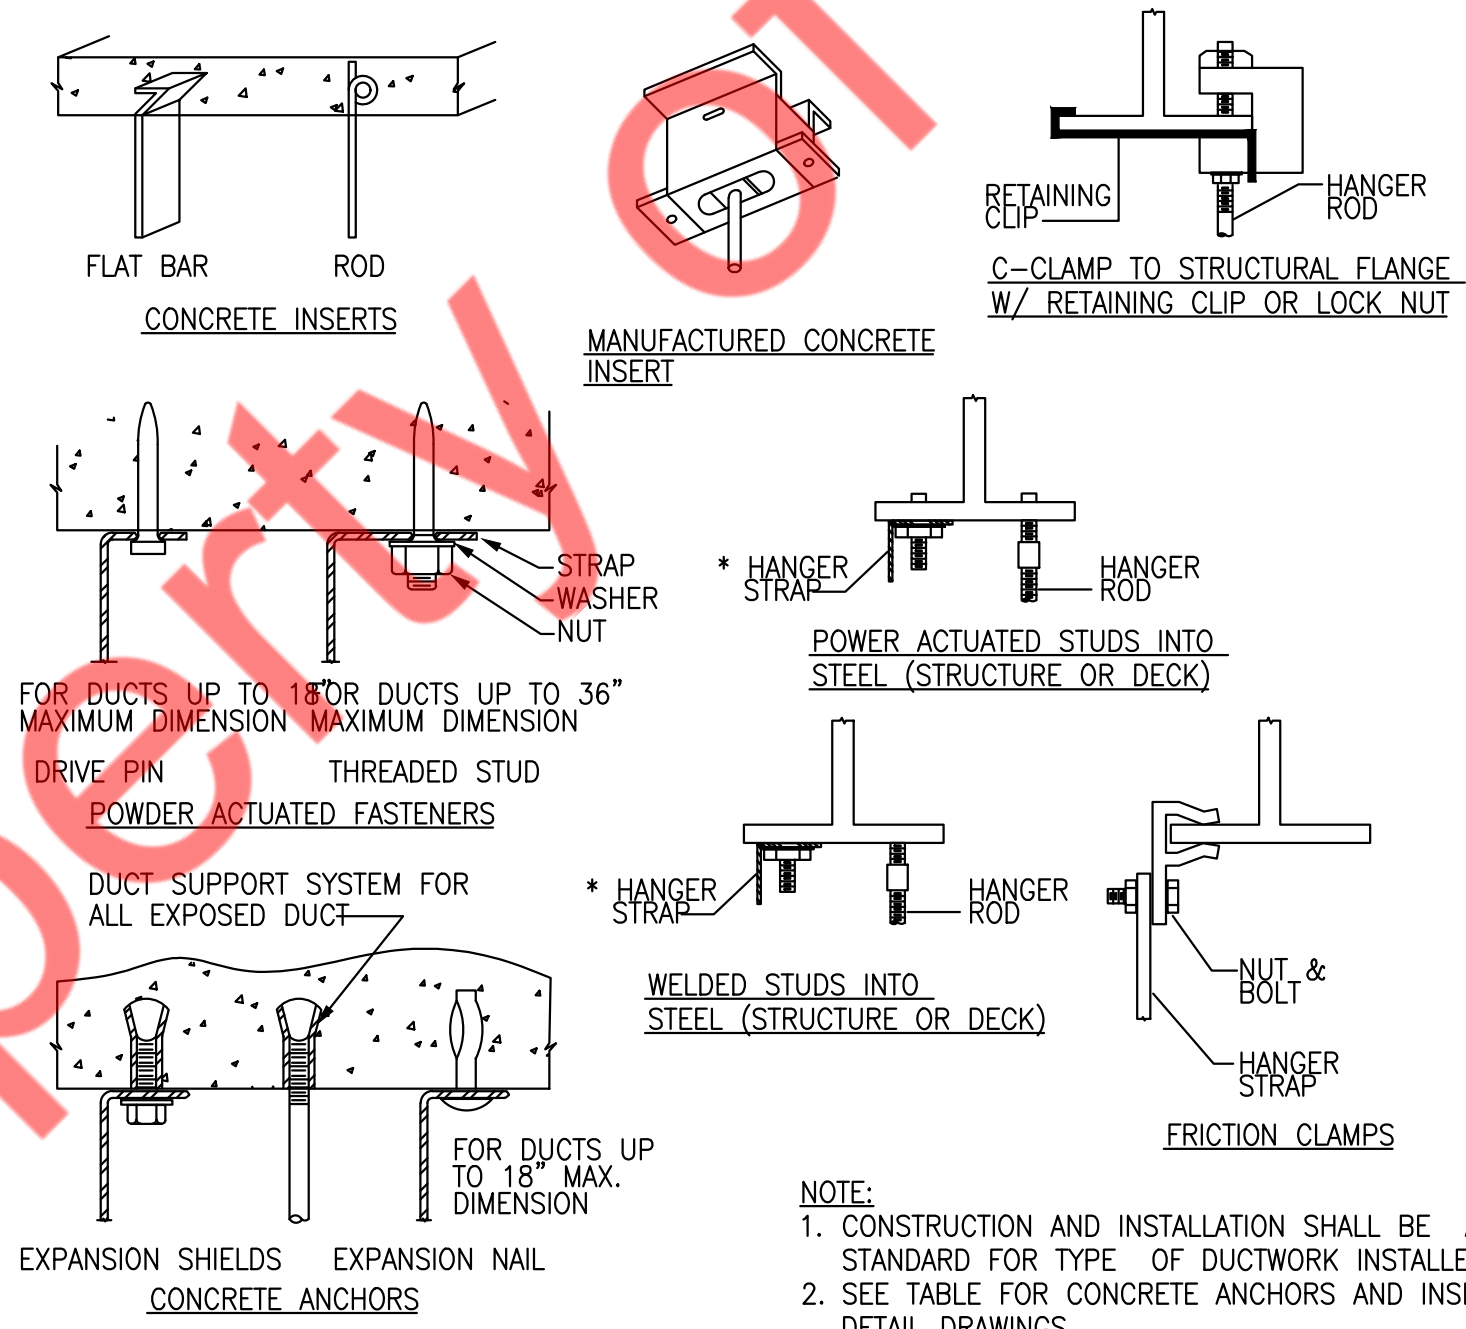

6 UPPER ATTACHMENT METHOD OF HANGING DUCT AND EQUIPMENT DETAIL
M5.3 N.T.S

REVISION SCHEDULE			
NO.	REV.	SUBMISSION DATE	ISSUED BY
1		PERMIT SET	06/21/22 NYE

ISSUE DATE: 4/6/2022 5:19:23 PM

RENOVATION
FOUR STAR
MUSHROOMS

DRAWN BY:	NYE
QAQC:	
APPROVED BY:	NYE
PROJECT NUMBER:	2206


MECHANICAL DETAILS
(3 OF 3)
M5.3

DOAS UNIT SCHEDULE																								
UNIT ID	MANUFACTURER	MODEL	TYPE	LOCATION	AREA SERVED	NOMINAL TONS	SUPPLY FAN		GAS HEAT		COOLING DATA				COMPRESSOR DETAILS				ELECTRICAL DATA				IEER	OPERATING WEIGHT (LBS.)
							TOTAL AIRFLOW	ESP. (IN. WC)	INPUT MBH	OUTPUT MBH	TOTAL MBH	SENSIBLE MBH	AMBIENT DB (°F)	LEAVING DB / WB (°F)	NO. OF COMPRESSORS	COMPRESSOR HP	TYPE OF REFRIGERANT	WEIGHT OF REFRIGERANT (LBS.)	VOLTS	PHASE	MCA (A)	MOCp (A)		
DOAS-1	CAPTIVEAIRE	CASRTU3-I.300-15-15T-DOAS	SELF-CONTAINED	ROOF	SEE ON PLAN	15	2400	0.25	300	240	186	71	84.3	56.2/54.4	1	VARIABLE SPEED VFD	R410A	33	208	3	59.2	60	18.8	2600
DOAS-2	CAPTIVEAIRE	CASRTU3-I.300-15-15T-DOAS	SELF-CONTAINED	ROOF	SEE ON PLAN	15	2400	0.25	300	240	186	71	84.3	56.2/54.4	1	VARIABLE SPEED VFD	R410A	33	208	3	59.2	60	18.8	2600
DOAS-3	CAPTIVEAIRE	CASRTU3-I.400-15-20T-DOAS	SELF-CONTAINED	ROOF	SEE ON PLAN	20	3000	0.5	375	300	264	99.6	84.3	52.8/50.2	1	VARIABLE SPEED VFD	R410A	35	208	3	80.6	90	18.2	2700
NOTES:-																								
1) REFER TO SHEETS M7.2 & M7.3 FOR MORE DETAILS.																								
2) ALL UNITS ARE AIR COOLED DOAS UNITS.																								
3) ALL UNITS ARE TO BE REMOTE CONTROLLED.																								

HEAT PUMP CONDENSING UNITS SCHEDULE																								
UNIT TAG	TYPE	LOCATION	INDOOR UNIT SERVED	CAP.TR	COOLING MBH	HEATING MBH	COMPRESSOR TYPE	NO. OF COMPRESSOR PER UNIT	COMPRESSOR HP	TYPE OF REFRIGERANT	WEIGHT OF REFRIGERANT (LBS.)	UNIT DIMENSIONS IN.(HXWXD)	WEIGHT (LBS)	PIPING DIMENSION		ELECTRICAL		MOP (A)	EER	IEER	COP	SOUND LEVEL (Dba)	MODEL NO.	MAKE
														LIQUID-HI PRESSURE	GAS HIGH-PRESSURE	(V/Hz/Ph)	MCA (A)							
ACCU-1(N)	REMOTE	SEE ON PLAN	AC-1 TO AC-8(N)	8	96	108	INVERTER SCROLL HERMATIC	1	7.37	R410	21.56	72"X49"X30"	600	3/8"	7/8"	208/60/3	33	50	14.6	32.6	4.34	58.5	TUHYPO963AN	mitsubishi
ACCU-2(N)	REMOTE	SEE ON PLAN	AC-9 TO AC-17(N)	8	96	108	INVERTER SCROLL HERMATIC	1	7.37	R410	21.56	72"X49"X30"	600	3/8"	7/8"	208/60/3	33	50	14.6	32.6	4.34	58.5	TUHYPO963AN	mitsubishi
ACCU-3(E)	REMOTE	SEE ON PLAN	AC-18(E)	2	SAE	SAE	SAE	SAE	SAE	SAE	SAE	SAE	SAE	SAE	SAE	SAE	SAE	SAE	SAE	SAE	SAE	SAE	38MARBQ24AA3	BRYANT
ACCU-4(E)	REMOTE	SEE ON PLAN	AC-19(E)	1.5	SAE	SAE	SAE	SAE	SAE	SAE	SAE	SAE	SAE	SAE	SAE	SAE	SAE	SAE	SAE	SAE	SAE	SAE	38MARBQ18AA3	BRYANT
ACCU-5(E)	REMOTE	SEE ON PLAN	AC-20(E)	2	SAE	SAE	SAE	SAE	SAE	SAE	SAE	SAE	SAE	SAE	SAE	SAE	SAE	SAE	SAE	SAE	SAE	SAE	38MHRBQ24AA3	BRYANT
ACCU-6(N)	REMOTE	SEE ON PLAN	AC-21(N)	0.75	9	12	DC-INVERTER DRIVEN	2.37	1.91	R410	1.05	25"X38"X15"	90	1/4"	3/8"	208-230/60/1	9	15	13.4	-	3.9	50	SLZ-KA09NA2	mitsubishi
NOTES:-																								
1. UNIT SHALL HAVE TEN YEAR EXTENDED WARRANTY FOR COMPRESSORS/PARTS.																								
2. PROVIDE LOW AMBIENT CONTROL FOR CONDENSING UNIT OPERATION DOWN TO -4°F.																								
3. PROVIDE COMPRESSOR CYCLE PROTECTOR.																								
4. PROVIDE STEEL RAILS AND VIBRATION ISOLATORS FOR CONDENSER MOUNTING.																								
5. STEEL RAILS TO BE PROVIDED BY MECH. CONTRACTOR.																								
6. CONTRACTOR SHALL PROVIDE A LONG LINE SET FOR REFRIGERANT PIPING IN THE EVENT THAT TOTAL REFRIGERANT LENGTH EXCEED THE MANUFACTURER'S STANDARD RECOMMENDED LENGTH.																								

ROOF TOP UNIT SCHEDULE																												
UNIT ID	MANUFACTURER	MODEL	TYPE	LOCATION	AREA SERVED	NOMINAL TONS	SUPPLY FAN		GAS HEAT		COOLING					COMPRESSOR DETAILS				ELECTRICAL DATA				EER	THERMAL EFFICIENCY	IEER	OPERATING WEIGHT (LBS.)	
							TOTAL AIRFLOW (CFM)	OUTSIDE AIR FLOW (CFM)	EXT. STATIC PRESS. (IN. WC)	INPUT MBH	OUTPUT MBH	TOTAL MBH	SENSIBLE MBH	AMBIENT DB (°F)	ENTERING DB / WB (°F)	STAGES	NO. OF COMPRESSORS PER UNIT	COMPRESSOR HP	TYPE OF REFRIGERANT	WEIGHT OF REFRIGERANT (LBS.)	VOLTS	PHASE	MCA (A)					MOCp (A)
RTU-1 (N)	TRANE	YHC036E3	SELF-CONTAINED	ROOF	SEE ON PLAN	3	1200	260	1	120	96	37.2	27.8	95	80.0/67.0	1	1	2.7	R410A	6.2	208	3	20.6	30	12.7	80%	-	800
RTU-2(N)	TRANE	YHC092F3	SELF-CONTAINED	ROOF	SEE ON PLAN	7.5	3000	535	1	200	160	89	66.6	95	80.0/67.0	2	2	4.1	R410A	6.2	208	3	41.9	50	12.6	80%	14.5	1200
RTU-3(N)	TRANE	YHC102F3	SELF-CONTAINED	ROOF	SEE ON PLAN	8.5	3400	670	1	200	160	102	77.9	95	80.0/67.0	2	2	5.1	R410A	6.6	208	3	42	50	12.5	80%	14.7	1300
NOTES:-																												
1) ALL EQUIPMENT MUST BE HIGH EFFICIENT, MEETING OR EXCEEDING THE BRANDS MINIMUM REQUIREMENTS.																												
2) ELECTRICAL CONNECTION TO BE SINGLE POINT AND TO BE THROUGH THE BOTTOM OF THE UNIT.																												
3) PROVIDE DISCONNECT SWITCH AND AN UNPOWERED GFCI RECEPTACLE.																												
4) 14" ROOF CURB - CONTRACTOR SHALL FIELD INSULATE. SHIP ASAP AHEAD OF THE UNIT.																												
5) CONDENSATE DRAIN WITH 2" DEEP VENTED TRAP DISCHARGE TO SPLASH BLOCK ON ROOF.																												
6) CABINET WITH 1/2" FIBERGLASS INSULATION.																												
7) UNIT SHALL BE COMPLETE WITH GAS HEATING SECTION. GAS REGULATOR TO RECEIVE 7" GAS PRESSURE FROM MAIN.																												
8) PROVIDE 8-WIRE, 24 VAC, AUTOMATIC CHANGEOVER, 2-STAGE HEAT / COOL, REMOTELY PROGRAMMABLE THERMOSTAT																												
9) REMOTE SENSORS SHALL BE PROVIDED IN SPACE WIRED BACK TO PROGRAMMABLE, 24 HOUR, 7 DAY, THERMOSTATS.																												
10) ANTI SHORT CYCLE TIMER.																												
11) THROWAWAY 2" FILTERS (MERV 8).																												
12) WHERE REQUIRED, PROVIDE LOW AMBIENT COOLING CAPABILITY DOWN TO 0 DEGREES F.																												
13) PROVIDE ALL COMPRESSORS WITH 5 YEAR WARRANTY.																												
14) RETURN AIR SMOKE DETECTOR - UNIT MOUNTED.																												
15) VFD SUPPLY FAN.																												
16) IF REQUIRED: TRANE-HOT GAS REHEAT WITH ASSOCIATED CONTROLS & SENSOR FOR HUMIDIFICATION CONTROL.																												
17) PLUMBING CONTRACTOR TO COORDINATE EXACT GAS REQUIREMENT OF RTU INSTALLED ON SITE.																												
18) PROVIDE AIR-SIDE ECONOMIZER FOR RTU-2 (N) & RTU-3(N). PROVIDE FDD.																												

PERFORATED SUPPLY PLENUM(S)											
HOOD NO	TAG	POS	LENGTH	WIDTH	HEIGHT	TYPE	RESERVE(S)				
							WIDTH	LENGTH	DIA	CFM	SP
1		Front	145"	14"	6"	MUA	10"	24"		586	0.186"
						MUA	10"	24"		586	0.186"
						MUA	10"	24"		586	0.186"

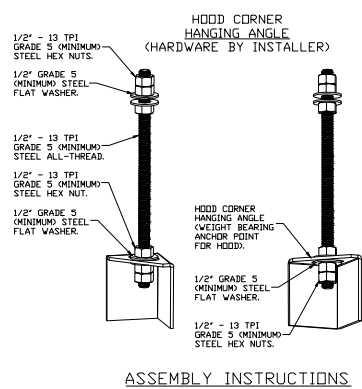

HANGING ANGLE MUST BE SUPPORTED WITH 1/2" - 13 TP1
GRADE 5 MINIMUM ALL-THREAD. SANDWICH HANGING
ANGLES AND CEILING ANCHOR POINTS WITH 1/2" GRADE 5
MINIMUM STEEL FLAT WASHERS AND 1/2" - 13 TP1
GRADE 5 MINIMUM HEX NUTS AS SHOWN. MUST USE
DOUBLED HEX NUT CONFIGURATION BENEATH HOOD HANGING
ANGLES AND ABOVE CEILING ANCHORS. MAINTAIN 1/4" OF
EXPOSED THREADS BENEATH BOTTOM HEX NUT. TORQUE
ALL HEX NUTS TO 57 FT-LBS.


[illegible]

SYSTEM DESIGN VERIFICATION (SDV)


IF ORDERED, CAS SERVICE WILL PERFORM A SYSTEM DESIGN VERIFICATION (SDV) ONCE ALL EQUIPMENT HAS HAD A COMPLETE START UP PER THE OPERATION AND INSTALLATION MANUAL. TYPICALLY, THE SDV WILL BE PERFORMED AFTER ALL INSPECTIONS ARE COMPLETE.

ANY FIELD RELATED DISCREPANCIES THAT ARE DISCOVERED DURING THE SDV WILL BE BROUGHT TO THE ATTENTION OF THE GENERAL CONTRACTOR AND CORRESPONDING TRADES ON SITE. THESE ISSUES WILL BE DOCUMENTED AND FORWARDED TO THE APPROPRIATE SALES OFFICE. IF CAS SERVICE HAS TO RESOLVE A DISCREPANCY THAT IS A FIELD ISSUE, THE GENERAL CONTRACTOR WILL BE NOTIFIED AND BILLED FOR THE WORK. SHOULD A RETURN TRIP BE REQUIRED DUE TO ANY FIELD RELATED DISCREPANCY THAT CANNOT BE RESOLVED DURING THE SDV, THERE WILL BE ADDITIONAL TRIP CHARGES.

DURING THE SDV, CAS SERVICE WILL ADDRESS ANY DISCREPANCY THAT IS THE FAULT OF THE MANUFACTURER. SHOULD A RETURN TRIP BE REQUIRED, THE GENERAL CONTRACTOR AND APPROPRIATE SALES OFFICE WILL BE NOTIFIED. THERE WILL BE NO ADDITIONAL CHARGES FOR MANUFACTURER DISCREPANCIES.

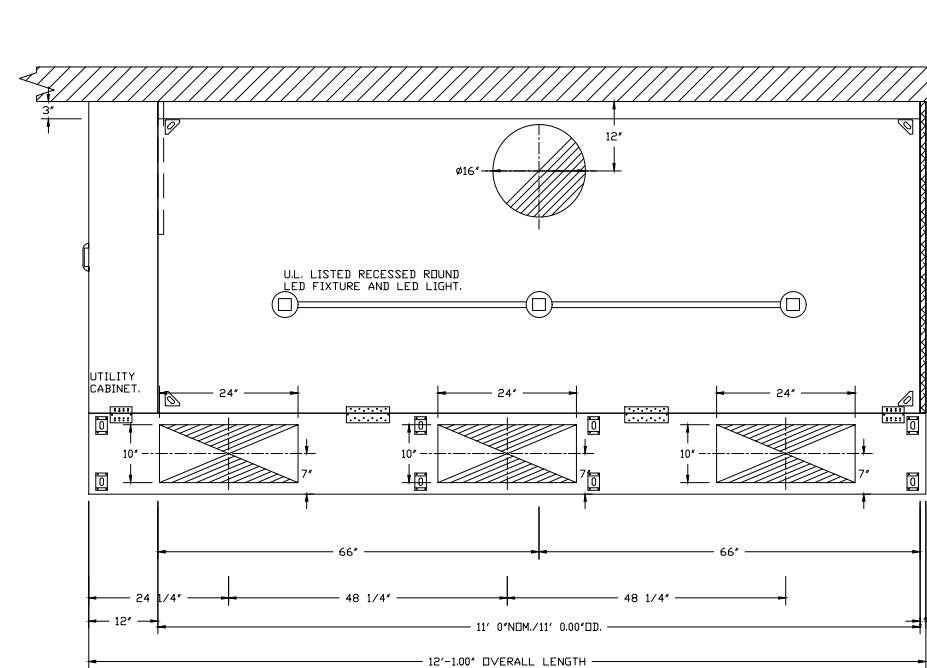


PLAN VIEW - HOCO #1
11' 0.00" LONG 5424ND-2-PSP-F

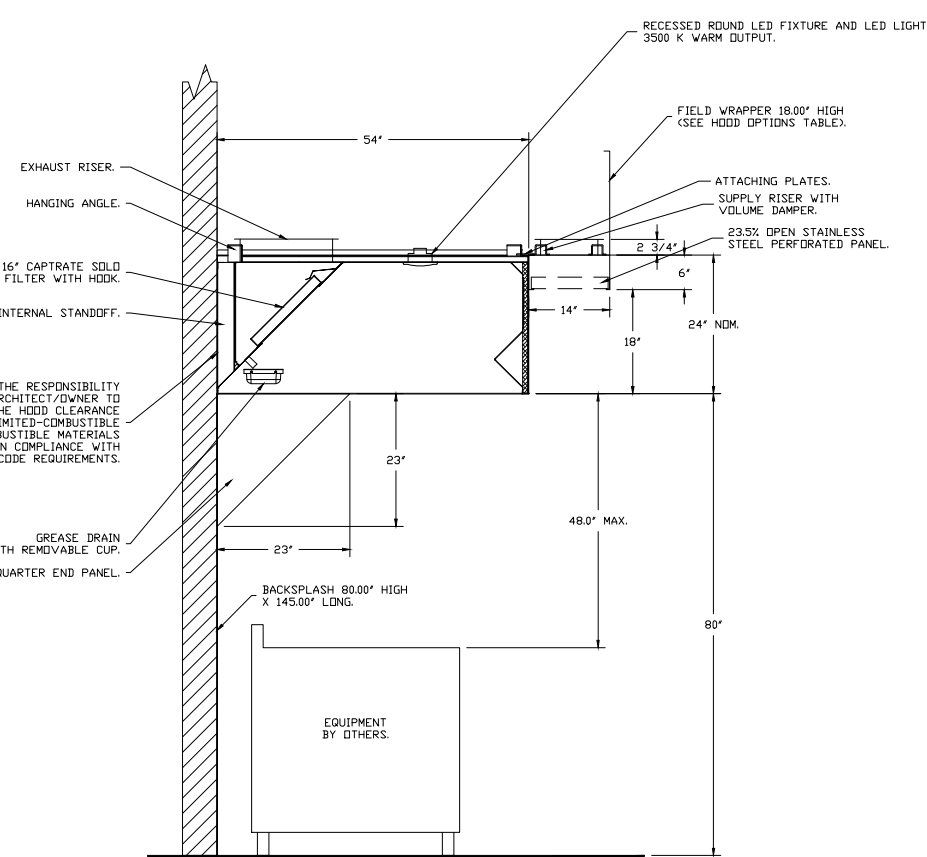

SECTION VIEW - MODEL 5424ND-2-PSP-F
HOOD - #1

MVA FAN INFORMATION - JOB#5368789																			
FAN UNIT NO	TAG	QTY	FAN UNIT MODEL #	BLOWER	HOUSING	CMF	DESIGN CFM	ESP	RPM	MOTOR ENCL	HP	BHP	PHASE	VOLT	FLA	NCA	MCCP	WEIGHT (LBS)	SDNES
2	1		A1-D250-25D-MPU	DMF-1-MOD	A1-D250	1000	1760	0.460	1964	ODP PREMIUM	1.500	1.6500	3	208	4.4	20.5A	316	1083	19.6

2	DX	1760	960°F	730°F	774°F	678°F	***	***	***	***	32.7 MM	22.9 MM	9.8 MM
GAS FIRED MAKE-UP AIR UNIT(S)													
FAN UNIT NO	TAG	INPUT BTUS	OUTPUT BTUS	TEMP RISE	REQUIRED INPUT GAS PRESSURE	GAS TYPE	BURNER EFFICIENCY(%)						
2	142011	130650	71°F	7 IN. W.C. - 14 IN. W.C.	NATURAL	92							

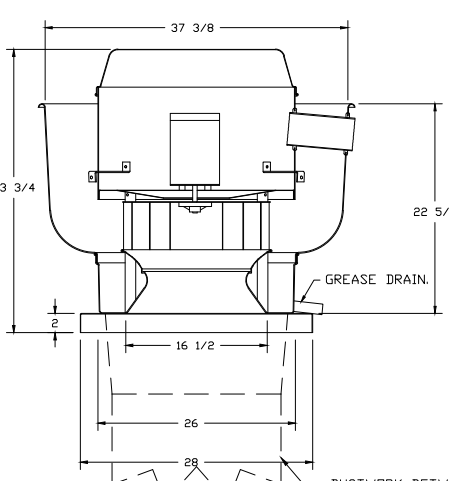


- DIRECT DRIVE CONSTRUCTION ON BELTS/PULLEYS
- ROLF MOUNTED FANS
- RESTAURANT MODEL
- UL705 AND UL742 AND UL504S
- VARIABLE SPEED CONTROL
- INTERNAL WIRING
- THERMAL PROTECTION (THERMAL PROTECTION CENSUS PHASES)
- HIGH HEAT OPERATION 300° (400°)
- DREASE SAFETY INSPECTION TESTING
- NEMA 3R CLASSIFICATION SWITCH

NORMAL TEMPERATURE TEST


EXHAUST FAN MUST OPERATE CONTINUOUSLY WHILE EXHAUSTING AT 170° (140°) UNTIL ALL FAN PARTS HAVE REACHED THERMAL EQUILIBRIUM, AND WITHOUT ANY SIGNIFICANT EFFECTS TO THE FAN WHEN WOULD CAUSE UNFAIR OPERATION.

ABNORMAL FLAME-UP TEST

EXHAUST FAN MUST OPERATE CONTINUOUSLY WHILE CONSUMING BURNING GASES VAPORS AT 600° (500°) FOR A PERIOD OF 15 MINUTES WITHOUT THE FAN BECOMING DAMAGED TO ANY EXTENT THAT COULD CAUSE A SAFETY CRISIS.

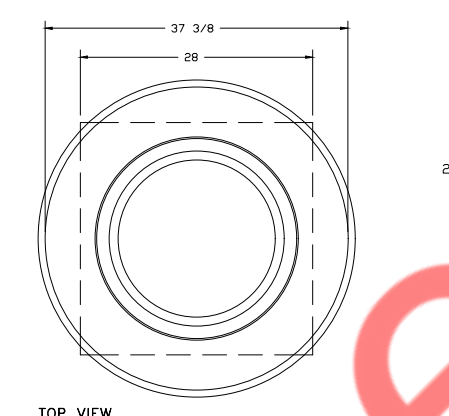

OPTIONS
GREASE BOX
FAN BASE CERAMIC SEAL - SHIP LOOSE -
FOR GREASE DUCTS.

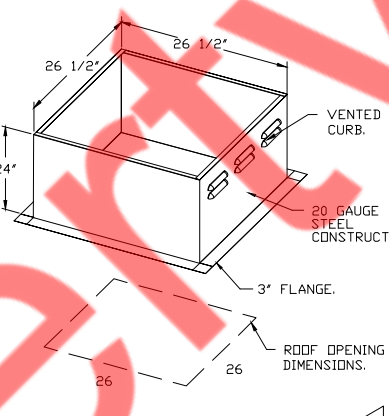

REVISIONS	
NO.	DESCRIPTION
1	
2	
3	
4	
5	
6	
7	
8	
9	
10	

CAPTIVE

Chicago Mechanical Office

2777 19th St., 27th Floor, New York, NY 10011-3740 (212) 775-2660 / Fax: (212) 775-6988 EMAIL: info@cmo.com

WWW.CMOCOM.COM

Four Stor Mushroom - Chicago

DATE: 3/9/2022

DWG.#: 5368769

DRAWN BY: Jeremy

SCALE: 3/4" = 1'-0"

MASTER DRAWING

SHEET NO. 3

Four Star Mushroom - Chicago

DATE: 3/9/2022

DWG.#: 5368789

DRAWN BY: Jeremy

SCALE: 3/4" = 1'-0"

MASTER DRAWING


SHEET NO.

3

SHEET NO.
3

FIRE SYSTEM INFORMATION - JOB#5368789						
FIRE SYSTEM NO	TAG	TYPE	SIZE	FLOW POINTS	INSTALLATION	
					SYSTEM	LOCATION ON HOOD
1		TANK FS	4.0/4.0	37	FIRE CABINET LEFT	LEFT, HOOD 1

GAS VALVE(S)				
FIRE SYSTEM NO	TAG	TYPE	SIZE	SUPPLIED BY
1		SC ELECTRICAL	1.000	CAPTIVEURE SYSTEMS

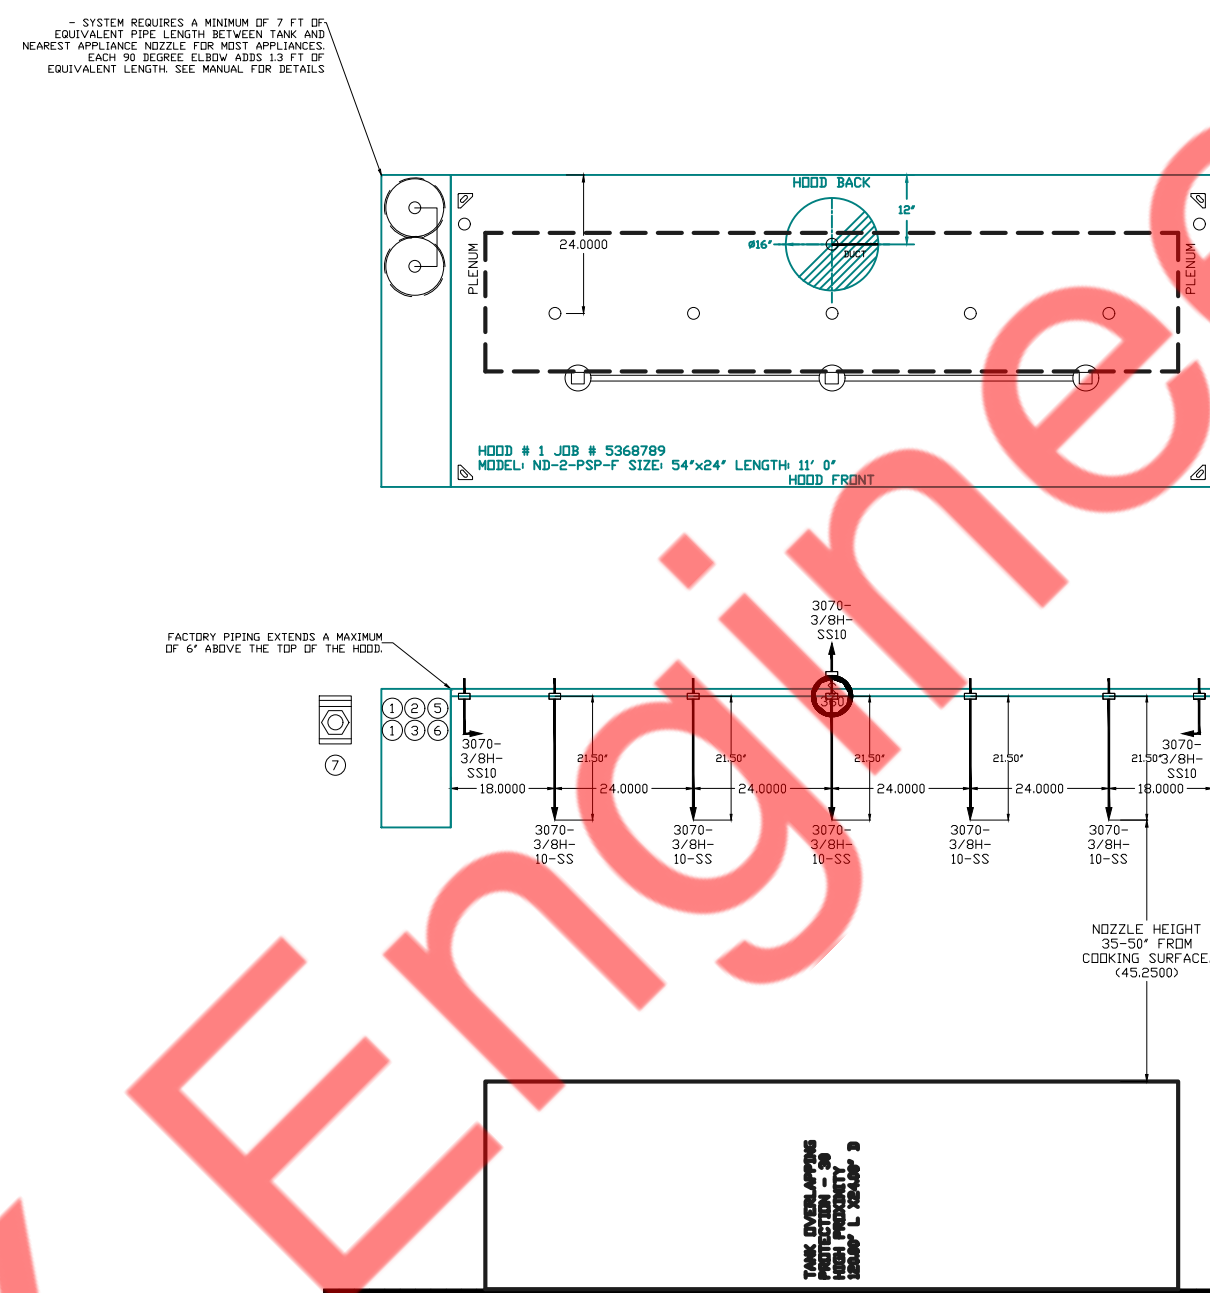

- NOTES
- FIELD PIPE DROPS AS SHOWN
- PIPING, ELBOWS, TEES, AND NOZZLES SUPPLIED BY GAS.
- REPLICATE NOZZLES IF FLOW PATTERN IS BLOCKED BY SHELVING, CRAWLERS, ETC.
- OVERLAPPING COVERAGE SHALL NOT BE USED ON ANY APPLIANCE WITH AN OBSTRUCTION IF APPLICABLE, EXTENDED PRE-PIPED DROPS ARE SHIPPED LOOSE.
- FACTORY PIPING EXTENDS A MAXIMUM OF 6" ABOVE THE TOP OF THE HOOD.
- APPLIANCE DIMENSIONS LISTED REPRESENT THE COOKING SURFACE SIZE, NOT THE OVERALL APPLIANCE SIZE.
- THIS FIRE SYSTEM COMPLIES WITH UL 300 REQUIREMENTS.

JOB #: 5368789.
JOB NAME: FOUR STAR MUSHROOM - CHICAGO
SYSTEM SIZE: TANK-SP-2 TOTAL FP REQUIRED
HOOD # 1 11' 0.00' LONG x 54' WIDE x 24'
RISER # 1 SIZE: 16" DIA.
HOOD # 1 METAL BLOW-OFF CAPS INCLUDED.

- HEAVY-DUTY APPLIANCES (RATED 600°F) WILL REQUIRE AN ADDITIONAL DOWNSTREAM FIRESTAT IN THE EVENT THAT THE DUCTWORK CONTAINS A HORIZONTAL RUNS OVER 25 FT IN LENGTH.
- MEDIUM TO LIGHT-DUTY APPLIANCES (RATED 450°F) WILL NOT REQUIRE ANY ADDITIONAL DOWNSTREAM DETECTION.

LEGEND - FIRE CABINET TANK SYSTEM

- 1 4 GALLON TANK.
2 PRIMARY ACTUATOR RELEASE.
3 SECONDARY ACTUATOR RELEASE.
4 PRESSURE SUPERVISION SWITCH.
5 PRIMARY HOSE ASSEMBLY.
6 SECONDARY HOSE ASSEMBLY.
7 REMOTE MANUAL ACTUATION DEVICE.

Four Star Mushroom - Chicago

DATE: 5/9/2022

DWG NO: 5368789

DRAWN BY: Jerry

SCALE:
3/4" = 1'-0"

MASTER DRAWING

SHEET NO.
2

REVISIONS

NO.	DESCRIPTION	DATE
1	ISSUED FOR PERMIT	5/9/22

Chicago Mechanical Office
www.cmo-engineers.com

2777 Maple Rd., 2nd Floor, Downer, IL 60515-3800 FAX: (708) 222-0688 EMAIL: info@cmo-engineers.com

REVISIONS	DESCRIPTION	DATE
Δ		
Δ		
Δ		
Δ		
 CAPTIVE AIR Chicago Mechanical Office 2777 Irving St., Ste. 27, Downey, CA 90241-3246 USA, (714) 371-6889 FAX: 714-371-6888 www.captiveair.com		
DATE: 3/9/2022 DWG. #: 33687169 DRAWN BY: JEREMY SCALE: 3/4" = 1'-0" MASTER DRAWING		
SHEET NO.		

REVISION SCHEDULE			
NO.	REV.	SUBMISSION DATE	ISSUED BY
1		PERMIT SET 06/21/22	NYE

ISSUE DATE: 4/6/2022 5:19:23 PM

RENOVATION

FOUR STAR
MUSHROOMS

DRAWN BY: NYE




QAQC:

APPROVED BY: NYE

PROJECT NUMBER: 2206

HOOD, MAKE-UP AIR UNIT &

M7.1

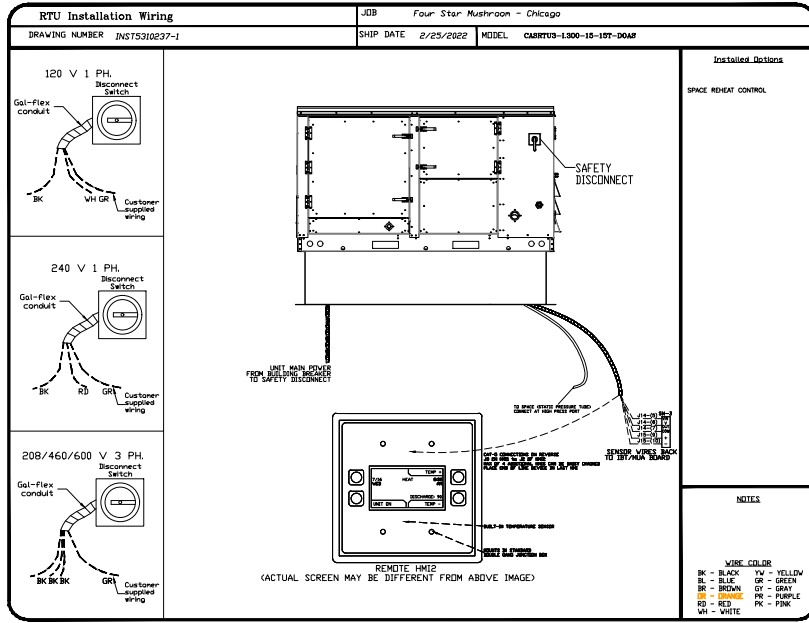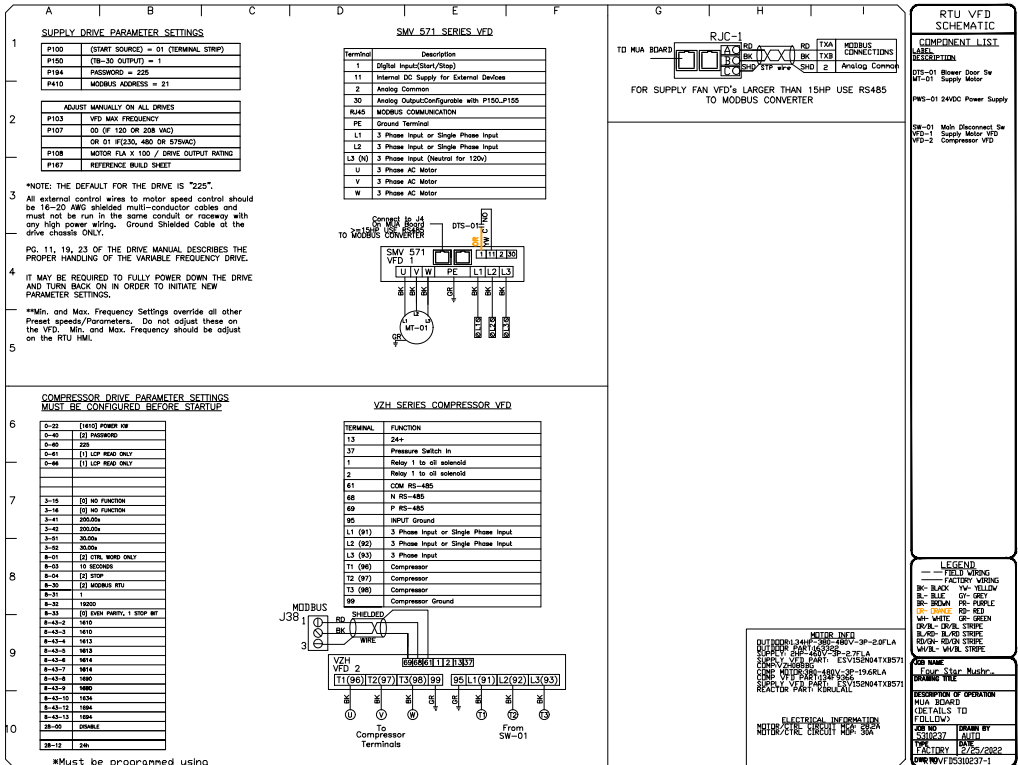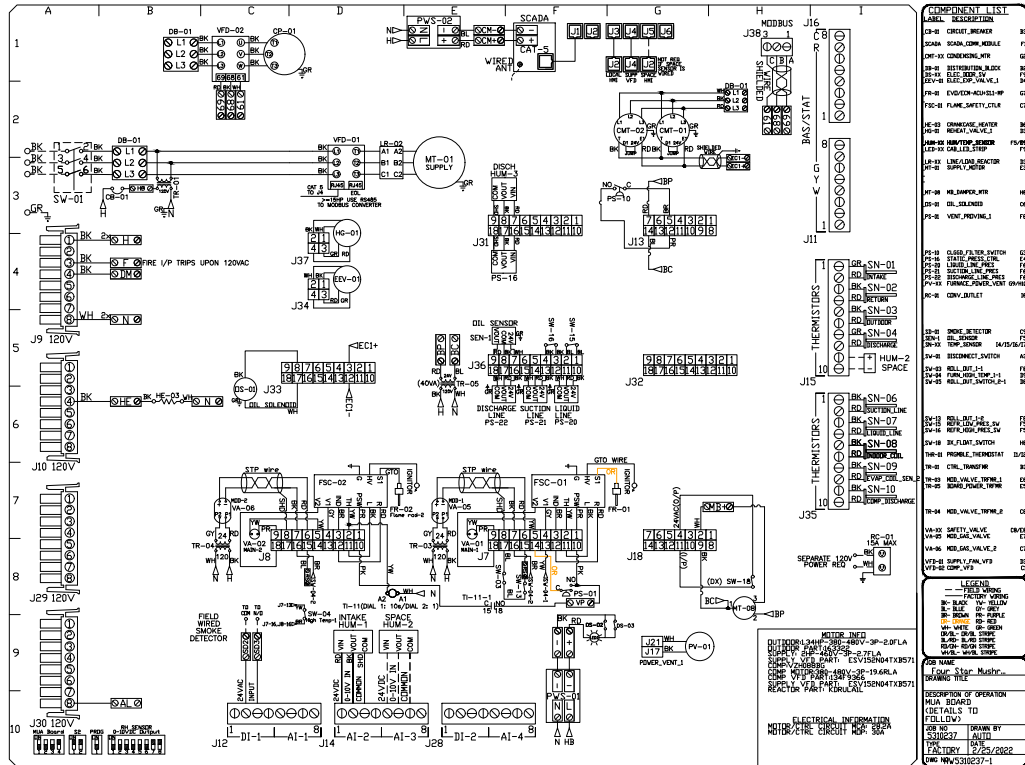

REVISIONS

DATE: 2/25/2022

DWG #: 5310237

DRAWN BY: Jeremy

SCALE: 3/4" = 1'-0"

MASTER DRAWING

SHEET NO. 4

REVISIONS

DATE: 2/25/2022

DWG #: 5310237

DRAWN BY: Jeremy




SCALE: 3/4" = 1'-0"

MASTER DRAWING

SHEET NO. 4

Four Star Mushroom - Chicago

CAPTIVE NY ENGINEERS
Chicago Mechanical Office
3777 Flinn Rd., Ste. 27, Downers Grove, IL 60551 PHONE: (630) 755-5800 FAX: (630) 755-5801 EMAIL: info@captive-ny.com

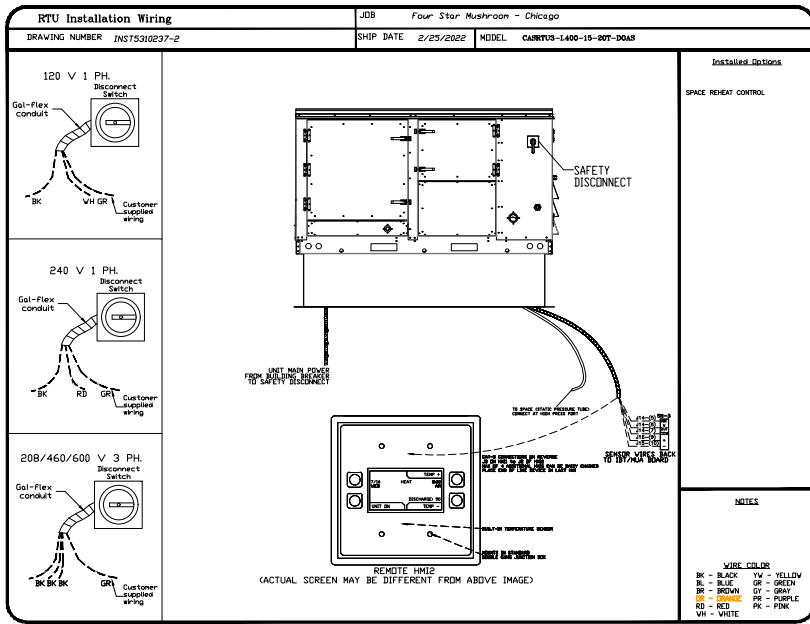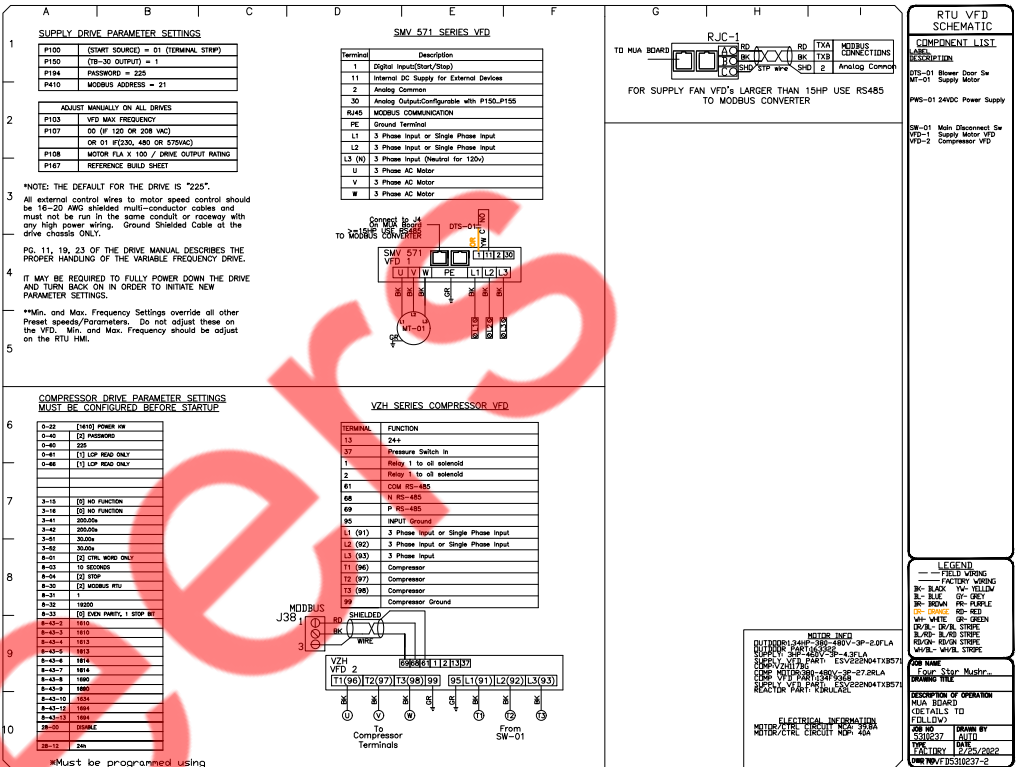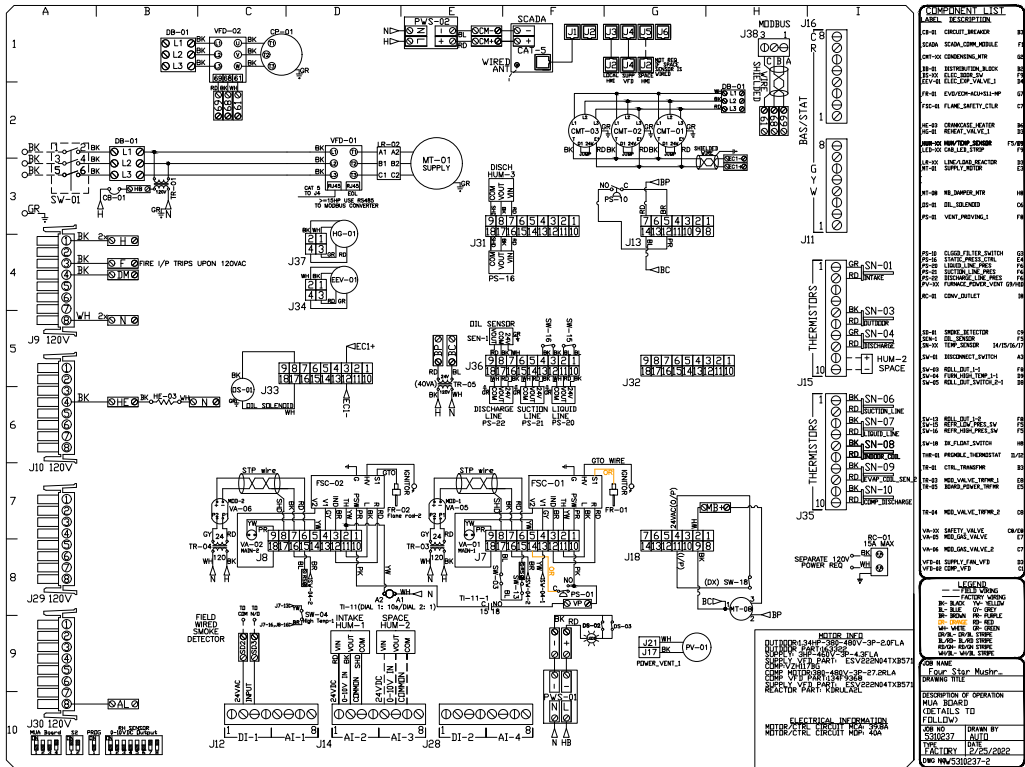

REVISIONS

DATE: 2/25/2022

DWG #: 5310237

DRAWN BY: Jeremy

SCALE: 3/4" = 1'-0"

MASTER DRAWING

SHEET NO. 5

REVISIONS

DATE: 2/25/2022

DWG #: 5310237

DRAWN BY: Jeremy

SCALE: 3/4" = 1'-0"

MASTER DRAWING

SHEET NO. 5


Four Star Mushroom - Chicago

CAPTIVE NY ENGINEERS
Chicago Mechanical Office
3777 Flinn Rd., Ste. 27, Downers Grove, IL 60551 PHONE: (630) 755-5800 FAX: (630) 755-5801 EMAIL: info@captive-ny.com

AIR DIFFUSION SUPPLY DUCT SPECIFICATIONS
PROVIDE AIR DIFFUSION SUPPLY DUCT EQUAL TO CAPTIVECAIRE SYSTEMS MODEL DW-S0(HC), DW-S90(HC), & DW-S180(HC).
THREE DISTINCT HOLE PATTERN OPTIONS TO COVER A VARIETY OF CEILING HEIGHTS.
NO ADDITIONAL DIFFUSERS REQUIRED, AS THE DUCT ITSELF PROVIDES AIR DIFFUSION.
MADE OF HIGH QUALITY STAINLESS STEEL DESIGNED TO LAST 20+ YEARS.
HIGH INDUCTION SUPPLY DUCT IS CONSTRUCTED USING 24 GAUGE, 430 SS - 5" THRU 24".
HIGH INDUCTION SUPPLY DUCT IS CONSTRUCTED USING 20 GAUGE, 430 SS - 26" THRU 36".
QUICK ONSITE ASSEMBLY USING EPDM GASKETS & UNIVERSAL V-BANDS.
DOUBLE WALL SUPPLY DUCT AVAILABLE FOR INTERIOR AND EXTERIOR SPACES, EITHER CONDITIONED OR UNCONDITIONED.
DOUBLE WALL SUPPLY DUCT AVAILABLE IN DW-1S, DW-2S, & DW-3S TO MEET SPECIFIC REGIONAL "R" VALUE REQUIREMENTS.

Insulation R-Value Recommendations		
Supply Duct Type	Minimum R-value	Space Type
Single Wall - S & -HC	N/A	Conditioned Space Only
Double Wall - 1S	R-4	Unconditioned Interior Space Only
Double Wall - 2S	R-8	Unconditioned Space Climate Zones 1-4
Double Wall - 3S	R-12	Unconditioned Space Climate Zones 5-8

DOUBLE WALL SUPPLY DUCT IS INSULATED WITH A 24 GAUGE 430 STAINLESS OUTER SHELL.
AIR DIFFUSION SUPPLY DUCT COMPLIES WITH SMACNA (SHEET METAL AND AIR CONDITIONING CONTRACTORS) BEST PRACTICES.
POSITIONING OF SPRINKLERS TO AVOID OBSTRUCTION TO DISCHARGE, SEE NFPA 13, TABLE 8.12.5.1.1.

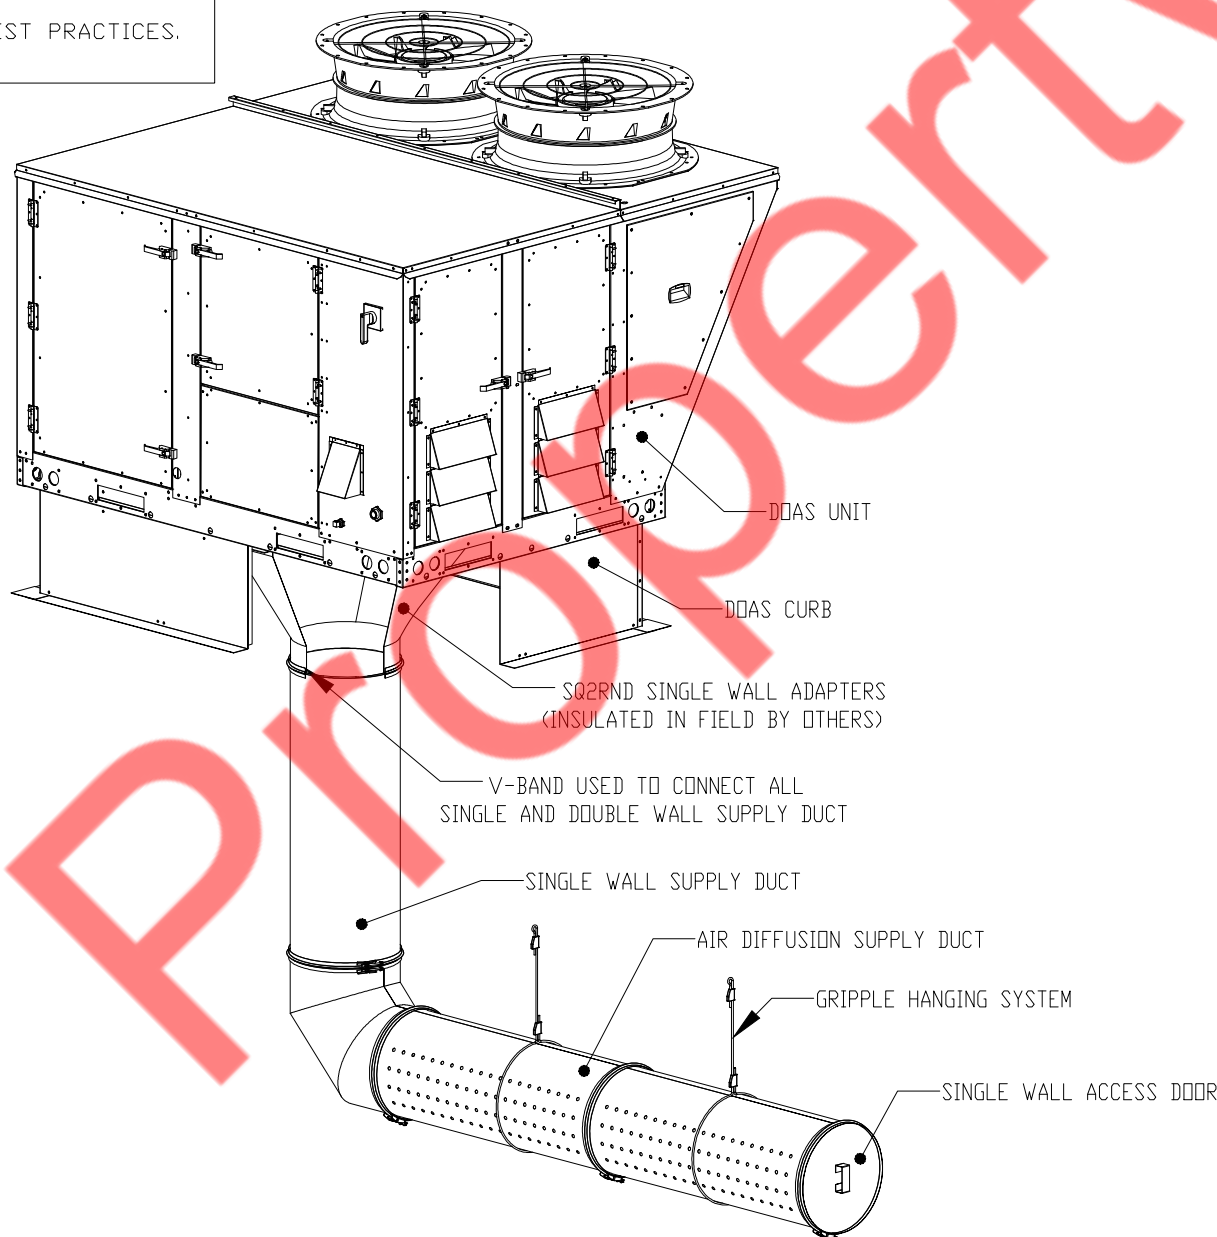

REVISIONS

DATE: 2/25/2022

DWG #: 5310237

DRAWN BY: Jeremy

SCALE: 3/4" = 1'-0"

MASTER DRAWING

SHEET NO. 6

REVISIONS

DATE: 2/25/2022

DWG #: 5310237

DRAWN BY: Jeremy

SCALE: 3/4" = 1'-0"

MASTER DRAWING

SHEET NO. 6

Four Star Mushroom - Chicago

CAPTIVE NY ENGINEERS
Chicago Mechanical Office
3777 Flinn Rd., Ste. 27, Downers Grove, IL 60551 PHONE: (630) 755-5800 FAX: (630) 755-5801 EMAIL: info@captive-ny.com

REVISION SCHEDULE

NO. REV. / SUBMISSION DATE ISSUED BY

PERMIT SET 06/21/22 NYE

ISSUE DATE: 4/6/2022 5:19:23 PM

RENOVATION

FOUR STAR MUSHROOMS

DRAWN BY: NYE

QAQC:

APPROVED BY: NYE

PROJECT NUMBER: 2206

HOOD, MAKE-UP AIR UNIT & DOAS DETAILS (3 OF 3)

M7.3

PLUMBING SYMBOLS LIST	
— SAN —	SANITARY SEWER (UNDERFLOOR)
— SAN —	SANITARY SEWER (ABOVE FLOOR)
----	VENT PIPING
-----	COLD WATER PIPING
-----	HOT WATER PIPING
-----	HOT WATER RETURN PIPING
— G —	GAS PIPING
-----	EXISTING HOT WATER PIPING
-----	EXISTING COLD WATER PIPING
— ∅ —	P—TRAP
— ○ —	PIPE UP
— ∩ —	PIPE DROP
— ⊙ —	CLEANOUT
— ⊕ —	PLUGGED OUTLET/CLEANOUT
— ⊕ —	POINT OF CONNECTION
— ⊕ —	GAS VALVE

PLUMBING ABBREVIATIONS	
CO	CLEANOUT
CODP	CLEAN OUT DECK PLATE
CW	COLD WATER
HW	HOT WATER
HWR	HOT WATER RETURN
SAN	SANITARY
V	VENT
LAV	LAVATORY
WC	WATER CLOSET
TYP.	TYPICAL
DN	DOWN
FD	FLOOR DRAIN
BFP	BACK FLOW PREVENTER
HWHT-1	WATER HEATER
N.I.C.	NOT IN SCOPE
ET-1	EXPANSION TANK
HWCP-1	HOT WATER CIRCULATION PUMP

PLUMBING DRAWING LIST	
P0.1	PLUMBING NOTES, SYMBOLS, ABBREVIATIONS & SPECIFICATIONS
P1.0	PLUMBING SANITARY FLOOR PLAN
P1.1	PLUMBING WATER AND GAS FLOOR PLAN
P5.0	PLUMBING DETAILS
P6.0	PLUMBING RISERS & SCHEDULES

BUILDING DEPARTMENT PLUMBING NOTES

- ALL PLUMBING SYSTEMS (SANITARY, WASTE, VENT, WATER, STORM) AND ASSOCIATED EQUIPMENT SHALL BE INSTALLED, OPERATED AND MAINTAINED IN ACCORDANCE WITH THE REQUIREMENTS OF 2019 CHICAGO PLUMBING CODE.
- INSTALLATION OF UNDERGROUND PIPING SHALL BE IN ACCORDANCE WITH THE REQUIREMENTS OF SECTION PC 702.2
- PROTECTION OF PIPING AND PLUMBING SYSTEM COMPONENTS AS PER SECTION PC 305.
- TRENCHING, EXCAVATION AND BACKFILL AS PER SECTION PC 306.
- RODENT PROOFING AS PER PC 304
- MATERIALS USED IN PLUMBING SYSTEMS SHALL BE IN ACCORDANCE WITH THE REQUIREMENTS OF SECTION PC 303, PC 605, PC 702, PC 902,PC 1102.
- EQUIPMENT CONNECTIONS AND JOINING OF PIPING SHALL BE IN ACCORDANCE WITH THE REQUIREMENTS OF CHAPTERS 4, 5, 6, 7 AND 9.
- DEEP SEAL TRAPS FOR FLOOR DRAINS SHALL BE PROVIDED AS PER PC 1002, AND CLEAN-OUTS SHALL BE INSTALLED IN ACCORDANCE WITH THE REQUIREMENTS OF SECTION PC 708
- DRAINAGE PIPE CLEANOUTS AS PER SECTION PC 708.
- VERTICAL AND HORIZONTAL PIPING SHALL BE SUPPORTED IN ACCORDANCE WITH THE REQUIREMENTS OF SECTION PC 308
- WATER SUPPLY SYSTEMS SHALL BE INSTALLED AND MAINTAINED IN ACCORDANCE WITH THE REQUIREMENTS OF CHAPTER 6 SECTION PC 601-603, 604, 606, 607, 608, 610
- THE SANITARY DRAINAGE SYSTEM SHALL BE SIZED AND INSTALLED IN ACCORDANCE WITH THE REQUIREMENTS OF CHAPTER 7 SECTION PC 701, 704, 705, 706, 707, 708, 711.
- VENT PIPING FOR THE SANITARY DRAINAGE SYSTEM SHALL BE INSTALLED IN ACCORDANCE WITH THE REQUIREMENTS OF CHAPTER 9 SECTIONS PC 901 THROUGH PC 912 THROUGH PC 917
- INSPECTION AND TESTING OF PLUMBING SYSTEMS SHALL BE IN ACCORDANCE WITH SECTION PC 107.
- GAS PIPING INSTALLATION SHALL IN IN ACCORDANCE WITH INTERNATIONAL FUEL GAS CODE CHAPTER 4.

PLUMBING SPECIFICATIONS:

1. BASIC PLUMBING REQUIREMENTS, MATERIALS AND METHODS

1.01 SCOPE

A. PROVIDE ALL MATERIAL, TOOLS, SUPERVISION AND LABOR INCLUDING ALL MISCELLANEOUS AND INCIDENTAL ITEMS REQUIRED FOR COMPLETE AND OPERABLE PLUMBING INSTALLATIONS AS SHOWN OR DESCRIBED ON THE DRAWINGS AND IN THESE SPECIFICATIONS.

B. THE CONTRACTOR SHALL BE RESPONSIBLE FOR THE PROTECTION OF ALL EXISTING AND NEW CONDITIONS AND MATERIALS WITHIN THE CONSTRUCTION AREA. ANY DAMAGE CAUSED BY THE CONTRACTOR SHALL BE REPAIRED TO THE OWNER'S SATISFACTION.

C. OBTAIN ALL PERMITS, PAY ALL PERMIT FEES AND SCHEDULE ALL REQUIRED INSPECTIONS. COPIES OF ALL PERMITS AND INSPECTION CERTIFICATES SHALL BE FORWARDED TO THE OWNER FOR RECORD.

D. THE GENERAL CONDITIONS OF THE CONTRACT AND ALL DIVISION 1 REQUIREMENTS APPLY TO THE WORK OF THIS SECTION.

E. THE CONTRACTOR SHALL VISIT THE SITE PRIOR TO SUBMITTING BID TO DETERMINE CONDITIONS AND THE EXTENT OF THE WORK. BY COMMENCING WORK, THE CONTRACTOR ACKNOWLEDGES HIS CONFIRMATION OF ALL CONDITIONS AS ACCEPTABLE WITH REFERENCE TO HIS CONTRACT, SCOPE OF WORK AND BID PRICE SUCH THAT NO ADDITIONAL COMPENSATION SHALL BE FORTHCOMING FOR UNFORESEEN EXISTING CONDITIONS.

F. IN ALL AREAS SUBJECT TO FREEZING CONDITIONS, THE CONTRACTOR SHALL PROVIDE FREEZE PROTECTION FOR ALL DOMESTIC WATER PIPING INSTALLED UNDER HIS CONTRACT.

G. ALL ELECTRICAL REQUIREMENTS SHALL BE COORDINATED WITH THE CONTRACTOR FOR ELECTRICAL WORK. THIS CONTRACTOR IS RESPONSIBLE FOR ALL LOW VOLTAGE WIRING FOR EQUIPMENT INSTALLED UNDER HIS CONTRACT. THE CONTRACTOR FOR ELECTRICAL WORK IS RESPONSIBLE FOR LINE VOLTAGE POWER WIRING ONLY.

H. COLOR AND FINISH SELECTIONS FOR ALL MATERIALS, INCLUDING PAINTING OF PIPING, SHALL BE AS DIRECTED AND/OR APPROVED BY THE ARCHITECT.

I. MINOR DETAILS NOT SHOWN OR SPECIFIED, BUT NECESSARY FOR THE PROPER AND ACCEPTABLE CONSTRUCTION, INSTALLATION OR OPERATION OF ANY PART OF THE WORK AS DETERMINED BY THE ENGINEER SHALL BE INCLUDED AS IF SPECIFIED OR INDICATED ON THE DRAWINGS.

J. THIS CONTRACTOR SHALL BE RESPONSIBLE FOR COORDINATING ALL REQUIREMENTS FOR THE INSTALLATION, CONNECTION, EXTENSION OR MODIFICATION TO ALL UTILITY SERVICES WITH RESPECTIVE PROVIDERS INCLUDING PAYMENT OF ALL ASSOCIATED FEES.

K. THE CONTRACTOR IS RESPONSIBLE FOR ALL PAINTING ASSOCIATED WITH CUTTING AND PATCHING. ALL PAINTING IN AREAS WITH COMPLETE FINISH RENOVATIONS SHALL BE PROVIDED BY THE GENERAL CONTRACTOR.

1.02 SUBMITTALS

A. SUBMITTAL REQUIREMENTS SHALL BE COORDINATED WITH THE ARCHITECT AND AUTHORITIES HAVING JURISDICTION. UNLESS OTHERWISE DIRECTED, CONTRACTOR SHALL PROVIDE SUBMITTALS AS LISTED BELOW.

- PIPE AND FITTINGS
- VALVES
- HANGERS AND SUPPORTS
- PLUMBING PIPING LAYOUT
- TESTS
- PLUMBING FIXTURES
- WATER HEATERS & ACCESSORIES
- MIXING VALVES
- ALL SCHEDULED PLUMBING EQUIPMENT

B. SUBMITTALS FROM SUPPLIERS OR MANUFACTURERS WHICH DO NOT BEAR THE STAMP OF THE SUBMITTING CONTRACTOR INDICATING THAT THE CONTRACTOR HAS REVIEWED THE SUBMITTAL FOR CONFORMANCE WITH THE PROJECT REQUIREMENTS WILL BE RETURNED REJECTED.

C. THE ENGINEER'S REVIEW OF SUBMITTALS IS A COURTESY WHICH DOES NOT RELIEVE THE CONTRACTOR FROM CONFORMING WITH THE CONSTRUCTION DOCUMENTS, REGARDLESS OF THE ACTION INDICATED BY THE SHOP DRAWINGS STAMP.

D. REVIEW OF SHOP DRAWINGS BY THE ENGINEER SHALL BE LIMITED TO THE INITIAL REVIEW, AND A SECOND REVIEW OF ANY REQUIRED RESUBMITTED DATA. IF THE ENGINEER IS REQUIRED TO REVIEW SHOP DRAWINGS FOR A THIRD (OR MORE) SUBMISSION OF THE SAME ITEM, THE CONTRACTOR SHALL BE LIABLE FOR COMPENSATING THE ENGINEER FOR THESE SUBSEQUENT REVIEWS AS PER THE ENGINEER'S CURRENT HOURLY RATE SCHEDULE.

E. SUBMIT PROOF OF APPROVAL AND/OR CONFIRMATION OF SATISFACTORY TEST RESULTS TO THE OWNER AND THE ARCHITECT.

F. SUBMIT TO THE OWNER'S MAINTENANCE PERSONNEL OPERATION AND MAINTENANCE DATA FOR ALL SYSTEM COMPONENTS, SERVICING REQUIREMENTS, INSPECTION DATA, REPLACEMENT PART NUMBERS AND AVAILABILITY AND CONTACT INFORMATION FOR SERVICE/SUPPLY COMPANY.

G. FOR ALL BELOW GRADE PIPING WHERE ACTUAL INSTALLATION DEVIATES FROM CONSTRUCTION DRAWINGS, THE CONTRACTOR SHALL PROVIDE AS-BUILT DRAWINGS INDICATING BELOW GRADE PIPE LOCATIONS DIMENSIONED TO NEAREST COLUMN LINES.

H. RECORD AS-BUILT DRAWINGS SHALL BE SUPPLIED TO THE OWNER/TENANT AFTER COMPLETION OF THE WORK SHOWING ANY ALTERATIONS, ADDITIONS AND/OR DELETIONS TO THE SYSTEM(S) INSTALLED.

1.03 SUBSTITUTIONS

A. ALL EQUIPMENT SHALL BE PRODUCTS OF THE SPECIFIED MANUFACTURER OR MANUFACTURERS. ALL BIDS SHALL BE BASED ON THE SPECIFIED MANUFACTURER OR MANUFACTURER'S EQUIPMENT. FOR SUBSTITUTIONS OF OTHER MANUFACTURER'S EQUIPMENT TO BE CONSIDERED, THE SUBSTITUTION MUST BE INDICATED PRIOR TO BIDDING WITH THE REASON FOR THE PROPOSED SUBSTITUTION IDENTIFIED, AND THE PROPOSED CREDIT TO THE OWNER INDICATED. THE ENGINEER SHALL DETERMINE THE ACCEPTABILITY OF ANY PROPOSED SUBSTITUTIONS.

B. THE CONTRACTOR ASSUMES ALL RESPONSIBILITY FOR COORDINATING THE WORK OF OTHER TRADES WHICH MAY BE AFFECTED BY SUBSTITUTIONS, INCLUDING ALL RELATED COSTS.

1.05 DEFINITIONS

A. FURNISH: TO PURCHASE, PROCURE, ACQUIRE AND DELIVER, COMPLETE WITH RELATED ACCESSORIES.

B. INSTALL: TO ERCT, MOUNT AND CONNECT, COMPLETE WITH RELATED ACCESSORIES.

C. PROVIDE: TO FURNISH AND INSTALL.

D. PLUMBING CONTRACTOR, THE CONTRACTOR, THIS CONTRACTOR: THE CONTRACTOR FOR PLUMBING WORK WHICH IS SPECIFIED HEREIN AND SHOWN ON THESE DRAWINGS.

1.06 DRAWINGS

A. THE DRAWINGS ARE DIAGRAMMATIC AND ARE INTENDED TO ILLUSTRATE THE GENERAL ARRANGEMENT AND ROUTING OF PIPING AND GENERAL LOCATIONS OF EQUIPMENT. PRECISE LOCATIONS OF EQUIPMENT, RISERS AND STACKS, AND ROUTING AND ELEVATION OF ALL PIPING SYSTEMS SHALL BE COORDINATED IN THE FIELD WITH THE ARCHITECT, ARCHITECTURAL DRAWINGS, THE WORK OF OTHER TRADES, EXISTING AND NEW BUILDING CONDITIONS AND/OR THE PREFERENCES OF THE OWNER/TENANT AS CONSTRUCTION PROCEEDS. ALL PIPING SHALL BE INSTALLED CONCEALED IN FINISHED SPACES, UNLESS NOTED OTHERWISE.

B. PROVIDE ALL NECESSARY INCIDENTAL MATERIALS AND ACCESSORIES REQUIRED TO MAKE THE WORK COMPLETE IN ALL RESPECTS, EVEN IF NOT PARTICULARLY SHOWN OR SPECIFIED.

C. REFER TO PLUMBING EQUIPMENT/FIXTURE SCHEDULE ON THE DRAWINGS FOR ALL FIXTURE AND EQUIPMENT SPECIFICATIONS.

D. REFER TO FIXTURE CONNECTION SIZE SCHEDULE FOR ALL FIXTURE ROUGHING SIZE REQUIREMENTS.

E. VERIFY ALL INDICATED CONDITIONS BEFORE STARTING WORK AND REPORT ANY DISCREPANCIES. THE DRAWINGS REFLECT CONDITIONS WHICH CAN BE REASONABLY INTERPRETED FROM THE EXISTING VISIBLE CONDITIONS OR FROM DRAWINGS AND INFORMATION FURNISHED BY THE OWNER.

F. LOCATE ALL FIXTURES AND EQUIPMENT AS PER THE FINAL ARCHITECTURAL DRAWINGS.

1.07 PRODUCTS

A. SANITARY AND VENT PIPING:

1. ABOVE GRADE PIPING SHALL BE CAST IRON PIPE WITH STAINLESS STEEL COUPLINGS AND ELASTOMERIC GASKETS WITH A MINIMUM 4 BANDS PER COUPLING.

2. SLOPE OF DRAINAGE SYSTEM SHALL BE 1/8" PER FOOT OF RUN FOR PIPE OVER 3" (I.D.) AND 1/4" PER FOOT OF RUN FOR PIPE 3" AND SMALLER (I.D.). VENT PIPING SHALL BE PITCHED TO DRAIN.

3. PVC OR OTHER COMBUSTIBLE PLASTIC PIPING SHALL NOT BE INSTALLED IN CEILING PLENUM SPACES.

4. ALL CAST IRON SOIL PIPE AND FITTINGS SHALL BE MARKED WITH THE COLLECTIVE TRADEMARK OF THE CAST IRON SOIL PIPE INSTITUTE (CISPI) AND BE LISTED BY NSF INTERNATIONAL.

B. DOMESTIC WATER PIPING:

1. ABOVE GRADE WATER PIPING SHALL BE TYPE 'L' HARD-DRAWN COPPER TUBE.

2. FITTINGS IN DOMESTIC WATER PIPING SHALL BE WROUGHT COPPER OR CAST BRASS.

3. JOINTS SHALL BE MADE WITH LEAD—FREE SOLDER.

4. THE ENTIRE DOMESTIC WATER DISTRIBUTION SYSTEM SHALL BE INSULATED INCLUDING ALL VALVES, FITTINGS, ETC.

5. COMPLY WITH NSF 61 FOR MATERIALS FOR WATER—SERVICE PIPING AND SPECIALTIES FOR DOMESTIC WATER.

6. ALL DOMESTIC WATER PIPING ABOVE GRADE SHALL BE INSULATED WITH FIRE—RETARDANT, FACTORY—APPLIED JACKET. PROVIDE COLD WATER PIPING WITH FACTORY—APPLIED VAPOR BARRIER. INSULATION REQUIREMENT SHOULD COMPLY WITH 2019 CHICAGO ENERGY CONSERVATION CODE 14N SECTION C403.11.3 REFER BELOW TABLE.

MINIMUM PIPE INSULATION THICKNESS		FLUID OPERATING TEMPERATURE RANGE AND USAGE (°F)		INSULATION CONDUCTIVITY BTU·IN./ (H·FT²·°F)		NOMINAL PIPE OR TUBE SIZE (INCHES)	
				CONDUCTIVITY	MEAN RATING TEMPERATURE, °F	<1	1 to < 1½
141–200	0.25–0.29	125	1.5	1.5	2	2	2
105–140	0.21–0.28	100	1.0	1.0	1.5	1.5	1.5
40–60	0.21–0.27	75	0.5	0.5	1.0	1.0	1.0

7. WATER DISTRIBUTION SYSTEM AS PER 2019 CHICAGO ENERGY CONSERVATION CODE 14N C404.7, HAVING ONE OR MORE RECIRCULATION PUMPS THAT PUMP WATER FROM A HEATED—WATER SUPPLY PIPE BACK TO THE HEATED—WATER SOURCE THROUGH A COLD—WATER SUPPLY PIPE SHALL BE A DEMAND RECIRCULATION WATER SYSTEM. PUMPS SHALL HAVE CONTROLS THAT COMPLY WITH BOTH OF THE FOLLOWING:

- THE CONTROL SHALL START THE PUMP UPON RECEIVING A SIGNAL FROM THE ACTION OF A USER OF A FIXTURE OR APPLIANCE, SENSING THE PRESENCE OF A USER OF A FIXTURE OR SENSING THE FLOW OF HOT OR TEMPERED WATER TO A FIXTURE FITTING OR APPLIANCE.
- THE CONTROL SHALL LIMIT THE TEMPERATURE OF THE WATER ENTERING THE COLD—WATER PIPING TO 104°F (40°C).

8. AS PER 2019 CHICAGO ENERGY CONSERVATION CODE 14N C404.6.1 HEATED—WATER CIRCULATION SYSTEMS SHALL BE PROVIDED WITH A CIRCULATION PUMP. THE SYSTEM RETURN PIPE SHALL BE A DEDICATED RETURN PIPE OR A COLD WATER SUPPLY PIPE. CONTROLS FOR CIRCULATING HOT WATER SYSTEM PUMPS SHALL START THE PUMP BASED ON THE IDENTIFICATION OF A DEMAND FOR HOT WATER WITHIN THE OCCUPANCY. THE CONTROLS SHALL AUTOMATICALLY TURN OFF THE PUMP WHEN THE WATER IN THE CIRCULATION LOOP IS AT THE DESIRED TEMPERATURE AND WHEN THERE IS NO DEMAND FOR HOT WATER.

9. HW SYSTEM PIPING IS DESIGNED AS PER MAXIMUM ALLOWED PIPE LENGTH METHOD AS PER 2019 CHICAGO ENERGY CONSERVATION CODE 14N C404.5.1. THE HW PIPE LENGTH FROM THE NEAREST SOURCE OF HEATED WATER TO THE TERMINATION OF THE FIXTURE SUPPLY PIPE SHALL BE AS PER FOLLOWING TABLE.

NOMINAL PIPE SIZE (INCHES)	MAXIMUM PIPING LENGTH (FEET)	
	PUBLIC LAV	OTHER FIXTURES
½"	2'	43'
¾"	0.5'	21'
1"	0.5'	13'
1¼"	0.5'	8'
1½"	0.5'	6'
2" OR LARGER	0.5'	4'

10. SEAL ALL JOINTS BETWEEN SEGMENTS OF INSULATION.

11. PROVIDE SHIELDS BETWEEN HANGERS AND INSULATION.

C. GAS PIPING:

1. GAS PIPING SHALL BE SIZED IN ACCORDANCE WITH PIPE SIZING TABLES OR SIZING EQUATIONS IN ACCORDANCE WITH SECTION 402.3(2).

2. INDIVIDUAL OUTLETS TO GAS RANGES SHALL NOT BE LESS THAN ¾ INCHES NPS.

3. METALLIC PIPE SHALL COMPLY WITH SECTIONS 403.4.1 THROUGH 403.4.4.

4. PIPING SYSTEM INSTALLATION SHALL COMPLY WITH REQUIREMENTS OF IFGC SECTION 404.

5. AS PER INTERNATIONAL FUEL GAS CODE, SECTION 404.4, UNDERGROUND PIPING, WHERE INSTALLED BELOW GRADE THROUGH THE OUTER FOUNDATION OR BASEMENT WALL OF A BUILDING, SHALL BE ENCASED IN A PROTECTIVE PIPE SLEEVE. THE ANNULAR SPACE BETWEEN THE GAS PIPING AND THE SLEEVE SHALL BE SEALED.

6. PIPING INSTALLED UNDERGROUND BENEATH BUILDINGS IS PROHIBITED EXCEPT WHERE THE PIPING IS ENCASED IN A CONDUIT OF WROUGHT IRON OR STEEL PIPE DESIGNED TO WITHSTAND THE SUPERIMPOSED LOADS. THE CONDUIT SHALL BE PROTECTED FROM CORROSION IN ACCORDANCE WITH SECTION 404.11 AND SHALL BE INSTALLED IN ACCORDANCE WITH SECTION 404.11.1 OR 404.11.2 OF INTERNATIONAL FUEL GAS CODE.

7. AS PER INTERNATIONAL FUEL GAS CODE SECTION 404.9, UNDERGROUND PIPING SYSTEMS SHALL BE INSTALLED A MINIMUM DEPTH OF 12 INCHES BELOW GRADE.

8. THE GAS PIPING IS ENCASED IN A CONDUIT OF WROUGHT IRON OR STEEL PIPE TO WITH STAND THE SUPERIMPOSED LOADS.

9. SHUTOFF VALVES SHALL BE LOCATED IN PLACES SO AS TO PROVIDE ACCESS FOR OPERATION AND SHALL BE INSTALLED SO AS TO BE PROTECTED FROM DAMAGE.

D. HANGERS AND SUPPORTS:

1. HANGERS SHALL BE STANDARD STEEL, MALLEABLE OR WROUGHT IRON, AS MANUFACTURED BY GRINNELL OR APPROVED EQUAL, SUITABLE FOR THE TYPE OF CONSTRUCTION. PIPING SHALL NOT BE HUNG FROM OTHER PIPE.

2. SECTIONS OF INDIVIDUAL PIPE RUNS SHALL BE SUPPORTED BY CLEVIS HANGERS.

3. ALL EQUIPMENT SHALL BE PROVIDED WITH APPROVED SUPPORTS.

4. PROVIDE SEISMIC RESTRAINTS IN ACCORDANCE WITH ALL APPLICABLE FEDERAL, STATE AND LOCAL CODES AND STANDARDS AND THE REQUIREMENTS OF AUTHORITIES HAVING JURISDICTION.

5. SUPPORTS SHALL BE PROVIDED IN STRICT ACCORDANCE WITH THE RECOMMENDATIONS OF THE PIPING MANUFACTURER.

E. VALVES:

1. PROVIDE GATE VALVES, BUTTERFLY OR BALL VALVES FOR SHUT—OFF DUTY ON MAIN AND BRANCH SUPPLY LINES. FOR ALL PIPE RUNS 2" AND SMALLER, PROVIDE BALL FOR ALL PIPE RUNS LARGER THAN 2" AND SMALLER THAN 4", PROVIDE GATE VALVES. PIPING 4" AND LARGER, PROVIDE BUTTERFLY VALVES FOR SHUT—OFF DUTY.

2. ALL FIXTURES WITH THE EXCEPTION OF FLUSHOMETER—EQUIPPED WATER CLOSETS AND URINALS SHALL HAVE STOP VALVES TO CONTROL SUPPLY TO THE FIXTURE. WHERE SUPPLIES ARE EXPOSED PROVIDE CHROME—PLATED STOPS WITH CHROME—PLATED ESCUTCHEONS ON PIPING PENETRATIONS.

3. ALL PLUMBING FIXTURES AND EQUIPMENT TO HAVE SHUT—OFF VALVES ON SUPPLY LINES.

4. ALL BRANCH LINES TO HAVE SHUT—OFF VALVES.

5. ALL VALVES SHALL BE ACCESSIBLE. PROVIDE ACCESS DOORS WHERE REQUIRED FOR VALVE ACCESS.

6. PROVIDE GLOBE VALVES FOR THROTTLING/BALANCING OF THE HOT WATER CIRCULATING SYSTEM.

F. INSTALL PIPING TO CONSERVE BUILDING SPACE. DO NOT INTERFERE WITH USE OF BUILDING SPACE AND THE WORK OF OTHER TRADES. ALL PIPING RUN IN CEILING SHALL BE INSTALLED TIGHT TO THE STRUCTURE ABOVE.

G. INSTALL PIPING TO ALLOW FOR EXPANSION AND CONTRACTION WITHOUT STRESSING PIPE, JOINTS OR CONNECTED EQUIPMENT. PROVIDE PIPE ANCHORS, GUIDES AND EXPANSION JOINTS OR LOOPS IN ALL HOT WATER AND HOT WATER CIRCULATING MAIN SUPPLY PIPING AND SEGMENTS OF SUCH PIPE THAT EXCEED 30'—0" IN LENGTH.

H. IN ALL AREAS WITH FINISHED SURFACES, SYSTEM PIPING AND COMPONENTS SHALL BE CONCEALED ABOVE OR WITHIN FINISHED SURFACES.

I. REDUCTIONS IN PIPE SIZES SHALL BE MADE WITH ONE—PIECE REDUCING FITTINGS. BUSHINGS ARE NOT ACCEPTABLE. USE FLANGED FITTINGS AT THE BASE OF RISERS.

J. VENT PENETRATIONS THROUGH THE ROOF SHALL BE FLASHED.

K. IF WATER PRESSURE EXCEEDS 80 PSI, A WATER PRESSURE REDUCING VALVE SHALL BE INSTALLED IN WATER PIPING AT CONNECTION TO MAIN.

L. PIPE BACKFLOW PREVENTER DRAINS TO FLOOR DRAIN OR OTHER APPROVED INDIRECT WASTE SOURCE.

M. PROVIDE ACCESS DOORS/PANELS FOR SERVICE AND ACCESS TO ALL VALVES AND OTHER SYSTEM COMPONENTS ENCLOSED IN WALLS AND CEILINGS. ACCESS DOORS SHALL BE FURNISHED BY THIS CONTRACTOR, INSTALLED BY THE GENERAL CONTRACTOR.

N. ALL FIXTURES REQUIRING VACUUM BREAKERS SHALL BE EQUIPPED WITH INTEGRAL VACUUM BREAKERS.

O. ANY PENETRATIONS THROUGH FIRE RATED PARTITIONS, FLOORS OR CEILINGS SHALL BE STEEL SLEEVED AND SEALED WITH 3M BRAND UL RATED FIRE BARRIER CAULK OR APPROVED EQUAL.

P. WHEN THE WATER PIPING SYSTEM IS COMPLETE, THOROUGHLY FLUSH ALL DIRT, SEDIMENT, SOLDER, ETC., OUT OF THE SYSTEM, REMOVING ALL STRAINERS, VALVE STEM SEATS, ETC., REQUIRED TO ACCOMPLISH THE FLUSHING.

Q. AT ALL INDIRECT WASTE DRAINS, MAINTAIN AIR GAP AS REQUIRED BY CODE.

INSTALL SLEEVES FOR ALL PIPES WHICH PASS THROUGH WALLS, FLOORS, AND CEILINGS. WHERE PIPES ARE TO BE INSULATED, THE SLEEVE SHALL BE LARGE ENOUGH TO ACCOMMODATE INSULATION. SLEEVES SHALL BE FLUSH WITH FINISHED SURFACES AT BOTH ENDS. ON FINISHED SURFACES IN EXPOSED AREAS PROVIDE ESCUTCHEONS COMPATIBLE WITH FINISH.

2. INSTALLATION

2.01 GENERAL

R. ALL WORK WHICH REQUIRES DISRUPTION OF THE ROOFING SHALL BE DONE BY A CONTRACTOR CERTIFIED BY THE ROOFING MANUFACTURER AS REQUIRED TO MAINTAIN ANY EXISTING ROOF WARRANTIES.

S. EXTERIOR INSTALLATIONS TO BE WEATHER PROOF IN ALL RESPECTS.

T. EXTERIOR MATERIALS AND EQUIPMENT SHALL BE PAINTED TO PREVENT CORROSION, COLOR PER ARCHITECT.

U. COORDINATE THE PLUMBING WORK WITH ALL OTHER AFFECTED WORK AND THE CONSTRUCTION SCHEDULE.

V. REAM PIPE AND TUBE ENDS. REMOVE BURRS. BEVEL PLAIN AND FERROUS END PIPE.

W. REMOVE SCALE AND FOREIGN MATERIAL, FROM INSIDE AND OUTSIDE, BEFORE ASSEMBLY.

X. PREPARE PIPING CONNECTIONS TO EQUIPMENT WITH FLANGES AND UNIONS.

Y. COORDINATION WITH THE WORK OF OTHER TRADES IS REQUIRED. PROVIDE OFFSETS IN PIPING SYSTEMS OR MINOR DEVIATIONS TO THE INDICATED PIPE ROUTING IN ORDER TO COORDINATE THE PLUMBING WORK WITH THE WORK OF ALL OTHER TRADES AND THE GENERAL BUILDING CONDITIONS.

Z. NO DOMESTIC WATER PIPING SHALL BE INSTALLED IN UNHEATED SPACES.

AA. PRIOR TO DISCONNECTING AND CONNECTING NEW WORK TO EXISTING SYSTEMS, THE PLUMBING CONTRACTOR SHALL NOTIFY THE PROPERTY MANAGER AND OFFER A PROPOSED SCHEDULE OF WORK. ESB WILL AUTHORIZE CONNECTIONS AND COORDINATE NECESSARY SHUT DOWNS AND DRAIN DOWNS AS REQUIRED. SHUT DOWNS AND DRAIN DOWNS MAY BE PERFORMED BY THE PLUMBING CONTRACTOR ONLY AFTER RECEIVING AUTHORIZATION, AND SHOULD BE PERFORMED UNDER SUPERVISION OF ESB PERSONNEL. THREE (3) DAYS ADVANCE NOTICE TO THE PROPERTY MANAGER IS REQUIRED.

AB. THE PLUMBING CONTRACTOR IS ADVISED THAT DUE TO THE NATURE OF THE OPERATIONS AND TENANT REQUIREMENTS, CONNECTIONS TO EXISTING SYSTEMS MAY HAVE TO BE MADE AFTER REGULAR WORKING HOURS. THE PROPERTY MANAGER WILL ADVISE THE PLUMBING CONTRACTOR OF THE TIME CONSTRAINTS UPON RECEIPT AND APPROVAL OF THE PLUMBING CONTRACTOR'S REQUEST FOR SHUT DOWN AND CONNECTION TO EXISTING SYSTEMS.

AC. WHEN CONNECTING TO EXISTING STACKS AND RISERS, PROVISION IS TO BE MADE FOR FUTURE CONNECTIONS BY PROVIDING CAPPED AND VALVED OUTLETS ON DOMESTIC WATER RISERS AND PLUGGED OUTLETS ON THE SANITARY AND VENT STACKS.

2.02 ABOVE GRADE

A. INSTALL PLUMBING PIPING IN ACCORDANCE WITH RECOGNIZED INDUSTRY PRACTICES TO ENSURE THAT PIPING COMPLIES WITH REQUIREMENTS AND SERVES INTENDED PURPOSES.

B. ROUTE PIPING IN AN ORDERLY MANNER, PLUMB AND PARALLEL TO BUILDING STRUCTURE. MAINTAIN GRADIENT, SLOPE PIPING AND ARRANGE SYSTEMS TO DRAIN. IN DOMESTIC WATER SYSTEMS, PROVIDE DRAIN VALVES AT MAIN SHUT—OFF VALVES AND ALL LOW POINTS IN PIPING.

C. USE EXISTING CONNECTIONS AT MAINS WHERE AVAILABLE FOR NEW BRANCH PIPING. LOCATE ALL RISERS AND PIPING BEFORE CONSTRUCTION COMMENCES AND TAKE CARE NOT TO DAMAGE SAME. ANY DAMAGE OCCURRING TO THE EXISTING PIPING WILL BE THE SOLE RESPONSIBILITY OF THE CONTRACTOR.

3. TESTING

A. AT THE COMPLETION OF THE PLUMBING WORK, COMPLETELY TEST THE ENTIRE INSTALLATION OF ALL SYSTEMS FOR PROPER OPERATION AND COMPLIANCE WITH APPLICABLE CODES AND LOCAL REQUIREMENTS. CORRECT ALL DEFICIENCIES FOUND.

B. TESTING OF THE INSTALLED SYSTEMS SHALL BE MADE BY THE CONTRACTOR IN THE PRESENCE OF A REPRESENTATIVE OF THE OWNER.

C. THE CONTRACTOR SHALL NOT COVER UP OR PERMANENTLY CONCEAL PIPING, DEVICES OR ANY PORTION OF NEWLY CONSTRUCTED PLUMBING SYSTEM(S) UNTIL SUCH SYSTEM, OR PORTION OF THE SYSTEM, HAS BEEN TESTED IN THE PRESENCE OF A REPRESENTATIVE OF THE OWNER AND INSPECTED BY THE LOCAL INSPECTOR AND APPROVED IN WRITING, EXCEPT PIPING PASSING THROUGH FLOORS, WALLS, PARTITIONS, OR BEAMS, FOR DISTANCES EQUAL TO THE THICKNESS OF SUCH FLOOR, WALL, PARTITION OR BEAM.

D. THIS CONTRACTOR SHALL NOTIFY THE VARIOUS DEPARTMENTS, BUREAUS AND INDIVIDUALS AT LEAST TWO WEEKS IN ADVANCE OF THE TIME THAT THE TESTS ARE TO BE CONDUCTED.

E. ALL DEFECTIVE PARTS SHALL BE REPLACED OR CORRECTED BY THIS CONTRACTOR AND AN EXTRA TEST OR TESTS SHALL BE MADE UNTIL THE OPERATION IS SATISFACTORY. ALL ARRANGEMENTS AND EXPENSES NECESSARY TO CONDUCT ALL TESTS REQUIRED BY THESE SPECIFICATIONS AND THE VARIOUS AGENCIES HAVING JURISDICTION OVER THE WORK INSTALLED UNDER THIS CONTRACT SHALL BE MADE BY THIS CONTRACTOR. NO EXTRA COMPENSATION WILL BE ALLOWED FOR THESE TESTS, THE COST THEREOF BEING INCLUDED IN THE LUMP SUM BID FOR THIS CONTRACT.

F. WHERE ANY EVIDENCE OF STOPPAGE IS FOUND IN PIPING OR EQUIPMENT, THIS CONTRACTOR SHALL DISCONNECT, CLEAN, REPAIR AND RECONNECT ALL OBSTRUCTED PIPING OR EQUIPMENT AND SHALL ALSO PAY FOR ALL NECESSARY CUTTING AND REPAIRS TO ADJOINING WORK.

G. ALL PIPING AND EQUIPMENT SHALL BE THOROUGHLY CLEANED INSIDE AND OUT, OF DIRT, CUTTINGS, OILS AND OTHER FOREIGN SUBSTANCES AND SHALL BE LEFT CLEAN.

H. ALL REQUIRED TESTS SHALL BE WITNESSED BY LOCAL AUTHORITIES AND THE OWNER'S REPRESENTATIVE.

J. ALL EQUIPMENT WILL BE FACTORY TESTED.

I. CONTRACTOR SHALL IDENTIFY TO THE OWNER'S REPRESENTATIVE ANY LEAKS OR DAMAGE THAT OCCURS AS A RESULT OF SYSTEM TESTING. CONTRACTOR SHALL TAKE NECESSARY PRECAUTIONS TO LIMIT ANY POTENTIAL DAMAGE. CORRECTIVE ACTION REQUIRED AS A RESULT OF TESTING SHALL BE PERFORMED IMMEDIATELY AND AT THE CONTRACTOR'S EXPENSE.

K. REPORT IN WRITING TO AUTHORITIES HAVING JURISDICTION, THE ARCHITECT AND THE OWNER THE RESULTS OF ALL TESTING.

L. TESTING REQUIREMENTS


- TEST ALL DOMESTIC WATER PIPING HYDROSTATICALLY TO 125 PSIG.
- HYDROSTATIC TEST PRESSURES SHALL REMAIN CONSTANT WITH NO VARIATION FOR 120 MINUTES.
- TESTS SHALL BE WITNESSED BY THE BUILDING ENGINEER.
- THE PLUMBING CONTRACTOR WILL BE HELD RESPONSIBLE FOR ALL DAMAGE DUE TO TEST FAILURES AND LEAKAGE IN THE TEST AREA AND ADJACENT TENANT OR ESB SPACES.

M. REFILL ENTIRE POTABLE HOT AND COLD WATER SUPPLY SYSTEM WITH CHLORINE SOLUTION (HTH OLIN CHEMICAL CORP.) AT A STRENGTH TO MEET STANDARDS OF THE DEPARTMENT OF HEALTH, AND FOR A PERIOD OF RETENTION AS STIPULATED.

N. THOROUGHLY FLUSH PIPING SYSTEM WITH FRESH WATER IMMEDIATELY PRIOR TO FINAL ACCEPTANCE.

4. WARRANTY


A. EQUIPMENT, MATERIALS AND WORKMANSHIP FURNISHED UNDER THIS CONTRACT SHALL BE GUARANTEED BY THE CONTRACTOR FOR A PERIOD OF ONE

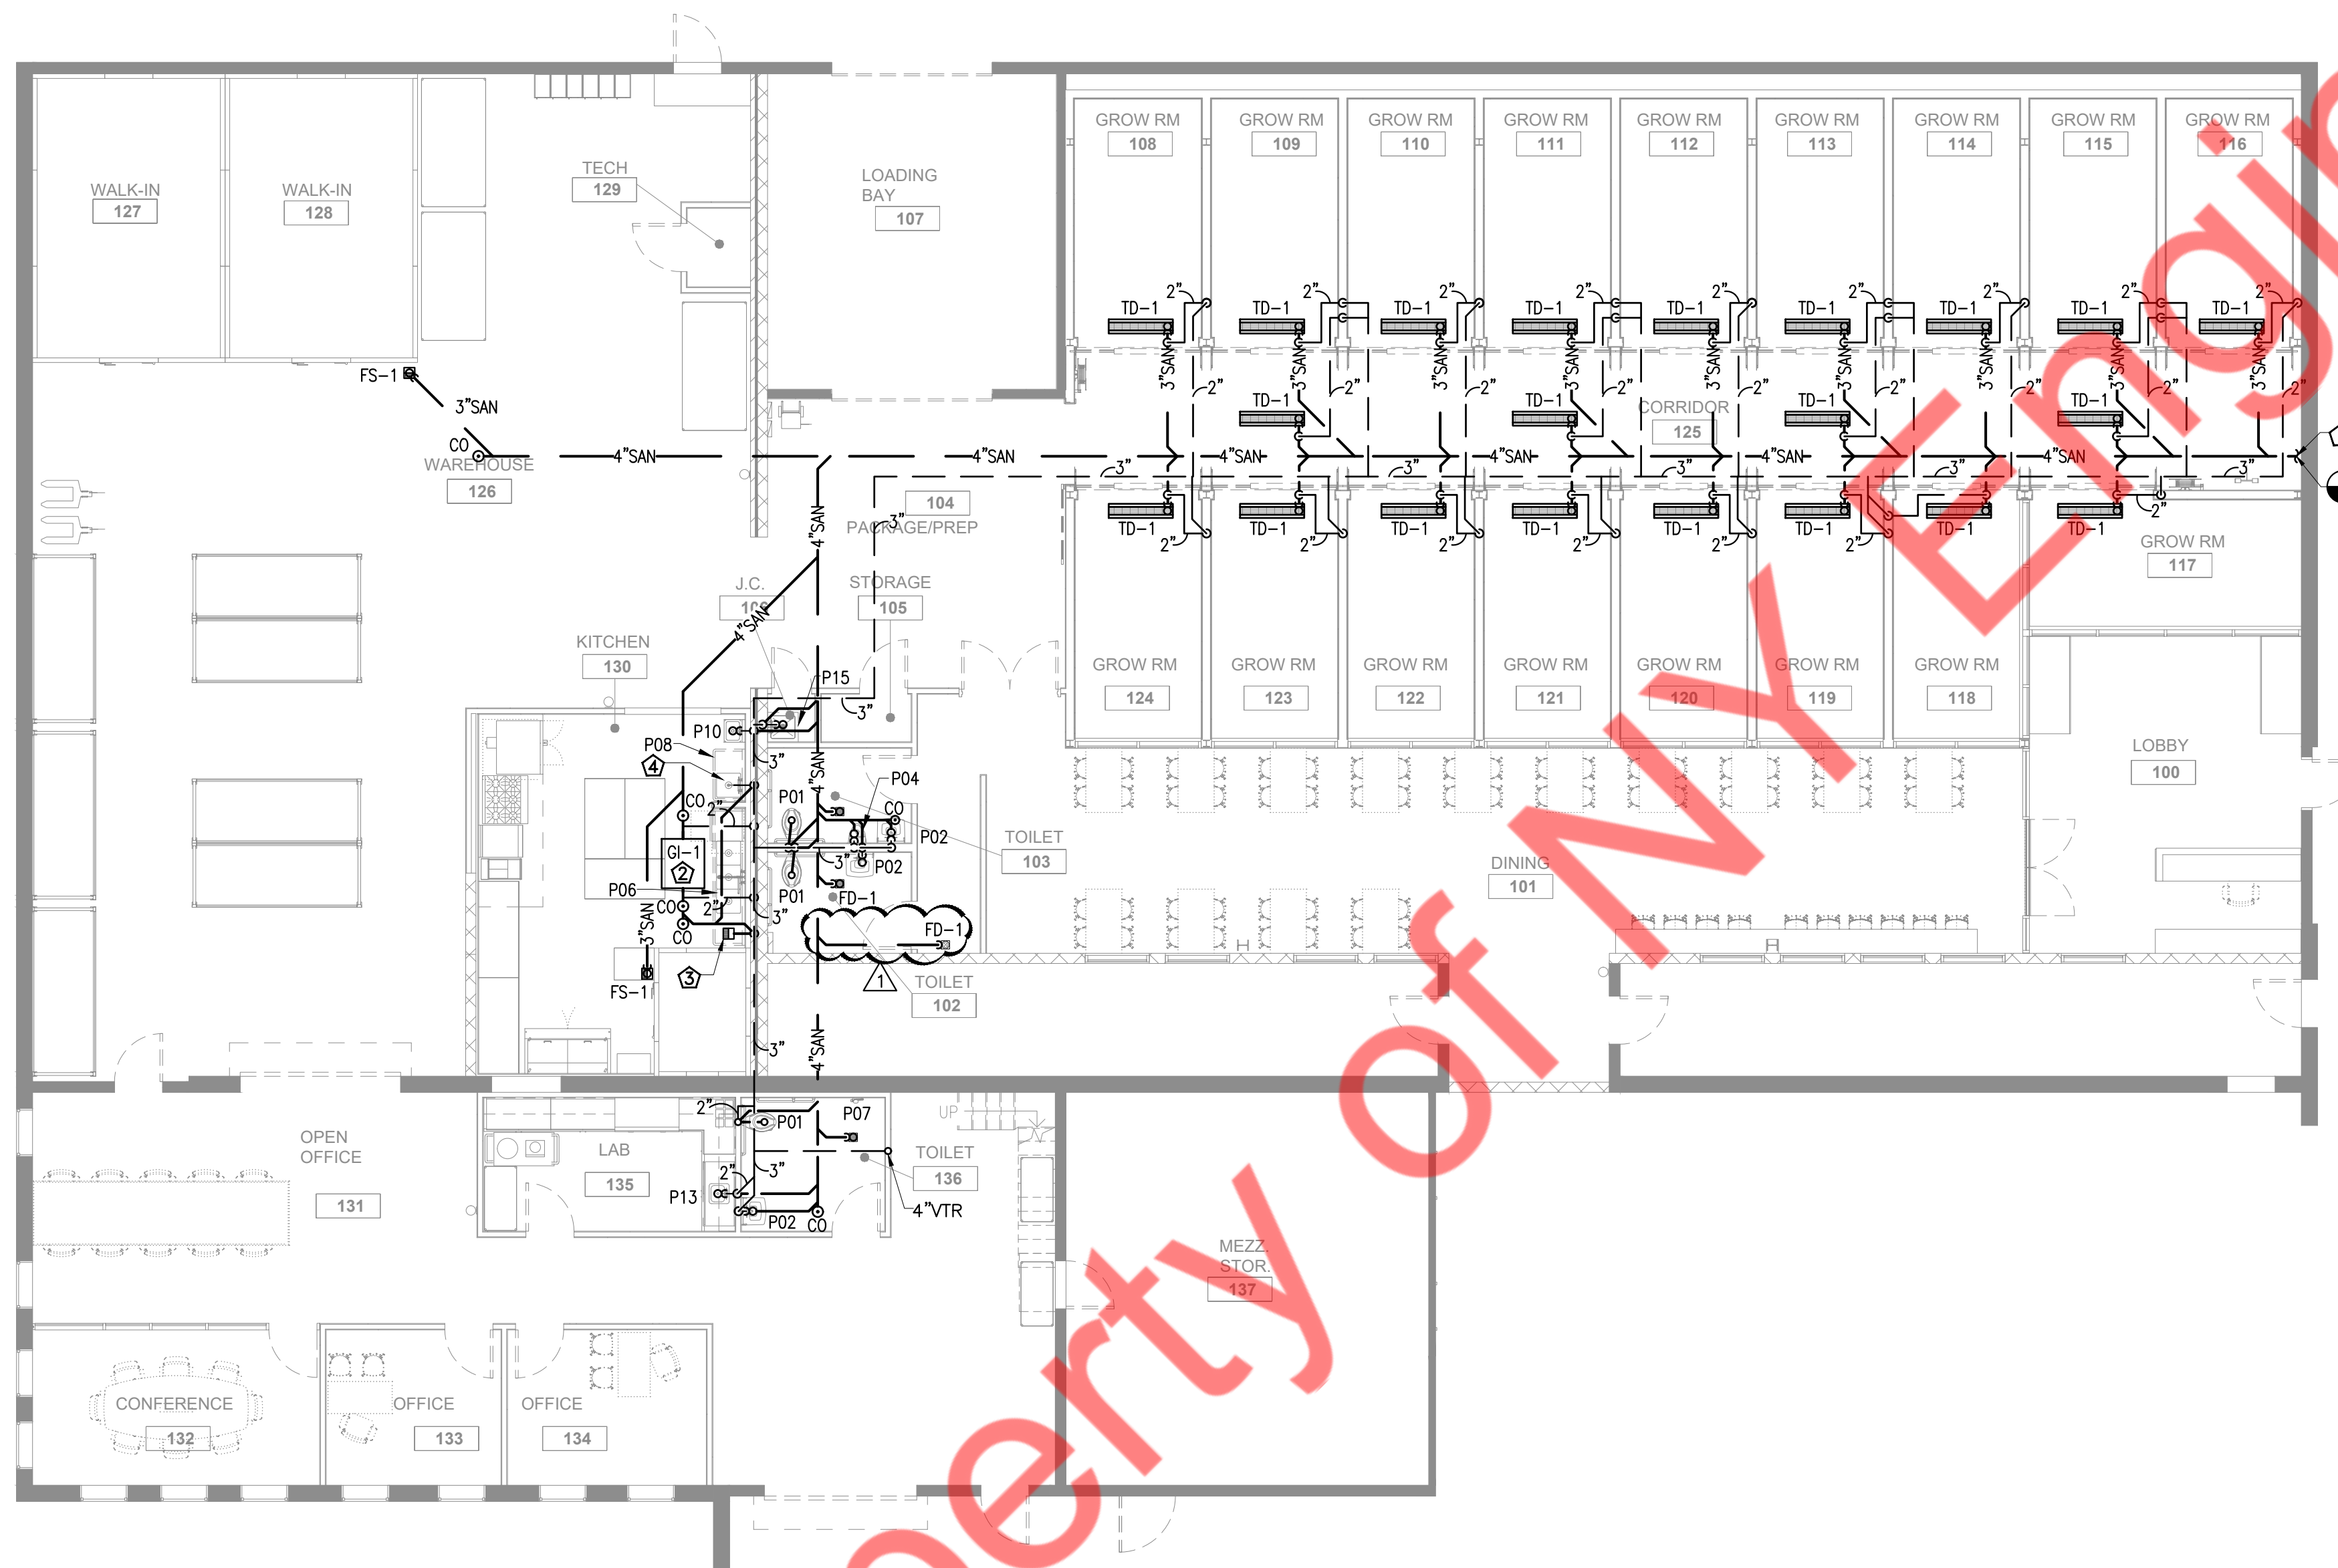

- GENERAL NOTES:
1. PROVIDE ACCESS PANELS FOR WATER HAMMER ARRESTOR, CLEANOUTS & SHUT-OFF VALVES AS REQUIRED.
 2. REFER RISER DIAGRAMS FOR ALL PIPE SIZES.
 3. WATER HEATER DRAIN SPILLS TO THE NEAREST MOP SINK.

- SANITARY KEYED NOTES:
- ① CONNECT NEW 4" SANITARY WASTE PIPING TO EXISTING SANITARY LINE. CONTRACTOR TO FIELD VERIFY SIZE, ROUTING AND INVERT ON SITE.
 - ② GI-1: GREASE INTERCEPTOR-SCHIER GB-50 GREASE TRAP FOR INDOOR INSTALLATION. FLOW RATE-50 GPM. INSTALL GREASE TRAP AS PER MANUFACTURER RECOMMENDATION.
 - ③ INDIRECT WASTE FROM 3 COMPARTMENT SINK TO FLOOR SINK WITH APPROVED AIR GAP.
 - ④ INDIRECT WASTE FROM 1 COMPARTMENT SINK TO FLOOR SINK WITH APPROVED AIR GAP.

1 PLUMBING SANITARY FLOOR PLAN
P1.0 SCALE: 1/8" = 1'-0"

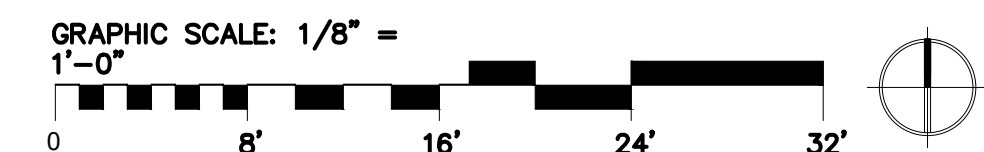

REVISION SCHEDULE			
NO.	REV.	SUBMISSION DATE	ISSUED BY
1		PERMIT SET	06/21/22 NYE

ISSUE DATE: 4/6/2022 5:19:23 PM

RENOVATION
FOUR STAR
MUSHROOMS

DRAWN BY: NYE
QAQC:
APPROVED BY: NYE
PROJECT NUMBER: 2206

PLUMBING SANITARY
FLOOR PLAN
P1.0



- GENERAL NOTES:
1. CW/HW PIPING TO BE PROVIDED WITH INSULATION AS PER CHICAGO ENERGY CONSERVATION CODE (REFER SHEET P0.1)
 2. PROVIDE BRANCH PRV IF PRESSURE EXCEEDS 85 PSI.
 3. CONTRACTOR TO FIELD VERIFY FEASIBILITY OF SLAB PENETRATION AS PER STRUCTURAL REQUIREMENT.
 4. PROVIDE ACCESS PANELS FOR WATER HAMMER ARRESTOR, CLEANOUTS & SHUT-OFF VALVES AS REQUIRED.
 5. REFER RISER DIAGRAMS FOR ALL PIPE SIZES.
 6. WATER HEATER DRAIN SPILLS TO THE NEAREST MOP SINK.

- DOMESTIC WATER AND GAS PLAN NOTES:
1. CONNECT NEW 2" CW TO EXISTING COLD WATER MAIN LINE. CONTRACTOR TO VERIFY IN FIELD THE BACKFLOW PREVENTER (RPZ) AND WATER METER. PROVIDE NEW BACKFLOW PREVENTER (RPZ) AND WATER METER IF NOT EXISTING. INSTALL IN-LINE OF EQUAL PIPE DIAMETER OF THE WATER SERVICE AND SHALL BE LOCATED NO MORE THAN FIVE FEET(5') ABOVE THE FLOOR. EXTEND NEW PIPING AS INDICATED. FIELD VERIFY EXACT SIZE AND LOCATION OF EXISTING MAIN INCOMING WATER LINE.
 2. PROVIDE A TEMPERING VALVE FOR LAVATORIES. POWER HYDROGUARD SERIES LFLM495, ASSE, 1070 OR EQUAL. SET TEMPERATURE TO A MAXIMUM OF 110°F.
 3. CONTRACTOR TO FIELD VERIFY EXISTING AVAILABLE GAS PRESSURE AND MAKE SURE TO PROVIDE ADEQUATE INLET PRESSURE REQUIRED FOR 6 BURNER, 2 BURNER, OVEN, FRYER, MUA-1, RTU(N)-1, RTU(N)-2, RTU(N)-3, DOAS-1, DOAS-2 & DOAS-3
 4. CONNECT NEW 4" GAS PIPING TO EXISTING GAS METER. CONTRACTOR TO VERIFY LOCATION, SIZE AND PRESSURE IN FIELD AND UPGRADE IF REQUIRED. CONTRACTOR TO FIELD VERIFY REQUIRED OF GAS BOOSTER PUMP AS PER AVAILABLE GAS PRESSURE AND BASE BID ACCORDINGLY.
 5. 1-1/2" AUTOMATIC GAS VALVE EXPOSED 6" BELOW CEILING HEIGHT. PROVIDED BY OWNER INSTALLED BY CONTRACTOR. INTERLOCK WITH HOOD SUPPRESSION SYSTEM. REDUCE FROM 2" AT INLET, AND INCREASE TO 2" AT OUTLET. PROVIDE 2" UNION ON INLET AND OUTLET.
 6. PROVIDE WATTS LF28BA VACUUM BREAKER ASSE 1001 (OR EQUAL) TO MOP FAUCET. INSTALLED AFTER THE CONTROL VALVE.
 7. NATURAL GAS DISTRIBUTION PIPING SHALL BE SCHEDULE 40 BLACK PIPE WITH 150# MALLEABLE IRON FITTINGS. GAS PIPING GREATER THEN 2" INSIDE DIAMETER OR CARRYING MORE THAN 5 POUNDS(P.S.G) SHALL BE SCHEDULE 40 BLACK PIPE WITH STANDARD WELD FITTINGS.

1 PLUMBING WATER AND GAS FLOOR PLAN
P1.1 SCALE: 1/8" = 1'-0"



REVISION SCHEDULE		
NO. REV.	SUBMISSION DATE	ISSUED BY
1	PERMIT SET	06/21/22 NYE



ISSUE DATE: 4/6/2022 5:19:23 PM

RENOVATION
FOUR STAR
MUSHROOMS

DRAWN BY: NYE
QAQC:
APPROVED BY: NYE
PROJECT NUMBER: 2206

PLUMBING WATER AND
GAS FLOOR PLAN



P1.1

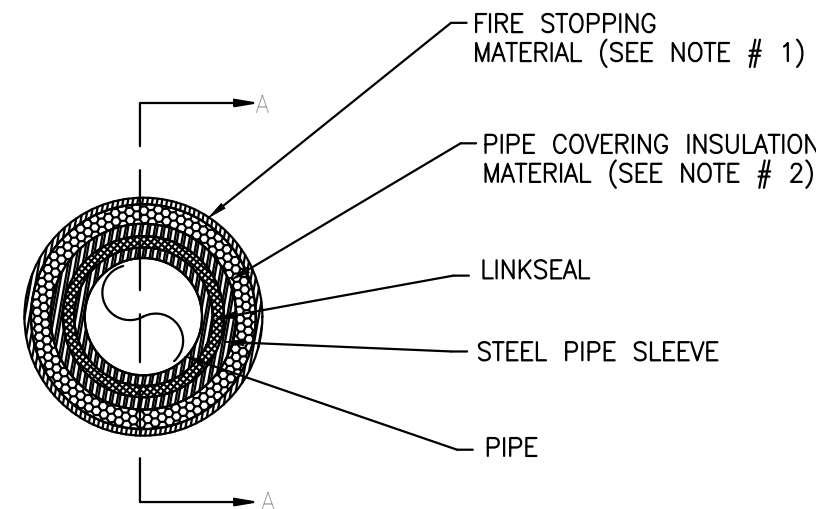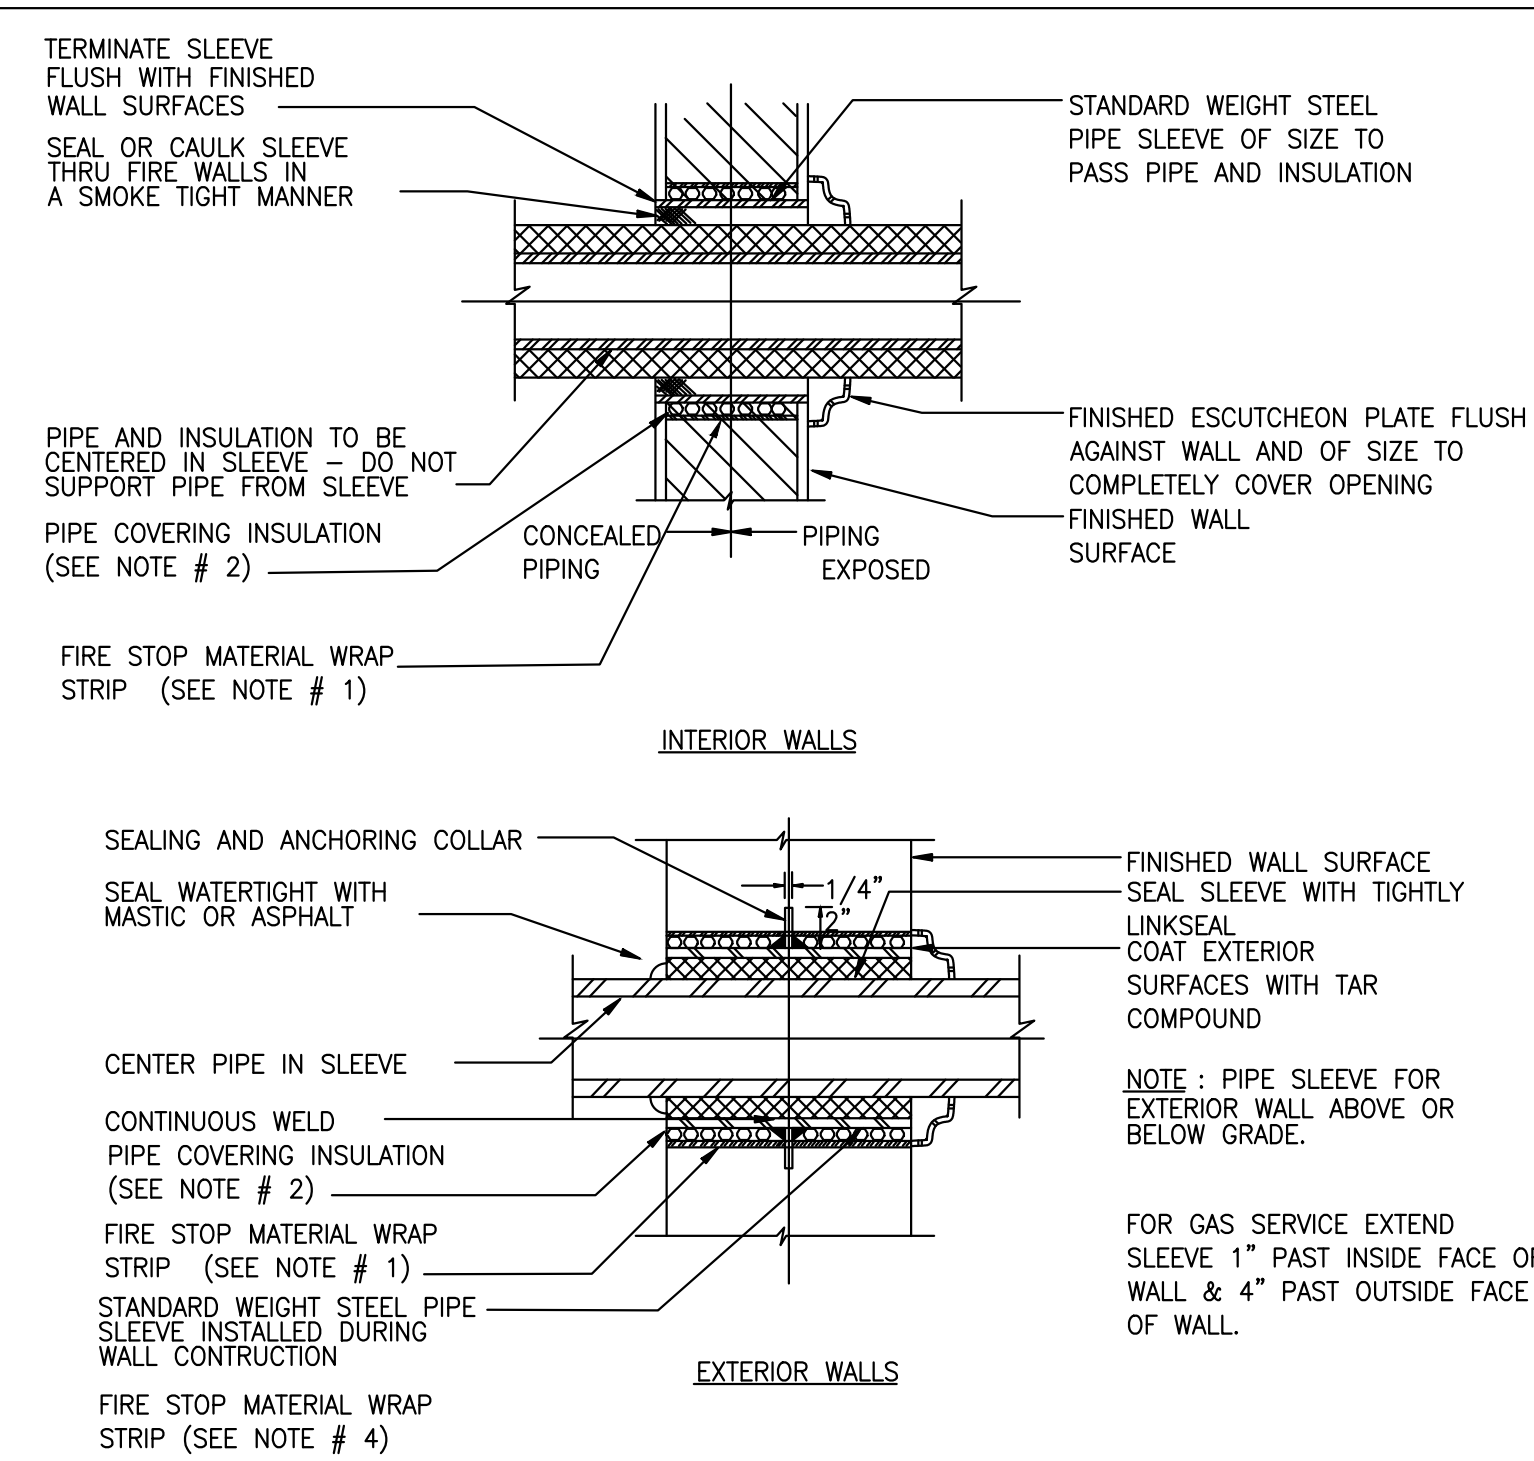

PIPE SLEEVE VIEW

NOTES:




- FIRESTOP MATERIAL WRAP STRIP SHALL BE 1/4" THICK INTUMESCENT ELASTOMERIC MATERIAL FACED ON ONE SIDE WITH ALUMINUM FOIL SUPPLIED IN 2 IN. WIDE STRIPS AND WRAP AROUND THE PIPE AS PER UL MATERIAL LISTED 3M COMPANY FS-195+ OR FILL CAVITY WITH CAULK OR SEALANT MIN. 1/4" DIA. CONTINUOUS BEAD APPLIED TO THE WRAP STRIP/WALL INTERFACE AND TO THE EXPOSED OF THE WRAP STRIP LAYER APPROX. 3/4" FROM WALL SURFACE. AS PER UL LISTED 3M COMPANY CP25WB+, IC 15WB+, FIRE DAM 150+CAULK.
- PIPE COVERING INSULATION SHALL BE 2" THICK HOLLOW CYLINDRICAL HEAVY DENSITY GLASS FIBER UNITS JACKETED ON THE OUTSIDE WITH AN ALL SERVICE JACKETED. AS PER UL CLASSIFICATION AND MARKING WITH A FLAME SPREAD INDEX OF 25 OR LESS AND A SMOKE DEVELOPED INDEX OF 50 OR LESS MAY BE USED.

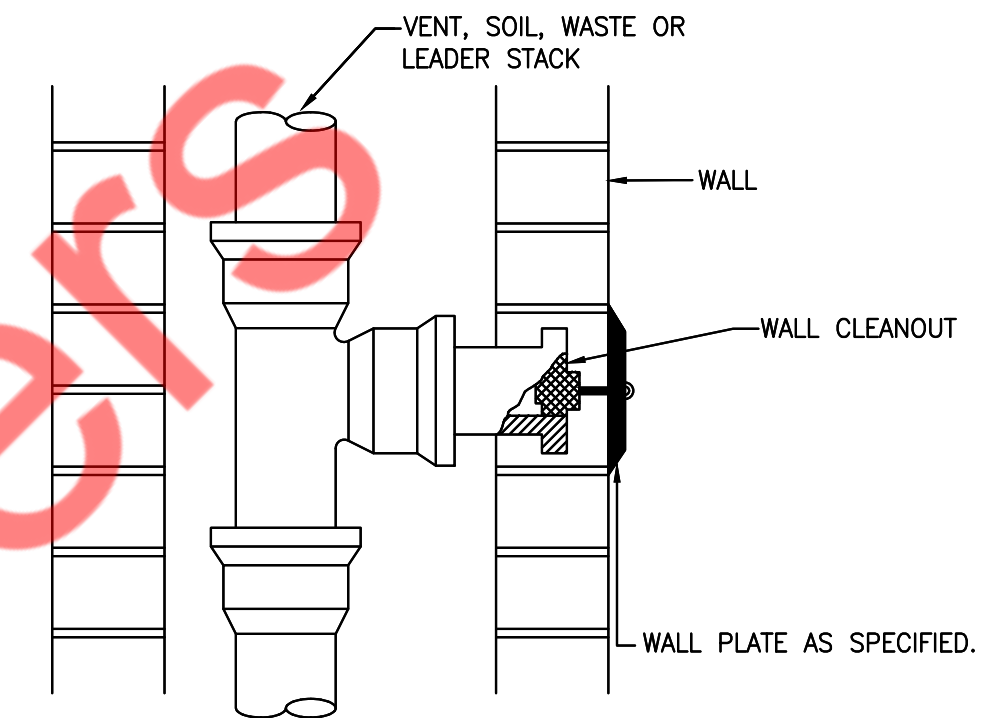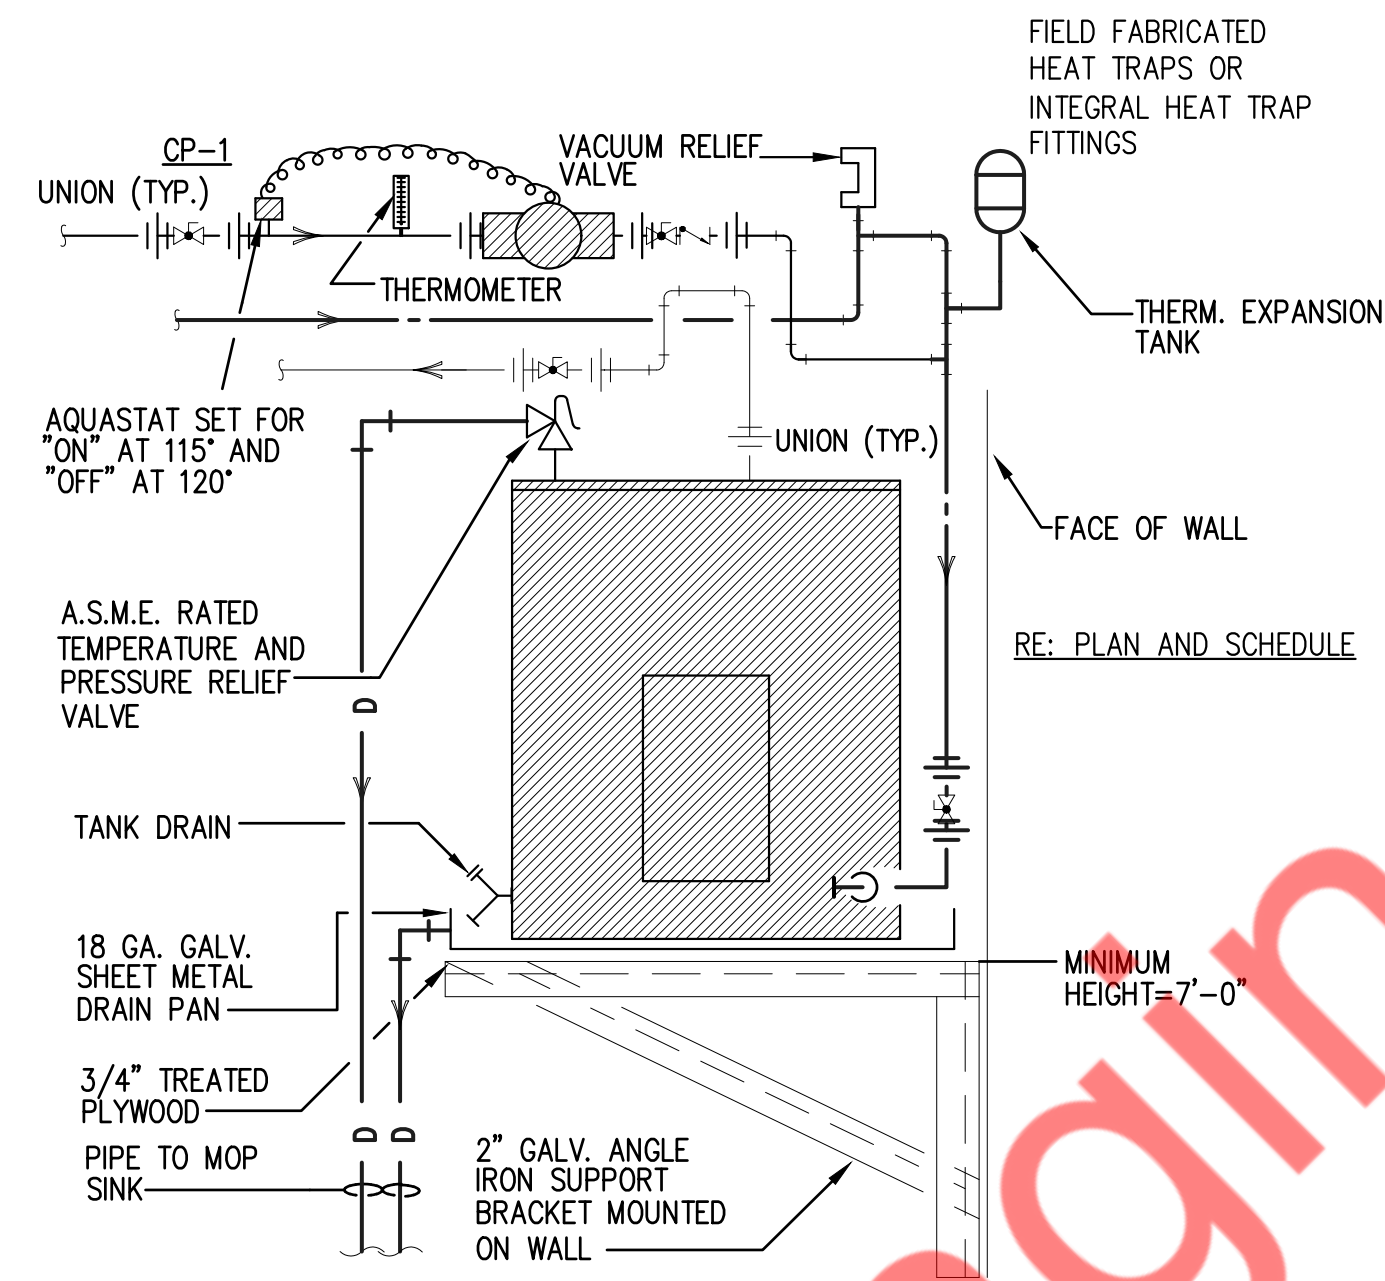


1 PIPE SLEEVE THRU WALL SECTION
P5.0 N.T.S

2 ELECTRIC WATER HEATER DETAILS
P5.0 N.T.S

3 WALL CLEANOUT DETAIL
P5.0 N.T.S

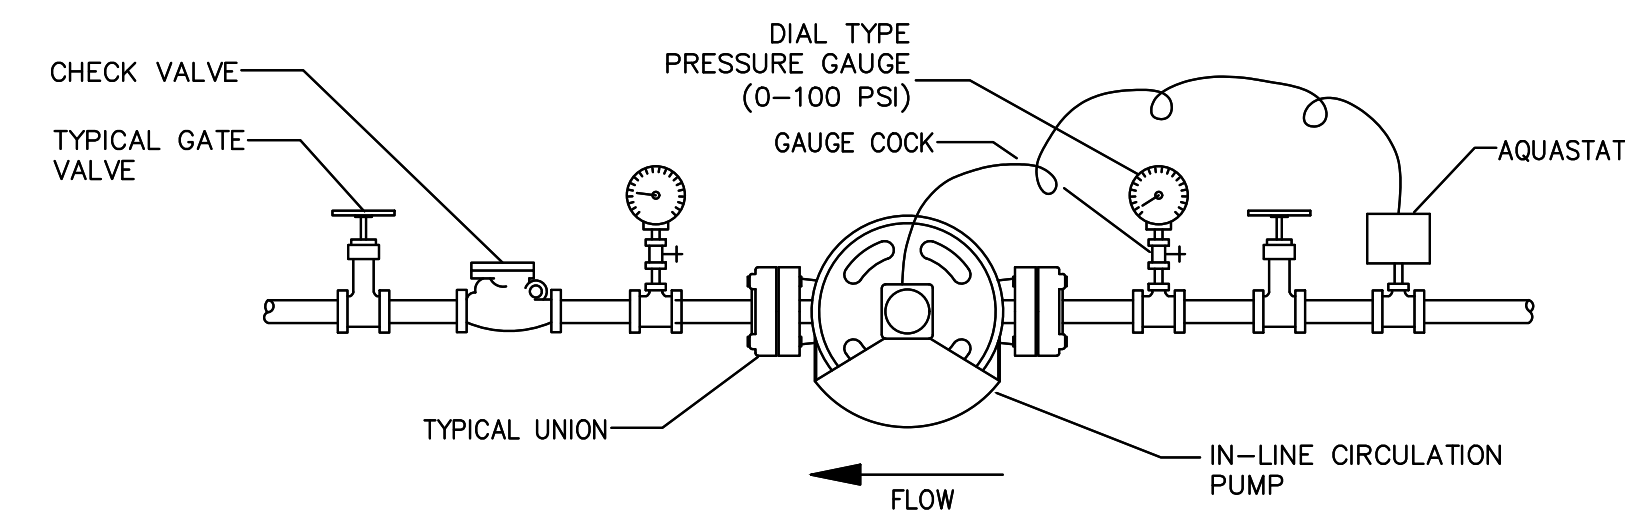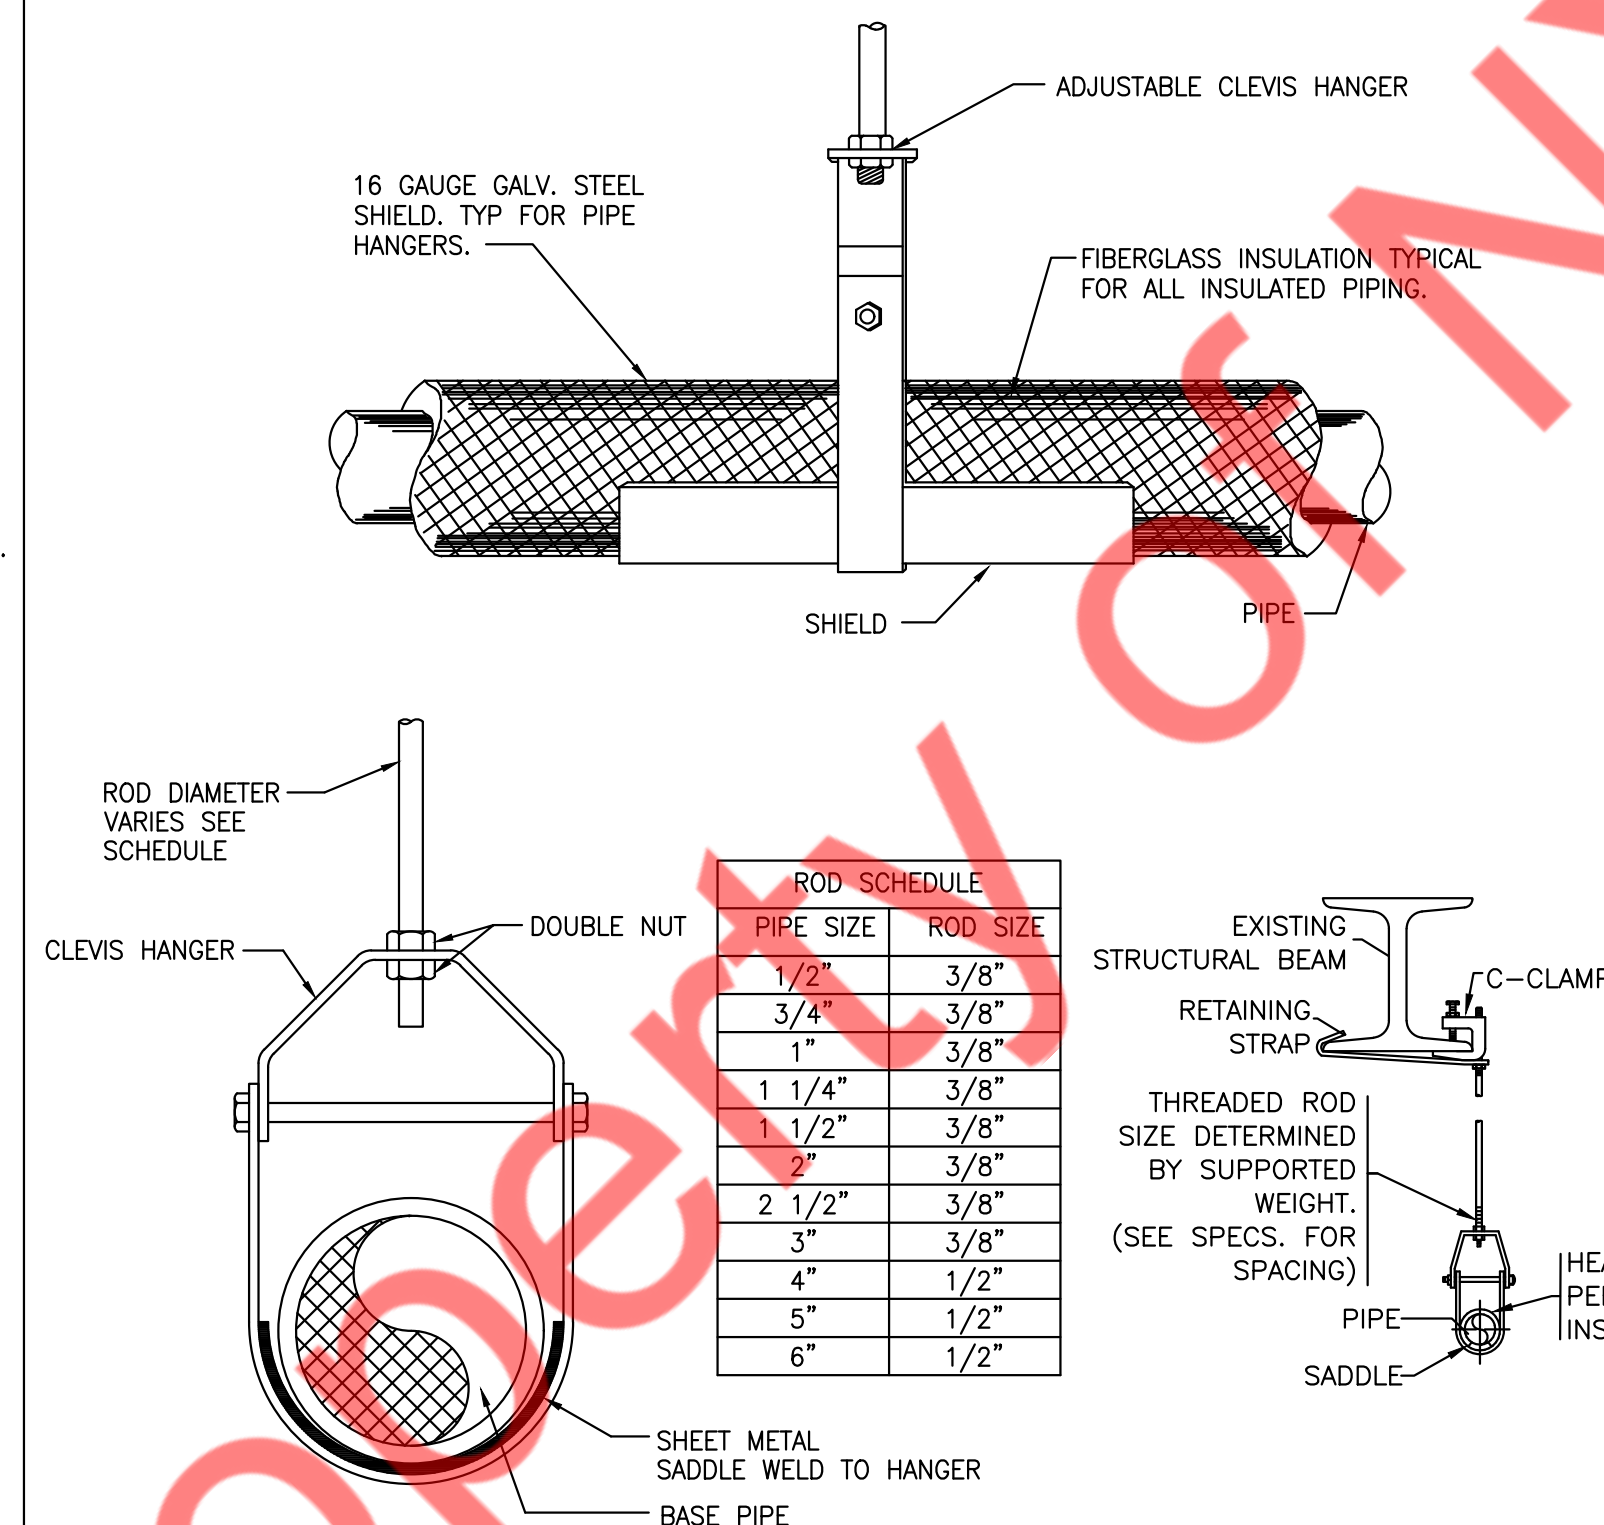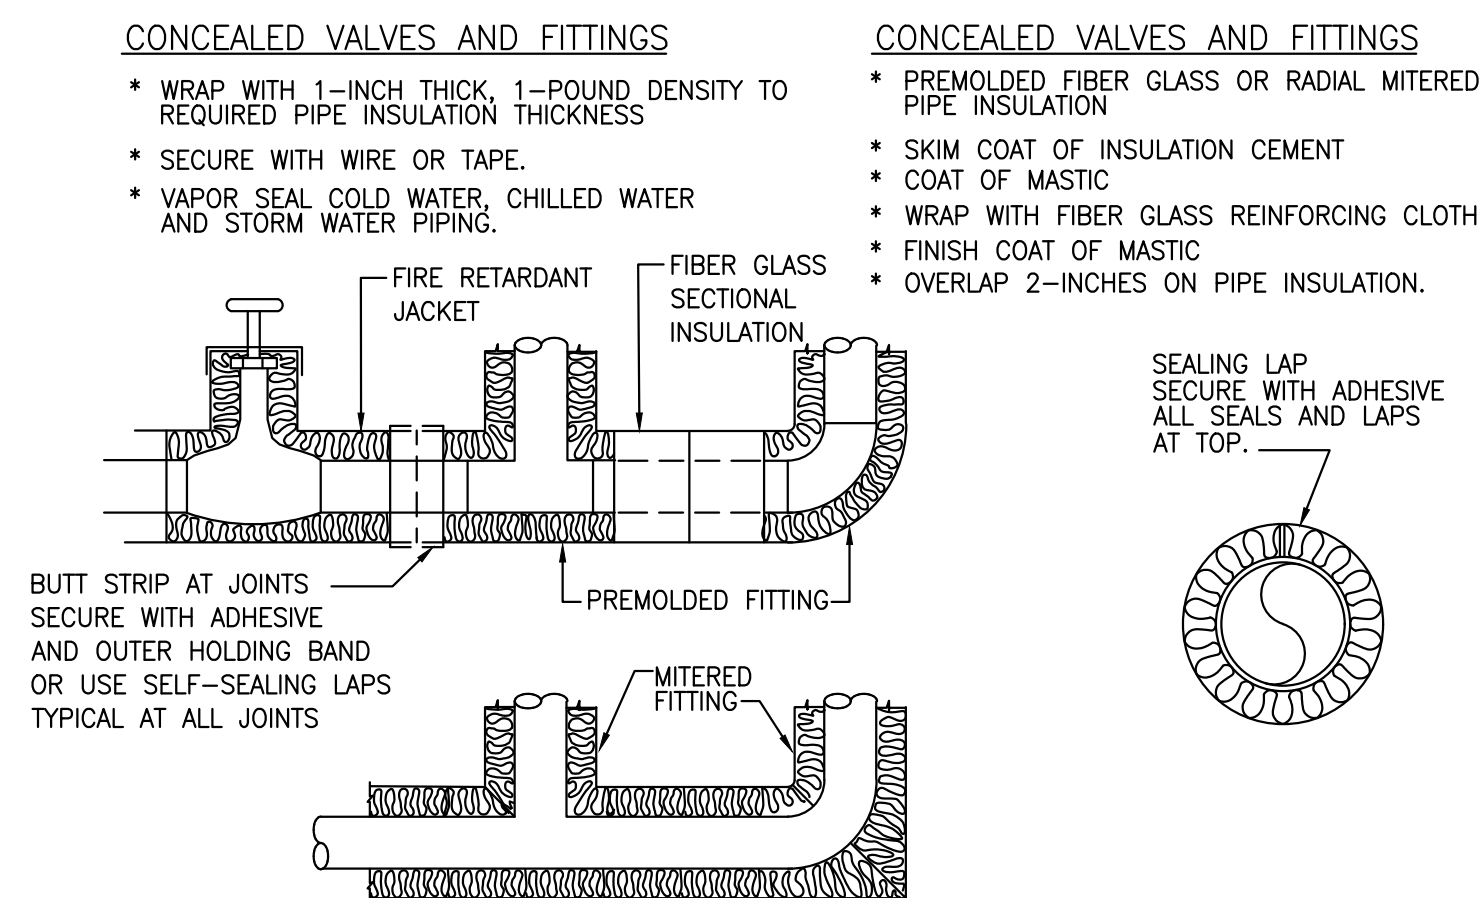

6 INLINE RECIRCULATING PUMP DETAIL
P5.0 N.T.S

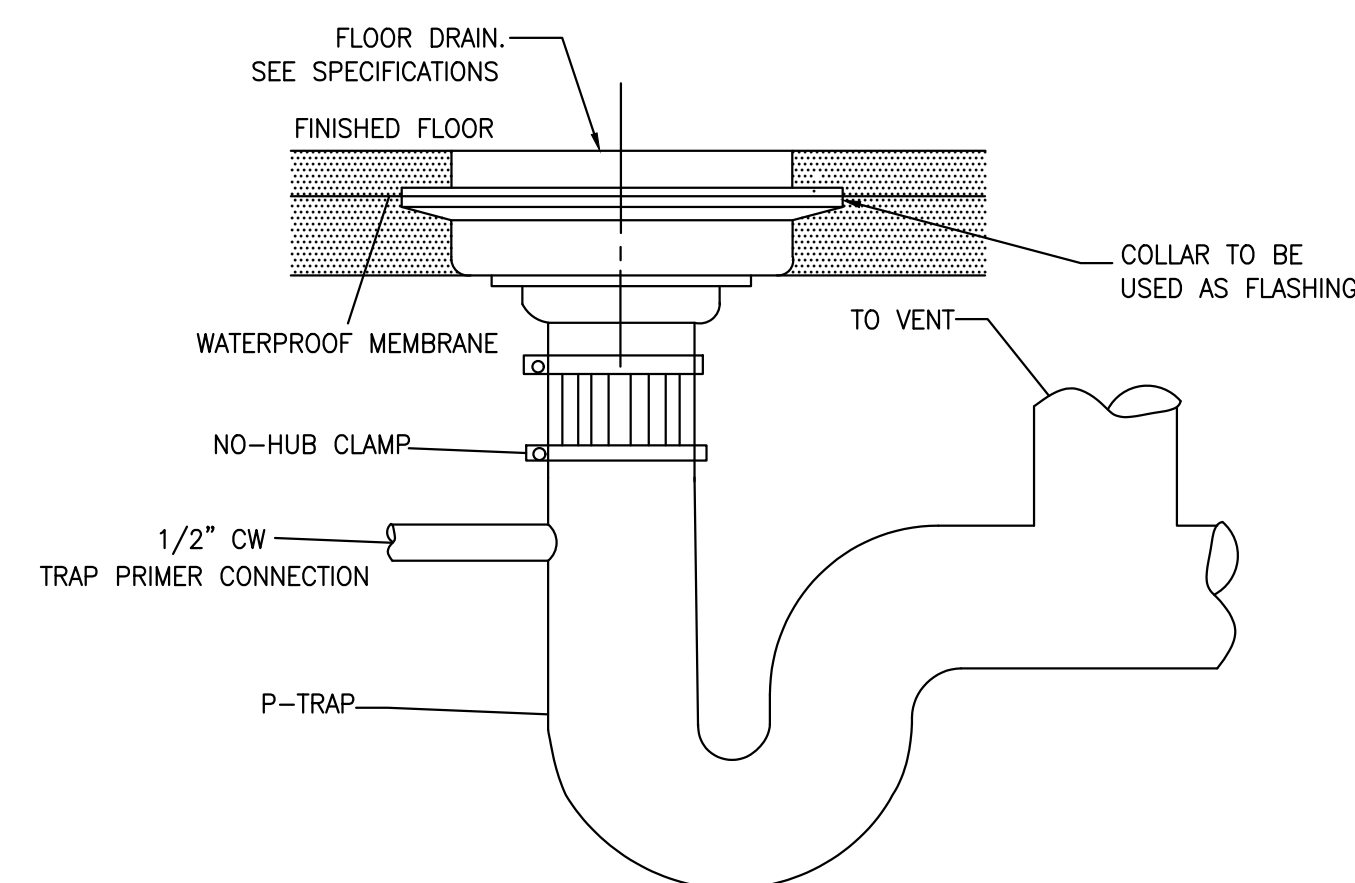

7 FLOOR DRAIN DETAIL
P5.0 N.T.S

4 INSULATION OF PIPING, VALVES AND FITTINGS FOR EXPOSED AND CONCEALED LOCATIONS
P5.0 N.T.S

5 HANGER DETAIL
P5.0 N.T.S

REVISION SCHEDULE
NO. REV. / SUBMISSION DATE ISSUED BY
PERMIT SET 06/21/22 NYE

ISSUE DATE: 4/6/2022 5:19:23 PM

RENOVATION
FOUR STAR
MUSHROOMS

DRAWN BY: NYE


QAQC:

APPROVED BY: NYE

PROJECT NUMBER: 2206


PLUMBING DETAILS

P5.0

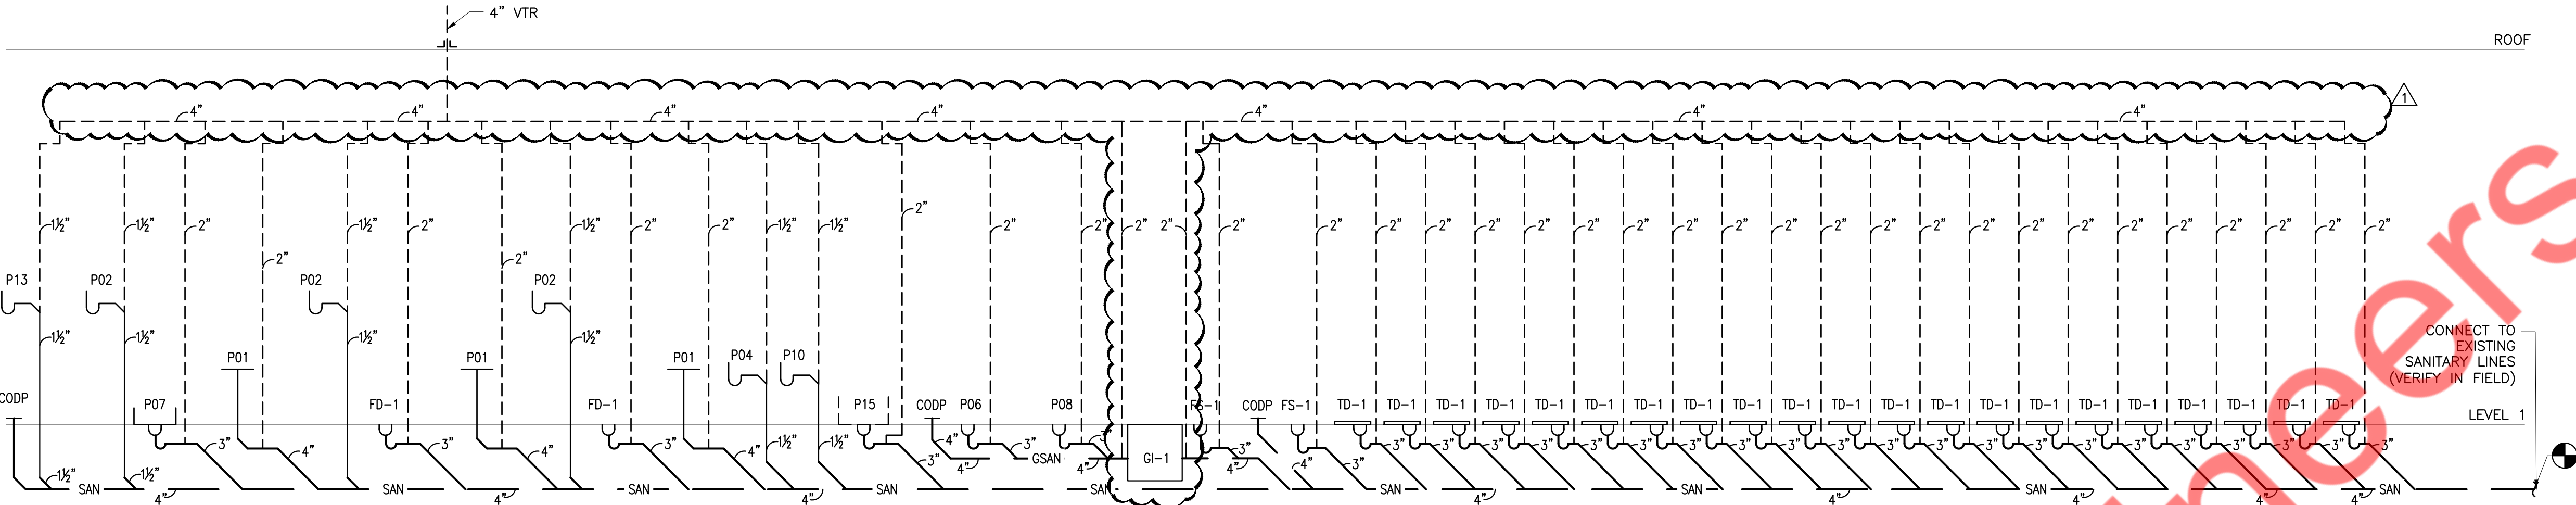


SANITARY RISER DIAGRAM
NOT TO SCALE

GAS PIPE SIZING PER TABLE 402.4(2), INTERNATIONAL FUEL GAS CODE
EQUIVALENT LENGTH OF PIPE = 29+38+76+43+10 = 196 + FITTINGS (+40%) = 275 FEET
EQUIVALENT LENGTH OF PIPE FOR GENERATOR = 46+35+21+10+7+15 = 134 + FITTINGS (+40%) = 188 FEET

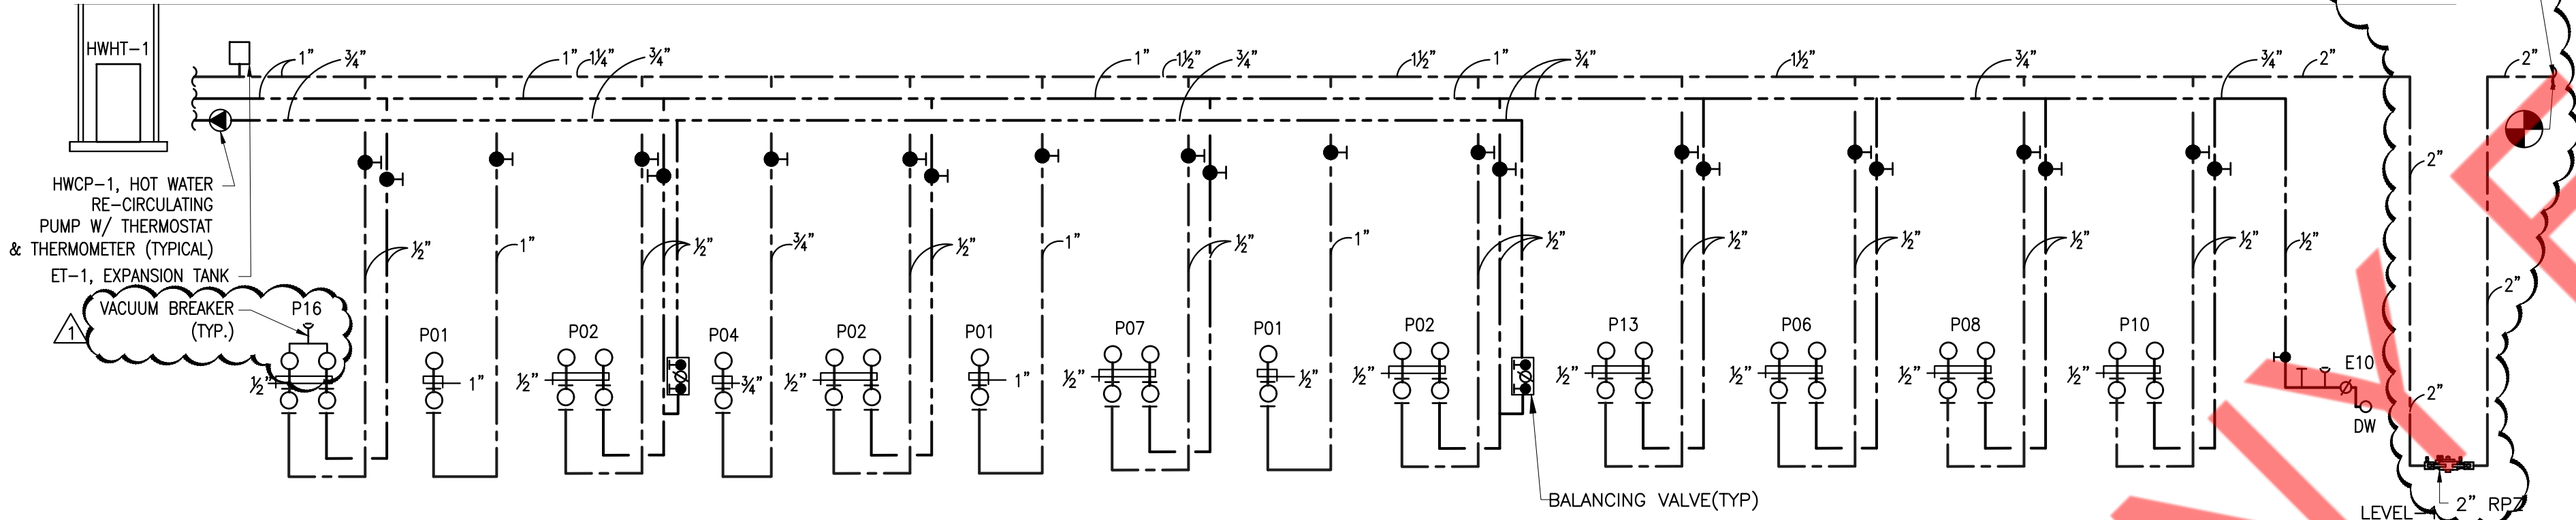

DOMESTIC WATER SUPPLY RISER DIAGRAM
NOT TO SCALE

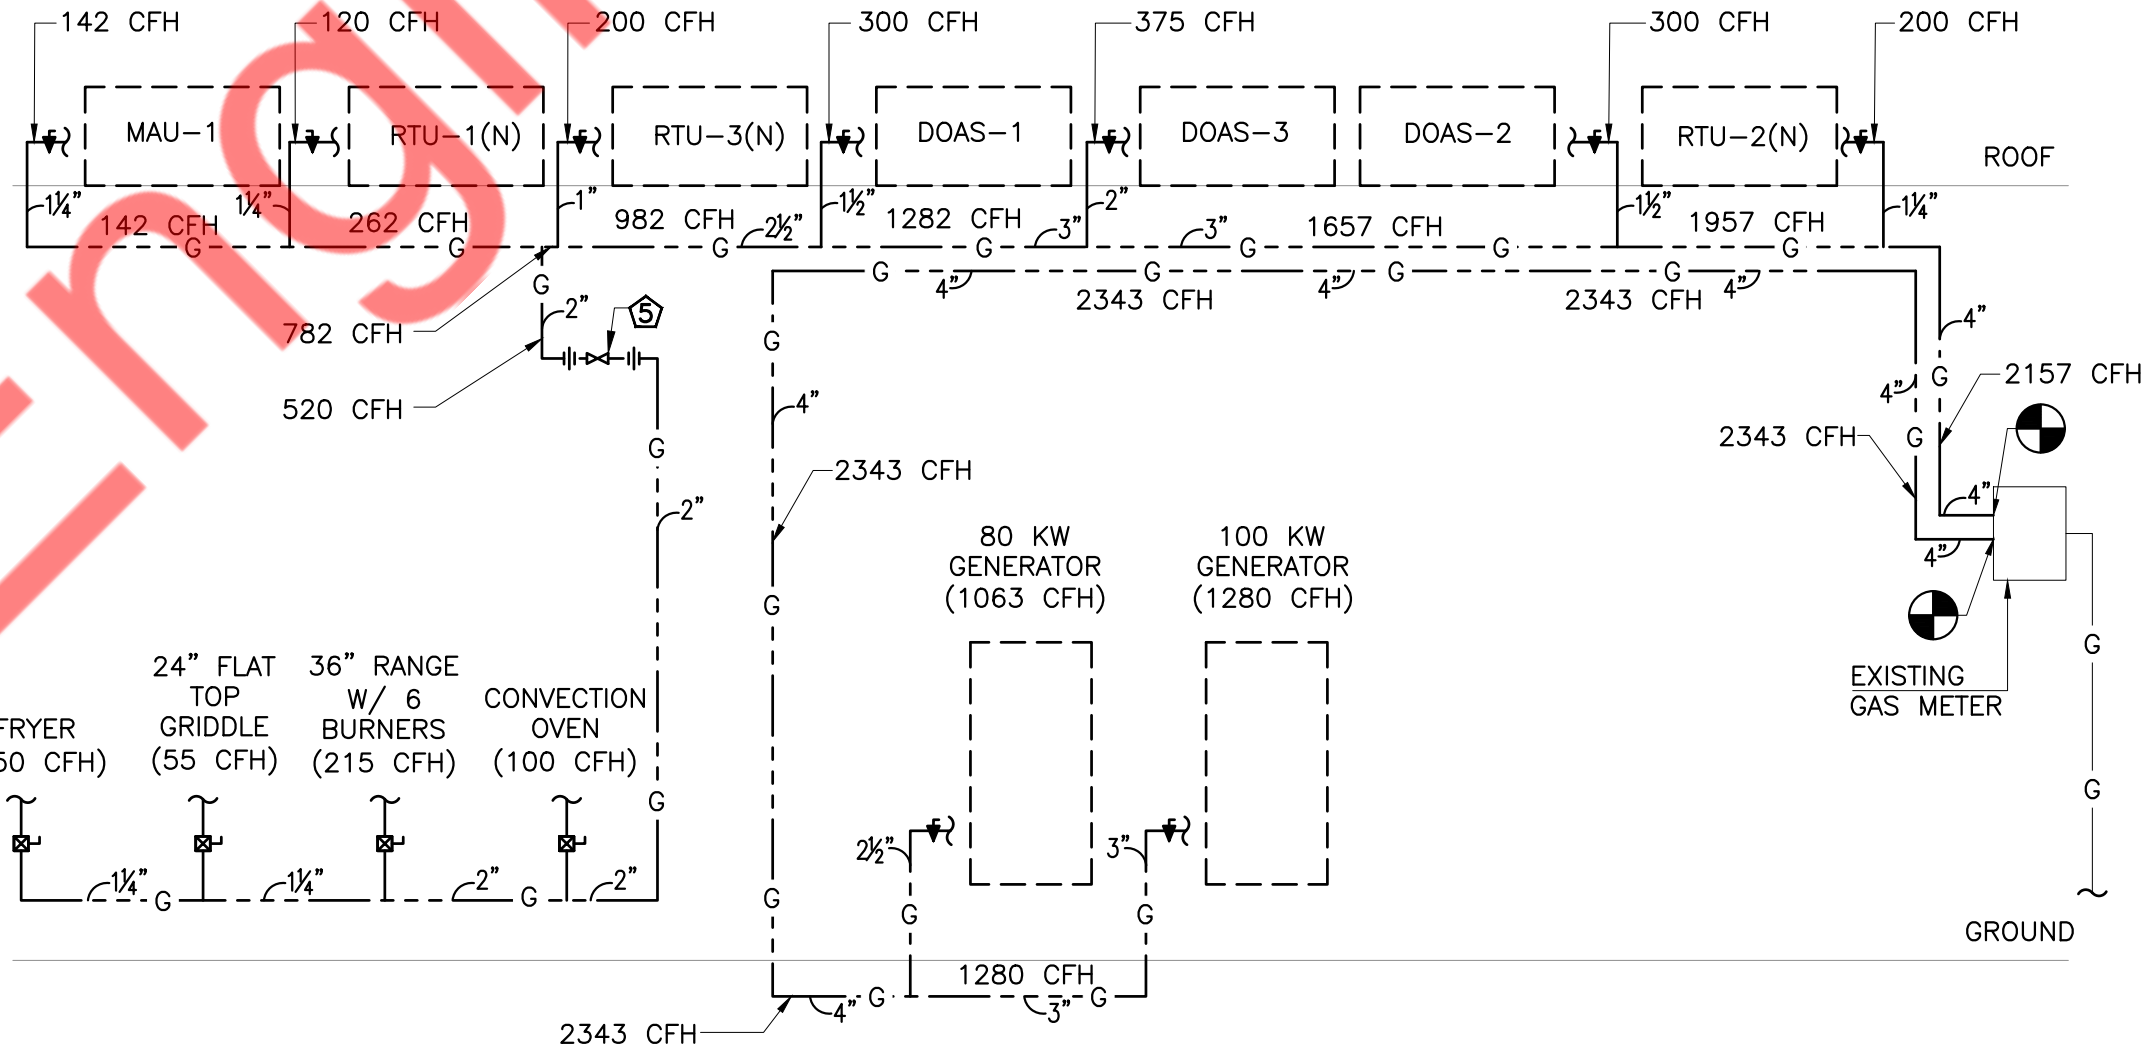

GAS RISER DIAGRAM
NOT TO SCALE

PLUMBING SCHUDULE								
FIXTURE	EQUIPMENT CATEGORY	MANUFACTURER	MODEL	SAN		VENT	CW	HW
				DIRECT	INDIRECT			
P01	WATER CLOSET	KHOLER CO.	K-96053-0	4"	-	2"	1"	-
P02	LAVATORY	KHOLER CO.	K-2032-N-0	1-1/2"	-	1-1/2"	-	-
P03	LAVATORY FAUCET	KHOLER CO.	K-400T20-4ANA	-	-	-	1/2"	1/2"
P04	URINAL	KHOLER CO.	K-5016-ER-0	2"	-	2"	3/4"	-
P05	3 COMP SINK FAUCET	ADVANCE TABCO	FC-3-1818-24RL	-	-	-	1/2"	1/2"
P06	3 COMP SINK	REGENCY	600FPRSFI2LL	-	2"	2"	-	-
P07	SHOWER	KHOLER CO.	K-98361-CP	-	-	-	1/2"	1/2"
P08	1-COMP SINK	ADVANCE TABCO	FC-1-1818-18L	2"	-	2"	-	-
P09	1-COMP SINK FAUCET	ADVANCE TABCO	K-101	-	-	-	1/2"	1/2"
P10	HAND SINK	REGENCY	600HS17SP	1-1/2"	-	1-1/2"	-	-
P11	HAND SINK FAUCET	REGENCY	600FW44GLL	-	-	-	1/2"	1/2"
P15	MOP SINK	MUSTEE	63M	3"	-	2"	-	-
P16	MOP SINK FAUCET	MUSTEE	63.600A	-	-	-	1/2"	1/2"
E10	DISHWASHER	HOBART	CUH	-	1-1/2"	-	-	1/2"
FS-1	FLOOR SINK	-	-	3"	-	2"	-	-
FD-1	FLOOR DRAIN	-	-	3"	-	2"	-	-
TD-1	TRENCH DRAIN	-	-	3"	-	2"	-	-
NOTE: ALL FIXTURE MAY BE SUBSTITUTED WITH APPROVED EQUAL. CONTACT OWNER FOR APPROVAL.								

ELECTRIC WATER HEATER SCHEDULE								
HEATER TAG	LOCATION	STORAGE GALLONS	FUEL TYPE	INPUT KW	RECOVERY RATE AT 100°F (GPH)	TYPE	MANUFACTURER & MODEL NO.	REMARKS
HWHT-1	ABOVE MOP SINK	80	ELECTRIC	12KW(3Ø, 240)	49	STORAGE ELECTRIC WATER HEATER (SHELF MOUNTED)	A.O. SMITH DEN-80	-DIMENSION 24" DIA X 60" H -INDOOR SHELF MOUNTED

EXPANSION TANK SCHEDULE						
TAG	LOCATION	SERVICE	CAPACITY (GALLONS)	MANUFACTURER & MODEL	DIMENSION (DIA X HEIGHT)	NO. OF EXPANSION TANK
ET-1	REFER FLOOR PLANS	HW	2	THERM-X-TROL ST-5	8" X 13"	1

RECIRCULATING PUMP SCHEDULE					
ITEM	QUANTITY	GPM	TOTAL HEAD(FT)	MOTOR HP	MANUFACTURER & MODEL NO
HWCP-1	1	2	10	0.115	GRUNDFOS UPS 15-18

FIXTURE UNIT CALCULATION								
FIXTURE	QTY	EQUIPMENT CATEGORY	UNITS PER FIXTURE			TOTAL		
			CW	HW	TOTAL	CW	HW	TOTAL
P01	3	WATER CLOSET	10	0	10	30	0	30
P02	3	LAVATORY	2	2	3	6	6	9
P04	1	URINAL	5	0	5	5	0	5
P06	1	3 COMP SINK	2	2	3	2	2	3
P07	1	SHOWER	4	4	6	4	4	6
P08	1	1-COMP SINK	2	2	3	2	2	3
P10	2	HAND SINK	1	1	1.5	2	2	3
P15	1	MOP SINK	3	3	4.5	3	3	4.5
E10	1	DISHWASHER	0	2	2	0	2	2
TOTAL FIXTURE UNITS						55.5	21	65.5
TOTAL FIXTURE UNITS 65.5 = 58.7 GPM								
WSFU VALUES AS PER CHICAGO PLUMBING CODE TABLE 18-29-604.10.1								
PER CHICAGO PLUMBING CODE, TABLE 18-29-604.10.2, 67 WSFU=58.7 GPM, FOR 58.7 GPM CALCULATED PIPE SIZE IS 2"								

GREASE INTERCEPTOR SIZING										
FIXTURE	QUANTITY	DIMENSIONS			VOLUME		PERCENTAGE USAGE(%)	ACTUAL USAGE (GALLONS)	FLOW RATE(GPM)	
		LENGTH(IN)	WIDTH(IN)	DEPTH(IN)	CUBIC INCHES	GALLONS			1 MIN.	2 MIN.
3 COMP SINK	1	18	18	14	13608	58.9	0.5	29.5	29.2	14.7
1 COMP SINK	1	18	18	14	4536	19.6	0.5	9.8	9.8	4.9
PROPOSED GREASE INTERCEPTOR, SCHIER MODEL GB-50								TOTAL:	39.3	19.64

GREASE INTERCEPTOR SCHEDULE						
ITEM	SERVICE	LOCATION	FLOW CAPACITY (GPM)	GREASE CAPACITY (LBS)	LIQUID CAPACITY (GALLON)	MANUFACTURER AND MODEL
GREASE INTERCEPTOR GI-1	KITCHEN WASTE	UNDER GROUND	50	249	35	SCHIER MODEL GB-50
NOTE- CONTRACTOR TO PROVIDE ALL REQUIRED ACCESSORIES FOR SATISFACTORY WORKING OF GREASE TRAP AS PER SITE CONDITIONS.						

GAS LOAD SUMMARY				
QTY.	DESCRIPTION	MANUFACTURER	MODEL	SIZE BTU/HR.
1	6 BURNER	VULCAN	365-6BN	215,000
1	2 BURNER	VULCAN	24RRG	55,000
1	FRYER	VULCAN	MPC 65	150,000
1	CONVECTION OVEN	VULCAN	VC6GGC	100,000
1	DOAS-1	CAPTIVEARE	CASRTU3-1.300-15-15T-DOAS	300,000
1	DOAS-2	CAPTIVEARE	CASRTU3-1.300-15-15T-DOAS	300,000
1	DOAS-3	CAPTIVEARE	CASRTU3-1.400-15-15T-DOAS	375,000
1	MAU-1	CAPTIVEARE	A1-D250-150-MPU	142,000
1	RTU-1(N)	TRANE	YHC036E3	120,000
1	RTU-2(N)	TRANE	YHC092F3	200,000
1	RTU-3(N)	TRANE	YHC102F3	200,000
1	100KW GENERATOR	GENERAC	SG100	1280,000
1	80KW GENERATOR	GENERAC	SG080	1063,000
TOTAL LOAD				4,500,000

REVISION SCHEDULE
NO. REV. / SUBMISSION DATE ISSUED BY
1 / 06/21/22 NYE

ISSUE DATE: 4/6/2022 5:19:23 PM

RENOVATION
FOUR STAR
MUSHROOMS

DRAWN BY: NYE

QAQC:

APPROVED BY: NYE

PROJECT NUMBER: 2206

PLUMBING RISERS
& SCHEDULES
P6.0